

2018 APPENDIX B BUILDING CODE SUMMARY

Name of Project: CRAVEN COUNTY GOVERNMENT CENTER EAST
Address: 1208 E. MAIN STREET, HAVELock, NORTH CAROLINA Zip Code: 28532
Owner/Authorized Agent: ZACH CHENOWETH
Phone # 252-617-7940 E-Mail: ZCHENOWETH@CRAVENCOUNTYNC.GOV
Owned By: City/County Private State
Code Enforcement Jurisdiction: City HAVELock County State

CONTACT: TIMOTHY D. OAKLEY, ARCHITECT
DESIGNER FIRM NAME LICENSE# TELEPHONE# E-MAIL
Architectural OAKLEY COLLIER ARCHITECTS TIM OAKLEY 5967 252-937-2500 TOAKLEY@OAKLEYCOLLIER.COM
Civil CRAVEN COUNTY JOE DUNNEHOOD --- JOSEPH.DUNNEHOOD@CRAVENCOUNTYNC.GOV
Electrical IMEG CORPORATION PATRICK MCCABE 51195 919-571-1111 PATRICK.J.MCCABE@IMEG.CORP.COM
Fire Alarm
Plumbing IMEG CORPORATION PATRICK MCCABE 51195 919-571-1111 PATRICK.J.MCCABE@IMEG.CORP.COM
Mechanical IMEG CORPORATION PATRICK MCCABE 51195 919-571-1111 PATRICK.J.MCCABE@IMEG.CORP.COM
Sprinkler-Standpipe
Structural SCALENE DESIGN ROBERT MACIA 026690 919-825-0295 RMACIA@SCALENE-DESIGN.COM
Retaining Walls >5' High
Other
(“Other” should include firms and individuals such as truss, precast, pre-engineered, interior designers, etc.)

2018 NC BUILDING CODE: New Building Addition Renovation
1st Time Interior Completion
Shell/Core - Contact the local inspection jurisdiction for possible additional procedures and requirements
Phased Construction - Shell/Core - Contact the local inspection jurisdiction for possible additional procedures and requirements

2018 NC EXISTING BUILDING CODE: Existing Prescriptive Repair Chapter 14
Alteration Level I Level II Level III
Historic Property Change of Use

CONSTRUCTED: (date) 1981 CURRENT OCCUPANCY(S) (Ch.3): BUSINESS
RENOVATED: (date) N/A PROPOSED OCCUPANCY(S) (Ch.3): BUSINESS
Risk Category (Table 1604.5): Current: I II III IV
Proposed: I II III IV

BASIC BUILDING DATA
Construction Type: I-A I-B II-A II-B III-A III-B IV V-A V-B
Sprinklers: No Partial Yes NFPA 13 NFPA 13R NFPA 13D
Standpipes: No Yes Class I II III Wet Dry
Fire District: No Yes Flood Hazard Area: No Yes
Special Inspections Required: No Yes (Contact the local inspection jurisdiction for additional procedures and requirements.)

FLOOR	EXISTING (SQ FT)	ADDITION (SQ FT)	SUB-TOTAL
6th Floor			
5th Floor			
4th Floor			
3rd Floor			
2nd Floor	3,274	0	3,274
1st Floor	7,207	0	7,207
Basement			
TOTAL	10,481	0	10,481

ALLOWABLE AREA
Primary Occupancy Classification(s):
Assembly A-1 A-2 A-3 A-4 A-5
Business
Educational
Factory F-1 Moderate F-2 Low
Hazardous H-1 Detonate H-2 Deflagrate H-3 Combust H-4 Health H-5 HPM
Institutional I-1 Condition I 2
I-2 Condition I 2
I-3 Condition I 2 3 4 5
I-4
Mercantile
Residential R-1 R-2 R-3 R-4
Storage S-1 Moderate S-2 Low High-piled
Parking Garage Open Enclosed Repair Garage
Utility and Miscellaneous

Accessory Occupancy Classification(s): N/A
Incidental Uses (Table 509): N/A
Special Uses (Chapter 4 - List Code Sections): N/A
Special Provisions: (Chapter 5 - List Code Sections): N/A
Mixed Occupancy: No Yes Separation: 0 Hr. Exception:
Non-Separated Use (508.3) - The required type of construction for the building shall be determined by applying the height and area limitations for each of the applicable occupancies to the entire building. The most restrictive type of construction, so determined, shall apply to the entire building.
Separated Use (508.4) - See below for area calculations for each story. The area of the occupancy shall be such that the sum of the ratios of the actual floor area of each use divided by the allowable floor area for each use shall not exceed 1:

Actual Area of Occupancy A + Actual Area of Occupancy B ≤ 1
Allowable Area of Occupancy A Allowable Area of Occupancy B
+ + ... = ≤ 1.00

STORY NO.	DESCRIPTION AND USE	(A) BLDG AREA PER STORY (ACTUAL)	(B) TABLE 506.2 AREA ¹	(C) AREA FOR FRONTAGE INCREASES ^{2,3}	(D) ALLOWABLE AREA PER STORY OR UNLIMITED ³

1. Frontage area increases from Section 506.3 are computed thus:
a. Perimeter which fronts a public way or open space having 20 feet minimum width = N/A (F)
b. Total Building Perimeter = N/A (P).
c. Ratio (F/P) = N/A (F/P)
d. W = Minimum width of public way = N/A (W)
e. Percent of frontage increase $f = 100[F/P - 0.25] \times W/30 =$ N/A (%).
2. Unlimited area applicable under conditions of Section 507.
3. Maximum Building Area = total number of stories in the building x D (maximum 3 stories) (506.2).
4. The maximum area of open parking garages must comply with Table 406.5.4.
5. Frontage increase is based on the unsprinklered area value in Table 506.2.

	ALLOWABLE	SHOWN ON PLANS	CODE REFERENCE 1
Building Height in Feet (Table 504.3) 2	55' - 0"	28' - 6 1/2"	N/A
Building Height in Stories (Table 504.4) 3	3	2	N/A

1. Provide code reference if the “Shown on Plans” quantity is not based on Table 504.3 or 504.4.
2. The maximum height of air traffic towers must comply with Table 412.3.1.
3. The maximum height of open parking garages must comply with Table 406.5.4.

BUILDING ELEMENT	FIRE SEPARATION DISTANCE (FEET)	RATING REQ'D	PROVIDED (W/ REDUCTION)	DETAIL# AND SHEET#	DESIGN# FOR RATED ASSEMBLY	SHEET# FOR RATED PENETRATION	SHEET# FOR RATED JOINTS
Structural Frame, including columns, girders, trusses	>30	0	0	N/A	N/A	N/A	N/A
Exterior Bearing Walls							
North	>30	0 HR	-	-	-	-	-
East	>30	0 HR	-	-	-	-	-
West	>30	0 HR	-	-	-	-	-
South	>30	0 HR	-	-	-	-	-
Interior Bearing Walls							
Exterior Non-bearing Walls and Partitions							
North	>30	0 HR	-	-	-	-	-
East	>30	0 HR	-	-	-	-	-
West	>30	0 HR	-	-	-	-	-
South	>30	0 HR	-	-	-	-	-
Interior Non-bearing Walls and Partitions							
		0 HR	-	-	-	-	-
Floor Construction, Including Supporting Beams and Joists		0 HR	-	-	-	-	-
Floor Ceiling Assembly		0 HR	-	-	-	-	-
Columns Supporting Floors		0 HR	-	-	-	-	-
Roof Construction, Including Supporting Beams and Joists		0 HR	-	-	-	-	-
Roof Ceiling Assembly		0 HR	-	-	-	-	-
Columns Supporting Roof		0 HR	-	-	-	-	-
Shaft Enclosures - Exit		1 HR	-	-	-	-	-
Shaft Enclosures - Other		1 HR	-	-	-	-	-
Corridor Separation		1 HR	-	-	-	-	-
Occupancy/Fire Barrier Separation	NA	-	-	-	-	-	-
Party/Fire Wall Separation	NA	-	-	-	-	-	-
Smoke Barrier Separation	NA	-	-	-	-	-	-
Smoke Partition	NA	-	-	-	-	-	-
Tenant/Dwelling Unit/Sleeping Unit Separation	NA	-	-	-	-	-	-
Incidental Use Separation	NA	-	-	-	-	-	-

* Indicates section number permitting reduction.

FIRE SEPARATION DISTANCE (FEET) FROM PROPERTY LINES	DEGREE OF OPENINGS PROTECTION (TABLE 705.4)	ALLOWABLE AREA (%)	ACTUAL SHOWN ON PLANS (%)
30 OR GREATER	UP, NS	NO LIMIT	N/A

LIFE SAFETY SYSTEM REQUIREMENTS
Emergency Lighting: No Yes
Exit Signs: No Yes
Fire Alarm: No Yes
Smoke Detection Systems: No Yes Partial
Carbon Monoxide Detection: No Yes

- LIFE SAFETY PLAN REQUIREMENTS
Life Safety Plan Sheet #: G1.1
Fire and/or smoke rated wall locations (Chapter 7).
Assumed and real property line locations (if not on the site plan).
Exterior wall opening area with respect to distance to assumed property lines (705.8).
Occupancy Use for each area as it relates to occupant load calculation (Table 1004.1.2).
Occupant loads for each area.
Exit access travel distances (1017).
Common path of travel distances (Tables 1006.2.1 & 1006.3.2)(1).
Dead end lengths (1020.4).
Clear exit widths for each exit door.
Maximum calculated occupant load capacity each exit door can accommodate based on egress width (1005.3).
Actual occupant load for each exit door.
A separate schematic plan indicating where fire rated floor/ceiling and/or roof structure is provided for purposes of occupancy separation.
Location of doors with panic hardware (1010.1.10).
Location of doors with delayed egress locks and the amount of delay (1010.1.9.7).
Location of doors with electromagnetic egress locks (1010.1.9.9).
Location of doors equipped with hold-open devices.
Location of emergency escape windows (1030).
The square footage of each fire area (202).
The square footage of each smoke compartment for Occupancy Classification 1-2 (407.5).
Code exceptions or table notes that may have been utilized regarding the items above.

ACCESSIBLE DWELLING UNITS (SECTION 1107)							
TOTAL UNITS	ACCESSIBLE UNITS REQUIRED	ACCESSIBLE UNITS PROVIDED	TYPE A UNITS REQUIRED	TYPE A UNITS PROVIDED	TYPE B UNITS REQUIRED	TYPE B UNITS PROVIDED	TOTAL ACCESSIBLE UNITS PROVIDED
N/A	N/A	N/A	N/A	N/A	N/A	N/A	N/A

ACCESSIBLE PARKING						
(SECTION 1106)						
LOT OR PARKING AREA	TOTAL # OF PARKING SPACES		# OF ACCESSIBLE SPACES PROVIDED			TOTAL # ACCESSIBLE PROVIDED
	REQUIRED	PROVIDED	REGULAR WITH 9' ACCESS AISLE	VAN SPACES WITH 132" ACCESS AISLE	8' ACCESS AISLE	
			EXISTING TO REMAIN			
TOTAL						

PLUMBING FIXTURE REQUIREMENTS (TABLE 2902.1)									
USE	WATER CLOSETS			URINALS			LAVATORIES	SHOWERS	DRINKING FOUNTAINS
	MALE	FEMALE	UNSEX	MALE	FEMALE	UNSEX	TUBS	REGULAR	ACCESSIBLE
EXISTING									
NEW REQ'D	5	5	-	5	5	-		N/A	N/A
	3	3	-	3	3	-		1	1

SPECIAL APPROVALS
Special approval: (Local Jurisdiction, Department of Insurance, OSC, DPI, DHHS, etc., describe below)

ENERGY SUMMARY	SEE SHEET E000 . For detailed code compliance.
----------------	---

ENERGY REQUIREMENTS:
The following data shall be considered minimum and any special attribute required to meet the energy code shall also be provided. Each Designer shall furnish the required portions of the project information for the plan data sheet. If performance method, state the annual energy cost for the standard reference design vs annual energy cost for the proposed design.

Existing building envelope complies with code: No Yes (The remainder of this section is not applicable)

Exempt Building: No Yes (Provide code or statutory reference)
Climate Zone: 3A 4A 5A
Method of Compliance: Energy Code Performance Prescriptive
ASHRAE 90.1 Performance Prescriptive
(If "Other" specify here)

THERMAL ENVELOPE (Prescriptive method only)
Roof/ceiling Assembly (each assembly)
Description of assembly: EXISTING
U-Value of total assembly: N/A
R-Value of insulation: R-25
Skylights in each assembly: N/A
U-Value of skylight: N/A
Total square footage of skylights in each assembly: N/A
Exterior Walls (each assembly)
Description of assembly: EXISTING
U-Value of total assembly: N/A
R-Value of insulation: N/A
Openings (windows or doors with glazing)
U-Value of assembly: N/A
Solar heat gain coefficient: N/A
Projection factor: N/A
Door R-Values: N/A
Walls below grade (each assembly)
Description of assembly: N/A
U-Value of total assembly: N/A
R-Value of total assembly: N/A
Floors over unconditioned space (each assembly)
Description of assembly: N/A
U-Value of total assembly: N/A
R-Value of total assembly: N/A
Floors slab on grade
Description of assembly: EXISTING
U-Value of total assembly: N/A
R-Value of insulation: N/A
Horizontal/vertical requirement: N/A
Slab heated: N/A

STRUCTURAL DESIGN
DESIGN LOADS:
Importance Factors: Snow N/A (Is)
Seismic N/A (Ie)
Live Loads: Roof N/A psf
Mezzanine N/A psf
Floor N/A psf
Ground Snow Load: N/A psf
Wind Load: Ultimate Wind Speed N/A mph (ASCE-7)
Exposure Category N/A


SEISMIC DESIGN CATEGORY: A B C D
Provide the following Seismic Design Parameters:
Risk Category (Table 1604.5): I II III IV
Spectral Response Acceleration: Ss N/A %g S1 N/A %g
Site Classification (ASCE 7): A B C D E F
Data Source: Field Test Presumptive Historical Data
Basic Structural System: Bearing Wall Dual w/Special Moment Frame
Building Frame Dual w/Intermediate R/C or Special Steel
Moment Frame Inverted Pendulum
Simplified Equivalent Lateral Force Dynamic
Analysis Procedure: Architectural, Mechanical, Components anchored: Yes No
LATERAL DESIGN CONTROL: Earthquake Wind
SOIL BEARING CAPACITIES:
Field Test (provide copy of test report): N/A psf
Presumptive Bearing Capacity: N/A psf
Pile Size, Type, and Capacity: N/A

MECHANICAL DESIGN
SEE SHEET M000 .
For detailed code compliance.
MECHANICAL SYSTEMS, SERVICE SYSTEMS AND EQUIPMENT
Thermal Zone N/A
Exterior Design Conditions
Winter dry bulb: N/A
Summer dry bulb: N/A
Relative humidity: N/A
Interior Design Conditions
Winter dry bulb: N/A
Summer dry bulb: N/A
Relative humidity: N/A
Building Heating Load: N/A
Building Cooling Load: N/A
Mechanical Spacing Conditioning System
Unitary
Description of unit: N/A
Heating efficiency: N/A
Cooling efficiency: N/A
Size category of unit: N/A
Boiler
Size category, if oversized, state reason: N/A
Chiller
Size category, if oversized, state reason: N/A
List equipment efficiencies: N/A

ELECTRICAL DESIGN
SEE SHEET E000 .
For detailed code compliance.
ELECTRICAL SYSTEM AND EQUIPMENT
Method of Compliance: Energy Code: Prescriptive Performance
ASHRAE 90.1: Prescriptive Performance
Lighting Schedule (each fixture type)
Lamp type required in fixture: N/A
Number of lamps in fixture: N/A
Ballast type used in the fixture: N/A
Number of ballasts in fixture: N/A
Total wattage per fixture: N/A
Total interior wattage specified vs. allowed (whole building or space by space): N/A
Total exterior wattage specified vs. allowed: N/A
Additional Efficiency Package Options
(When using the 2018 NCECC; not required for ASHRAE 90.1)
C406.2 More Efficient HVAC Equipment Performance
C406.3 Reduced Lighting Power Density
C406.4 Enhanced Digital Lighting Controls
C406.5 On-Site Renewable Energy
C406.6 Dedicated Outdoor Air System
C406.7 Reduced Energy Use in Service Water Heating



RENOVATION FOR:
CRAVEN COUNTY GOVERNMENT CENTER
EAST
CRAVEN COUNTY
1208 E. MAIN STREET, HAVELock, NORTH CAROLINA 28532

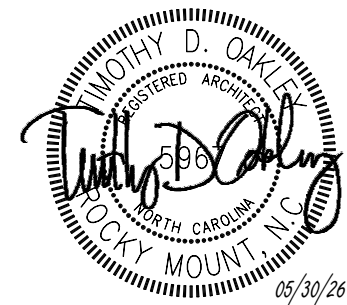


GENERAL NOTE:
Prior to construction start. Contractor shall verify & be responsible for all Dimensions.

Revisions	Description	Date
-----------	-------------	------


Date MAY 30 2028	Project No. 25012
Drawn By ACR	Sheet No. G0.2
Checked By DG	Sheet Title BUILDING CODE SUMMARY

NOTE:
BASIS OF DESIGN ARCHITECTURAL SERIES MODEL AL2409-R4 SEMI RECESSED FULL PANEL DOOR WITH CLEAR ACRYLIC GLAZING, 31/2" ROLLED EDGE TRIM, VERTICAL DIE CUT RED LETTERING, WHITE BAKED ENAMEL INTERIOR BOX AS MANUFACTURED BY LARSEN'S MANUFACTURING COMPANY OR APPROVED EQUAL.

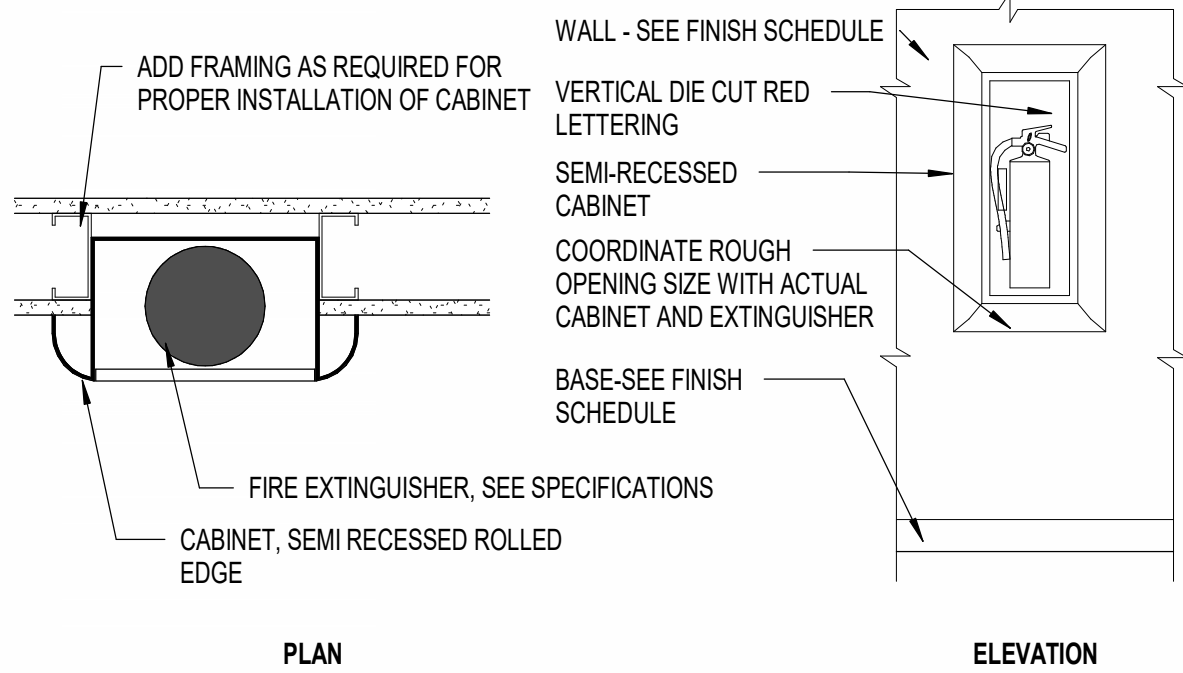


3 SEMI RECESSED FEC

1 1/2" = 1'-0"

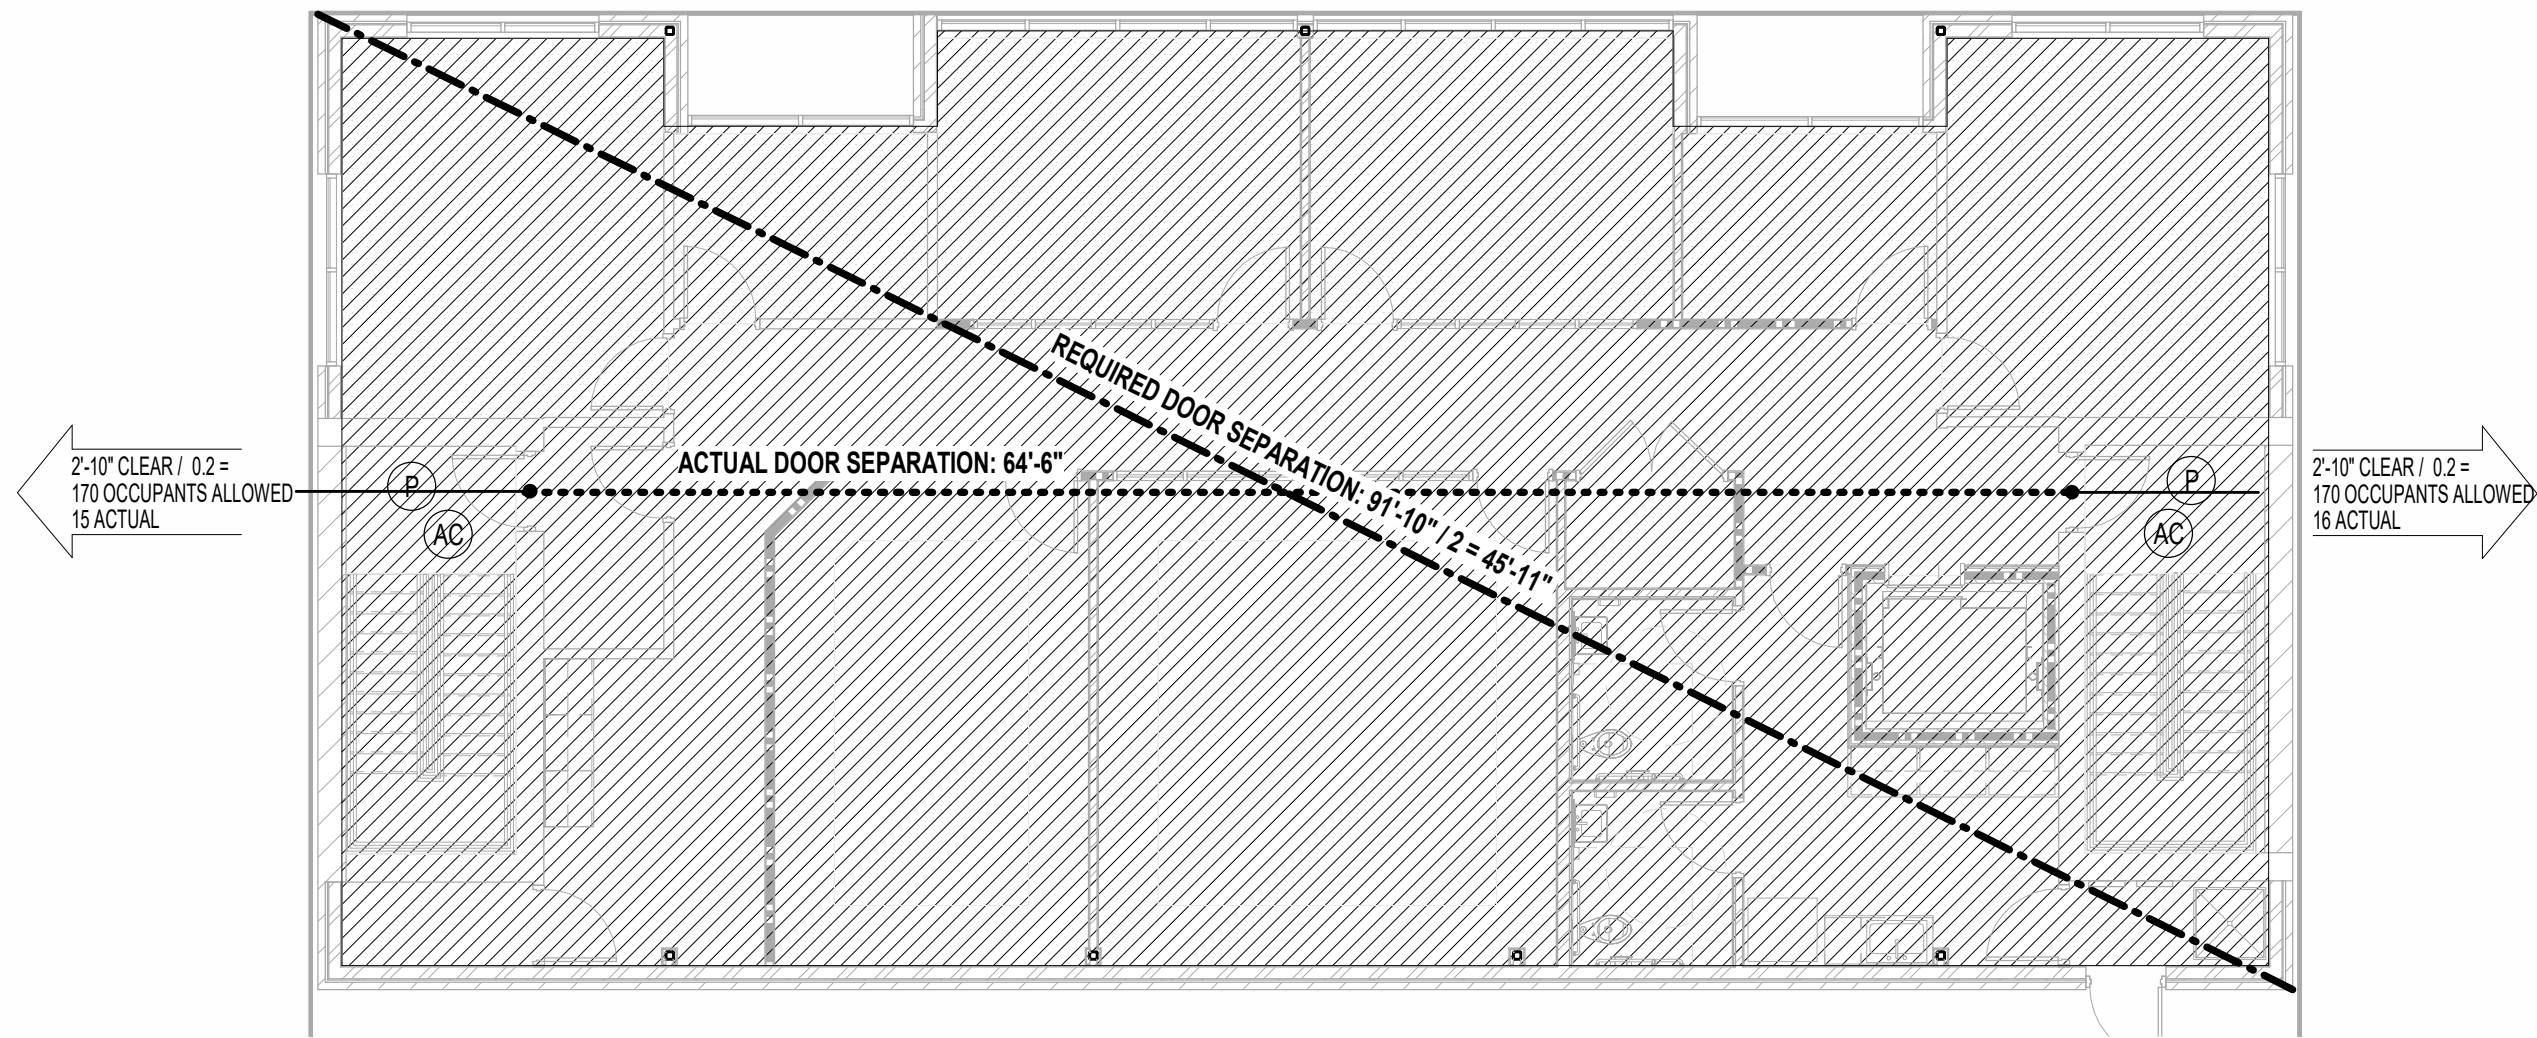

1 SECOND FLOOR LIFE SAFETY PLAN

1/8" = 1'-0"

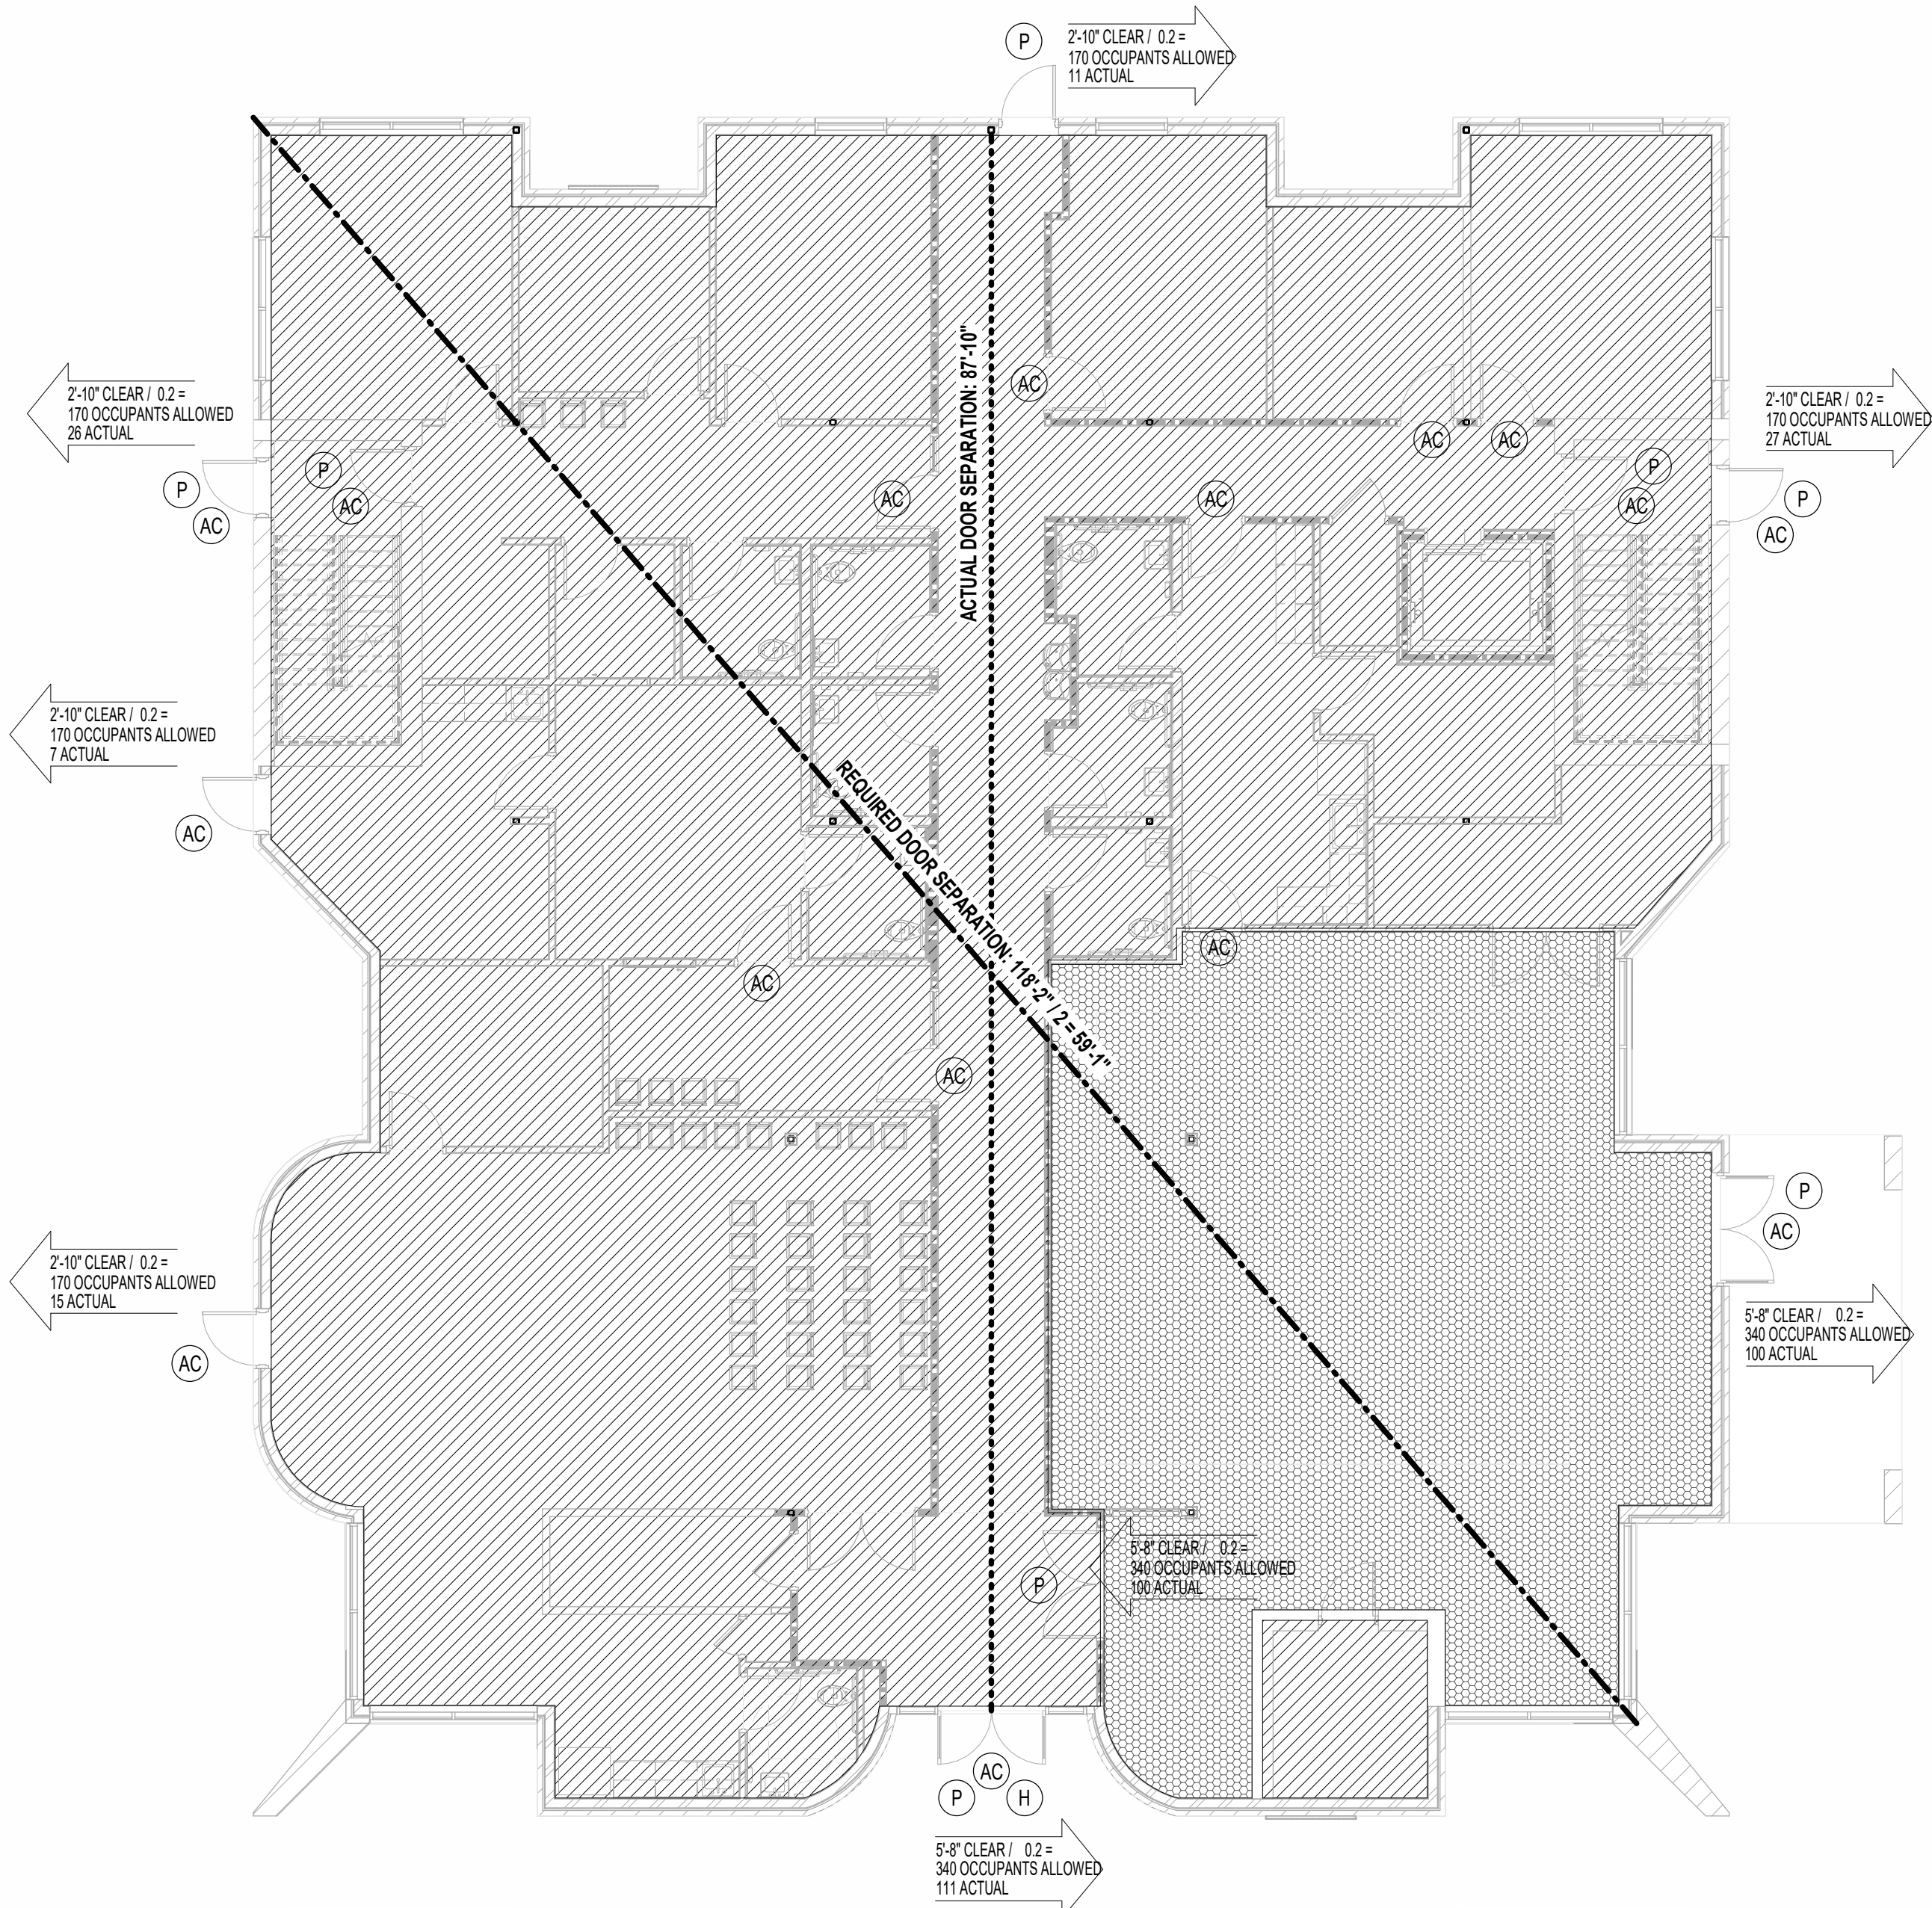

2 FIRST FLOOR LIFE SAFETY PLAN

1/8" = 1'-0"

LIFE SAFETY LEGEND

XX" DOOR / 0.2"	EGRESS WIDTH	X	OCCUPANCY
XXX OCC. ALLOWED	EGRESS CAPACITY FACTOR	XXX	SQUARE FEET OF ROOM
XXX ACTUAL	EGRESS CAPACITY ALLOWED	XX	OCCUPANT LOAD
	ANTICIPATED EGRESS LOAD		OCCUPANT LOAD FACTOR
---	EXIT SEPARATION DISTANCE - REQUIRED	⊗	EXIT SIGN
---	EXIT SEPARATION DISTANCE - PROVIDED	⊗	EXIT SIGN / EMERGENCY LIGHT
---	MAXIMUM TRAVEL DISTANCE	⊗	EMERGENCY LIGHT
---	COMMON PATH OF TRAVEL	⊗	HORN TYPE AUDIO / VISUAL APPLIANCE
(H)	HANDICAP DOOR OPERATOR WALL MOUNTED SWITCH	F	FIRE ALARM PULL STATION
(P)	PANIC HARDWARE	FEC	FIRE EXTINGUISHER IN CABINET SEMI-RECESSED
(AC)	ACCESS CONTROLLED DOOR	FE	FIRE EXTINGUISHER - SURFACE MOUNTED

NOTE: ELECTRICAL PLANS FOR COMPLETE DESCRIPTION OF DEVICES AND ADDITIONAL DETAILS INCLUDING MOUNTING AND PLACEMENT.

DOOR CLEARANCE LEGEND

FRONT APPROACH - PULL SIDE	FRONT APPROACH - PUSH SIDE	HINGE APPROACH - PULL SIDE	HINGE APPROACH - PULL SIDE
HINGE APPROACH - PUSH SIDE	LATCH APPROACH - PULL SIDE	LATCH APPROACH - PUSH SIDE	

MEANS OF EGRESS: OCCUPANT LOAD

	SPACE	SF / AREA PER OCCUPANT (PER TABLE 1004.1.2)	LOAD	COMMENTS
FIRST FLOOR	BUSINESS: B	5,397 SF / 100 GROSS	54	
	ASSEMBLY: A-3	1,400 SF / 7 NET	200	
	SUB-TOTAL (FIRST FLOOR)		254	
SECOND FLOOR	BUSINESS: B	3,032 SF / 100 GROSS	31	
	ASSEMBLY: A-3	N/A	-	
	SUB-TOTAL (SECOND FLOOR)		31	
TOTAL EGRESS DESIGN OCCUPANT LOAD			285	

RENOVATION FOR:


CRAVEN COUNTY GOVERNMENT CENTER

EAST

CRAVEN COUNTY

1208 E. MAIN STREET, HAVELock, NORTH CAROLINA 28532

OAKLEY COLLIER ARCHITECTS
OCA ARCHITECTS
107 Condevood Road, Rocky Mount, NC 27884 (P) 252.931.2500
205 W. Martin Street, Raleigh, NC 27601

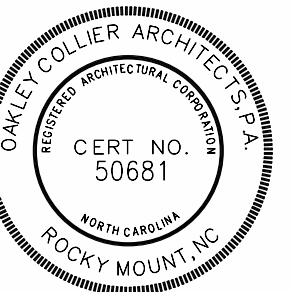

GENERAL NOTE:
Prior to construction start. Contractor shall verify & be responsible for all Dimensions.

Revisions	Description	Date
-----------	-------------	------

Date MAY 30 2026	Project No. 25012
Drawn By ACR	Sheet No. G1.1
Checked By DG	Sheet Title LIFE SAFETY

DESIGN CRITERIA	
BUILDING CODES: 2018 NORTH CAROLINA STATE BUILDING CODE	
ASCE 7-10 MINIMUM DESIGN LOADS FOR BUILDINGS AND OTHER STRUCTURES	
RISK CATEGORY:	
DESIGN LIVE LOADS:	RISK CATEGORY: II
OFFICE	50 PSF
PUBLIC AREAS/LOBBIES	100 PSF
ROOF	20 PSF
*ALL LIVE LOADS ARE REDUCED BASED ON TRIBUTARY AREA AS ALLOWED BY THE BUILDING CODES.	
SNOW LOAD:	GROUND SNOW LOAD, PG 10 PSF
	IMPORTANCE FACTOR, IS 1.0
	SNOW EXPOSURE FACTOR, CE 1.0
	THERMAL FACTOR, CT 1.0
	FLAT ROOF SNOW LOAD, PF 10 PSF
FUTURE LOADS: UNLESS SPECIFICALLY INDICATED ON THE STRUCTURAL DESIGN DRAWINGS THERE HAVE BEEN NO DESIGN PROVISIONS MADE TO ACCOMMODATE FUTURE LOADS OR TO ACCOMMODATE FUTURE ADDITIONS TO THE STRUCTURE.	
GEOTECHNICAL INFO:	
FOUNDATION DESIGN IS BASED ON A PRESUMPTIVE ALLOWABLE BEARING CAPACITY OF 2,000 PSF. GENERAL CONTRACTOR TO FIELD VERIFY PRIOR TO CONSTRUCTION.	
GENERAL	
G-01	THE CONTRACTOR IS RESPONSIBLE FOR COORDINATION OF THE STRUCTURAL WORK WITH CIVIL, LANDSCAPE ARCHITECTURAL, ARCHITECTURAL, MECHANICAL, ELECTRICAL, AND PLUMBING DOCUMENTS AS WELL AS ANY OTHER APPLICABLE TRADES. THE CONTRACTOR IS TO NOTIFY THE DESIGN TEAM OF ANY IDENTIFIED DISCREPANCIES PRIOR TO THE START OF CONSTRUCTION.
G-02	THE STRUCTURAL CONTRACT DOCUMENTS REPRESENT THE FINISHED STRUCTURE AND EXCEPT WHERE SPECIFICALLY SHOWN DO NOT INDICATE THE MEANS OR METHODS OF CONSTRUCTION. THE CONTRACTOR IS RESPONSIBLE FOR ALL CONSTRUCTION MEANS, METHODS, TECHNIQUES, SEQUENCE, AND PROCEDURES.
G-03	THE CONTRACTOR IS RESPONSIBLE FOR THE STABILITY OF THE STRUCTURE AND FOR APPLICATION OF CONSTRUCTION LOADS TO THE STRUCTURE UNTIL THE CONSTRUCTION OF THE STRUCTURE IS COMPLETE. THE CONTRACTOR IS RESPONSIBLE FOR THE DESIGN, INSTALLATION AND REMOVAL OF ALL TEMPORARY BRACING, FORMWORK, SUPPORTS, AND SHORING REQUIRED TO STABILIZE THE STRUCTURE DURING CONSTRUCTION. THE CONTRACTOR IS TO UTILIZE A THIRD PARTY STRUCTURAL ENGINEER TO PROVIDE THE DESIGN AND DOCUMENTATION FOR TEMPORARY BRACING, FORMWORK, SUPPORTS AND SHORING AS REQUIRED BY THE PROJECT SPECIFICATIONS.
G-04	THE CONTRACTOR IS TO VERIFY ALL EXISTING SITE GRADING CONDITIONS, EXISTING UTILITIES AND EXISTING BUILDING DIMENSIONS AND CONDITIONS AS THEY APPLY TO THE NEW STRUCTURAL CONSTRUCTION. THE CONTRACTOR IS TO NOTIFY THE DESIGN TEAM OF ANY IDENTIFIED DISCREPANCIES PRIOR TO THE START OF CONSTRUCTION.
G-05	THE CONTRACTOR IS TO PROTECT ALL EXISTING AND NEW UTILITIES, STRUCTURES, AND FACILITIES FROM DAMAGE DURING CONSTRUCTION.
G-06	ANY WORK NOT IN CONFORMANCE WITH THE STRUCTURAL CONTRACT DOCUMENTS OR THE APPLICABLE BUILDING CODE(S) WILL BE CORRECTED BY THE CONTRACTOR IN A MANNER ACCEPTABLE TO THE STRUCTURAL ENGINEER OF RECORD.
G-07	SECTIONS, DETAILS AND NOTES APPLY TO ALL LIKE OR SIMILAR CONDITIONS.
G-08	DO NOT SCALE STRUCTURAL DRAWINGS TO OBTAIN DIMENSIONAL INFORMATION. THE CONTRACTOR IS TO REQUEST ANY DIMENSIONAL INFORMATION REQUIRED.
G-09	THE STRUCTURAL PLANS DO NOT SHOW EVERY OPENING OR PENETRATION REQUIRED THROUGH STRUCTURAL ELEMENTS. THE CONTRACTOR IS TO VERIFY ALL OPENING SIZES AND LOCATIONS WITH OTHER DISCIPLINES, TRADES AND SHOP DRAWINGS. OPENINGS ARE TO BE CONSTRUCTED USING TYPICAL DETAILS AND CRITERIA PROVIDED ON THE STRUCTURAL DRAWINGS. OPENINGS REQUIRED THAT CANNOT CONFORM TO THE TYPICAL DETAILS OR CRITERIA PROVIDED ON THE STRUCTURAL DRAWINGS ARE TO BE SUBMITTED TO THE STRUCTURAL ENGINEER FOR REVIEW.
DEMOLITION	
D-01	THE CONTRACTOR IS RESPONSIBLE FOR THE STABILITY OF THE EXISTING STRUCTURE AND FOR APPLICATION OF CONSTRUCTION LOADS TO THE EXISTING STRUCTURE DURING THE DEMOLITION PROCESS AND UNTIL THE FINAL CONSTRUCTION OF THE STRUCTURE IS COMPLETE. THE CONTRACTOR IS RESPONSIBLE FOR THE DESIGN, INSTALLATION AND REMOVAL OF ALL TEMPORARY BRACING, FORMWORK, SUPPORTS, AND SHORING REQUIRED TO STABILIZE THE EXISTING STRUCTURE DURING CONSTRUCTION. THE CONTRACTOR IS TO UTILIZE A THIRD PARTY STRUCTURAL ENGINEER TO PROVIDE THE DESIGN AND DOCUMENTATION FOR TEMPORARY BRACING, FORMWORK, SUPPORTS AND SHORING.
D-02	ALL EXISTING FOUNDATIONS AND FRAMING SHOWN ON THE STRUCTURAL CONTRACT DRAWINGS ARE INDICATED FOR REFERENCE ONLY AND ARE TO BE FIELD VERIFIED BY THE CONTRACTOR. NOTIFY THE ENGINEER OF ANY DISCREPANCIES BETWEEN THE EXISTING CONDITIONS AND THOSE SHOWN ON THE STRUCTURAL CONTRACT DOCUMENTS. EXISTING STRUCTURAL FRAMING AND FOUNDATIONS SHOWN ARE BASED ON FIELD VERIFICATION OF VISIBLE ELEMENTS.
POST-INSTALLED ADHESIVE/MECHANICAL ANCHORS	
A-01	POST-INSTALLED ANCHORS ARE TO BE USED ONLY WHERE INDICATED ON THE STRUCTURAL DRAWINGS. THE CONTRACTOR IS TO SUBMIT ANY PROPOSED POST-INSTALLED ANCHORAGE NOT SHOWN ON THE CONTRACT DOCUMENT TO THE ENGINEER FOR REVIEW.
A-02	ALL POST-INSTALLED ANCHORS ARE TO BE INSTALLED AS INDICATED BY THE STRUCTURAL DRAWINGS AND IN STRICT ACCORDANCE WITH THE ANCHOR MANUFACTURER'S INSTRUCTIONS.
A-03	THE BASIS OF DESIGN FOR MECHANICAL ANCHORS ARE THE FOLLOWING PRODUCTS: HILTI KWIK BOLT T2Z EXPANSION ANCHOR WITH SAFESIT SYSTEM; SIMPSON STRONG-TIE TITEN HD SCREW ANCHOR; DEWALT POWER-STUD+SD1
A-04	THE BASIS OF DESIGN FOR ADHESIVES/EPOXY ARE THE FOLLOWING PRODUCTS: HILTI HIT-HY200 V3 OR HILTI-RE 500 V3 WITH SAFESIT SYSTEM; SIMPSON STRONG-TIE SET-3G; DEWALT ACT100-GOLD
A-05	THE CONTRACTOR MAY SUBMIT ALTERNATIVE MECHANICAL ANCHORS AND ADHESIVES/EPOXY THAT MEET OR EXCEED THE PROPERTIES AND LOAD CARRYING CAPACITIES OF THE BASIS OF DESIGN PRODUCTS TO THE ENGINEER FOR REVIEW.
A-06	PRIOR TO THE INSTALLATION OF ANY POST-INSTALLED ANCHORS, THE CONTRACTOR IS TO LOCATE ALL REINFORCING STEEL WITHIN STRUCTURAL ELEMENTS USING NON-DESTRUCTIVE METHODS. IF ANCHOR LOCATIONS ARE IN CONFLICT WITH ANY REINFORCING STEEL NOTIFY THE ENGINEER FOR DIRECTION.

CONCRETE AND REINFORCING STEEL	
C-01	CONCRETE TO MEET THE FOLLOWING 28 DAY COMPRESSIVE STRENGTHS (F'C): CONCRETE SLABS ON GRADE 3,000 PSI, NORMAL WEIGHT FOOTINGS 4,000 PSI, NORMAL WEIGHT FOUNDATION WALLS 4,000 PSI, NORMAL WEIGHT GROUT 5,000 PSI, NON-SHRINK, NON-METALLIC
C-02	PROVIDE CLEAR COVER ON REINFORCING STEEL PER ACI 318 AND AS INDICATED BELOW: CONVENTIONALLY REINFORCED CONCRETE 3" CONCRETE CAST AGAINST AND EXPOSED TO EARTH 2" FOR BARS #6 AND LARGER CONCRETE EXPOSED TO EARTH AND WEATHER 1 1/2" FOR BARS SMALLER THAN #6 CONCRETE NOT EXPOSED TO EARTH AND WEATHER 3/4" FOR SLABS AND WALLS BRG 1 1/2" FOR BEAMS AND COLUMNS *NOTE: 'EXPOSED TO WEATHER' INCLUDES CONCRETE SURFACES PERMANENTLY EXPOSED TO THE ELEMENTS. CONCRETE SURFACES SUCH AS ROOF SLABS THAT ARE COVERED WITH PROTECTIVE SYSTEMS ARE NOT CONSIDERED TO BE EXPOSED TO WEATHER. C-03 DETAIL, FABRICATE AND INSTALL ALL REINFORCING STEEL PER STRUCTURAL CONTRACT DOCUMENTS, ACI-318 AND ACI-315. C-04 DO NOT WELD REINFORCING STEEL UNLESS SPECIFICALLY INDICATED ON STRUCTURAL CONTRACT DOCUMENTS. C-05 EMBEDDED ITEMS SUCH AS ANCHOR BOLTS, REINFORCING STEEL DOWELS, AND EMBED PLATES ARE TO BE SET AND SECURED IN PLACE PRIOR TO THE PLACEMENT OF CONCRETE. 'WET SETTING' OF EMBEDDED ITEMS IS NOT ACCEPTABLE. C-06 CLAY BRICK, ROCKS, WOOD, OR CMU BRICK ARE NOT TO BE USED TO SUPPORT REINFORCING STEEL IN FOOTINGS OR SLABS ON GRADE. C-07 DOWELS EXTENDING FROM CONCRETE ELEMENTS SHOULD MATCH THE SIZE AND SPACING OF MAIN REINFORCING STEEL WHEN NOT SPECIFICALLY NOTED OTHERWISE. REQUIRED LAP LENGTHS FOR DOWELS AND MAIN REINFORCING STEEL IS TO BE PROVIDED PER THE TYPICAL SCHEDULES PROVIDED ON THE STRUCTURAL DRAWINGS. C-08 LOCATE LAPS IN REINFORCING STEEL AS FOLLOWS, UNLESS SPECIFICALLY NOTED OTHERWISE: CONTINUOUS FOOTINGS - AT CONTRACTOR'S PREFERENCE WALL HORIZONTAL REINFORCING - AT CONTRACTOR'S PREFERENCE WALL VERTICAL REINFORCING - AS INDICATED ON SECTIONS AND DETAILS C-09 FOLLOW STRUCTURAL DRAWINGS FOR ACCEPTABLE INSTALLATION OF PLUMBING, ELECTRICAL, TELECOMMUNICATION, MECHANICAL OR OTHER UTILITY LINES AND CONDUIT THROUGH AND WITHIN CONCRETE ELEMENTS. THE CONTRACTOR IS TO NOTIFY THE DESIGN TEAM OF ANY CONDITIONS THAT DO NOT COMPLY WITH DETAILS SHOWN ON THE STRUCTURAL DRAWINGS. C-10 HORIZONTAL CONSTRUCTION JOINTS IN CONCRETE ELEMENTS ARE NOT ACCEPTABLE WITHOUT PRIOR APPROVAL OF THE ENGINEER. C-11 THE CONTRACTOR IS TO PROVIDE VERTICAL CONSTRUCTION JOINTS AS NECESSARY TO ENSURE THE QUALITY AND FINISH OF CONCRETE SATISFIES THE PROJECT SPECIFICATIONS. THE CONTRACTOR'S PROPOSED CONSTRUCTION JOINT LOCATIONS ARE TO BE SUBMITTED TO THE ENGINEER FOR REVIEW PRIOR TO CONCRETE PLACEMENT. REFER TO TYPICAL CONSTRUCTION JOINT DETAILS FOR ADDITIONAL REINFORCING, KEYWAYS AND OTHER REQUIREMENTS.

CONCRETE MASONRY (CMU)	
M-01	MASONRY ASSEMBLY 28 DAY COMPRESSIVE STRENGTH (F'M): 1,500 PSI CONCRETE MASONRY UNIT COMPRESSIVE STRENGTH: 1,900 PSI MASONRY GROUT, TYPE S, 28 DAY COMPRESSIVE STRENGTH: 2,000 PSI
M-02	DETAIL, FABRICATE AND INSTALL ALL REINFORCING STEEL PER STRUCTURAL CONTRACT DOCUMENTS AND ACI-530.01.
M-03	EMBEDDED ITEMS SUCH AS ANCHOR BOLTS, REINFORCING STEEL DOWELS, AND EMBED PLATES ARE TO BE SET AND SECURED IN PLACE PRIOR TO GROUTING MASONRY UNITS. 'WET SETTING' OF EMBEDDED ITEMS IS NOT ACCEPTABLE.
M-04	DOWELS EXTENDING FROM CONCRETE ELEMENTS INTO MASONRY SHOULD MATCH THE SIZE AND SPACING OF MAIN REINFORCING STEEL WHEN NOT SPECIFICALLY NOTED OTHERWISE. REQUIRED LAP LENGTHS FOR DOWELS AND MAIN REINFORCING STEEL IS TO BE PROVIDED PER THE TYPICAL SCHEDULES PROVIDED ON THE STRUCTURAL DRAWINGS.
M-05	WALLS, PEDESTALS AND PIERS BELOW GRADE ARE TO HAVE ALL CELLS OF MASONRY UNITS GROUTED SOLID.
M-06	ALL WALLS, PEDESTALS AND PIERS ABOVE GRADE ARE TO HAVE ONLY REINFORCED CELLS OF MASONRY UNITS GROUTED SOLID UNLESS SPECIFICALLY NOTED OTHERWISE ON STRUCTURAL DETAILS.
M-07	FOLLOW STRUCTURAL DRAWINGS FOR ACCEPTABLE INSTALLATION OF PLUMBING, ELECTRICAL, TELECOMMUNICATION, MECHANICAL OR OTHER UTILITY LINES AND CONDUIT THROUGH AND WITHIN CONCRETE MASONRY ELEMENTS. THE CONTRACTOR IS TO NOTIFY THE DESIGN TEAM OF ANY CONDITIONS THAT DO NOT COMPLY WITH DETAILS SHOWN ON THE STRUCTURAL DRAWINGS.

FOUNDATIONS	
F-01	FOOTINGS ARE TO BE FOUNDIED AT A DEPTH PROVIDING THE DESIGN BEARING CAPACITY AND AT AN ELEVATION WHERE THE TOP OF THE FOOTING IS BELOW THE FROST PENETRATION DEPTH AS DICTATED BY THE BUILDING CODE BUT NO LESS THAN 12" BELOW THE FINAL FINISHED GRADE. THE CONTRACTOR IS TO COMPARE THE TOP OF FOOTING ELEVATIONS INDICATED ON THE STRUCTURAL DRAWINGS WITH THE FINAL GRADE INDICATED ON THE CIVIL/LANDSCAPE ARCHITECTURAL DRAWINGS AND NOTIFY THE DESIGN TEAM OF ANY DISCREPANCIES PRIOR TO THE START OF CONSTRUCTION.
F-02	THE CONTRACTOR IS RESPONSIBLE TO ADEQUATELY PROTECT ALL EXCAVATIONS, WHERE REQUIRED, SHORE THE EXCAVATIONS WITH SYSTEMS DESIGNED AND DETAILED BY THE CONTRACTOR'S ENGINEER.
F-03	UNLESS SPECIFICALLY NOTED ON THE STRUCTURAL DRAWINGS, ALL FOUNDATION WALLS AND BASEMENT WALLS ARE TO BE TEMPORARILY BRACED BY THE CONTRACTOR DURING BACKFILL OPERATIONS AND UNTIL SLABS AT TOP OF WALLS HAVE BEEN INSTALLED AND HAVE REACHED DESIGN STRENGTH OR ARE AT LEAST 7 DAYS OLD.
F-04	FOLLOW STRUCTURAL DRAWINGS FOR ACCEPTABLE INSTALLATION OF PLUMBING, ELECTRICAL, TELECOMMUNICATION, MECHANICAL OR OTHER UTILITY LINES UNDER AND THROUGH FOUNDATION ELEMENTS. THE CONTRACTOR IS TO NOTIFY THE DESIGN TEAM OF ANY CONDITIONS THAT DO NOT COMPLY WITH DETAILS SHOWN ON THE STRUCTURAL DRAWINGS.

STRUCTURAL STEEL	
S-01	STEEL PROPERTIES: ANGLES, BARS, RODS: A36 (FY=36 KSI) PLATE: A36 (FY=36 KSI) AND A572, GRADE 50 (50 KSI) WHERE INDICATED F1554, GRADE 36
S-02	ANCHOR BOLTS: DESIGN, DETAIL, FABRICATE AND ERECT STRUCTURAL STEEL PER STRUCTURAL CONTRACT DOCUMENTS AND AISC 360-05 AND AISC 325-05.
S-03	WELD ELECTRODES: E70XX. PERFORM ALL WELDING PER AWS D1.1-4.
S-04	ALL STEEL MEMBER CONNECTIONS ARE TO BE DESIGNED BY THE FABRICATOR'S ENGINEER FOR THE LOADS INDICATED. WHEN SPECIFIC REACTIONS ARE NOT PROVIDED ON PLANS OR BY NOTE, CONNECTIONS ARE TO BE DESIGNED FOR THE MAXIMUM ALLOWABLE UNIFORM LOADS AS DETERMINED BY PART 3 OF THE AISC MANUAL OF STEEL CONSTRUCTION FOR THE SECTION, SPAN AND STRENGTH SPECIFIED.
S-05	UNLESS SPECIFICALLY INDICATED, SPliced STRUCTURAL STEEL MEMBERS ARE NOT ACCEPTABLE. ALL PROPOSED SPLICES MUST BE SUBMITTED TO THE ENGINEER FOR REVIEW PRIOR TO CONSTRUCTION.
S-06	FIELD MODIFICATION OF STRUCTURAL STEEL MEMBERS AND THEIR CONNECTIONS IS PROHIBITED UNLESS THE PROPOSED MODIFICATIONS HAVE BEEN REVIEWED BY THE ENGINEER.
S-07	REFER TO ARCHITECTURAL, MECHANICAL, ELECTRICAL AND PLUMBING DRAWINGS FOR BLOCK, CLIPS, TABS AND OTHER ATTACHMENTS REQUIRED. SHOW ALL ITEMS ON STRUCTURAL STEEL SHOP DRAWINGS.
S-08	FOLLOW STRUCTURAL DRAWINGS FOR ACCEPTABLE OPENINGS, HOLES AND SPECIAL COPING OF STRUCTURAL STEEL MEMBERS REQUIRED FOR THE INSTALLATION OF PLUMBING, ELECTRICAL, TELECOMMUNICATION, MECHANICAL OR OTHER UTILITY LINES AND CONDUIT THROUGH STEEL MEMBERS. THE CONTRACTOR IS TO NOTIFY THE DESIGN TEAM OF ANY CONDITIONS THAT DO NOT COMPLY WITH DETAILS SHOWN ON THE STRUCTURAL DRAWINGS.

ABBREVIATIONS			
@	AT	HD	HEADED
&	AND	HORZ	HORIZONTAL
#	NUMBER	INT	INTERIOR
AB	ANCHOR BOLTS	INFO	INFORMATION
ADDL	ADDITIONAL	JT	JOINT
AFB	ABOVE FINISHED FLOOR	K	KIPS
ALT	ALTERNATE	KSI	KIPS PER SQUARE INCH
ARCH	ARCHITECT / ARCHITECTURAL	LBS	POUNDS
BOT	BOTTOM	LLH	LONG LEG HORIZONTAL
BCX	BOTTOM CHORD EXTENSION	LLV	LONG LEG VERTICAL
BLDG	BUILDING	LWC	LIGHTWEIGHT CONCRETE
BOS	BOTTOM OF STEEL	MAX	MAXIMUM
BRG	BEARING	MC	MOMENT CONNECTION
BTWN	BETWEEN	MECH	MECHANICAL
CANT	CANTILEVER	MEP	MECHANICAL, ELECTRICAL, PLUMBING
CJ	CONTROL JOINT	MFR	MANUFACTURER
CL	CENTERLINE	MIN	MINIMUM
CLR	CLEAR	MISC	MISCELLANEOUS
CMU	CONCRETE MASONRY UNIT	MOW	MIDDLE OF WALL
COL	COLUMN	NS	NEAR SIDE
CONC	CONCRETE	NTS	NOT TO SCALE
CONN	CONNECTION	NWC	NORMAL WEIGHT CONCRETE
CONS	CONSTRUCTION	OC	ON CENTER
CONT	CONTINUOUS	OPNG	OPENING
CORD	COORDINATE	OPP	OPPOSITE HAND
CTRD	CENTERED	PAF	POWDER ACTUATED FASTENER
d	PENNY (NAILS)	PARL	PARALLEL
DBA	DEFORMED BAR ANCHOR	PERP	PERPENDICULAR
DET	DETAIL	PL	PLATE
DIA	DIAMETER	PSF	POUNDS PER SQAURE FOOT
DIM	DIMENSION	PSI	POUNDS PER SQAURE INCH
DIST	DISTANCE	PT	PRESSURE TREATED
DN	DOWN	P-T	POST TENSIONED
DWIG	DRAWING	REF	REFERENCE
DWL	DOWEL	REIN	REINFORCING
EA	EACH	REQD	REQUIRED
EE	EACH END	SCH	SCHEDULE
EF	EACH FACE	SIM	SIMILAR
EJ	EXPANSION JOINT	SOG	SLAB ON GRADE
ELEV	ELEVATION	SPEC	SPECIFICATION(S)
EMBD	EMBEDDED / EMBEDMENT	SQ	SQUARE
ENGR	ENGINEER	STD	STANDARD
EOD	EDGE OF DECK	STIF	STIFFENER
EOS	EDGE OF SLAB	STIR	STIRRUP(S)
EQL	EQUAL	STL	STEEL
EW	EACH WAY	TCX	TOP CHORD EXTENSION
EXST	EXISTING	THRU	THROUGH
EXP	EXPANSION	TOC	TOP OF CONCRETE
EXT	EXTERIOR	TOF	TOP OF FOOTING
FDN	FOUNDATION	TOS	TOP OF STEEL
FFE	FINISHED FLOOR ELEVATION	TOW	TOP OF WALL
FW	FACE OF WALL	TYP	TYPICAL
FRT	FIRE RETARDANT TREATED	UNO	UNLESS NOTED OTHERWISE
FS	FAR SIDE	VERT	VERTICAL
FTG	FOOTING	VIF	VERIFY IN FIELD
GA	GAUGE	W/	WITH
GALV	GALVANIZED	WP	WORK POINT

RENOVATION FOR:

CRAVEN COUNTY GOVERNMENT

CENTER EAST

CRAVEN COUNTY

1208 E. MAIN STREET, HAVELOCK, NORTH CAROLINA 28532





05/26/2026
THIS DOCUMENT WAS ELECTRONICALLY SIGNED BY ROBERT T. MACIVER



GENERAL NOTE: Prior to construction start, Contractor shall verify & be responsible for all Dimensions.		
Revisions	Description	Date
#		
Date	Project No.	
05/28/2026	25012	
Drawn By	Sheet No.	
LS	S001	
Checked By		
RM		
Sheet Title GENERAL NOTES & ABBREVIATIONS		



107 Condelewood Road, Rocky Mount, NC 27884 (919) 522-9337, 2500
205 W. Martin Street, Raleigh, NC 27601

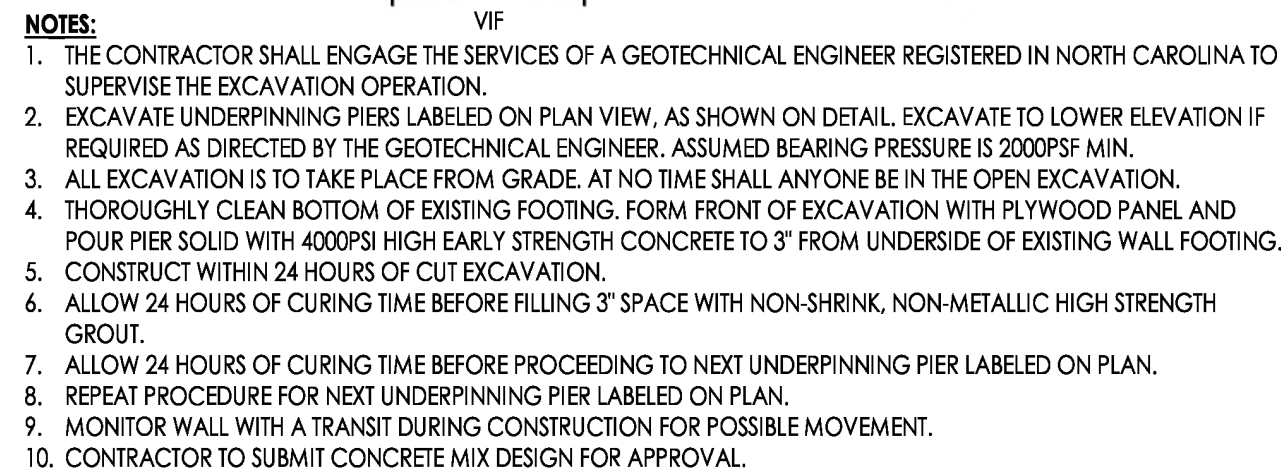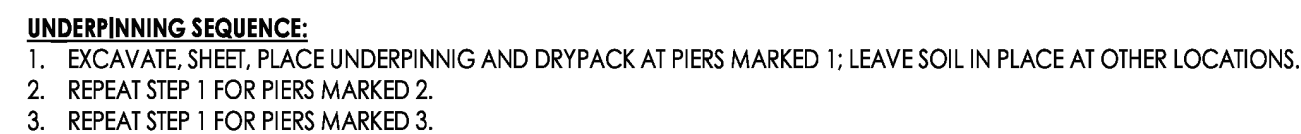

6 $3/4^n = 1 - 0^n$

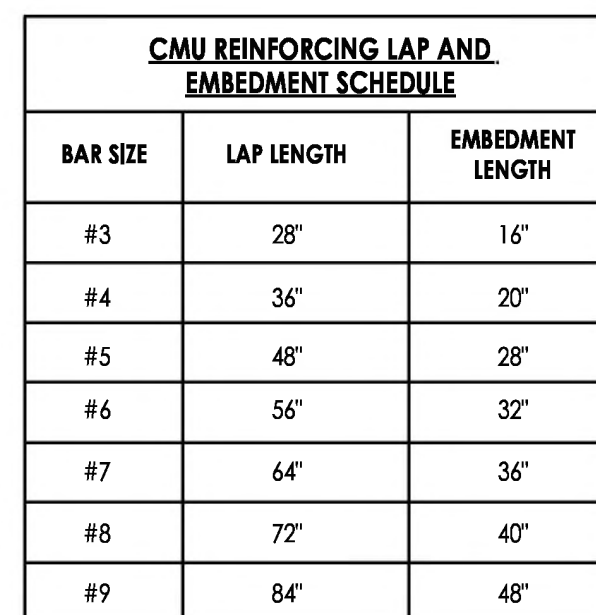 


NOTES:

1. THIS SCHEDULE APPLIES TO REINFORCED CMU WALLS WHICH ARE BRACED/CONNECTED TO FLOORS OR ROOF AT THE TOP OF THE WALL. LAPS AND EMBEDMENT LENGTHS FOR CANTILEVERED CMU WALLS ARE NOT TO BE DETERMINED USING THIS SCHEDULE.

4 $3/4^n = 1'-0''$



 1. SEE STRUCTURAL AND ARCHITECTURAL DRAWINGS AND SPECIFICATIONS FOR REQUIRED HORIZONTAL JOINT REINFORCING, BOND BEAMS AND VERTICAL REINFORCEMENT.
2. PROVIDE DOWELS WITH HOOKS INTO FOUNDATION AT ALL VERTICAL REINFORCEMENT. DOWELS TO MATCH VERTICAL BARS IN SIZE AND SPACING.
3. GROUT SOLID ALL CELLS CONTAINING VERTICAL REINFORCING FOR FULL HEIGHT OF WALL.
4. SEE ARCHITECTURAL DRAWING FOR LOCATION AND SPACING OF CONTROL JOINTS. MAXIMUM SPACING BETWEEN CONTROL JOINTS IS NOT TO EXCEED 25 FEET.



$$\overline{1/8^n = 1'-0''}$$


NOTES:

1. SEE S001 FOR GENERAL STRUCTURAL NOTES AND ABBREVIATION LEGEND.
2. TOP OF SLAB ELEVATION = 0'-0" UNLESS NOTED OTHERWISE
3. EXISTING STRUCTURE INDICATED WAS DETERMINED BY FIELD INVESTIGATIONS. CONTRACTOR TO VERIFY ALL EXISTING CONDITIONS.
4. SEE THIS SHEET FOR SLAB CONSTRUCTION DETAILS.
5. ~~FOOTING~~ ~~xxxi~~ INDICATES TOP OF FOOTING ELEVATION FROM EXISTING SLAB ON GRADE ELEVATION
6. ~~FOOTING~~ ~~xxxi~~ TO BE CENTERED ON WALLS AND COLUMNS UNLESS NOTED OTHERWISE.
7. DETERMINE LOCATIONS OF ALL FLOOR DRAINS, SLOPES TO DRAINS, AND SLAB DEPRESSIONS FROM ARCHITECTURAL DRAWINGS.
8. SEE THIS SHEET FOR MISCELLANEOUS TYPICAL FOUNDATION DETAILS.



$$\underline{\underline{3/4^n = 1'-0^n}}$$

Copyright © 2025 Oakley Collier Architects. These drawings are of the property of the Architect for use under his supervision. No reproduction or other use is allowed without permission.

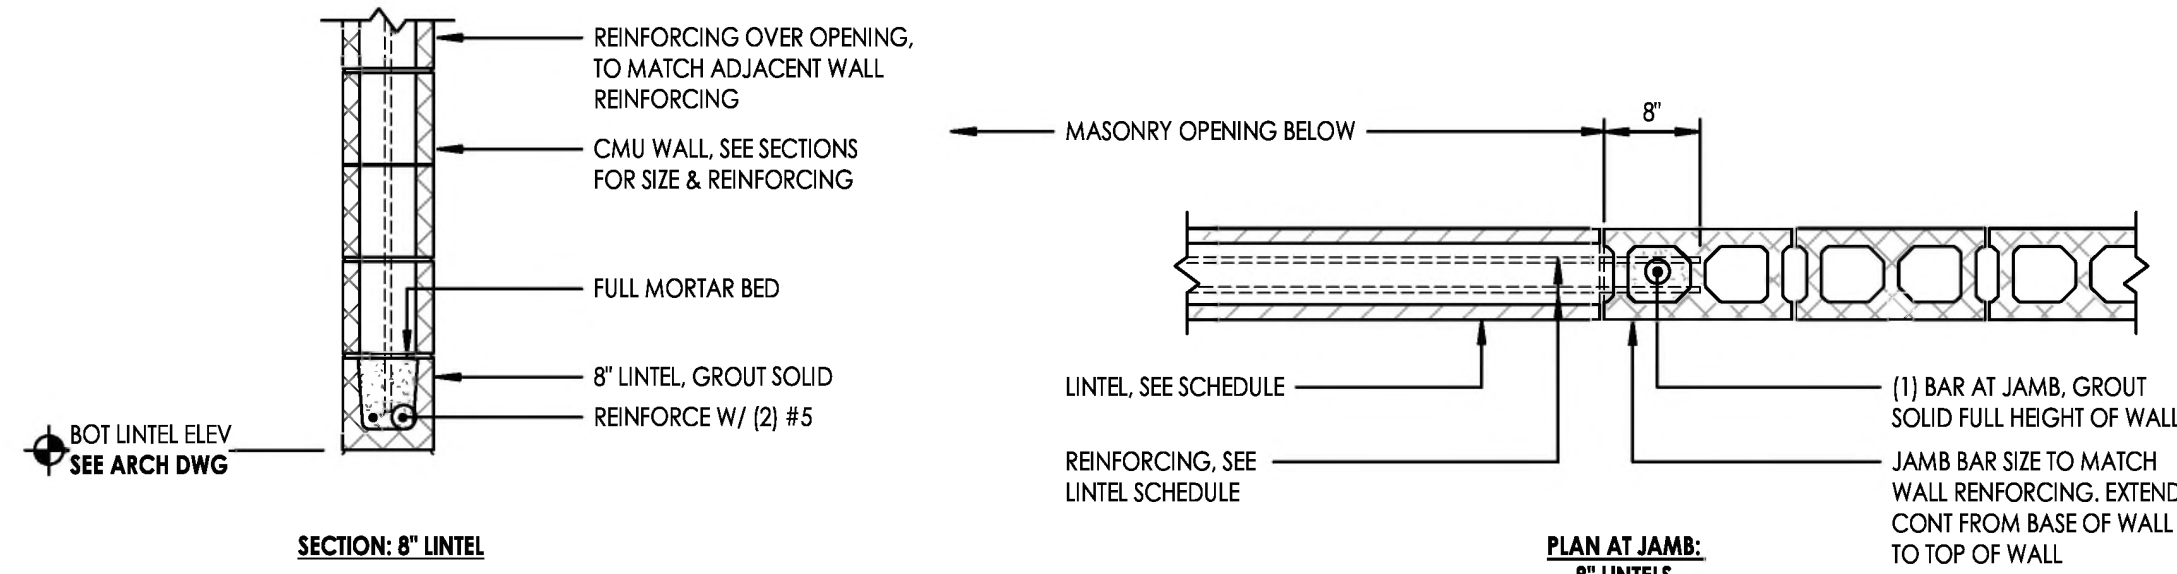


4 CMU LINTEL SCHEDULE - LOAD BEARING

3/4" = 1'-0"

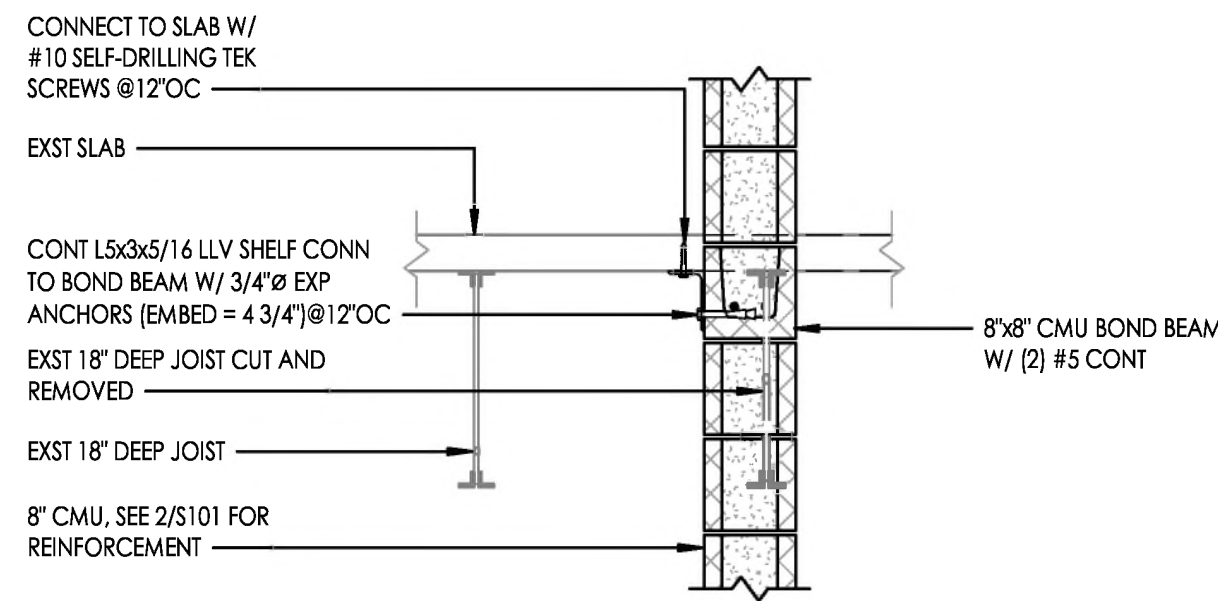

3 SECTION

3/4" = 1'-0"

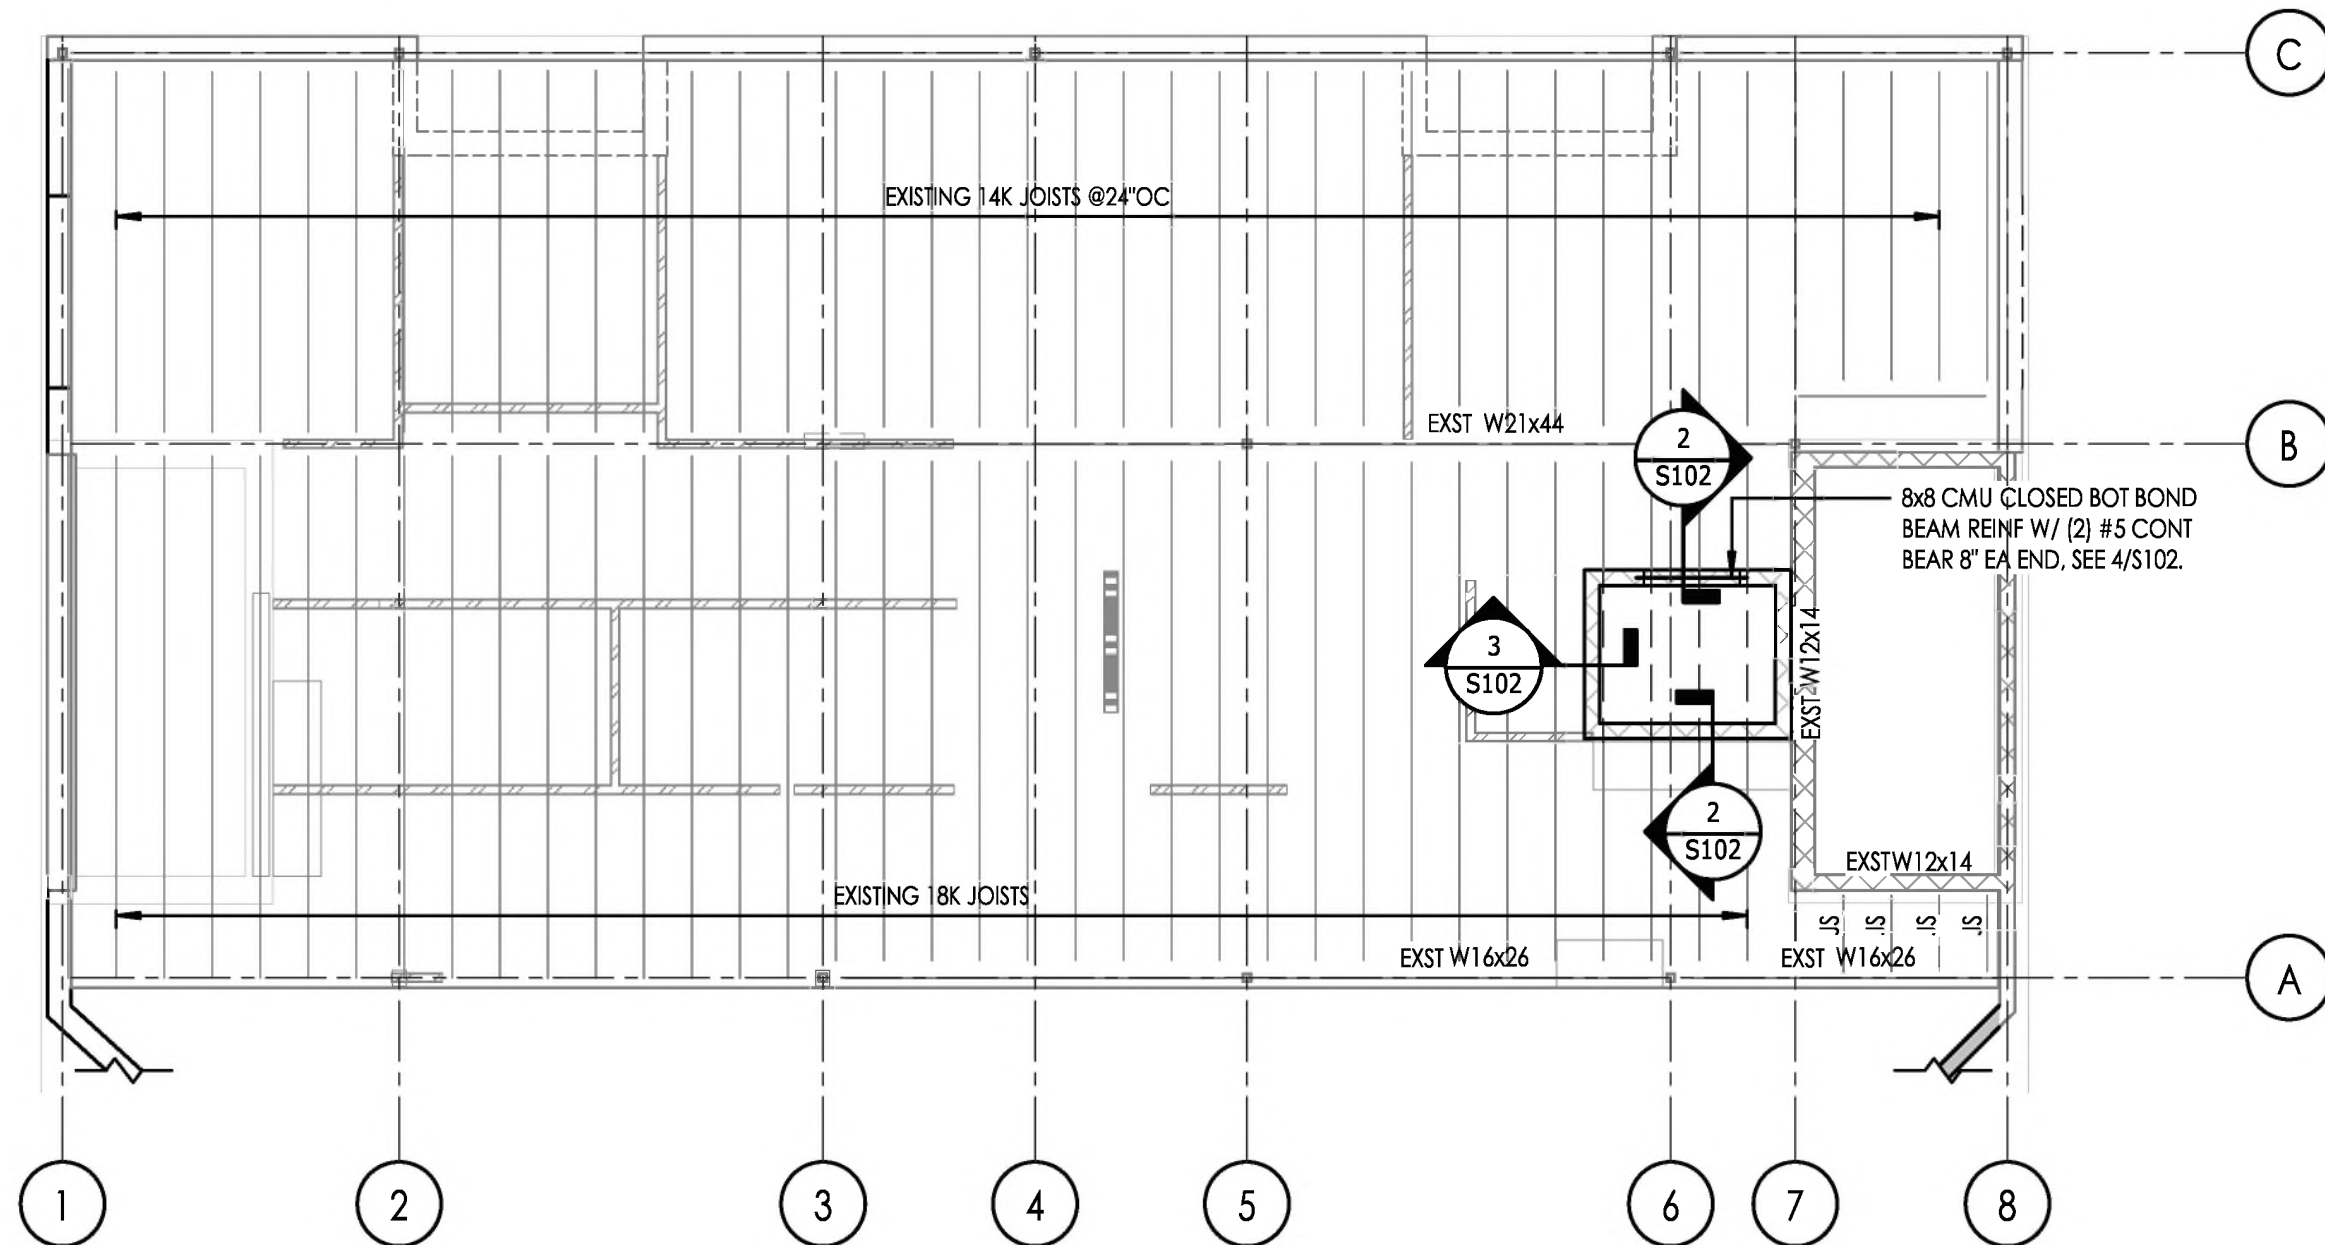


1 2ND FLOOR FRAMING PLAN

1/8" = 1'-0"



NOTES:

1. SEE S001 FOR STRUCTURAL GENERAL NOTES AND ABBREVIATION LEGEND.
2. TOP OF SLAB ELEVATION = 13'-8" UNLESS NOTED OTHERWISE. FIELD VERIFY PRIOR TO CONSTRUCTION.
3. CONTRACTOR TO VERIFY ALL EXISTING CONDITIONS.
4. SEE S101 FOR WALL REINFORCING.

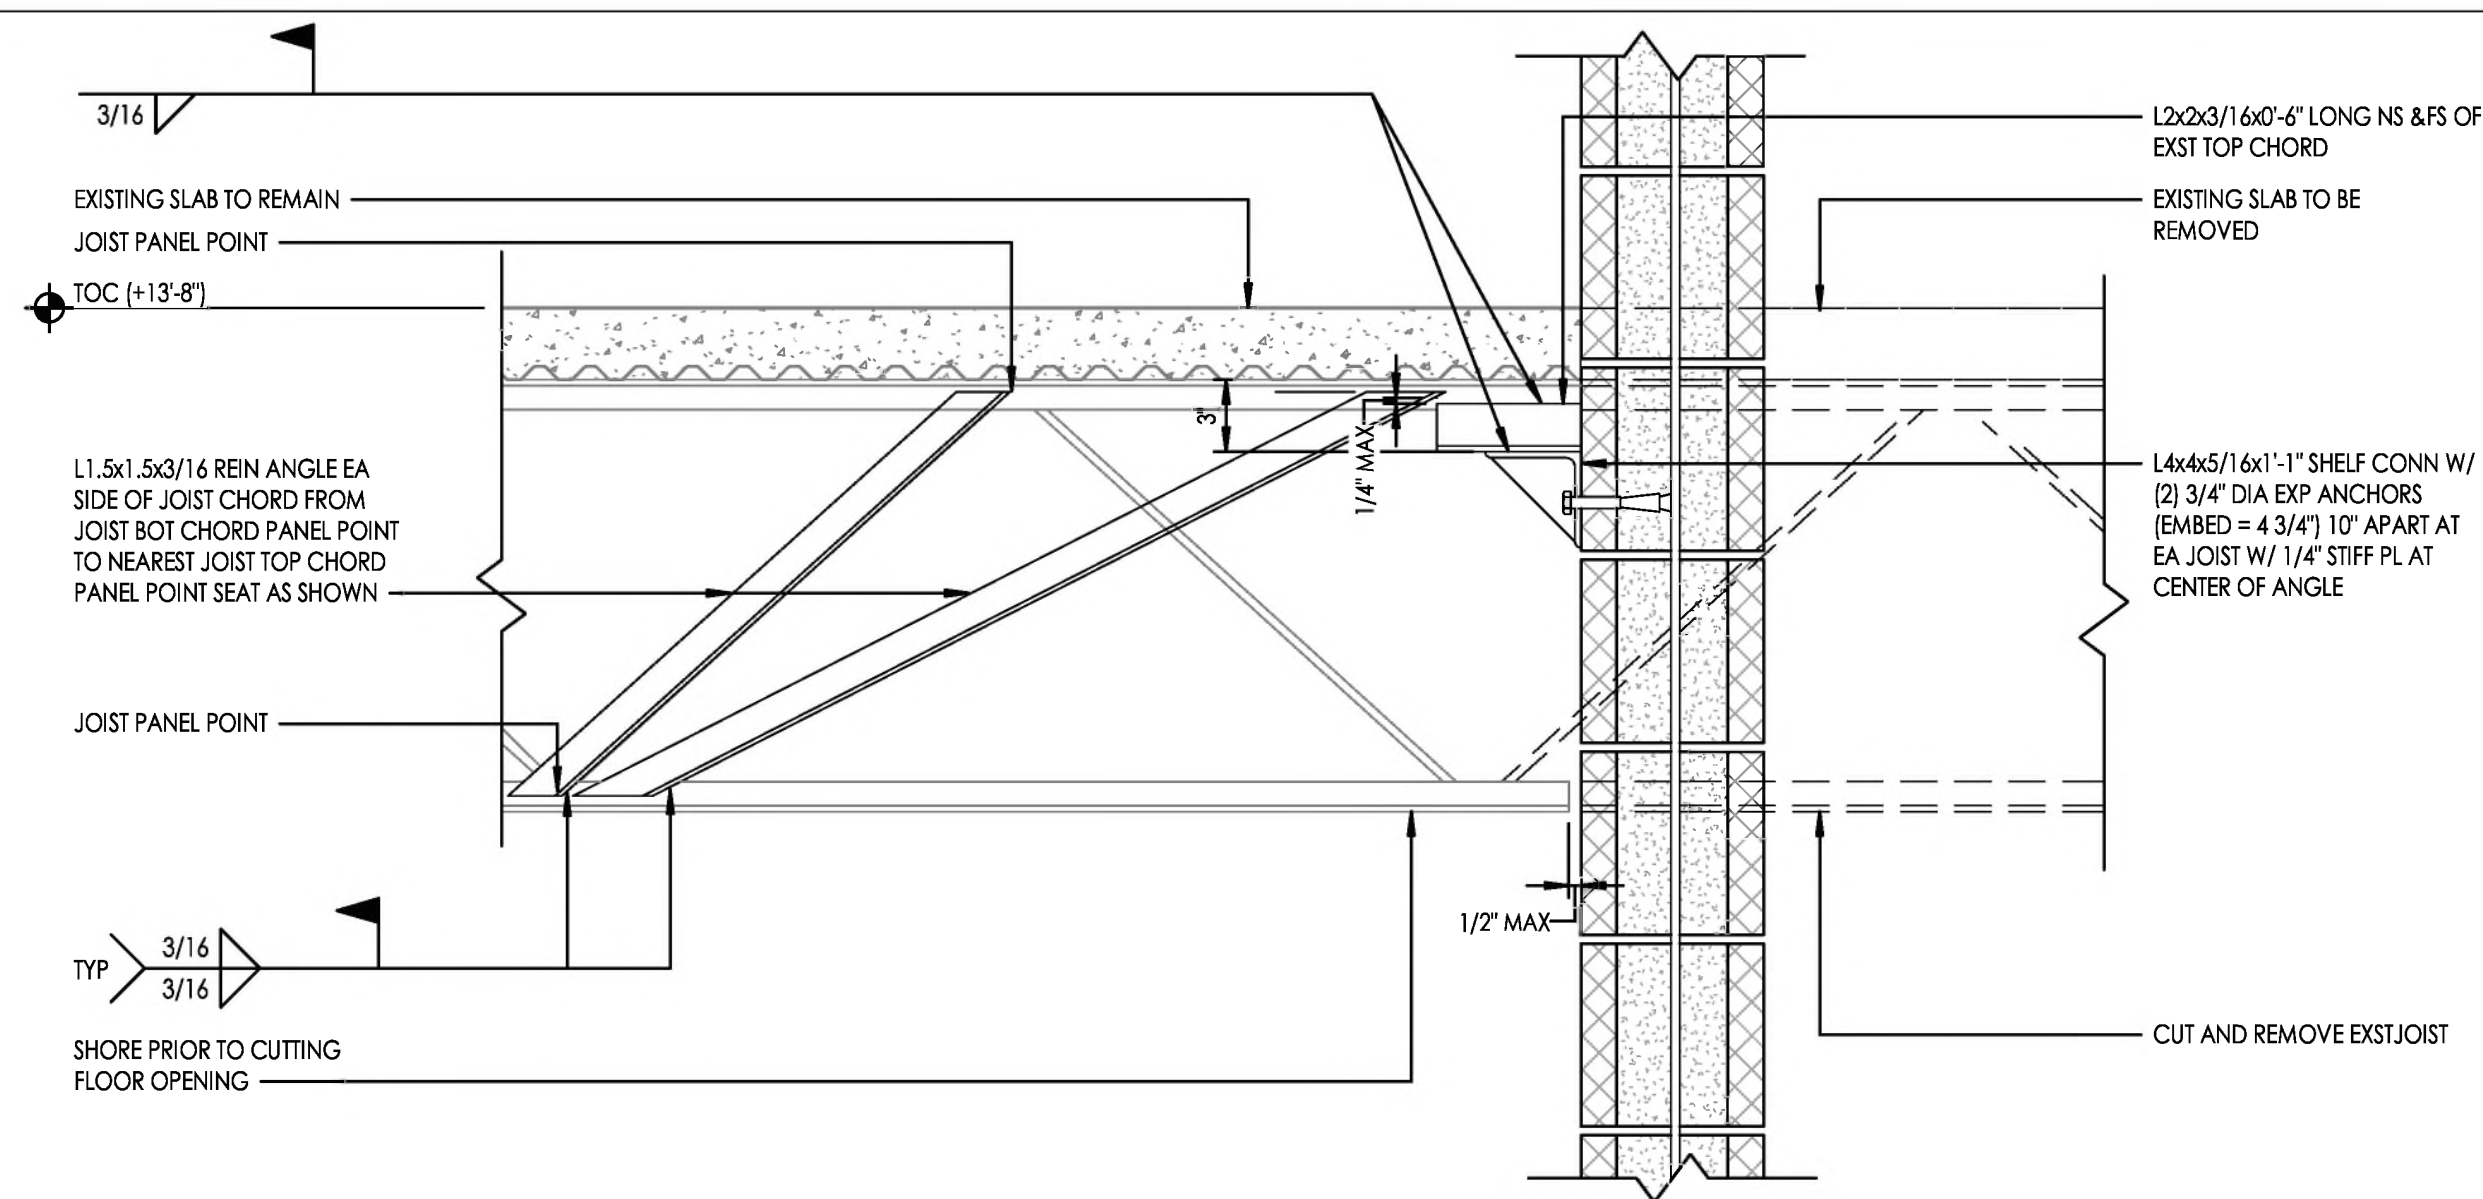

2 SECTION

1 1/2" = 1'-0"

Technical drawing showing a cross-section of a CMU wall with expansion joints. The wall is composed of multiple cells, each filled with grout. A horizontal hoist beam is shown intersecting the wall. The drawing includes dimensions and labels for various components:


- 1.3"x3"x8"x11" LONG W/ [2]3/4" DIA EXPANSION JOINTS W/ 4 3/4" EMBD**: Label for the expansion joint.
- HOIST BEAM**: Label for the horizontal beam.
- BOS SEE PLAN**: Label for the beam of stay.
- ALL CELLS MUST BE GROUTED SOLID**: Requirement for the grout.
- CMU WALL, SEE SECTIONS FOR SIZE AND REINFORCING**: Label for the concrete masonry unit wall.
- Dimensions**:
 - $1 \frac{3}{4}"$: Dimension for the expansion joint width.
 - $\frac{3}{16}$ and $\frac{1}{4}$: Dimensions for the hoist beam.
 - t_c : Thickness of the CMU wall.
 - b_o : Overall width of the expansion joint.

The image displays three technical drawings of a concrete masonry bond beam, illustrating its construction and reinforcement details.


- PLAN View:** Shows the cross-section of the bond beam. Key features include:
 - WALL THICKNESS:** Indicated on the left and bottom.
 - STD HOOK:** Two standard hooks are shown at the top of the vertical wall reinforcement.
 - DOWELS TO MATCH BOND BEAM REINFORCING:** Two vertical dowels are shown connecting the wall reinforcement to the bond beam reinforcement.
 - BOND BEAM REINFORCING:** The reinforcement within the bond beam, shown as a series of vertical bars.
 - 48#BAR DIA LAP, TYP:** A typical lap length for the 48# bars is indicated.
- ISOMETRIC View:** A 3D perspective view of the bond beam. Key features include:
 - CONCRETE MASONRY BOND BEAM UNITS:** The main structure of the bond beam.
 - VERTICAL REINFORCEMENT CONT THRU BOND BEAM:** Vertical bars passing through the bond beam.
 - SOLID GROUTED BOND BEAM:** The bond beam is shown as a solid, grouted unit.
 - BOND BEAM REINFORCING:** The reinforcement within the bond beam.
- ELEVATION : STEP View:** Shows the side view of the bond beam. Key features include:
 - 2'-0" AT STEP IN BOND BEAM:** A dimension indicating the length of the bond beam at a step.
 - 2" CLR:** A clearance dimension.
 - TOP OF BOND BM ELEV:** The elevation of the top of the bond beam.
 - VERTICAL WALL REINFORCEMENT:** The reinforcement within the vertical wall.
 - AT STEP, LAP BARS TO MATCH BOND BEAM REINFORCEMENT, LAP 48#BAR DIAMETER:** A detail showing the lap of bars at a step.
 - CONT BOND BEAM REINFORCEMENT, LAP 48#BAR DIAMETER WHERE REQUIRED:** A detail showing the continuation of bond beam reinforcement.

1. SEE S001 FOR STRUCTURAL GENERAL NOTES AND ABBREVIATION LEGEND.
2. TOP OF METAL DECK ELEVATION = 27'-4" UNLESS NOTED OTHERWISE.
3. CONTRACTOR TO VERIFY ALL EXISTING CONDITIONS.
4. SEE THIS SHEET FOR MISCELLANEOUS TYPICAL ROOF FRAMING DETAILS.
5. SEE S101 FOR WALL REINFORCING KEY PLAN.


2 CMU ELEVATOR SHAFT
3/4" = 1'-0"

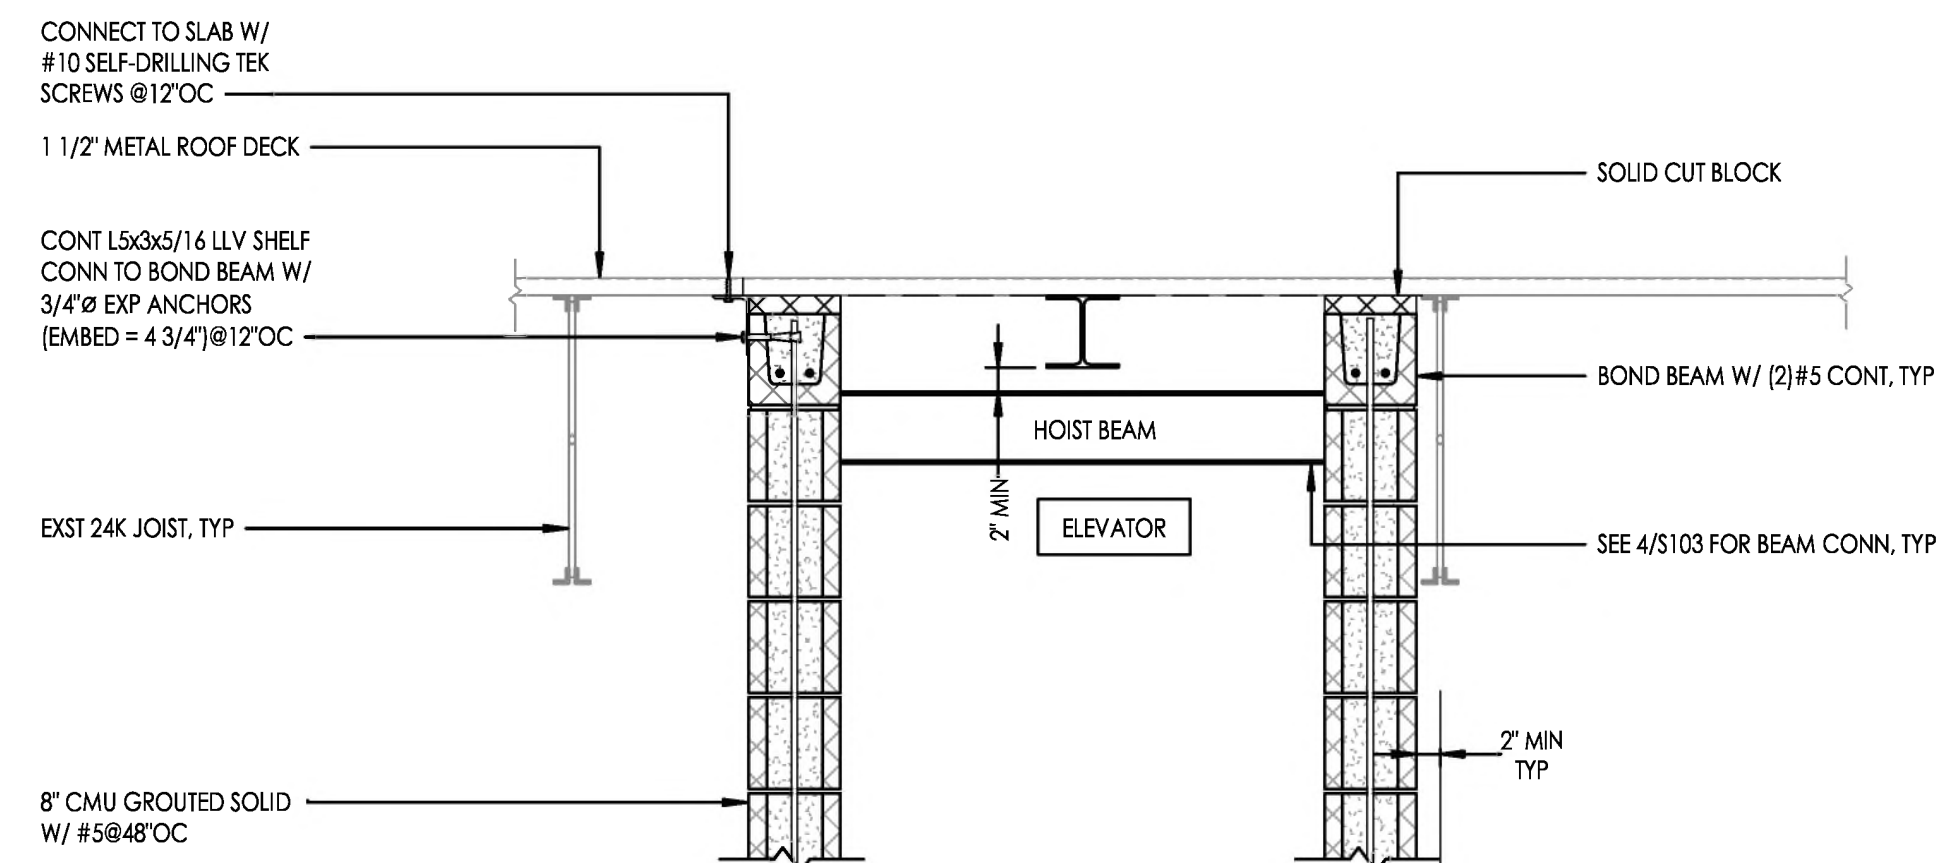

Copyright © 2025 Oakley Collier Architects. These drawings are of the property of the Architect for use under his supervision. No reproduction or other use is allowed without permission.

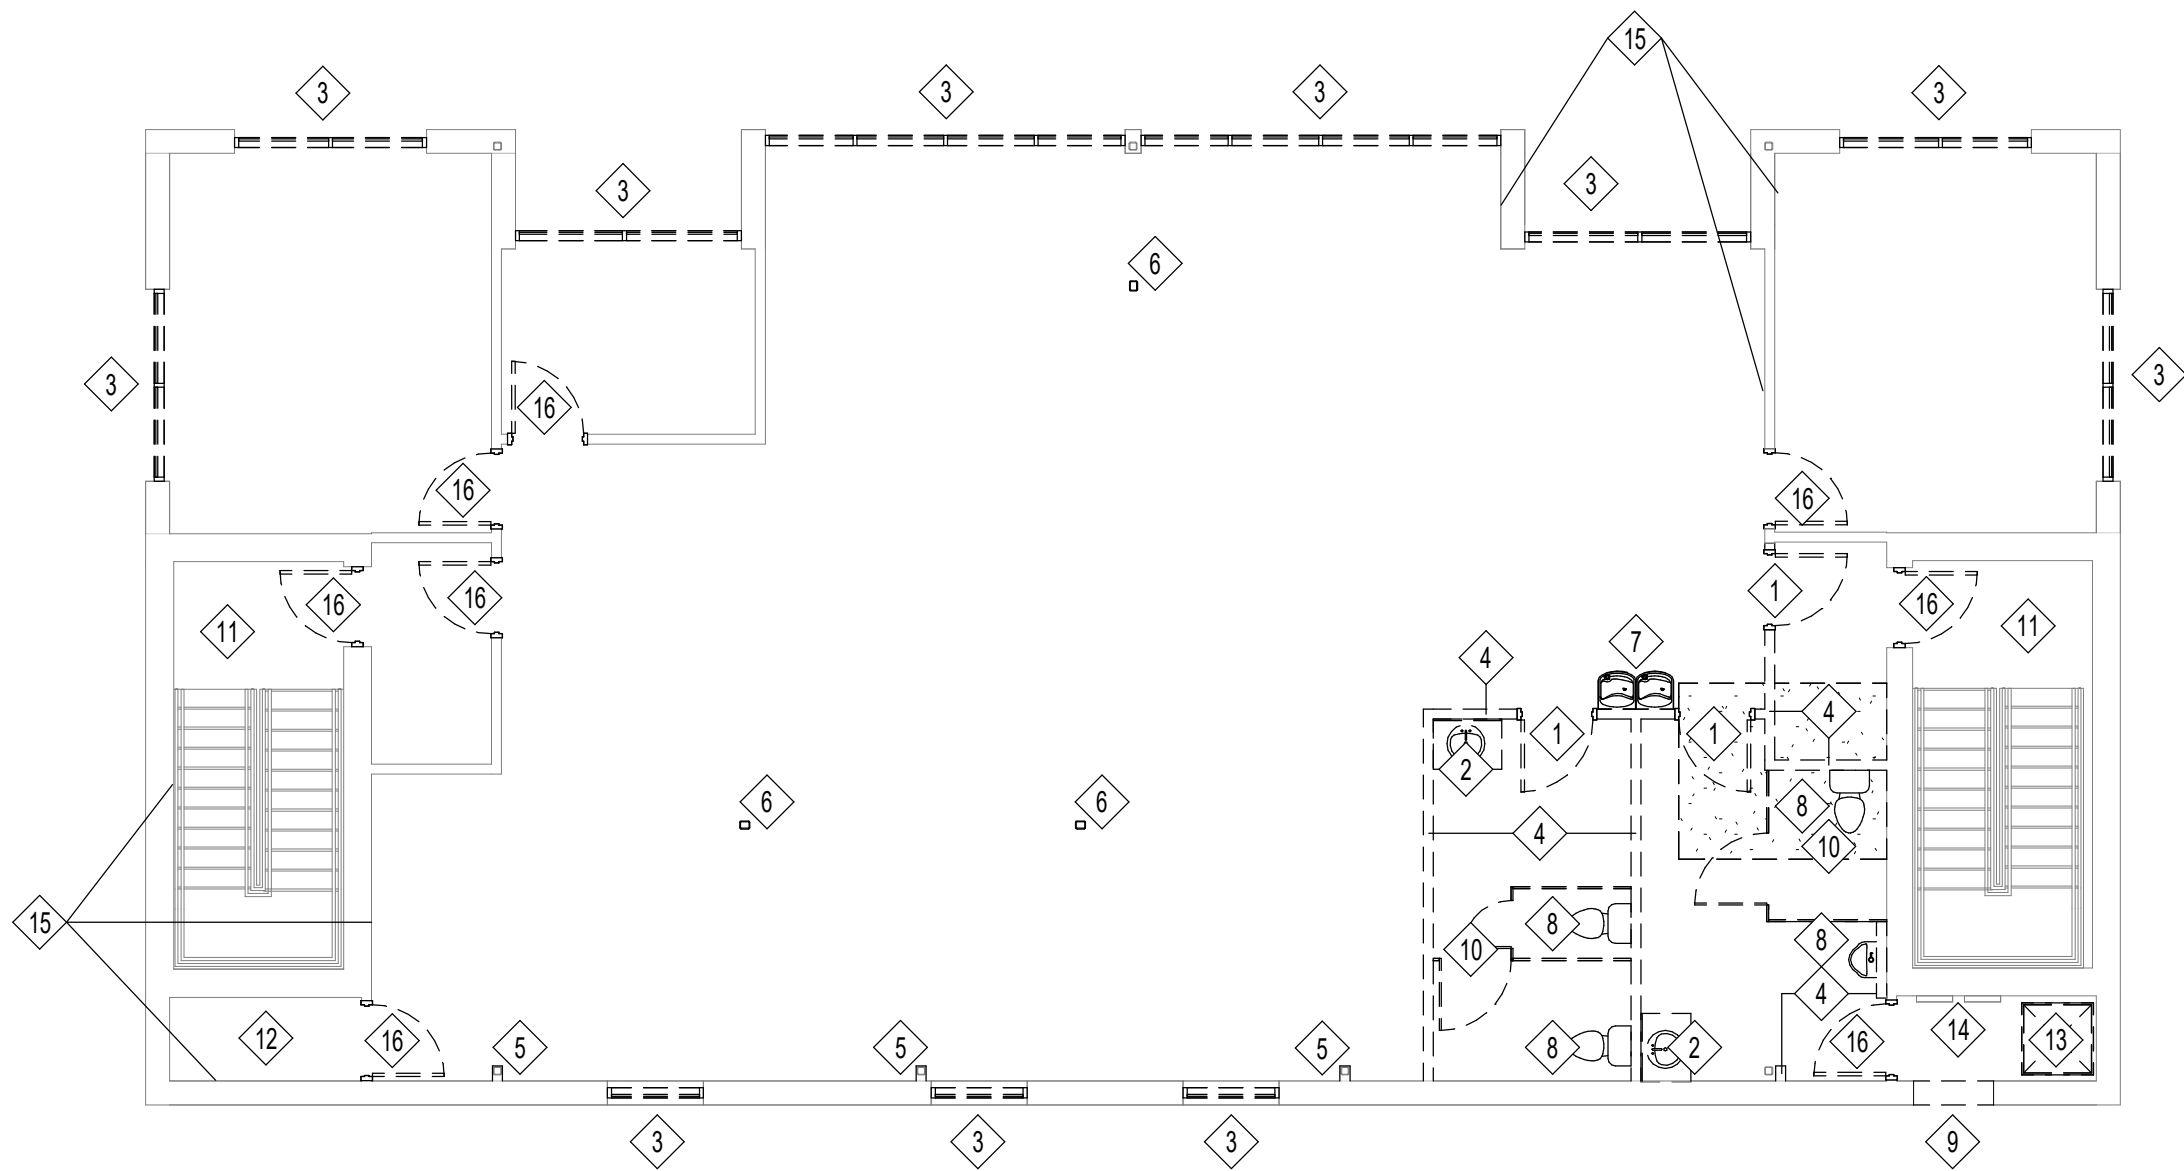

1 SECOND FLOOR DEMOLITION PLAN
1/8" = 1'-0"

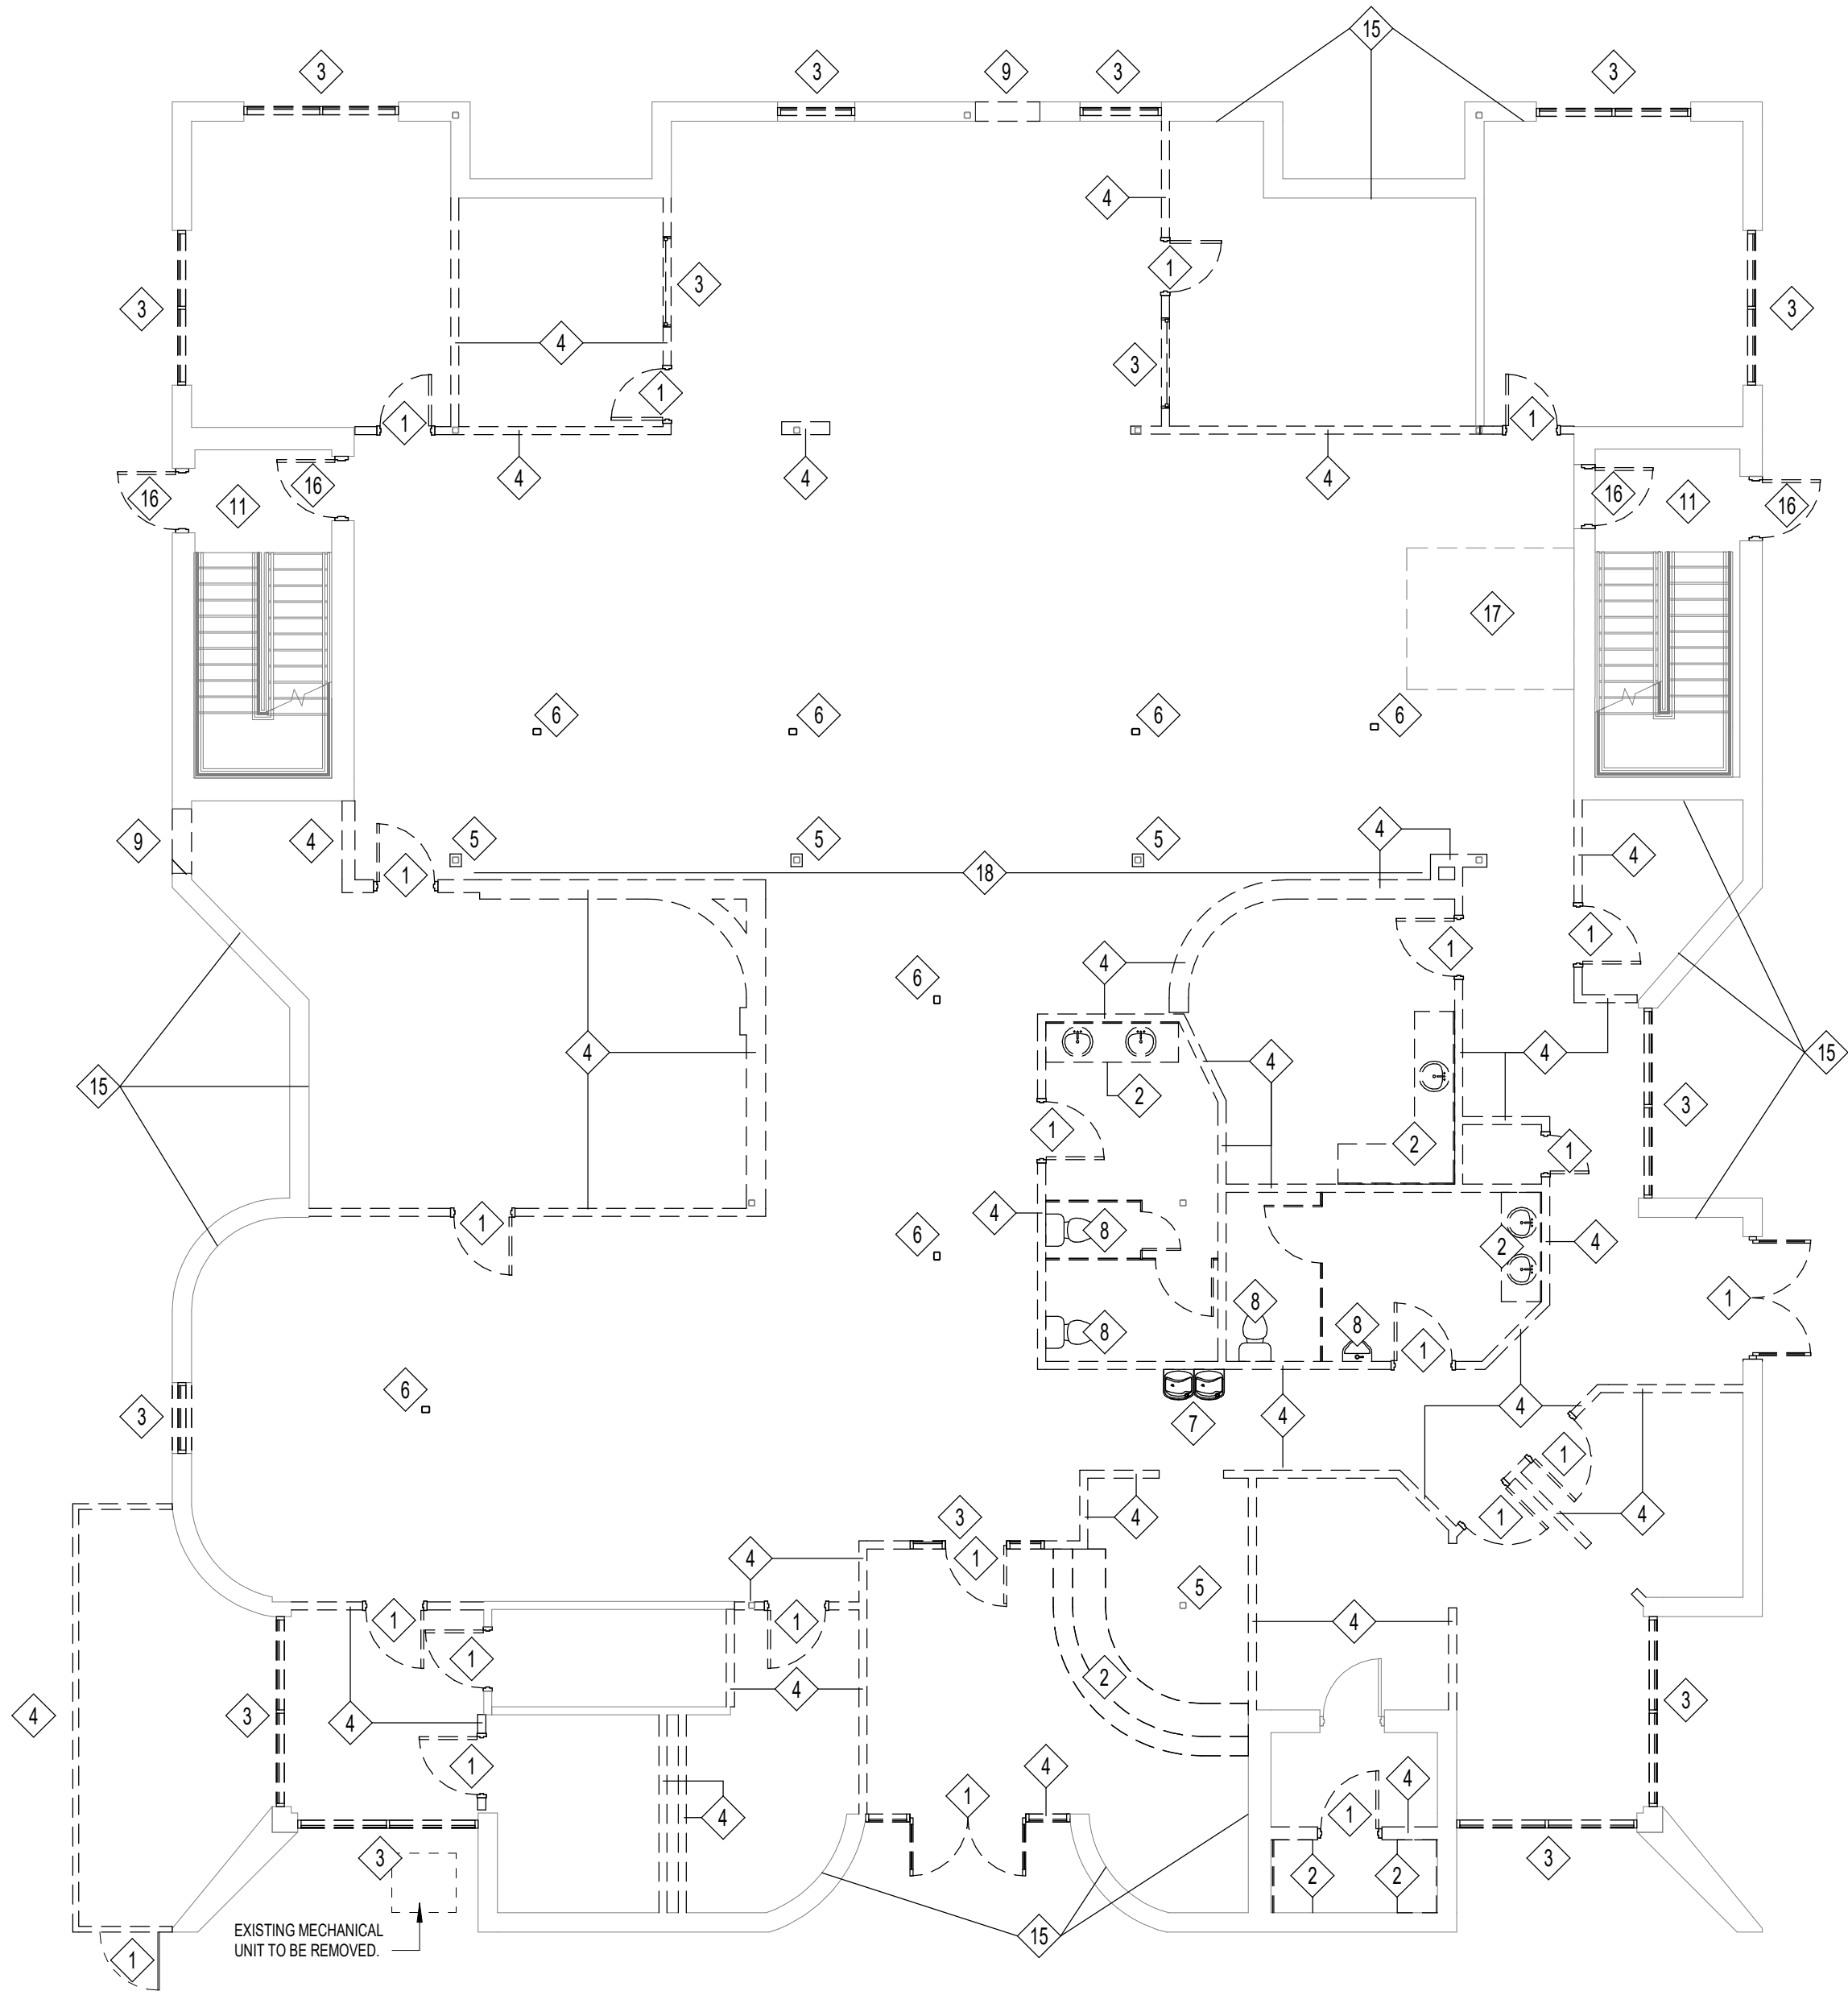

2 FIRST FLOOR DEMOLITION PLAN
1/8" = 1'-0"

DEMOLITION LEGEND

	2X2 EXISTING LAY-IN CEILING TO REMAIN		EXISTING BUILDING TO REMAIN
	2X2 EXISTING LAY IN CEILING WITHIN PROJECT SCOPE. DEMOLISH AND REPLACE ALL CEILING TILES.		DASHED LINE INDICATES WALL OR DOOR AND ALL ASSOCIATED COMPONENTS TO BE DEMOLISHED.
	2X4 LIGHT FIXTURE TO BE RELOCATED		SOLID LINE INDICATES WALL, DOOR, OR CEILING TO REMAIN
	SUPPLY DIFFUSER TO BE RELOCATED		DEMOLITION KEYNOTE TAG


DEMOLITION NOTES

- FIELD VERIFY ALL EXISTING CONSTRUCTION CONDITIONS AND FINISHES PRIOR TO SUBMITTING A BID AND START OF ANY WORK. DISCREPANCIES IN ACTUAL CONDITIONS AND PLANS SHALL BE BROUGHT TO THE ATTENTION OF THE ARCHITECT AND/OR ENGINEER FOR EVALUATION BEFORE SUBMITTING BID AND/OR CONTINUING WITH WORK.
- FIELD VERIFY THE LOCATION OF ALL UTILITIES, INCLUDING BURIAL DEPTH, PRIOR TO START OF ANY WORK. CONDITIONS THAT PROHIBIT THE WORK FROM BEING PERFORMED AS SHOWN SHALL BE BROUGHT TO THE ATTENTION OF THE ARCHITECT AND/OR ENGINEER FOR EVALUATION BEFORE CONTINUING WITH WORK.
- VERIFY WITH THE OWNER PRIOR TO THE START OF WORK THE EXTENT OF DEMOLITION ITEMS TO BE SALVAGED.
- ITEMS NOT BEING SALVAGED SHALL BE TRANSPORTED AND DISPOSED OF IN A LEGAL MANNER IN ACCORDANCE WITH ALL APPLICABLE CODES.
- ADDITIONAL DEMOLITION WORK ASSOCIATED WITH PLUMBING, MECHANICAL, AND ELECTRICAL WORK IS REQUIRED. COORDINATE WORK REQUIRED WITH ALL TRADES.
- ALL DEMOLITION PLUMBING, MECHANICAL, AND ELECTRICAL WORK SHALL BE PERFORMED IN COMPLIANCE WITH ALL APPLICABLE CODES.
- ALL DEMOLITION WORK SHALL BE COORDINATED AND BE PERFORMED IN ACCORDANCE WITH OWNER.
- REMOVE, REPLACE AND/OR REINSTALL ALL EXISTING WALL MOUNTED DEVICE COVER PLATES INCLUDING SWITCHES, RECEPTACLES, OUTLETS, PANEL FACES, RECESSED CABINET FACES, ETC., AS REQUIRED FOR RENOVATION WORK AND PROPER INSTALLATION OF NEW FINISHES. FINISHING/PAINTING AROUND EXISTING NOTED ITEMS WILL NOT BE ACCEPTED.
- SEE SPECIFICATIONS FOR ADDITIONAL DEMOLITION REQUIREMENTS.
- CLEAN AND PREPARE ALL EXISTING SURFACES/SUBSTRATES TO REMAIN AS REQUIRED FOR PROPER INSTALLATION OF NEW FINISHES PER MANUFACTURER'S RECOMMENDATIONS.
- CLEAN AND PREPARE EXISTING SUBSTRATE IN ALL AREAS RECEIVING NEW FLOOR FINISHES AS REQUIRED BY RENOVATION WORK AND FOR PROPER INSTALLATION OF NEW FINISHES PER MANUFACTURER'S RECOMMENDATIONS.
- PERFORM DEMOLITION WORK IN A MANNER SO AS TO MINIMIZE DAMAGE TO EXISTING SURROUNDING ITEMS TO REMAIN.
- PATCH ALL EXISTING FLOORS, WALLS, AND CEILINGS AS REQUIRED FOR DEMOLITION AND RENOVATION WORK INCLUDING ALL PLUMBING, MECHANICAL, AND ELECTRICAL WORK.
- PATCH ALL EXISTING TO REMAIN FLOORS, WALLS, AND CEILINGS THAT ARE DAMAGED DURING THE COURSE OF DEMOLITION WORK INCLUDING ALL PLUMBING, MECHANICAL, AND ELECTRICAL DEMOLITION WORK.
- FURNISH AND INSTALL FLOOR LEVELING COMPOUND AS NECESSARY TO ACHIEVE A SMOOTH AND MONOLITHIC APPEARANCE FOR PROPER INSTALLATION OF NEW FINISHES. NOTIFY ARCHITECT IN ADVANCE IF THE LEVELING COMPOUND SHALL CREATE ANY UNEVEN FLOOR TRANSITIONS.
- CUT AND PATCH EXISTING WALLS AS NECESSARY FOR RENOVATION AND DEMOLITION WORK. WALLS SHALL BE PATCHED TO MATCH ADJACENT EXISTING SURFACES AND PROVIDE A SMOOTH AND SEAMLESS TRANSITION FROM NEW TO EXISTING.
- IT IS THE INTENT OF THESE DOCUMENTS THAT "PATCH" MEANS THAT THE EXISTING CONSTRUCTION SHALL BE REPAIRED IN A MANNER, WITH SAME OR SIMILAR MATERIALS, PROVIDING A SMOOTH AND SEAMLESS TRANSITION FROM NEW TO EXISTING MATERIALS AND THE PATCH SHALL BE PREPARED TO RECEIVE NEW FINISHES PER FINISH MANUFACTURER'S RECOMMENDATIONS.
- IT IS THE INTENT OF THESE DOCUMENTS THAT "PREPARED" MEANS THAT THE EXISTING CONSTRUCTION SHALL BE MADE READY TO RECEIVE NEW FINISHES IN ACCORDANCE WITH FINISH MANUFACTURER'S RECOMMENDATIONS.
- REMOVE ALL WINDOW TREATMENTS FROM ALL WINDOWS WITHIN LIMITS OF WORK AREA. PATCH AND REPAIR EXISTING CONSTRUCTION TO REMAIN AS NECESSARY.
- REMOVE ALL DECORATIVE DOOR TRIM ELEMENTS FROM ALL DOORS WITHIN THE LIMITS OF THE WORK AREA AND REPAIR EXISTING CONSTRUCTION TO REMAIN AS NECESSARY.
- REMOVE ALL MISCELLANEOUS OFFICE TYPE WALL MOUNTED ITEMS WITHIN THE LIMITS OF THE WORK AREA AND REPAIR EXISTING CONSTRUCTION TO REMAIN AS NECESSARY.
- REMOVE ALL EXISTING EXTERIOR LIGHTING FIXTURES, CAMERAS, AND ALL SOFFITS AND FASCIAS.
- PATCH AND REPAIR ANY EXISTING THROUGH-WALL VENTS THAT ARE NO LONGER NEEDED FOR NEW CONSTRUCTION.
- REMOVE ALL EXISTING VINYL WALLCOVERING ON ALL FIRST & SECOND FLOOR WALLS THAT ARE TO REMAIN. PREP ALL EXISTING WALLS TO RECEIVE NEW PAINT PER THE FINISH SCHEDULE.
- REMOVE ALL EXISTING GYPSUM WALLBOARD ON EXISTING TO REMAIN EXTERIOR WALLS.

DEMOLITION KEYNOTES - FLOOR PLAN

- REMOVE EXISTING DOOR FRAME, PANEL, AND ALL RELATED HARDWARE COMPLETELY.
- REMOVE ALL CASEWORK, EMBEDDED PLUMBING FIXTURES, AND RELATED ITEMS ENTIRELY.
- REMOVE EXISTING WINDOW / STOREFRONT SYSTEM AND ALL RELATED COMPONENTS, INCLUDING BLINDS/SHADES, COMPLETELY.
- CUT AND REMOVE EXISTING WALL OR PORTION OF WALL AS INDICATED AND ALL RELATED COMPONENTS ENTIRELY. PATCH AND REPAIR ADJACENT WALLS AS NECESSARY. SALVAGE WALL-MOUNTED ITEMS FOR RE-USE. CONFIRM ALL SALVAGED ITEMS WITH OWNER.
- REMOVE EXISTING COLUMN COVER ENTIRELY.
- REMOVE EXISTING CONDUIT TRACK AND ALL RELATED COMPONENTS ENTIRELY.
- REMOVE EXISTING ELECTRIC WATER COOLER AND ALL HARDWARE ENTIRELY.
- REMOVE EXISTING TOILET, URINAL, TOILET ACCESSORIES, AND ALL RELATED HARDWARE COMPLETELY.
- CUT AND REMOVE PORTION OF EXISTING WALL FOR NEW DOOR AND FRAME. COORDINATE WITH DOOR SCHEDULE AND PROVIDE ALL NECESSARY SUPPORT.
- REMOVE TOILET PARTITION SYSTEM ENTIRELY. PATCH AND REPAIR ADJACENT WALLS AS NECESSARY FOR SMOOTH INSTALLATION OF NEW FINISHES.
- REMOVE ALL WALLPAPER AND FLOORING IN STAIR TOWER. PREP EXISTING SURFACES TO RECEIVE NEW FINISHES PER FINISH SCHEDULE.
- REMOVE GYPSUM BOARD ENTIRELY FROM THE INTERIOR SIDE OF THE EXTERIOR WALLS IN THIS ROOM. CLEAN REMAINING GYPSUM BOARDS AND PREP FOR NEW FINISHES PER FINISH SCHEDULE.
- REMOVE EXISTING MOP SINK AND PREPARE FOR INSTALLATION OF NEW MOP SINK AS SHOWN IN FLOOR PLAN.
- EXISTING ELECTRICAL PANELS. SEE ELECTRICAL PLANS
- REMOVE ALL EXISTING GYPSUM WALLBOARD ON EXTERIOR WALLS TO REMAIN. TYPICAL ALL EXTERIOR WALLS
- REMOVE AND REPLACE ALL EXISTING GYPSUM WALLBOARD ON EXTERIOR WALLS TO REMAIN.
- REMOVE EXISTING DOOR, FRAME, AND ALL RELATED HARDWARE. PREP OPENING FOR NEW DOOR AND FRAME PER DOOR SCHEDULE.
- CUT AND REMOVE PORTION OF EXISTING CONCRETE SLAB FOR NEW ELEVATOR PIT. SEE SECTIONS FOR DETAILS AND EXACT DIMENSIONS. PATCH AND REPAIR ALL ADJACENT SURFACES.
- REMOVE EXISTING SOFFIT AND OLD EXTERIOR WALL FRAMING LOADED ABOVE THE LAY-IN CEILING IN THIS AREA.

Copyright © 2025 Oakley Collier Architects. These drawings are of the property of the Architect for use under his supervision. No reproduction or other use is allowed without permission.

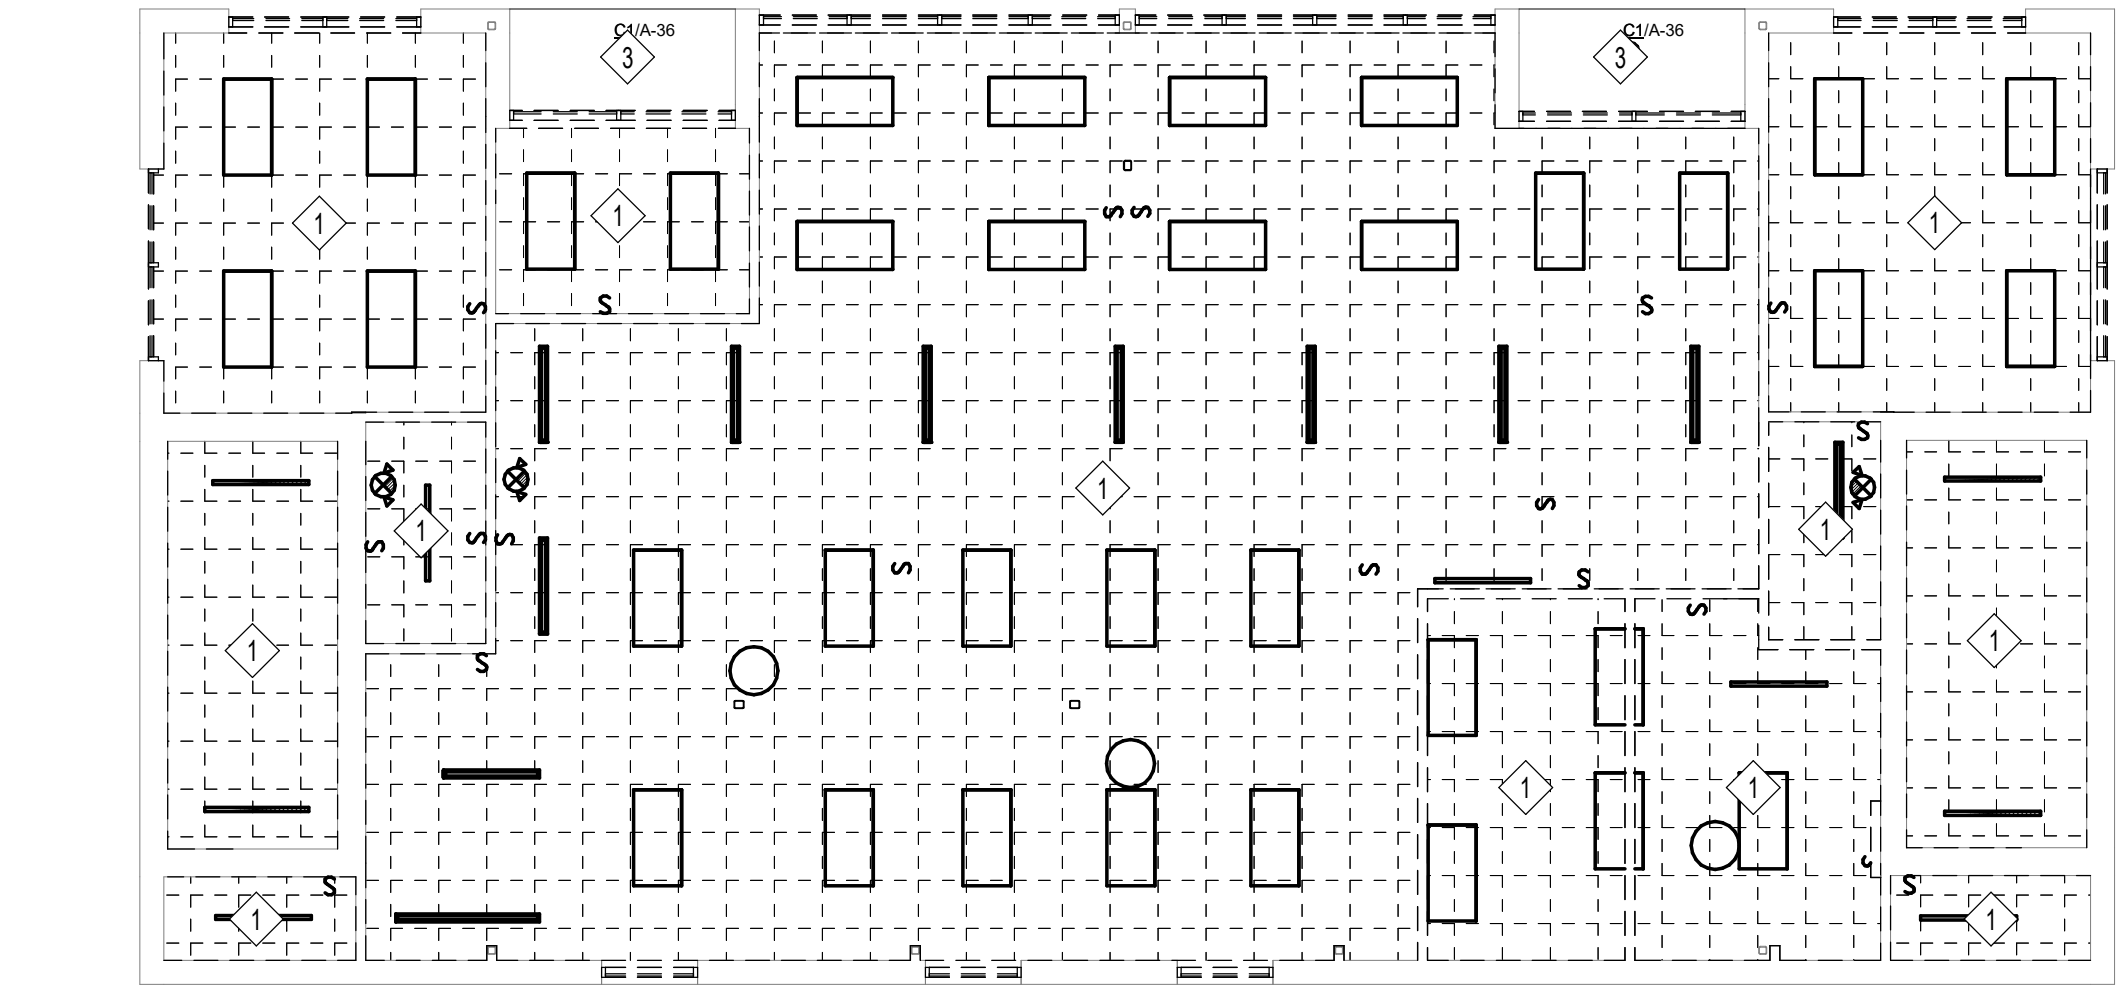

1 SECOND FLOOR DEMOLITION RCP
1/8" = 1'-0"



2 FIRST FLOOR DEMOLITION RCP
1/8" = 1'-0"

DEMOLITION LEGEND

	2X2 EXISTING LAY-IN CEILING TO REMAIN		EXISTING BUILDING TO REMAIN
	2X2 EXISTING LAY IN CEILING WITHIN PROJECT SCOPE, DEMOLISH AND REPLACE ALL CEILING TILES.		DASHED LINE INDICATES WALL OR DOOR AND ALL ASSOCIATED COMPONENTS TO BE DEMOLISHED.
	2X4 LIGHT FIXTURE TO BE RELOCATED		SOLID LINE INDICATES WALL, DOOR, OR CEILING TO REMAIN
	SUPPLY DIFFUSER TO BE RELOCATED		DEMOLITION KEYNOTE TAG

DEMOLITION NOTES

- A. FIELD VERIFY ALL EXISTING CONSTRUCTION CONDITIONS AND FINISHES PRIOR TO SUBMITTING A BID AND START OF ANY WORK. DISCREPANCIES IN ACTUAL CONDITIONS AND PLANS SHALL BE BROUGHT TO THE ATTENTION OF THE ARCHITECT AND/OR ENGINEER FOR EVALUATION BEFORE SUBMITTING BID AND/OR CONTINUING WITH WORK.
- B. FIELD VERIFY THE LOCATION OF ALL UTILITIES, INCLUDING BURIAL DEPTH, PRIOR TO START OF ANY WORK. CONDITIONS THAT PROHIBIT THE WORK FROM BEING PERFORMED AS SHOWN SHALL BE BROUGHT TO THE ATTENTION OF THE ARCHITECT AND/OR ENGINEER FOR EVALUATION BEFORE CONTINUING WITH WORK.
- C. VERIFY WITH THE OWNER PRIOR TO THE START OF WORK THE EXTENT OF DEMOLITION ITEMS TO BE SALVAGED.
- D. ITEMS NOT BEING SALVAGED SHALL BE TRANSPORTED AND DISPOSED OF IN A LEGAL MANNER IN ACCORDANCE WITH ALL APPLICABLE CODES.
- E. ADDITIONAL DEMOLITION WORK ASSOCIATED WITH PLUMBING, MECHANICAL, AND ELECTRICAL WORK IS REQUIRED. COORDINATE WORK REQUIRED WITH ALL TRADES.
- F. ALL DEMOLITION PLUMBING, MECHANICAL, AND ELECTRICAL WORK SHALL BE PERFORMED IN COMPLIANCE WITH ALL APPLICABLE CODES.
- G. ALL DEMOLITION WORK SHALL BE COORDINATED AND BE PERFORMED IN ACCORDANCE WITH OWNER.
- H. REMOVE, REPLACE AND/OR REINSTALL ALL EXISTING WALL MOUNTED DEVICE COVER PLATES INCLUDING SWITCHES, RECEPTACLES, OUTLETS, PANEL FACES, RECESSED CABINET FACES, ETC., AS REQUIRED FOR RENOVATION WORK AND PROPER INSTALLATION OF NEW FINISHES. FINISHING/PAINTING AROUND EXISTING NOTED ITEMS WILL NOT BE ACCEPTED.
- I. SEE SPECIFICATIONS FOR ADDITIONAL DEMOLITION REQUIREMENTS.
- J. CLEAN AND PREPARE ALL EXISTING SURFACES/SUBSTRATES TO REMAIN AS REQUIRED FOR PROPER INSTALLATION OF NEW FINISHES PER MANUFACTURER'S RECOMMENDATIONS.
- K. CLEAN AND PREPARE EXISTING SUBSTRATE IN ALL AREAS RECEIVING NEW FLOOR FINISHES AS REQUIRED BY RENOVATION WORK AND FOR PROPER INSTALLATION OF NEW FINISHES PER MANUFACTURER'S RECOMMENDATIONS.
- L. PERFORM DEMOLITION WORK IN A MANNER SO AS TO MINIMIZE DAMAGE TO EXISTING SURROUNDING ITEMS TO REMAIN.
- M. PATCH ALL EXISTING FLOORS, WALLS, AND CEILINGS AS REQUIRED FOR DEMOLITION AND RENOVATION WORK INCLUDING ALL PLUMBING, MECHANICAL, AND ELECTRICAL WORK.
- N. PATCH ALL EXISTING TO REMAIN FLOORS, WALLS, AND CEILINGS THAT ARE DAMAGED DURING THE COURSE OF DEMOLITION WORK INCLUDING ALL PLUMBING, MECHANICAL, AND ELECTRICAL DEMOLITION WORK.
- O. FURNISH AND INSTALL FLOOR LEVELING COMPOUND AS NECESSARY TO ACHIEVE A SMOOTH AND MONOLITHIC APPEARANCE FOR PROPER INSTALLATION OF NEW FINISHES. NOTIFY ARCHITECT IN ADVANCE IF THE LEVELING COMPOUND SHALL CREATE ANY UNEVEN FLOOR TRANSITIONS.
- P. CUT AND PATCH EXISTING WALLS AS NECESSARY FOR RENOVATION AND DEMOLITION WORK. WALLS SHALL BE PATCHED TO MATCH ADJACENT EXISTING SURFACES AND PROVIDE A SMOOTH AND SEAMLESS TRANSITION FROM NEW TO EXISTING.
- Q. IT IS THE INTENT OF THESE DOCUMENTS THAT "PATCH" MEANS THAT THE EXISTING CONSTRUCTION SHALL BE REPAIRED IN A MANNER, WITH SAME OR SIMILAR MATERIALS, PROVIDING A SMOOTH AND SEAMLESS TRANSITION FROM NEW TO EXISTING MATERIALS AND THE PATCH SHALL BE PREPARED TO RECEIVE NEW FINISHES PER FINISH MANUFACTURER'S RECOMMENDATIONS.
- R. IT IS THE INTENT OF THESE DOCUMENTS THAT "PREPARED" MEANS THAT THE EXISTING CONSTRUCTION SHALL BE MADE READY TO RECEIVE NEW FINISHES IN ACCORDANCE WITH FINISH MANUFACTURER'S RECOMMENDATIONS.
- S. REMOVE ALL WINDOW TREATMENTS FROM ALL WINDOWS WITHIN LIMITS OF WORK AREA. PATCH AND REPAIR EXISTING CONSTRUCTION TO REMAIN AS NECESSARY.
- T. REMOVE ALL DECORATIVE DOOR TRIM ELEMENTS FROM ALL DOORS WITHIN THE LIMITS OF THE WORK AREA AND REPAIR EXISTING CONSTRUCTION TO REMAIN AS NECESSARY.
- U. REMOVE ALL MISCELLANEOUS OFFICE TYPE WALL MOUNTED ITEMS WITHIN THE LIMITS OF THE WORK AREA AND REPAIR EXISTING CONSTRUCTION TO REMAIN AS NECESSARY.
- V. REMOVE ALL EXISTING EXTERIOR LIGHTING FIXTURES, CAMERAS, AND ALL SOFFITS AND FASCIAS.
- W. PATCH AND REPAIR ANY EXISTING THROUGH-WALL VENTS THAT ARE NO LONGER NEEDED FOR NEW CONSTRUCTION.
- X. REMOVE ALL EXISTING VINYL WALLCOVERING ON ALL FIRST & SECOND FLOOR WALLS THAT ARE TO REMAIN. PREP ALL EXISTING WALLS TO RECEIVE NEW PAINT PER THE FINISH SCHEDULE.
- Y. REMOVE ALL EXISTING GYPSUM WALLBOARD ON EXISTING TO REMAIN EXTERIOR WALLS.

DEMOLITION KEYNOTES - RCP



1. REMOVE ALL EXISTING CEILING TILE AND GRID IN THIS ROOM. SALVAGE CLEAN TILES AND ALL CEILING-MOUNTED ITEMS FOR RE-USE. CONFIRM ALL SALVAGED ITEMS WITH OWNER.
2. REMOVE ALL EXISTING GYPSUM CEILING IN THIS ROOM. SALVAGE ALL CEILING-MOUNTED ITEMS FOR RE-USE. CONFIRM ALL SALVAGED ITEMS WITH OWNER.
3. ALTERNATE G-1 - REMOVE EXISTING SOFFIT SHEATHING AS REQUIRED FOR NEW SOFFIT SHEATHING INSTALLATION.

RENOVATION FOR:

CRAVEN COUNTY GOVERNMENT CENTER
EAST

CRAVEN COUNTY


1208 E. MAIN STREET, HAVELock, NORTH CAROLINA 28532

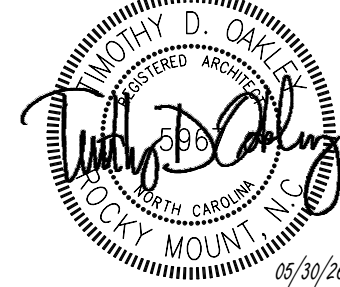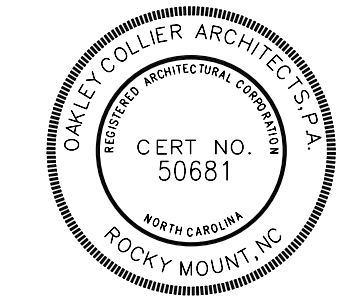


GENERAL NOTE:
Prior to construction start. Contractor shall verify & be responsible for all Dimensions.

Revisions	Description	Date
-----------	-------------	------


Date MAY 30 2026	Project No. 25012
Drawn By ACR	Sheet No. D1.2
Checked By DG	Sheet Title DEMOLITION - REFLECTED CEILING PLAN

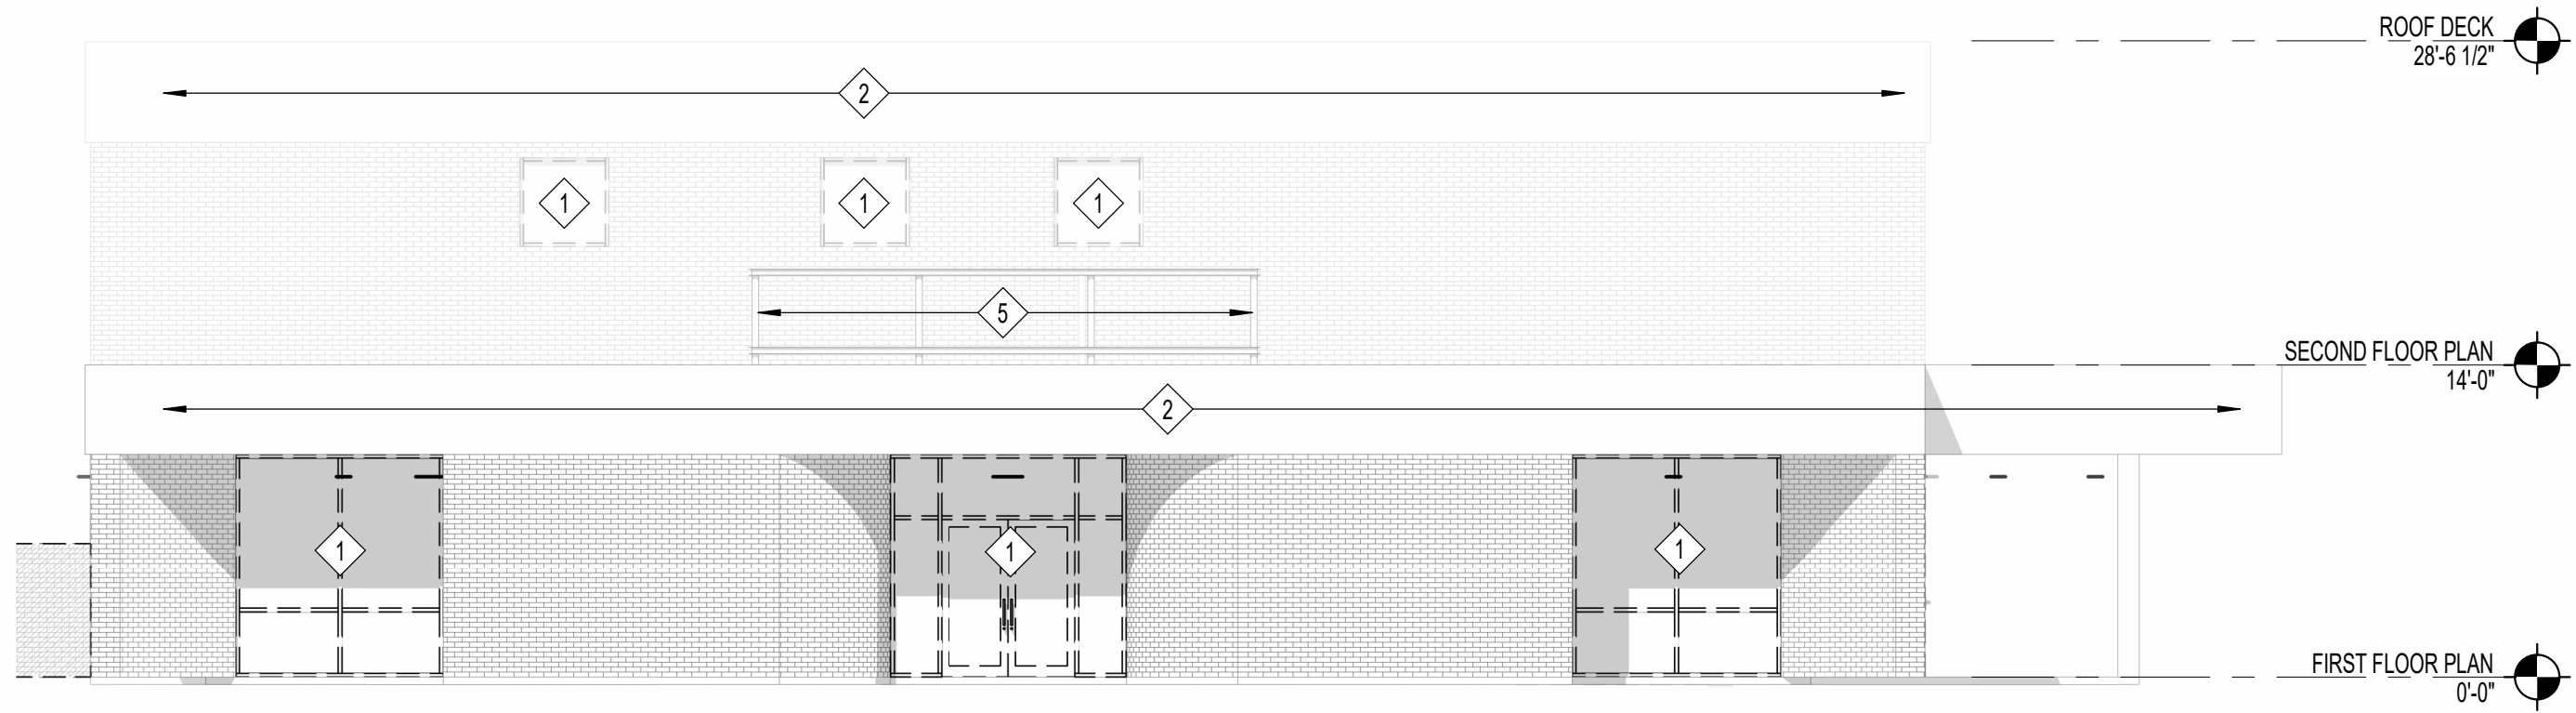


1 WEST DEMO ELEVATION
1/8" = 1'-0"

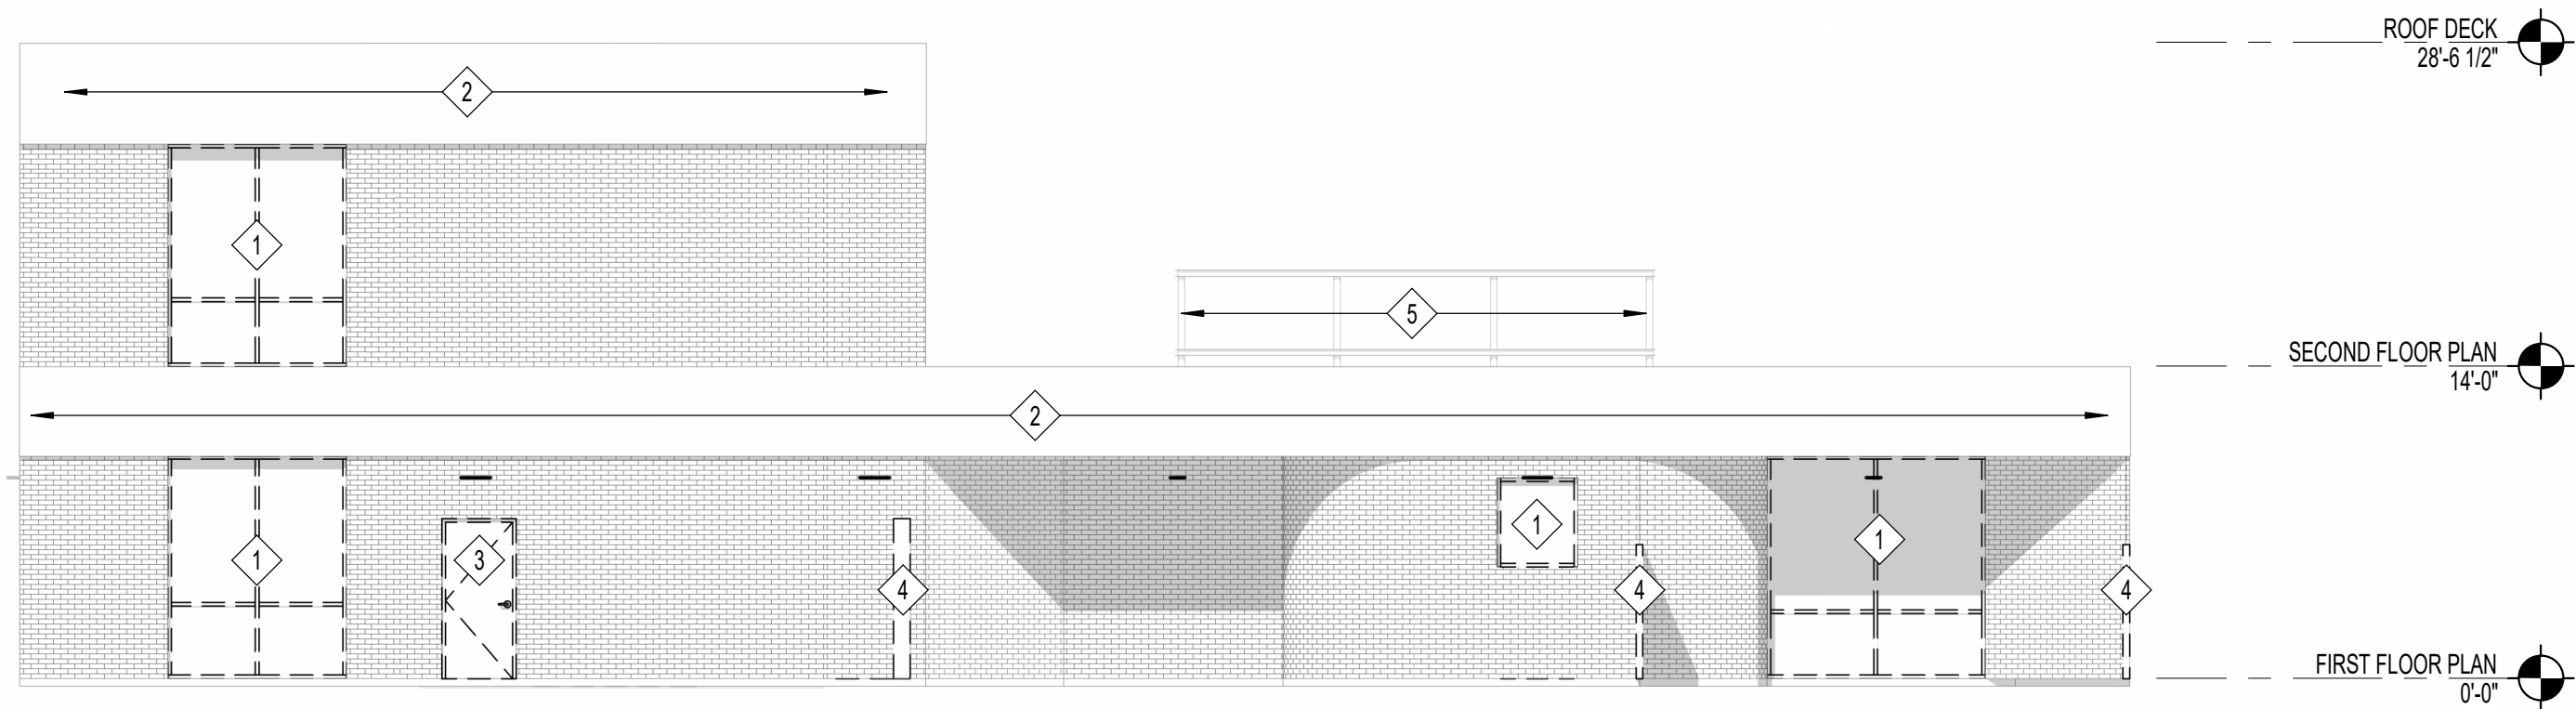

2 NORTH DEMO ELEVATION
1/8" = 1'-0"

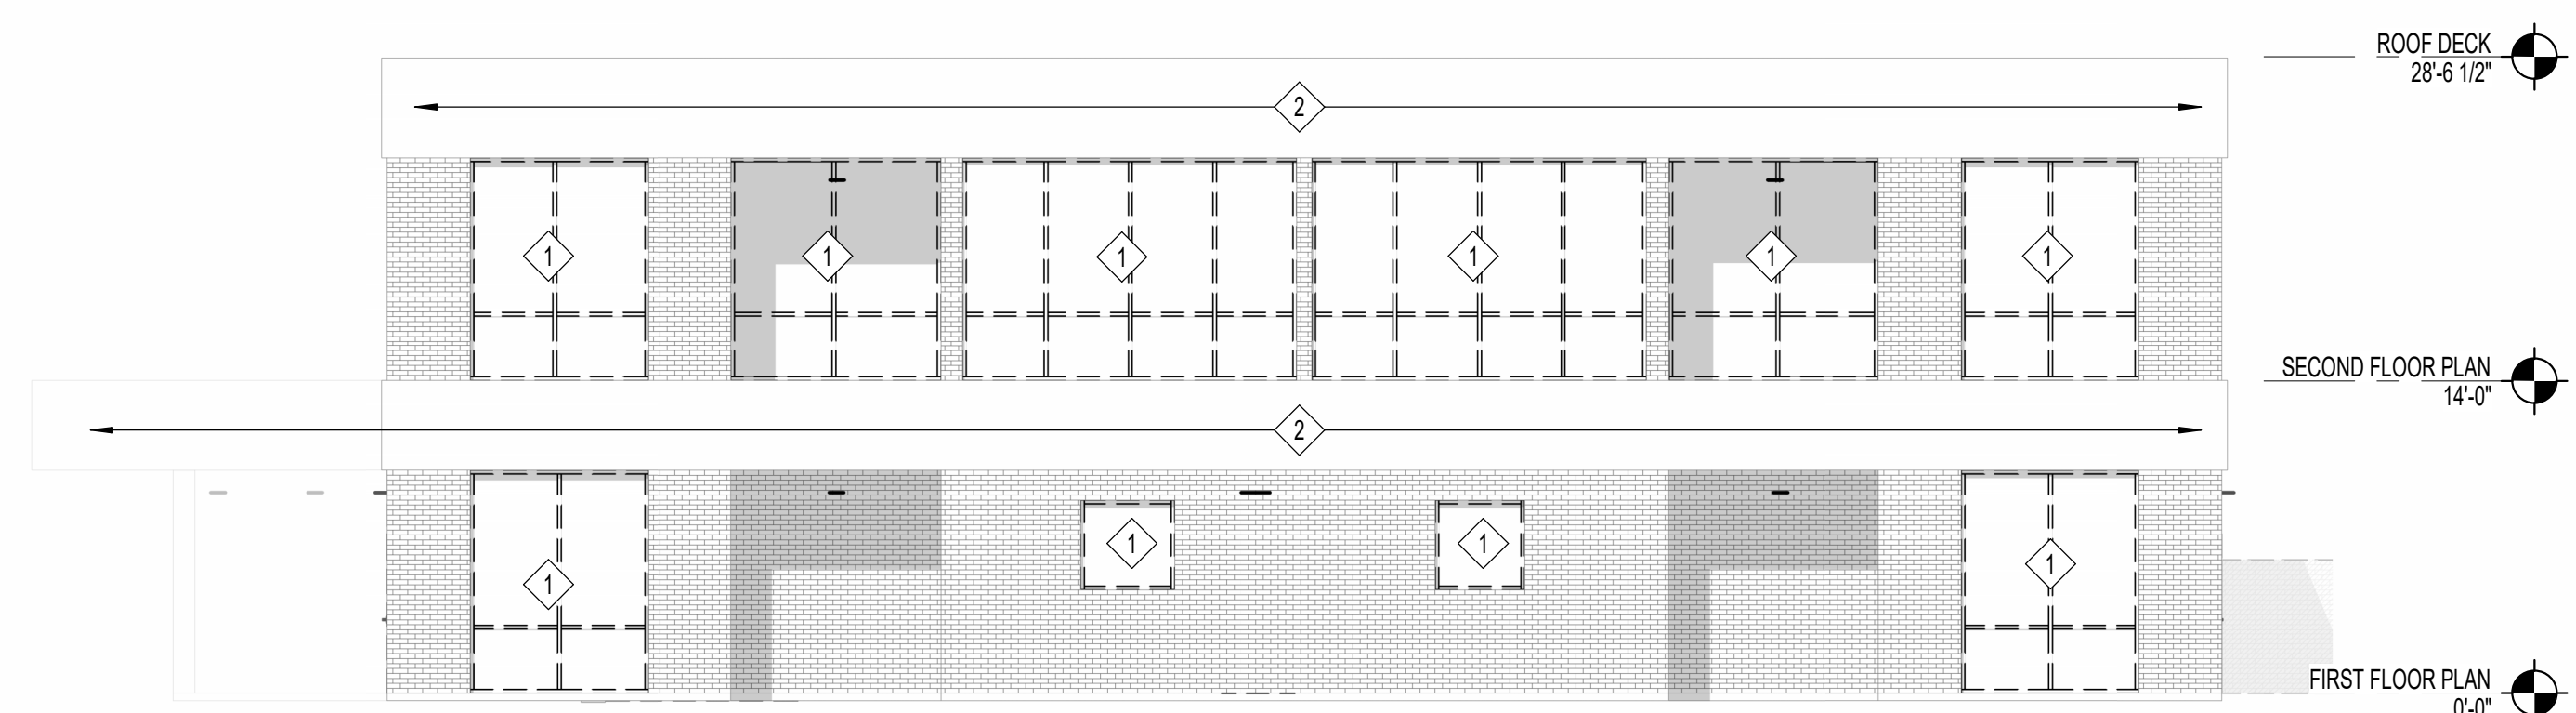

3 EAST DEMO ELEVATION
1/8" = 1'-0"

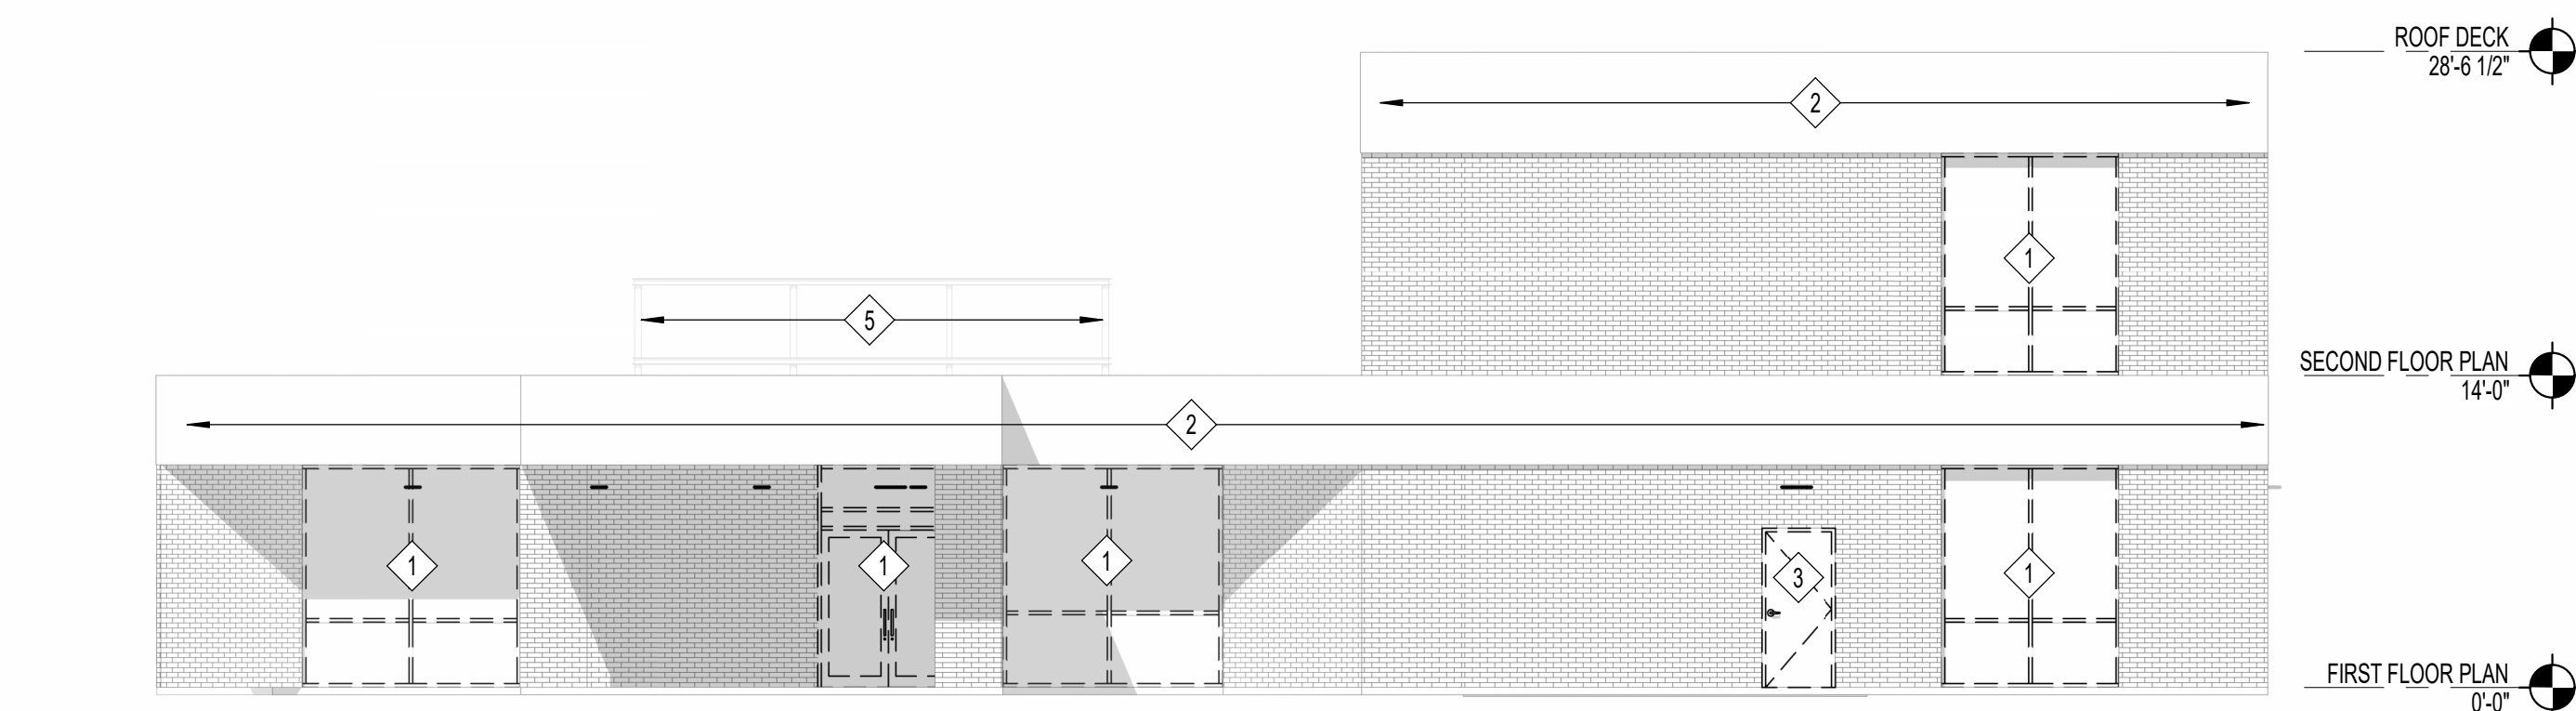

4 SOUTH DEMO ELEVATION
1/8" = 1'-0"

DEMOLITION LEGEND

	2X2 EXISTING LAY-IN CEILING TO REMAIN		EXISTING BUILDING TO REMAIN
	2X2 EXISTING LAY IN CEILING WITHIN PROJECT SCOPE, DEMOLISH AND REPLACE ALL CEILING TILES.		DASHED LINE INDICATES WALL OR DOOR AND ALL ASSOCIATED COMPONENTS TO BE DEMOLISHED.
	2X4 LIGHT FIXTURE TO BE RELOCATED		SOLID LINE INDICATES WALL, DOOR, OR CEILING TO REMAIN
	SUPPLY DIFFUSER TO BE RELOCATED		DEMOLITION KEYNOTE TAG

DEMOLITION NOTES

- FIELD VERIFY ALL EXISTING CONSTRUCTION CONDITIONS AND FINISHES PRIOR TO SUBMITTING A BID AND START OF ANY WORK. DISCREPANCIES IN ACTUAL CONDITIONS AND PLANS SHALL BE BROUGHT TO THE ATTENTION OF THE ARCHITECT AND/OR ENGINEER FOR EVALUATION BEFORE SUBMITTING BID AND/OR CONTINUING WITH WORK.
- FIELD VERIFY THE LOCATION OF ALL UTILITIES, INCLUDING BURIAL DEPTH, PRIOR TO START OF ANY WORK. CONDITIONS THAT PROHIBIT THE WORK FROM BEING PERFORMED AS SHOWN SHALL BE BROUGHT TO THE ATTENTION OF THE ARCHITECT AND/OR ENGINEER FOR EVALUATION BEFORE CONTINUING WITH WORK.
- VERIFY WITH THE OWNER PRIOR TO THE START OF WORK THE EXTENT OF DEMOLITION ITEMS TO BE SALVAGED.
- ITEMS NOT BEING SALVAGED SHALL BE TRANSPORTED AND DISPOSED OF IN A LEGAL MANNER IN ACCORDANCE WITH ALL APPLICABLE CODES.
- ADDITIONAL DEMOLITION WORK ASSOCIATED WITH PLUMBING, MECHANICAL, AND ELECTRICAL WORK IS REQUIRED. COORDINATE WORK REQUIRED WITH ALL TRADES.
- ALL DEMOLITION PLUMBING, MECHANICAL, AND ELECTRICAL WORK SHALL BE PERFORMED IN COMPLIANCE WITH ALL APPLICABLE CODES.
- ALL DEMOLITION WORK SHALL BE COORDINATED AND BE PERFORMED IN ACCORDANCE WITH OWNER.
- REMOVE, REPLACE AND/OR REINSTALL ALL EXISTING WALL MOUNTED DEVICE COVER PLATES INCLUDING SWITCHES, RECEPTACLES, OUTLETS, PANEL FACES, RECESSED CABINET FACES, ETC., AS REQUIRED FOR RENOVATION WORK AND PROPER INSTALLATION OF NEW FINISHES. FINISHING/PAINTING AROUND EXISTING NOTED ITEMS WILL NOT BE ACCEPTED.
- SEE SPECIFICATIONS FOR ADDITIONAL DEMOLITION REQUIREMENTS.
- CLEAN AND PREPARE ALL EXISTING SURFACES/SUBSTRATES TO REMAIN AS REQUIRED FOR PROPER INSTALLATION OF NEW FINISHES PER MANUFACTURER'S RECOMMENDATIONS.
- CLEAN AND PREPARE EXISTING SUBSTRATE IN ALL AREAS RECEIVING NEW FLOOR FINISHES AS REQUIRED BY RENOVATION WORK AND FOR PROPER INSTALLATION OF NEW FINISHES PER MANUFACTURER'S RECOMMENDATIONS.
- PERFORM DEMOLITION WORK IN A MANNER SO AS TO MINIMIZE DAMAGE TO EXISTING SURROUNDING ITEMS TO REMAIN.
- PATCH ALL EXISTING FLOORS, WALLS, AND CEILINGS AS REQUIRED FOR DEMOLITION AND RENOVATION WORK INCLUDING ALL PLUMBING, MECHANICAL, AND ELECTRICAL WORK.
- PATCH ALL EXISTING TO REMAIN FLOORS, WALLS, AND CEILINGS THAT ARE DAMAGED DURING THE COURSE OF DEMOLITION WORK INCLUDING ALL PLUMBING, MECHANICAL, AND ELECTRICAL DEMOLITION WORK.
- FURNISH AND INSTALL FLOOR LEVELING COMPOUND AS NECESSARY TO ACHIEVE A SMOOTH AND MONOLITHIC APPEARANCE FOR PROPER INSTALLATION OF NEW FINISHES. NOTIFY ARCHITECT IN ADVANCE IF THE LEVELING COMPOUND SHALL CREATE ANY UNEVEN FLOOR TRANSITIONS.
- CUT AND PATCH EXISTING WALLS AS NECESSARY FOR RENOVATION AND DEMOLITION WORK. WALLS SHALL BE PATCHED TO MATCH ADJACENT EXISTING SURFACES AND PROVIDE A SMOOTH AND SEAMLESS TRANSITION FROM NEW TO EXISTING.
- IT IS THE INTENT OF THESE DOCUMENTS THAT "PATCH" MEANS THAT THE EXISTING CONSTRUCTION SHALL BE REPAIRED IN A MANNER, WITH SAME OR SIMILAR MATERIALS, PROVIDING A SMOOTH AND SEAMLESS TRANSITION FROM NEW TO EXISTING MATERIALS AND THE PATCH SHALL BE PREPARED TO RECEIVE NEW FINISHES PER FINISH MANUFACTURER'S RECOMMENDATIONS.
- IT IS THE INTENT OF THESE DOCUMENTS THAT "PREPARED" MEANS THAT THE EXISTING CONSTRUCTION SHALL BE MADE READY TO RECEIVE NEW FINISHES IN ACCORDANCE WITH FINISH MANUFACTURER'S RECOMMENDATIONS.
- REMOVE ALL WINDOW TREATMENTS FROM ALL WINDOWS WITHIN LIMITS OF WORK AREA. PATCH AND REPAIR EXISTING CONSTRUCTION TO REMAIN AS NECESSARY.
- REMOVE ALL DECORATIVE DOOR TRIM ELEMENTS FROM ALL DOORS WITHIN THE LIMITS OF THE WORK AREA AND REPAIR EXISTING CONSTRUCTION TO REMAIN AS NECESSARY.
- REMOVE ALL MISCELLANEOUS OFFICE TYPE WALL MOUNTED ITEMS WITHIN THE LIMITS OF THE WORK AREA AND REPAIR EXISTING CONSTRUCTION TO REMAIN AS NECESSARY.
- REMOVE ALL EXISTING EXTERIOR LIGHTING FIXTURES, CAMERAS, AND ALL SOFFITS AND FASCIAS.
- PATCH AND REPAIR ANY EXISTING THROUGH-WALL VENTS THAT ARE NO LONGER NEEDED FOR NEW CONSTRUCTION.
- REMOVE ALL EXISTING VINYL WALLCOVERING ON ALL FIRST & SECOND FLOOR WALLS THAT ARE TO REMAIN. PREP ALL EXISTING WALLS TO RECEIVE NEW PAINT PER THE FINISH SCHEDULE.
- REMOVE ALL EXISTING GYPSUM WALLBOARD ON EXISTING TO REMAIN EXTERIOR WALLS.

DEMOLITION KEYNOTES - ELEVATIONS

- REMOVE EXISTING WINDOW / STOREFRONT SYSTEM AND ALL RELATED COMPONENTS, INCLUDING BLINDS/SHADES, COMPLETELY.
- ALTERNATE G-1 - REMOVING EXISTING EIFS SYSTEM AND SHEATHING
- REMOVE EXISTING DOOR FRAME, PANEL, AND ALL RELATED HARDWARE COMPLETELY.
- CUT AND REMOVE EXISTING WALL OR PORTION OF WALL AS INDICATED AND ALL RELATED COMPONENTS ENTIRELY. PATCH AND REPAIR ADJACENT WALLS AS NECESSARY. SALVAGE WALL-MOUNTED ITEMS FOR RE-USE. CONFIRM ALL SALVAGED ITEMS WITH OWNER.
- REMOVE EXISTING SCREEN WALL PANELS, EXISTING STEEL PIPE COLUMNS AND STEEL SUPPORT FRAME ARE TO REMAIN.


RENOVATION FOR:

CRAVEN COUNTY GOVERNMENT CENTER
EAST

CRAVEN COUNTY
1208 E. MAIN STREET, HAVELock, NORTH CAROLINA 28532

OAKLEY
COLLIER
ARCHITECTS
OCA

107 Condlewood Road, Rocky Mount, NC 27884 (P) 252.931.2500
205 W. Martin Street, Raleigh, NC 27601

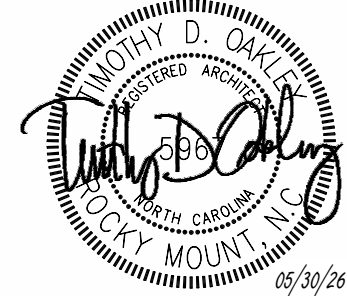

GENERAL NOTE:
Prior to construction start. Contractor shall verify & be responsible for all Dimensions.

Revisions	Description	Date
-----------	-------------	------

Date MAY 30 2026	Project No. 25012
Drawn By ACR	Sheet No. D2.1
Checked By DG	Sheet Title DEMOLITION - ELEVATIONS

Copyright © 2025 Oakley Collier Architects. These drawings are of the property of the Architect for use under his supervision. No reproduction or other use is allowed without permission.

WALL LEGEND																				
INTERIOR STUD WALL - 3 5/8"			INTERIOR STUD WALL - 3 5/8" (SOUND RESISTANT)			INTERIOR STUD WALL - 3 5/8" - 1HR RATED U419			INTERIOR STUD WALL - 3 5/8" (SOUND RESISTANT) - 1HR RATED			INTERIOR STUD WALL - 6" (SOUND-RESISTANT)			INTERIOR STUD WALL - 6" (SOUND-RESISTANT) - 1HR RATED			INTERIOR CHASE WALL - 1 1/2"		
MARK	PLAN VIEW	REMARKS	MARK	PLAN VIEW	REMARKS	MARK	PLAN VIEW	REMARKS	MARK	PLAN VIEW	REMARKS	MARK	PLAN VIEW	REMARKS	MARK	PLAN VIEW	REMARKS	MARK	PLAN VIEW	REMARKS
1A		TOP OF WALL = TIGHT TO DECK	1B		TOP OF WALL = TIGHT TO DECK	1C		TOP OF WALL = TIGHT TO DECK	1D		TOP OF WALL = TIGHT TO DECK	2B		TOP OF WALL = TIGHT TO DECK	2D		TOP OF WALL = TIGHT TO DECK	3		TOP OF WALL = TIGHT TO DECK

- KEYNOTES - FLOOR PLAN**
- EXISTING COLUMN. VERIFY EXACT LOCATION IN FIELD.
 - INFILL WALL AS REQ'D AROUND NEW DOOR. USE BRICK FACADE TO MATCH ADJACENT EXISTING BRICK. SEE ELEVATIONS
 - NEW COUNTY SEAL, SEE BUILDING ELEVATIONS.
 - NEW MOP SINK; SEE PME.
 - UTILITY SHELF TO BE INSTALLED IN THIS ROOM. FOR DETAILS ON THE UTILITY SHELF, SEE SHEET TOILET ACCESSORY CHART.

INTERIOR / EXTERIOR - ELEVATOR SHAFT WALL - 1HR RATED		
MARK	PLAN VIEW	REMARKS
4		TOP OF WALL = TIGHT TO DECK

GENERAL FLOOR PLAN NOTES

A. DIMENSIONS ON THIS PLAN ARE FROM: FACE OF EXTERIOR WALL TO CENTERLINE OF INTERIOR WALLS. VERIFY ALL DIMENSIONS IN-FIELD AND ALIGN ALL NEW WALLS TO BE FLUSH WITH EXISTING WALLS WHERE ADJACENT.

B. PROVIDE BRACING BACK TO STRUCTURE FOR INTERIOR WALLS, TYPICAL.

C. ALL DRYWALL SHALL BE 5/8" AND SHALL EXTEND 4" MINIMUM ABOVE FINISH CEILING (U.N.O.)

D. INSTALL SOUND ATTENUATION BATT INSULATION FULL HEIGHT IN ALL INTERIOR STUD FRAMED WALLS.

E. INSTALL SOUND ATTENUATION BATT INSULATION 4" WIDE AROUND CEILING PERIMETER OF ALL ROOMS WITH SOUND BATT IN WALLS.

F. VERIFY ALL DIMENSIONS AND SIZES PRIOR TO CONSTRUCTION.


G. SCHEDULE AND COORDINATE ALL INSPECTIONS REQUIRED.

H. OBTAIN ALL PERMITS REQUIRED.


I. COORDINATE ALL SCHEDULES WITH THE OWNER PRIOR TO CONSTRUCTION.

J. REFER TO STRUCTURAL PLANS FOR ALL STRUCTURAL HEADERS.

K. SEE DOOR AND WINDOW SCHEDULES FOR ALL DOOR AND WINDOW SIZES.

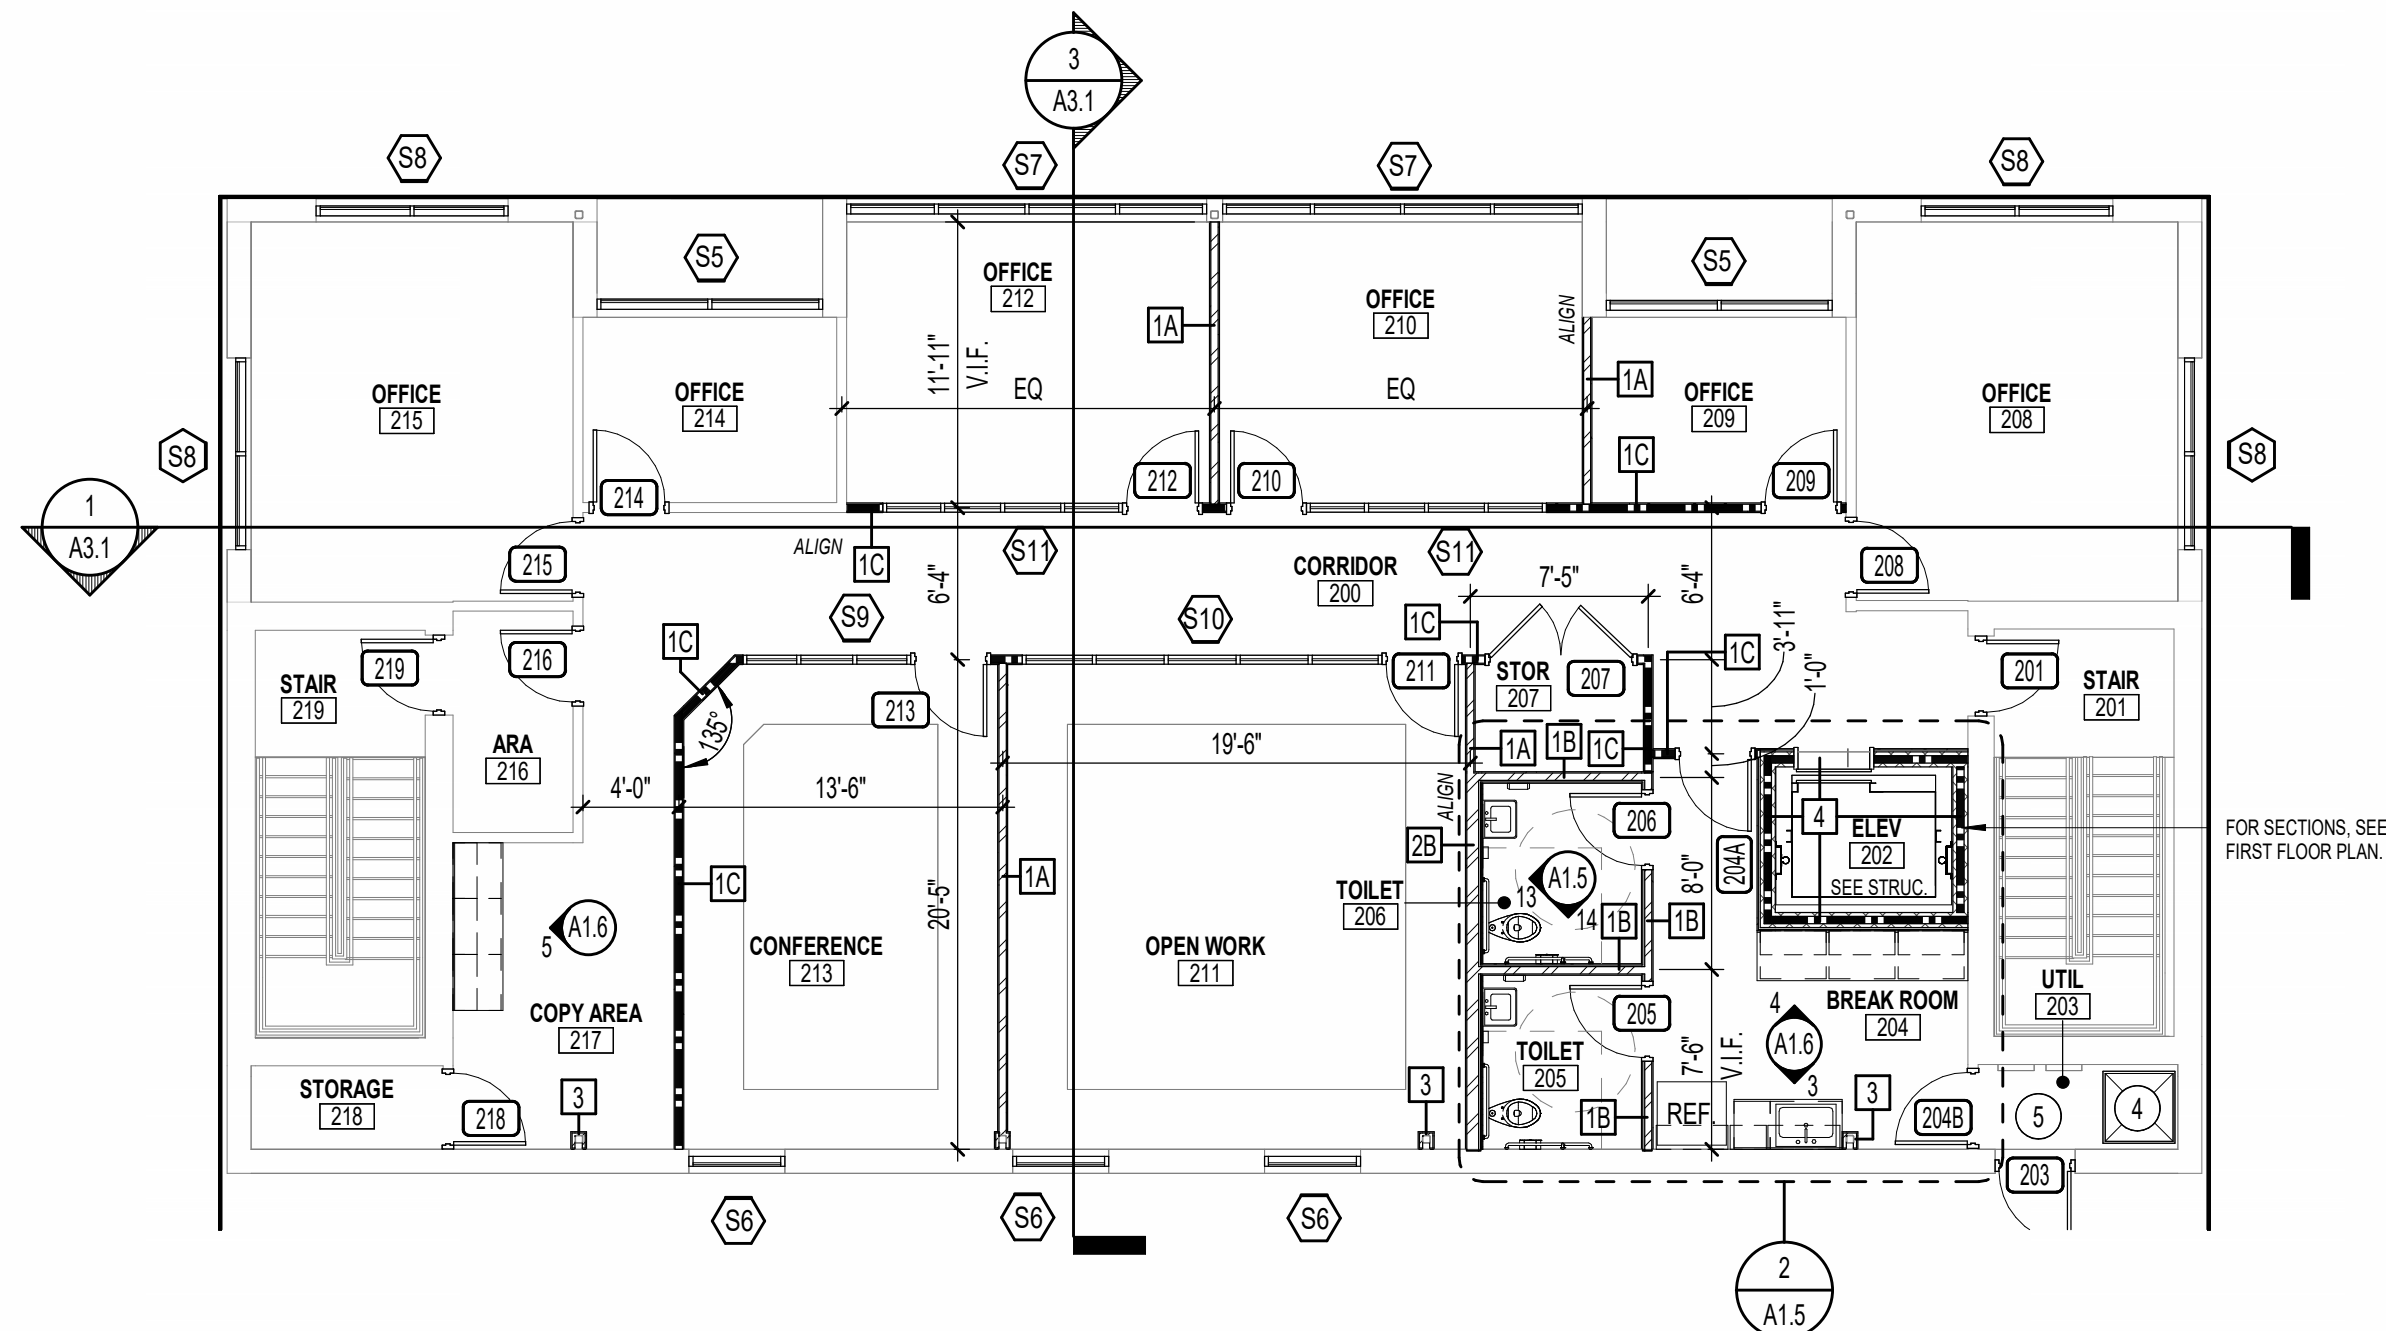

2 SECOND FLOOR PLAN
1/8" = 1'-0"

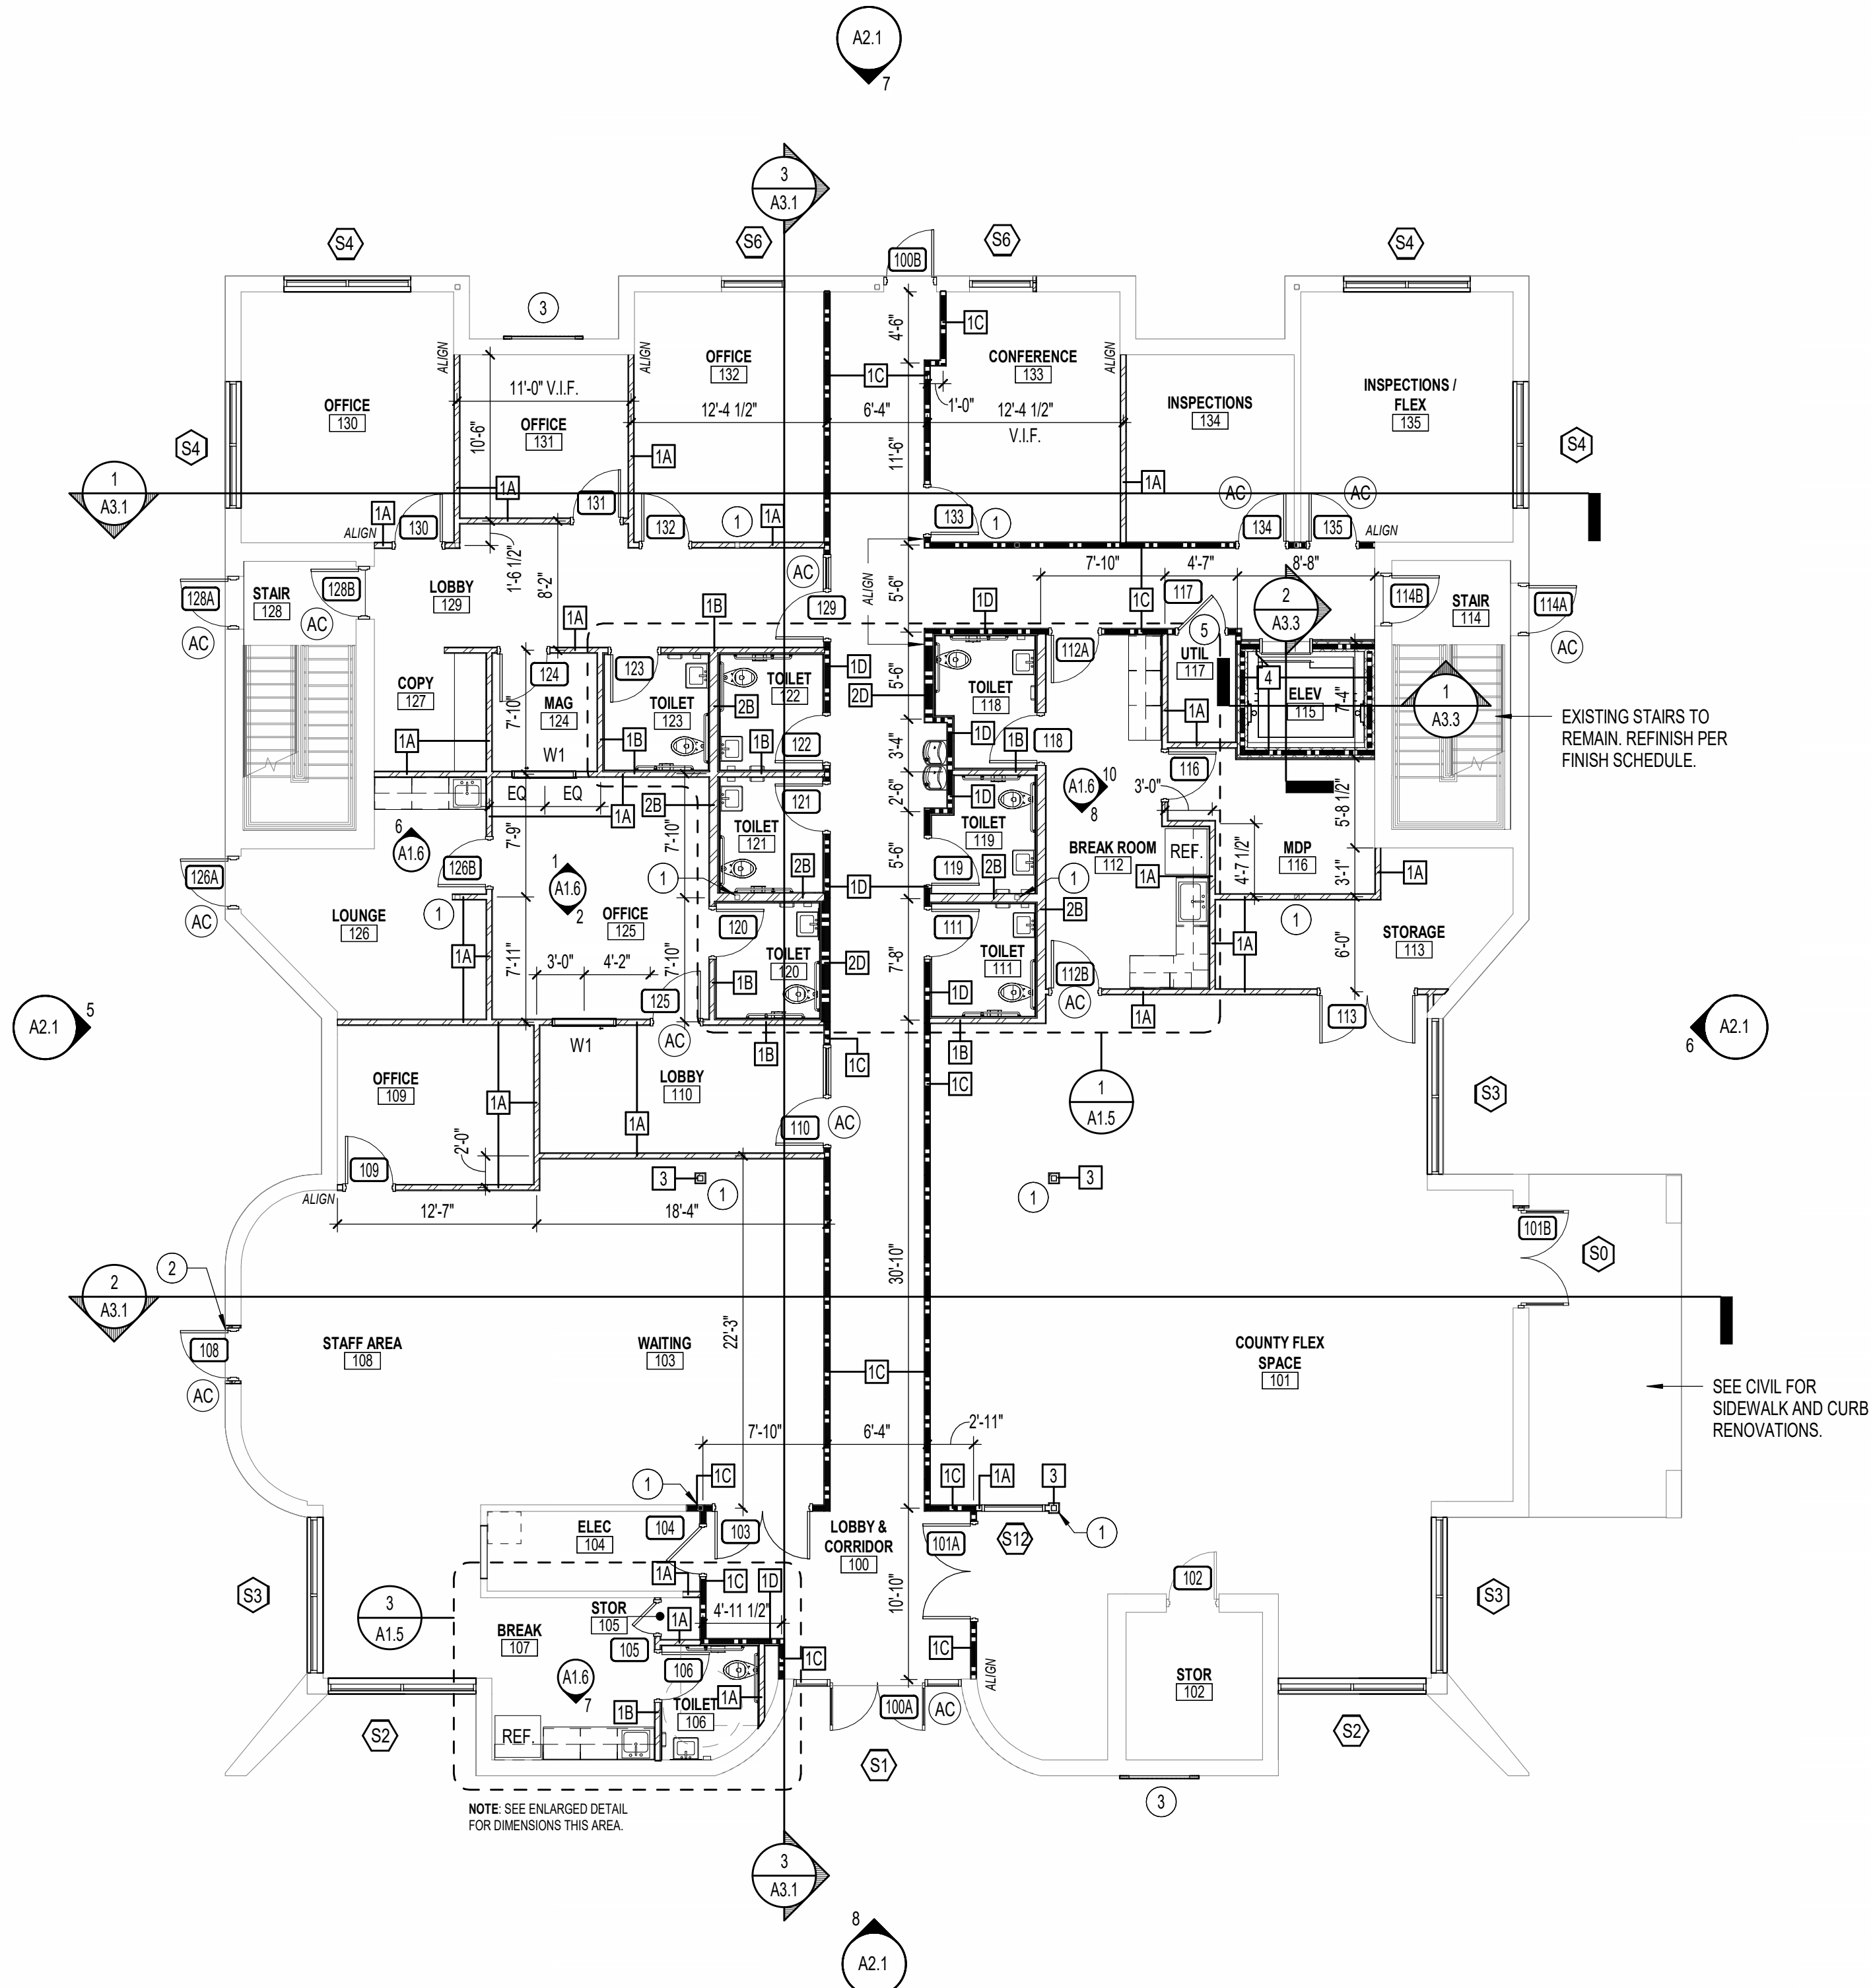

1 FIRST FLOOR PLAN
1/8" = 1'-0"

OAKLEY
COLLIER
ARCHITECTS
OCA

107 Condevwood Road, Rocky Mount, NC 27884 | P: 252.931.2500
205 W. Main Street, Raleigh, NC 27601

RENOVATION FOR:
**CRAVEN COUNTY GOVERNMENT CENTER
EAST**
CRAVEN COUNTY
1208 E. MAIN STREET, HAVELock, NORTH CAROLINA 28532




GENERAL NOTE:
Prior to construction start, Contractor shall verify & be responsible for all Dimensions.


Revisions	Description	Date
-----------	-------------	------

Date MAY 30 2026	Project No. 25012
Drawn By ACR	Sheet No. A1.1
Checked By DG	Sheet Title FLOOR PLANS


Copyright © 2025 Oakley Collier Architects. These drawings are of the property of the Architect for use under his supervision. No reproduction or other use is allowed without permission.

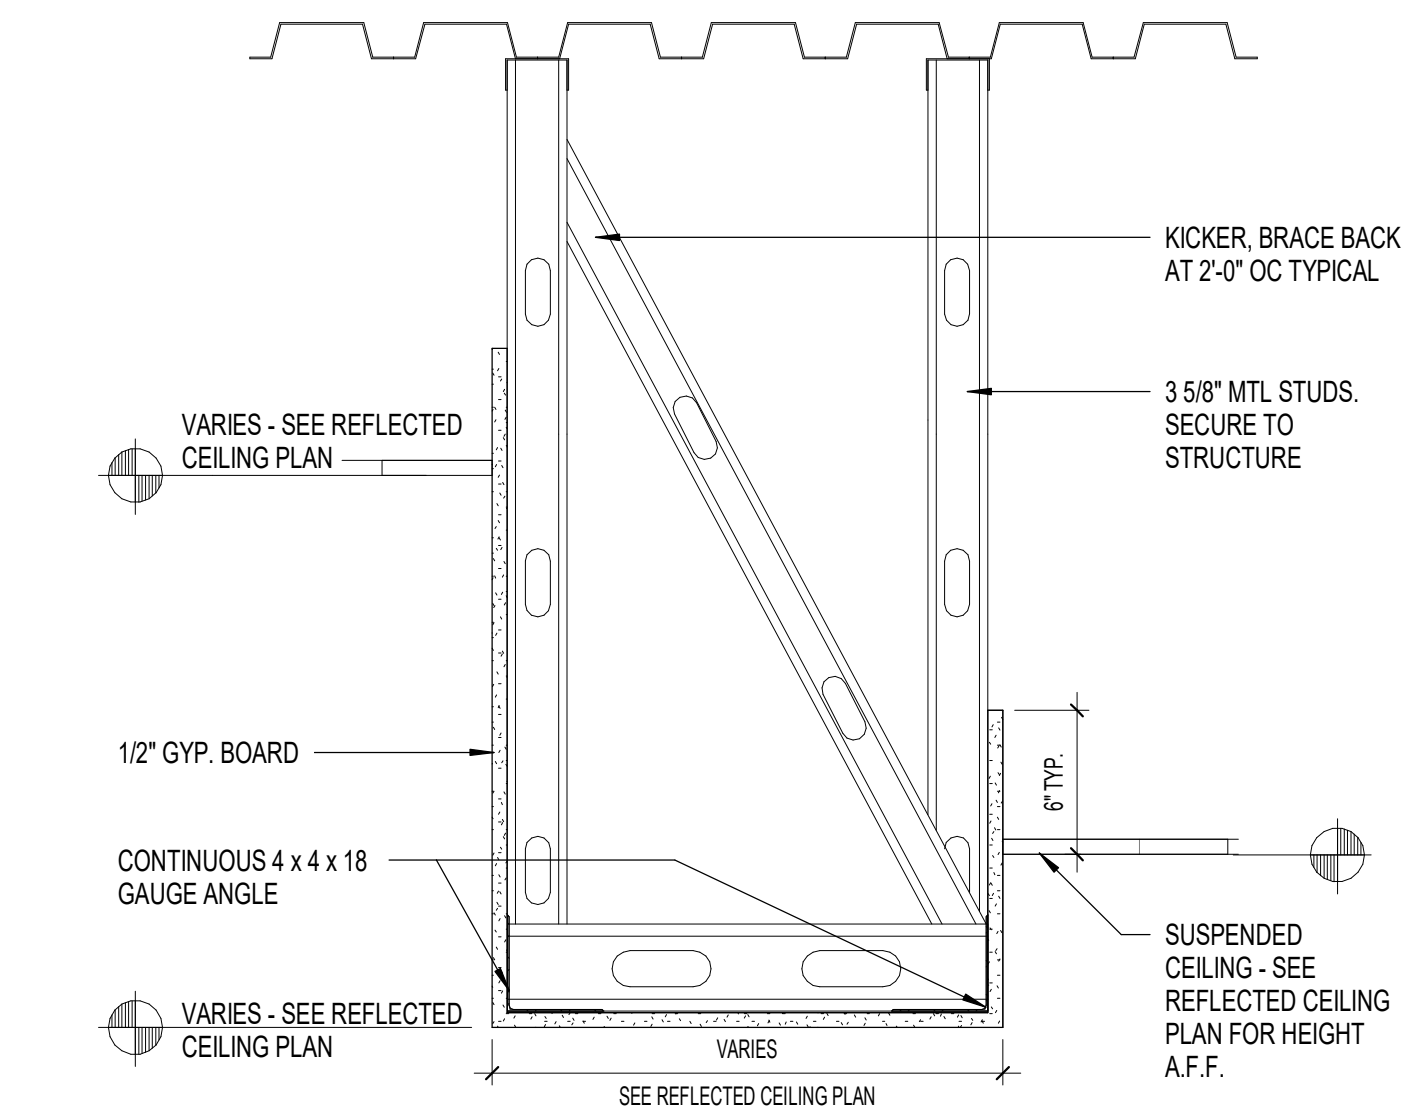

3 TYP BULKHEAD DETAIL
1 1/2" = 1'-0"

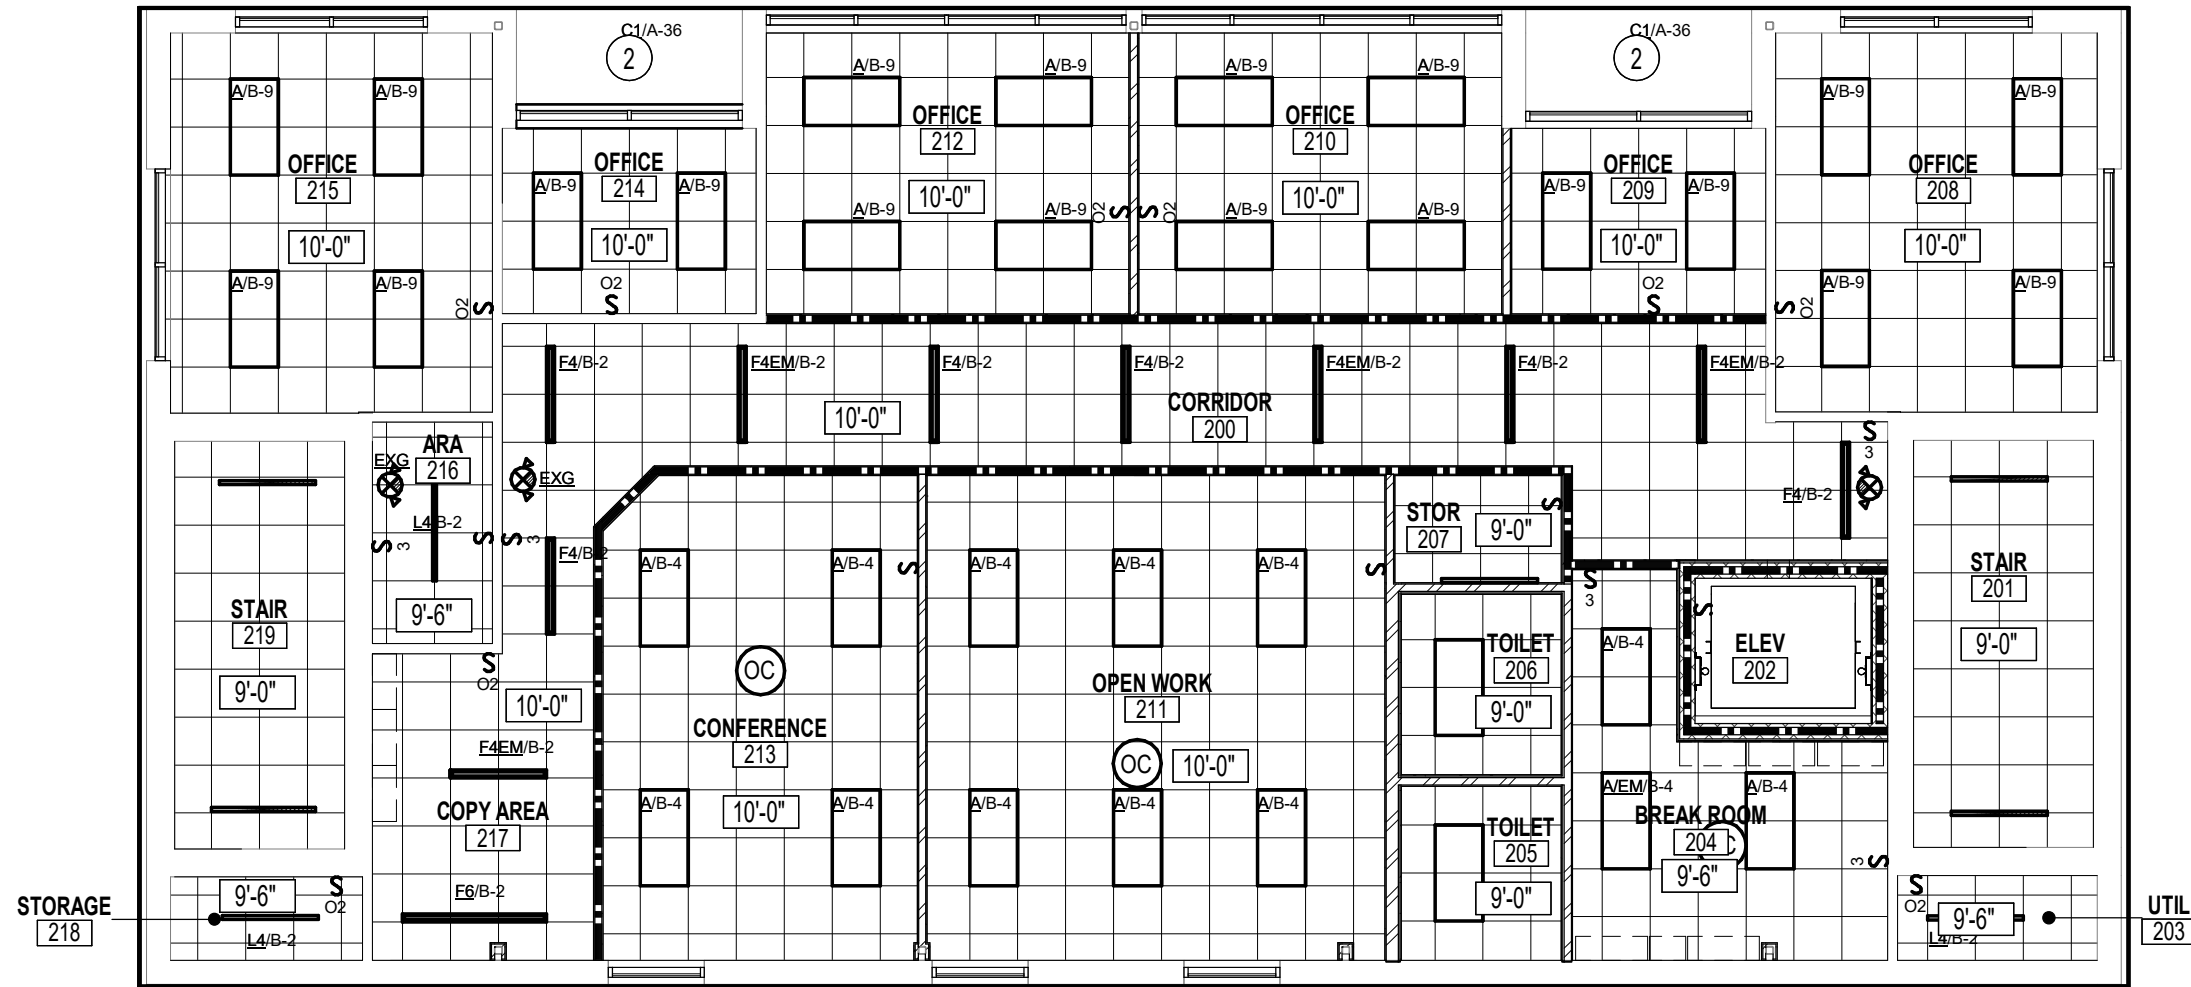

2 SECOND FLOOR RCP
1/8" = 1'-0"

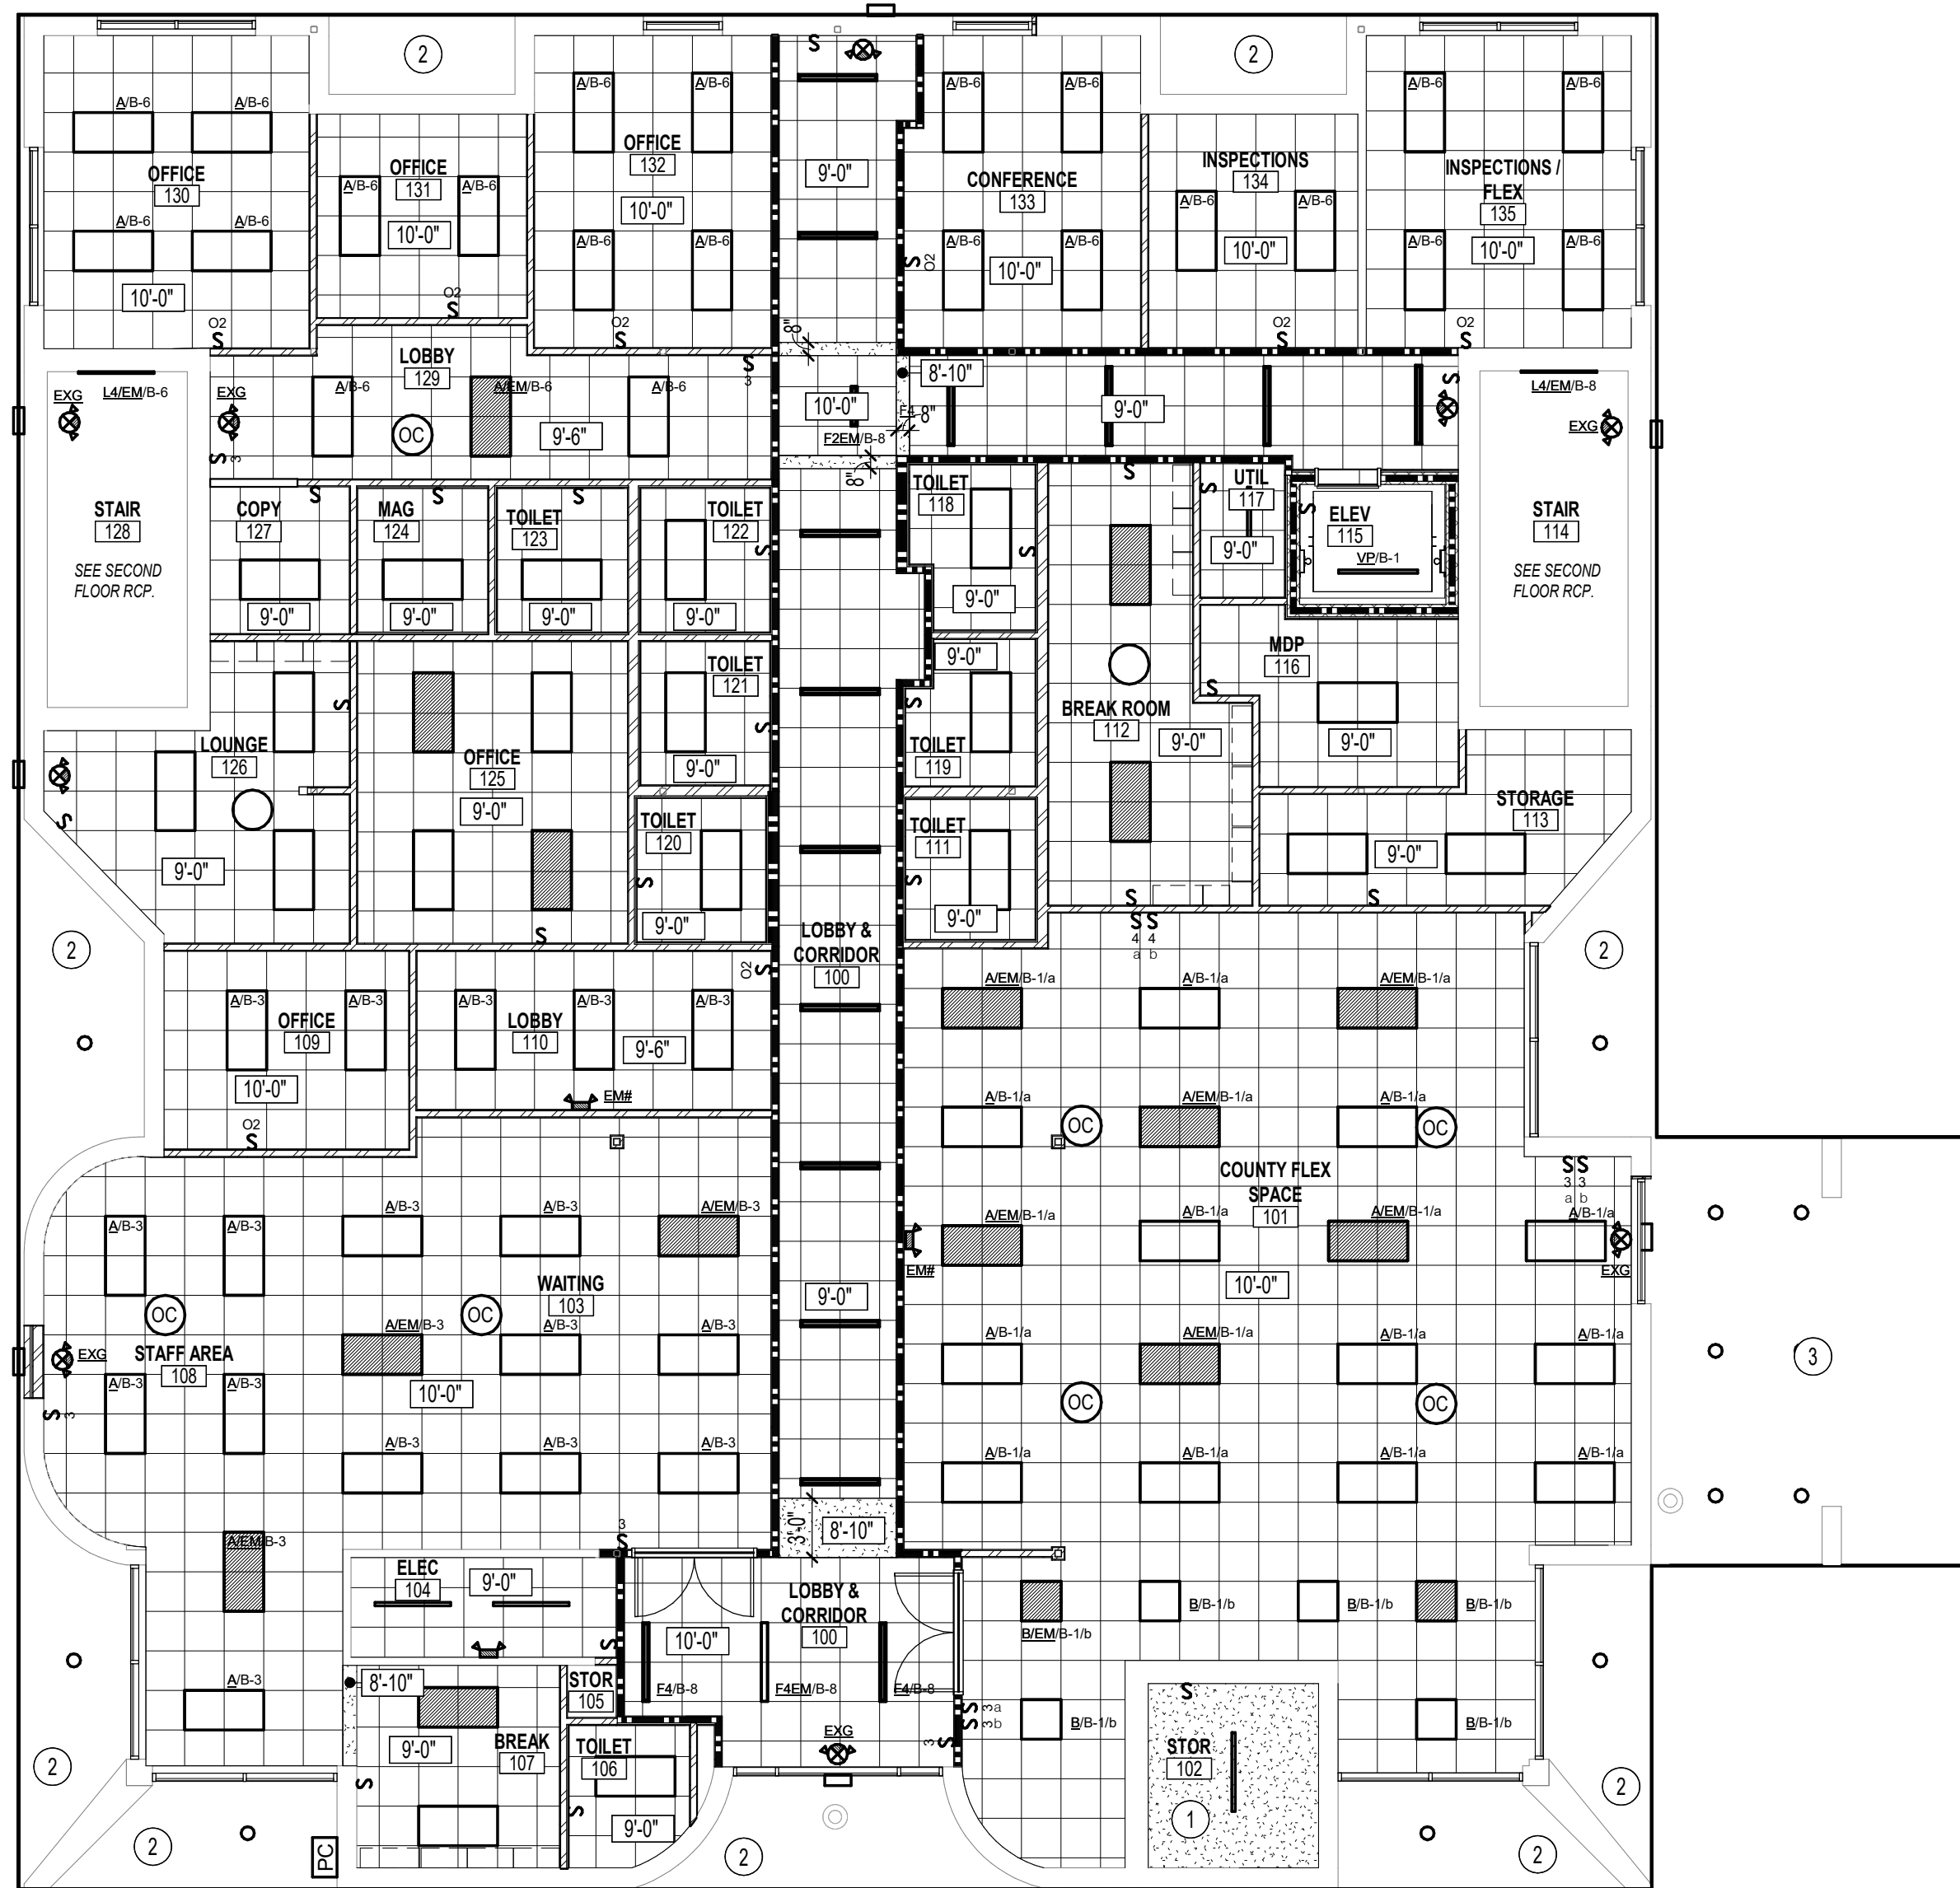

1 FIRST FLOOR RCP
1/8" = 1'-0"

LEGEND

	ACT-1: 2X2 LAY-IN CEILING SYSTEM		HIGH BAY LED LIGHTING FIXTURE
	ACT-2: 2X2 LAY-IN CEILING SYSTEM (VINYL COATED) TYP IN WET LOCATIONS		8' BAR LIGHT FIXTURE
	5/8" GYPSUM BOARD		CAN LIGHT FIXTURE
	CEILING HEIGHT KEY		LED VERTICAL PENDANT FIXTURE
			WALL MOUNTED TELEVISION

CEILING NOTES

- SEE MECHANICAL, ELECTRICAL, PLUMBING, AND FIRE PROTECTION PLANS FOR FULL DESCRIPTION OF CEILING MOUNTED ITEMS/DEVICES
- ALL GRIDS ARE CENTERED IN A ROOM UNLESS NOTED OTHERWISE.
- REFER TO REFLECTED CEILING PLANS FOR CEILING HEIGHTS AND FINISH PLANS FOR CEILING TYPES.
- CONTRACTOR TO REVIEW LAYOUT AND NOTIFY ARCHITECT OF ACOUSTICAL CEILING PANELS THAT ARE LESS THAN 3" IN WIDTH OR LENGTH.
- ALL NEW LIGHT FIXTURES, EXIT SIGNS, SPRINKLER HEADS AND TERMINAL DEVICES TO BE CENTERED IN CEILING PANELS, UNLESS OTHERWISE INDICATED.
- NOT ALL MEP DEVICES ARE SHOWN IN CEILING PLANS, SEE MEP DRAWINGS FOR LOCATIONS AND QUANTITIES.
- FOR PENDANT MOUNTING HEIGHT REFER TO ELEVATIONS AND REFLECTED CEILING PLAN LEGEND


KEYNOTES - RCP

- BASE BID - PATCH AND REPAIR EXISTING EIFS SOFFIT AS REQUIRED, RE-PAINT. ALTERNATE G-1 - REMOVE EXISTING SOFFIT AND REPLACE WITH 5/8" GLASSMAT SHEATHING AND DEFS FINISH.
- BASE BID - PATCH AND REPAIR EXISTING SOFFITS AS REQUIRED AND REPAIR. ALTERNATE G-1 - REMOVE EXISTING SOFFIT AND REPLACE WITH NEW GLASSMAT SHEATHING AND DEFS FINISH
- REPLACE OLD GYPSUM CEILING BOARD WITH NEW BOARD, ALIGN TO EXISTING CEILING HEIGHT. (PAINTED)

RENOVATION FOR:

CRAVEN COUNTY GOVERNMENT CENTER
EAST

CRAVEN COUNTY
1208 E. MAIN STREET, HAVELock, NORTH CAROLINA 28532

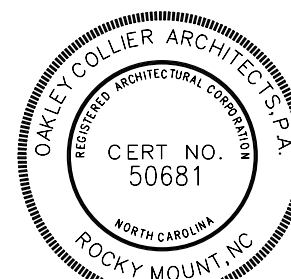


GENERAL NOTE:
Prior to construction start. Contractor shall verify & be responsible for all Dimensions.


Revisions
Description Date

Date MAY 30 2026	Project No. 25012
Drawn By ACR	Sheet No. A1.2
Checked By DG	
Sheet Title REFLECTED CEILING PLANS	


Copyright © 2025 Oakley Collier Architects. These drawings are of the property of the Architect for use under his supervision. No reproduction or other use is allowed without permission.

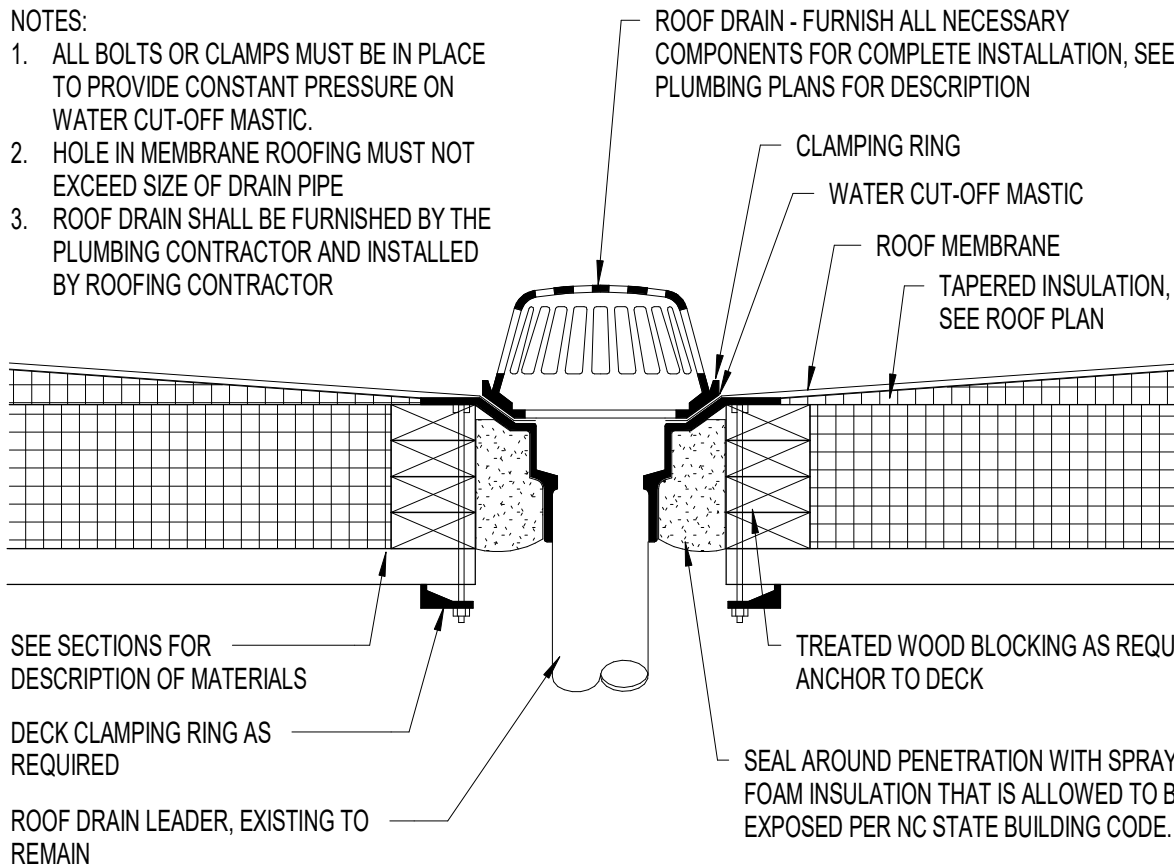


2
A1.3
1 1/2" = 1'-0"

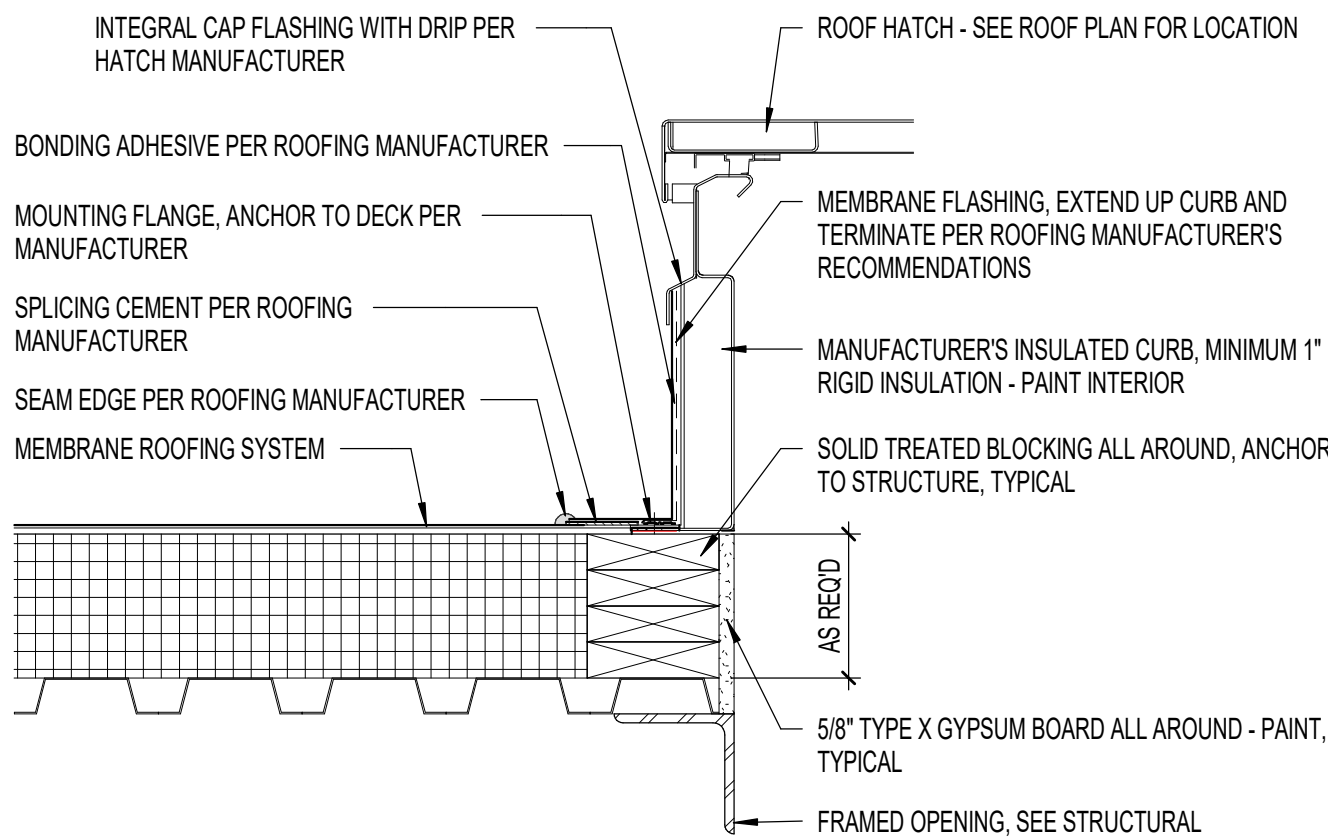


5
A1.3
1 1/2" = 1'-0"

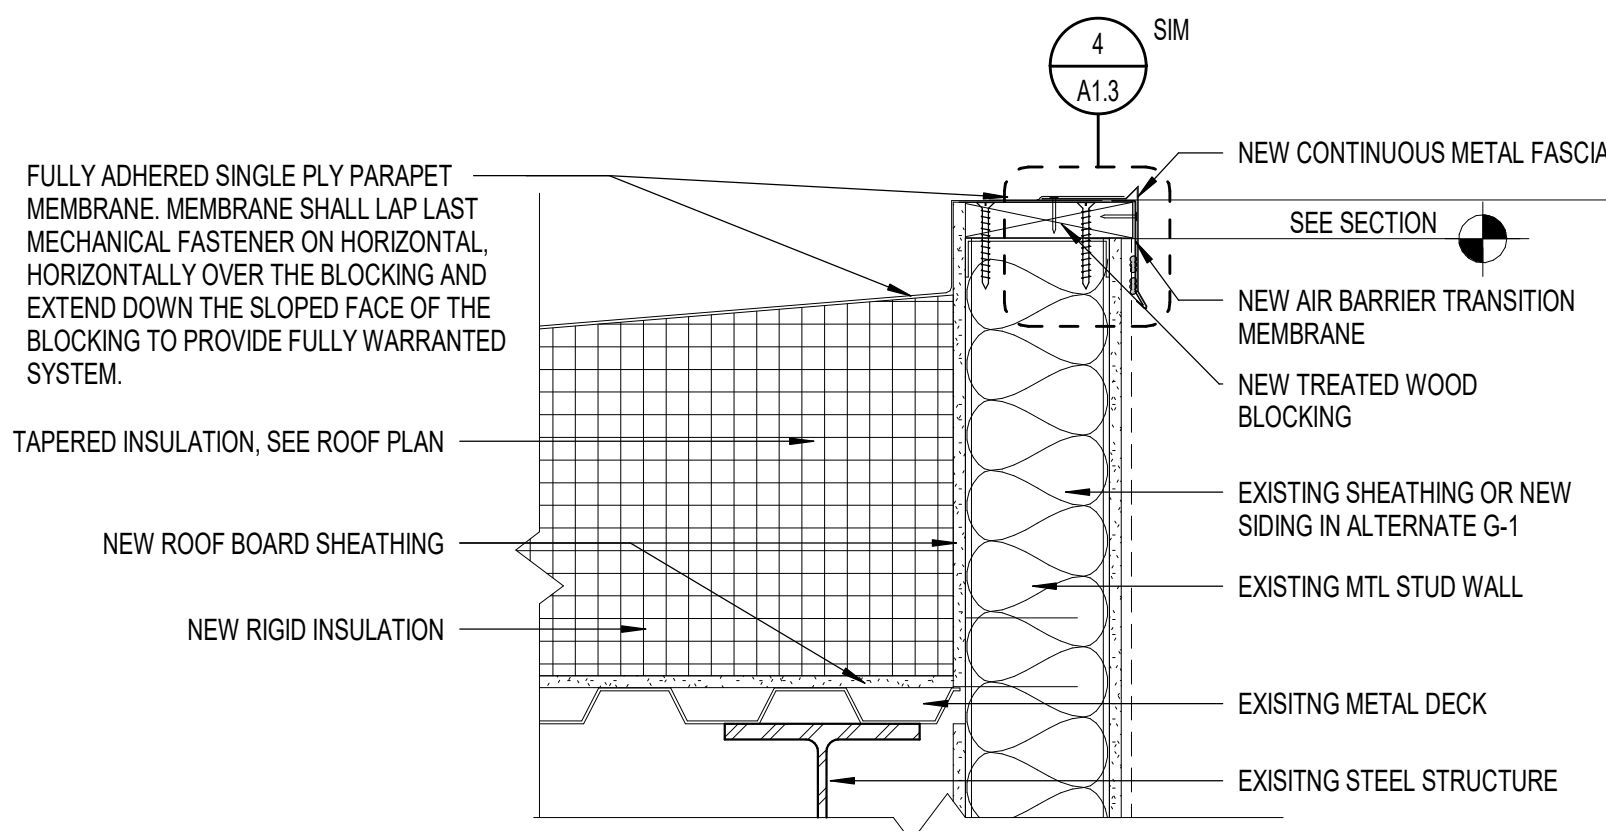

3
A1.3
1 1/2" = 1'-0"

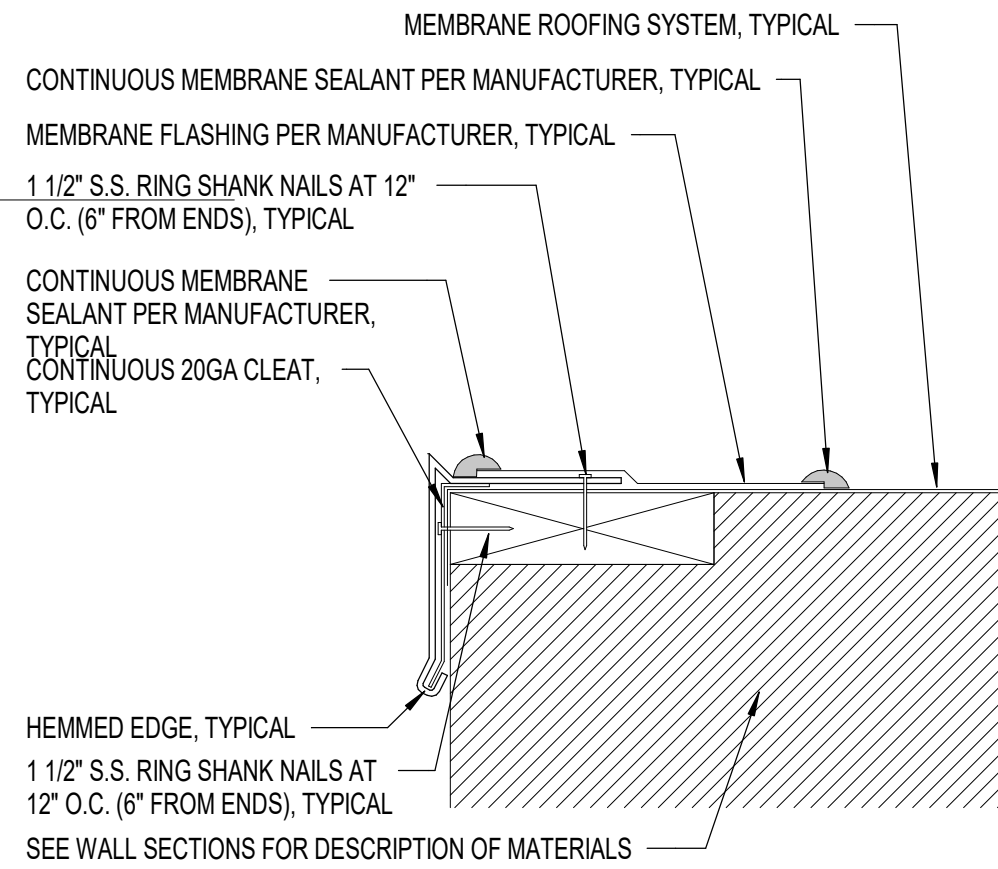

4
A1.3
3" = 1'-0"

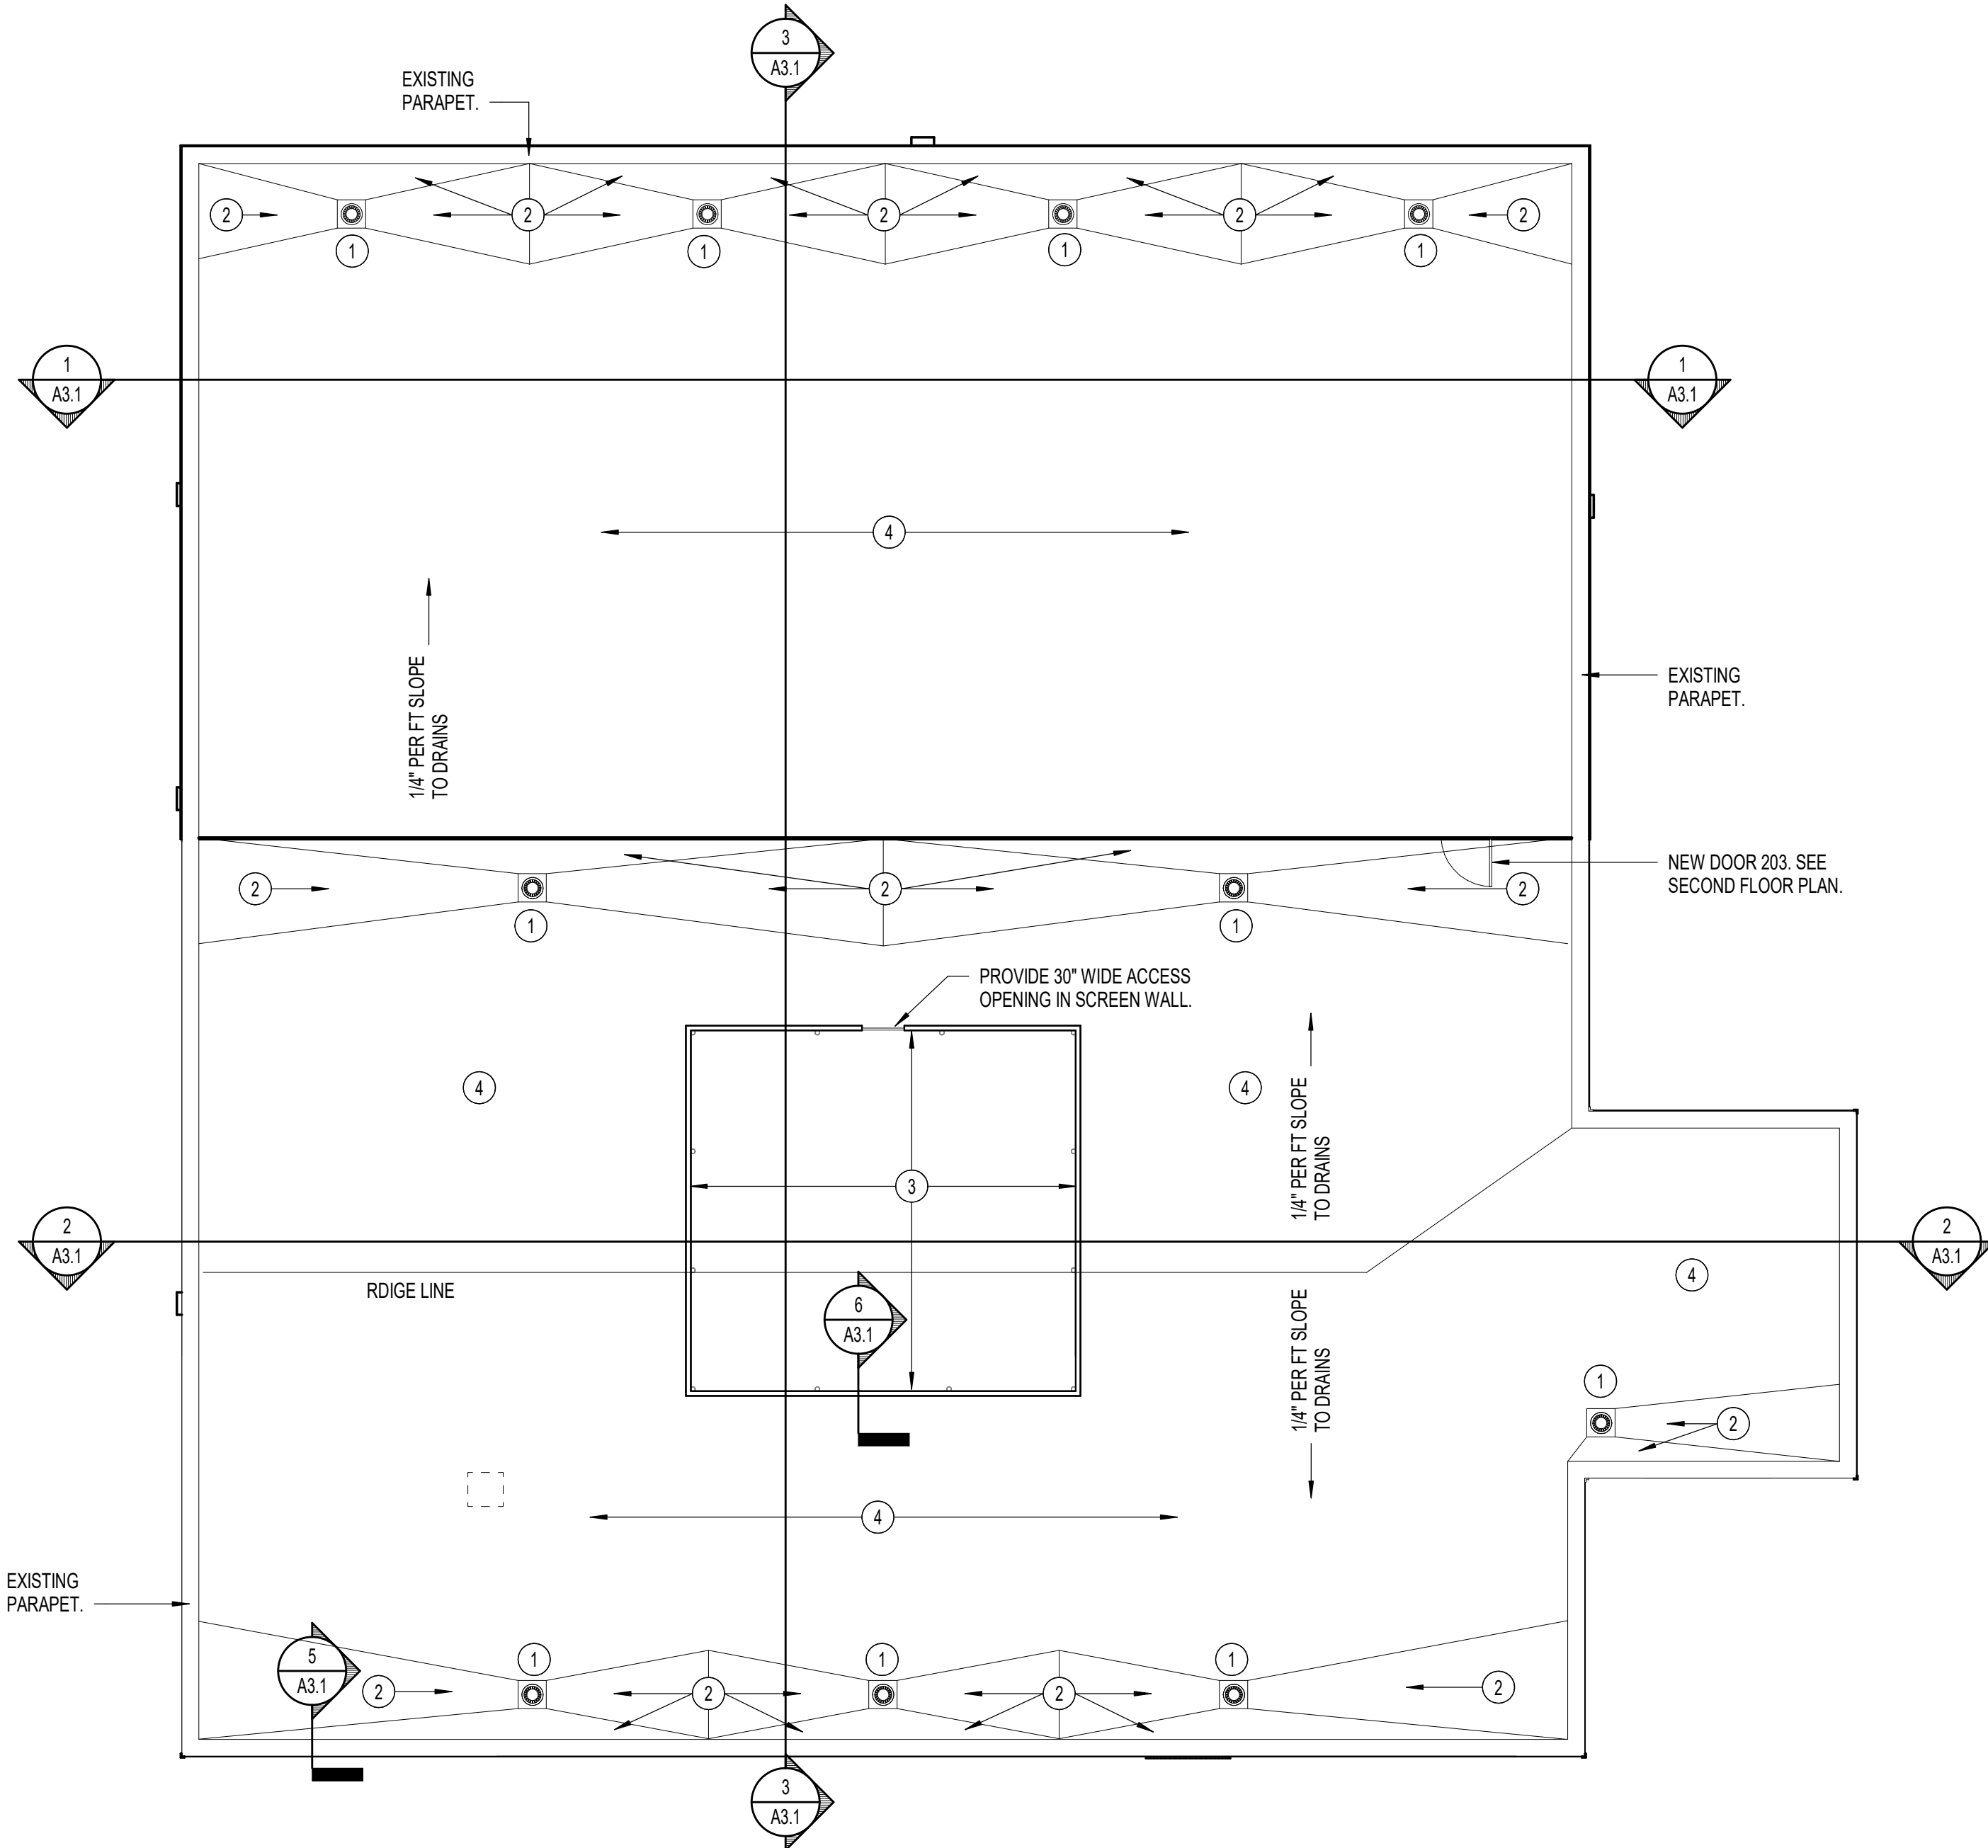

1
A1.3
1/8" = 1'-0"

ROOF LEGEND

- INDICATES DIRECTION OF ROOF SLOPE ACHIEVED THRU STRUCTURE AND TAPERED INSULATION.
- * INDICATES THICKNESS OF TAPERED INSULATION ABOVE PRIMARY ROOF INSULATION AND UNDERLAYMENT BOARD IF REQUIRED - REFER TO WALL SECTIONS AND STRUCTURAL FOR ACTUAL ELEVATIONS.
- RD PRIMARY ROOF DRAIN, REFER TO PLUMBING PLANS FOR DESCRIPTION, TYPICAL.
- OD SECONDARY (EMERGENCY) ROOF DRAIN, REFER TO PLUMBING PLANS FOR DESCRIPTION, TYPICAL
- SC THROUGH WALL SCUPPER SECONDARY (EMERGENCY) ROOF DRAIN, TYPICAL.

GENERAL ROOF NOTES

- CONTRACTOR SHALL COORDINATE ALL ROOF MOUNTED EQUIPMENT AND PENETRATIONS REQUIRED AND MAKE ALL NECESSARY PROVISIONS FOR SAME.
- SEE CIVIL PLANS FOR RENOVATIONS TO EXISTING ROOF LEADERS
- ALL ROOF MOUNTED ITEMS SHALL BE PAINTED, CLEAN PREPARE AND PRIME SURFACES AS REQUIRED - COLOR PER ARCHITECT.
- FURNISH AND INSTALL 36" WIDE X LENGTH REQUIRED SELF-ADHERED ICE AND WATER SHIELD ROOFING UNDERLAYMENT AT ALL EDGES, RIDGES, HIPS, AND VALLEYS.
- PREPARE EXISTING SURFACES AS REQUIRED TO RECEIVE NEW ROOFING SYSTEM PER MANUFACTURERS SPECIFICATIONS

KEYNOTES - ROOF PLAN

- EXISTING MECHANICAL SCREEN WALL. REMOVE EXISTING WALL PANEL, CLEAN, PREP AND REPAINT ALL EXISTING STEEL PIPE COLUMNS AND HORIZONTAL FRAMING. ADD NEW FRAMING AND SIDING PER SCREEN DETAIL
- NEW ROOF CRICKET - SLOPE TO DRAIN PER MANUFACTURERS SPECIFICATIONS.
- NEW ROOF DRAIN TO TIE INTO EXISTING PIPING. INSTALL PER MANUFACTURERS SPECIFICATIONS
- TAPERED RIGID INSULATION, R-25 MINIMUM. SLOPE TO EXISTING ROOF DRAIN LOCATIONS. INSTALL PER MANUFACTURER SPECIFICATIONS

RENOVATION FOR:

CRAVEN COUNTY GOVERNMENT CENTER



EAST

CRAVEN COUNTY

1208 E. MAIN STREET, HAVELOCK, NORTH CAROLINA 28532

OAKLEY COLLIER ARCHITECTS
OCA ARCHITECTS

107 Candlevood Road, Rocky Mount, NC 27884 | P: 252.931.2500
205 W. Main Street, Raleigh, NC 27601

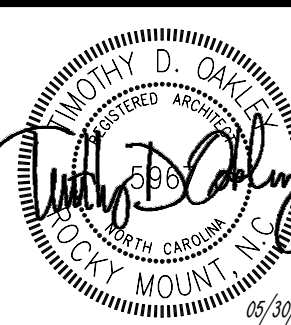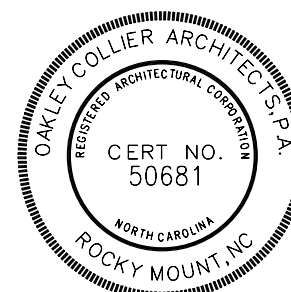

GENERAL NOTE:
Prior to construction start. Contractor shall verify & be responsible for all Dimensions.


Revisions	Description	Date
-----------	-------------	------

Date MAY 30 2026	Project No. 25012
Drawn By ACR	Sheet No. A1.3
Checked By DG	Sheet Title ROOF PLAN


Copyright © 2025 Oakley Collier Architects. These drawings are of the property of the Architect for use under his supervision. No reproduction or other use is allowed without permission.

FINISH SCHEDULE


ROOM NUMBER	ROOM NAME	FLOOR	BASE	NORTH	EAST	SOUTH	WEST	CEILING	SIGNAGE	COMMENTS
100	LOBBY & CORRIDOR	LVT-1 / FT-1	RB	PNT-1	PNT-1	PNT-1	SEE PLAN	ACT-1 / GYP	AS REQ	SEE PLAN.
101	COUNTY FLEX SPACE	LVT-1 / LVT-2	RB	PNT-1	SEE PLAN	PNT-1	PNT-1	ACT-1	A	
102	STOR	LVT-1	RB	PNT-1	PNT-1	PNT-1	PNT-1	GYP	A	
103	WAITING	LVT-1 / LVT-2	RB	PNT-1	PNT-1	PNT-1	SEE PLAN	ACT-1 / GYP	A	
104	ELEC	LVT-1	RB	PNT-1	PNT-1	PNT-1	PNT-1	ACT-1	B	
105	STOR	LVT-1	RB	PNT-1	PNT-1	PNT-1	PNT-1	ACT-1	B	
106	TOILET	FT-2	TB	PNT-1E	WT-1	PNT-1E	PNT-1E	ACT-1	D	
107	BREAK	LVT-1	RB	PNT-1	PNT-1	PNT-1	PNT-1	ACT-1	B	
108	STAFF AREA	LVT-1	RB	PNT-2	PNT-1	PNT-1	PNT-2	ACT-2	A	
109	OFFICE	CPT-1	RB	PNT-1	PNT-1	PNT-1	PNT-1	ACT-1	A	
110	LOBBY	LVT-1	RB	PNT-1	PNT-1	PNT-1	PNT-2	ACT-1	A	
111	TOILET	FT-2	TB	PNT-1E	WT-1	PNT-1E	PNT-1E	ACT-1	D	
112	BREAK ROOM	LVT-1	RB	PNT-1	PNT-1	PNT-1	PNT-1	ACT-1	A	
113	STORAGE	LVT-1	RB	PNT-1	PNT-1	PNT-1	PNT-1	ACT-1	A	
114	STAIR	RF-1	RB	PNT-1	PNT-1	PNT-1	PNT-1	ACT-1	B / E	NEW RUBBER TREADS, RUBBER FLOORING, AND RUBBER BASE.
115	ELEV	LVT-1	RB	BY MANUF.	BY MANUF.	BY MANUF.	BY MANUF.	BY MANUF.	B	
116	MDP	LVT-1	RB	PNT-1	PNT-1	PNT-1	PNT-1	ACT-1	B	
117	UTIL	LVT-1	RB	PNT-1	PNT-1	PNT-1	PNT-1	ACT-1	B	
118	TOILET	FT-2	TB	PNT-1E	WT-1	PNT-1E	WT-1	ACT-1	D	
119	TOILET	FT-2	TB	PNT-1E	WT-1	PNT-1E	PNT-1E	ACT-1	D	
120	TOILET	FT-2	TB	PNT-1E	WT-1	PNT-1E	PNT-1E	ACT-1	D	
121	TOILET	FT-2	TB	PNT-1E	PNT-1E	PNT-1E	WT-1	ACT-1	D	
122	TOILET	FT-2	TB	PNT-1E	PNT-1E	PNT-1E	WT-1	ACT-1	D	
123	TOILET	FT-2	TB	PNT-1E	WT-1	PNT-1E	PNT-1E	ACT-1	D	
124	MAG	LVT-1	RB	PNT-1	PNT-1	PNT-1	PNT-1	ACT-1	A	
125	OFFICE	CPT-1	RB	PNT-1	PNT-1	PNT-1	PNT-1	ACT-1	A	INSTALL PER ELEVATOR MANUF'S RECOMMENDATION.
126	LOUNGE	LVT-1	RB	PNT-1	PNT-1	PNT-1	PNT-1	ACT-1	A	
127	COPY	LVT-1	RB	PNT-1	PNT-1	PNT-1	PNT-1	ACT-1	A	

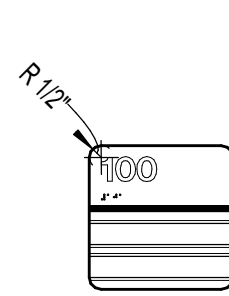


(A) CHANGEABLE COPY SIGN

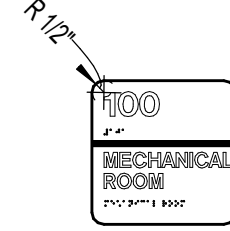


(B) ROOM NUMBER / NAME SIGN

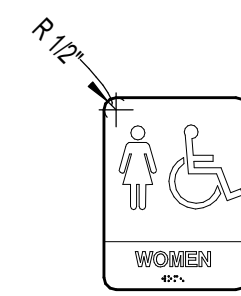

(C) SPECIFIC REST ROOM SIGN

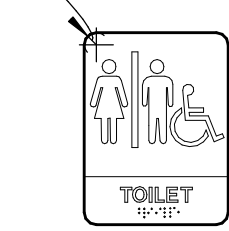

(D) NEUTRAL REST ROOM SIGN

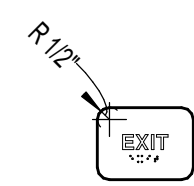


(E) EXIT SIGN

NOTES:

- ALL ROOMS AND ENTRANCES TO A ROOM UNLESS NOTED OTHERWISE SHALL HAVE ONE SIGN.
- SIGN TYPES INDICATED BY LETTER DESIGNATION, AS INDICATED, AND KEYED TO ROOM FINISH SCHEDULE.
- ALL TOILETS SHALL HAVE A RESTROOM SIGN.
- COORDINATE ROOM DESIGNATIONS AND NUMBERS WITH OWNER PRIOR TO ORDERING.
- ALL SIGNAGE SHALL COMPLY WITH ALL APPLICABLE CODES.
- CHANGEABLE COPY SIGNS SHALL HAVE TWO (2) LINES WITH NON-GLARE ACRYLIC FACES FOR OWNER INSERTS.
- ALL COMPONENTS COLORS SHALL BE AS SELECTED BY ARCHITECT FROM MANUFACTURER'S FULL RANGE.
- ALL SIGNS SHALL BE LOCATED ON STRIKE SIDE OF DOOR AND SHALL BE 48 INCHES MINIMUM AND 60 INCHES MAXIMUM FROM FINISH FLOOR TO BASELINE OF ALL BRAILLE CELLS. A CLEAR SPACE OF 18X18 INCHES SHALL BE LOCATED IN FRONT OF THE SIGN, CENTERED ON THE RAISED TEXT.

INTERIOR SIGNAGE

1 1/2" = 1'-0"

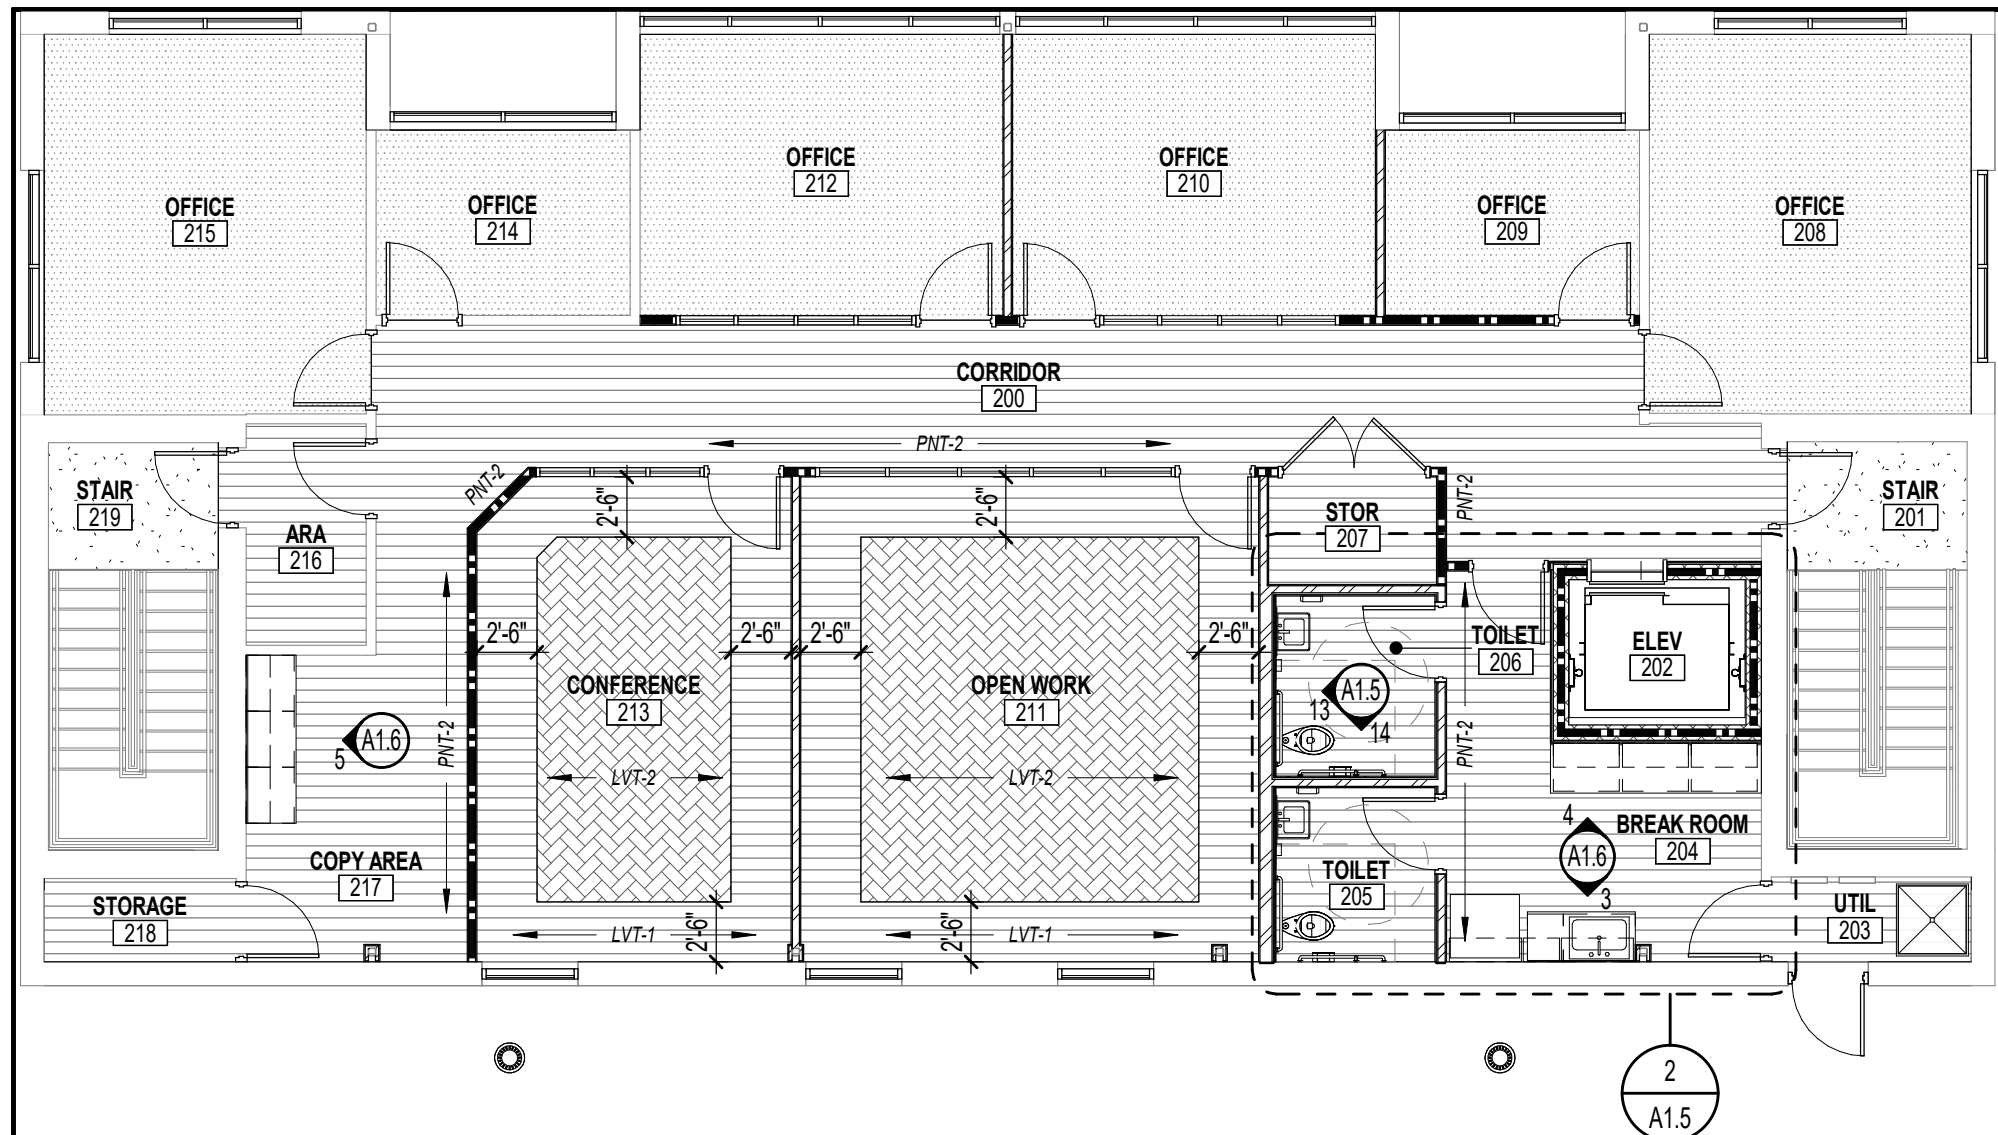


2
A1.4
SECOND FLOOR FINISH PLAN
1/8" = 1'-0"

FINISH SCHEDULE

ROOM NUMBER	ROOM NAME	FLOOR	BASE	NORTH	EAST	SOUTH	WEST	CEILING	SIGNAGE	COMMENTS
128	STAIR	RF-1	RB	PNT-1	PNT-1	PNT-1	PNT-1	ACT-1	B / E	NEW RUBBER TREADS, RUBBER FLOORING, AND RUBBER BASE.
129	LOBBY	LVT-1	RB	PNT-1	PNT-1	PNT-1	PNT-1	ACT-1	A	
130	OFFICE	CPT-1	RB	PNT-1	PNT-1	PNT-1	PNT-1	ACT-1	A	
131	OFFICE	LVT-1	RB	PNT-1	PNT-1	PNT-1	PNT-1	ACT-1	A	
132	OFFICE	CPT-1	RB	PNT-1	PNT-1	PNT-1	PNT-1	ACT-1	A	
133	CONFERENCE	CPT-1	RB	PNT-1	PNT-1	PNT-1	PNT-1	ACT-1	A	
134	INSPECTIONS	CPT-1	RB	PNT-1	PNT-1	PNT-1	PNT-1	ACT-1	A	
135	INSPECTIONS / FLEX	CPT-1	RB	PNT-1	PNT-1	PNT-1	PNT-1	ACT-1	A	
200	CORRIDOR	LVT-1	RB	PNT-1	PNT-1	SEE PLAN	PNT-1	ACT-1	A	
201	STAIR	RF-1	RB	PNT-1	PNT-1	PNT-1	PNT-1	ACT-1	E	NEW RUBBER TREADS, RUBBER FLOORING, AND RUBBER BASE.
202	ELEV	LVT-1	RB	BY MANUF.	BY MANUF.	BY MANUF.	BY MANUF.	BY MANUF.	B	
203	UTIL	LVT-1	RB	PNT-1	PNT-1	PNT-1	PNT-1	ACT-1	B	
204	BREAK ROOM	LVT-1	RB	PNT-1	PNT-1	PNT-1	PNT-1	ACT-1	A	
205	TOILET	FT-2	TB	PNT-1E	PNT-1E	PNT-1E	WT-1	ACT-1	D	
206	TOILET	FT-2	TB	PNT-1E	PNT-1E	PNT-1E	WT-1	ACT-1	D	
207	STOR	LVT-1	RB	PNT-1	PNT-1	PNT-1	PNT-1	ACT-1	A	
208	OFFICE	CPT-1	RB	PNT-1	PNT-1	PNT-1	PNT-1	ACT-1	A	
209	OFFICE	CPT-1	RB	PNT-1	PNT-1	PNT-1	PNT-1	ACT-1	A	
210	OFFICE	CPT-1	RB	PNT-1	PNT-1	PNT-1	PNT-1	ACT-1	A	
211	OPEN WORK	LVT-1 / LVT-2	RB	PNT-1	PNT-1	PNT-1	PNT-1	ACT-1	A	
212	OFFICE	CPT-1	RB	PNT-1	PNT-1	PNT-1	PNT-1	ACT-1	A	
213	CONFERENCE	LVT-1 / LVT-2	RB	PNT-1	PNT-1	PNT-1	PNT-1	ACT-1	A	
214	OFFICE	CPT-1	RB	PNT-1	PNT-1	PNT-1	PNT-1	ACT-1	A	
215	OFFICE	CPT-1	RB	PNT-1	PNT-1	PNT-1	PNT-1	ACT-1	A	
216	ARA	LVT-1	RB	PNT-1	PNT-1	PNT-1	PNT-1	ACT-1	A	
217	COPY AREA	LVT-1	RB	PNT-1	PNT-2	PNT-1	PNT-1	ACT-1	A	
218	STORAGE	LVT-1	RB	PNT-1	PNT-1	PNT-1	PNT-1	ACT-1	A	
219	STAIR	RF-1	RB	PNT-1	PNT-1	PNT-1	PNT-1	ACT-1	B / E	NEW RUBBER TREADS, RUBBER FLOORING, AND RUBBER BASE.

CLEAN, PATCH, AND PAINT EXISTING STAIR HANDRAILS.

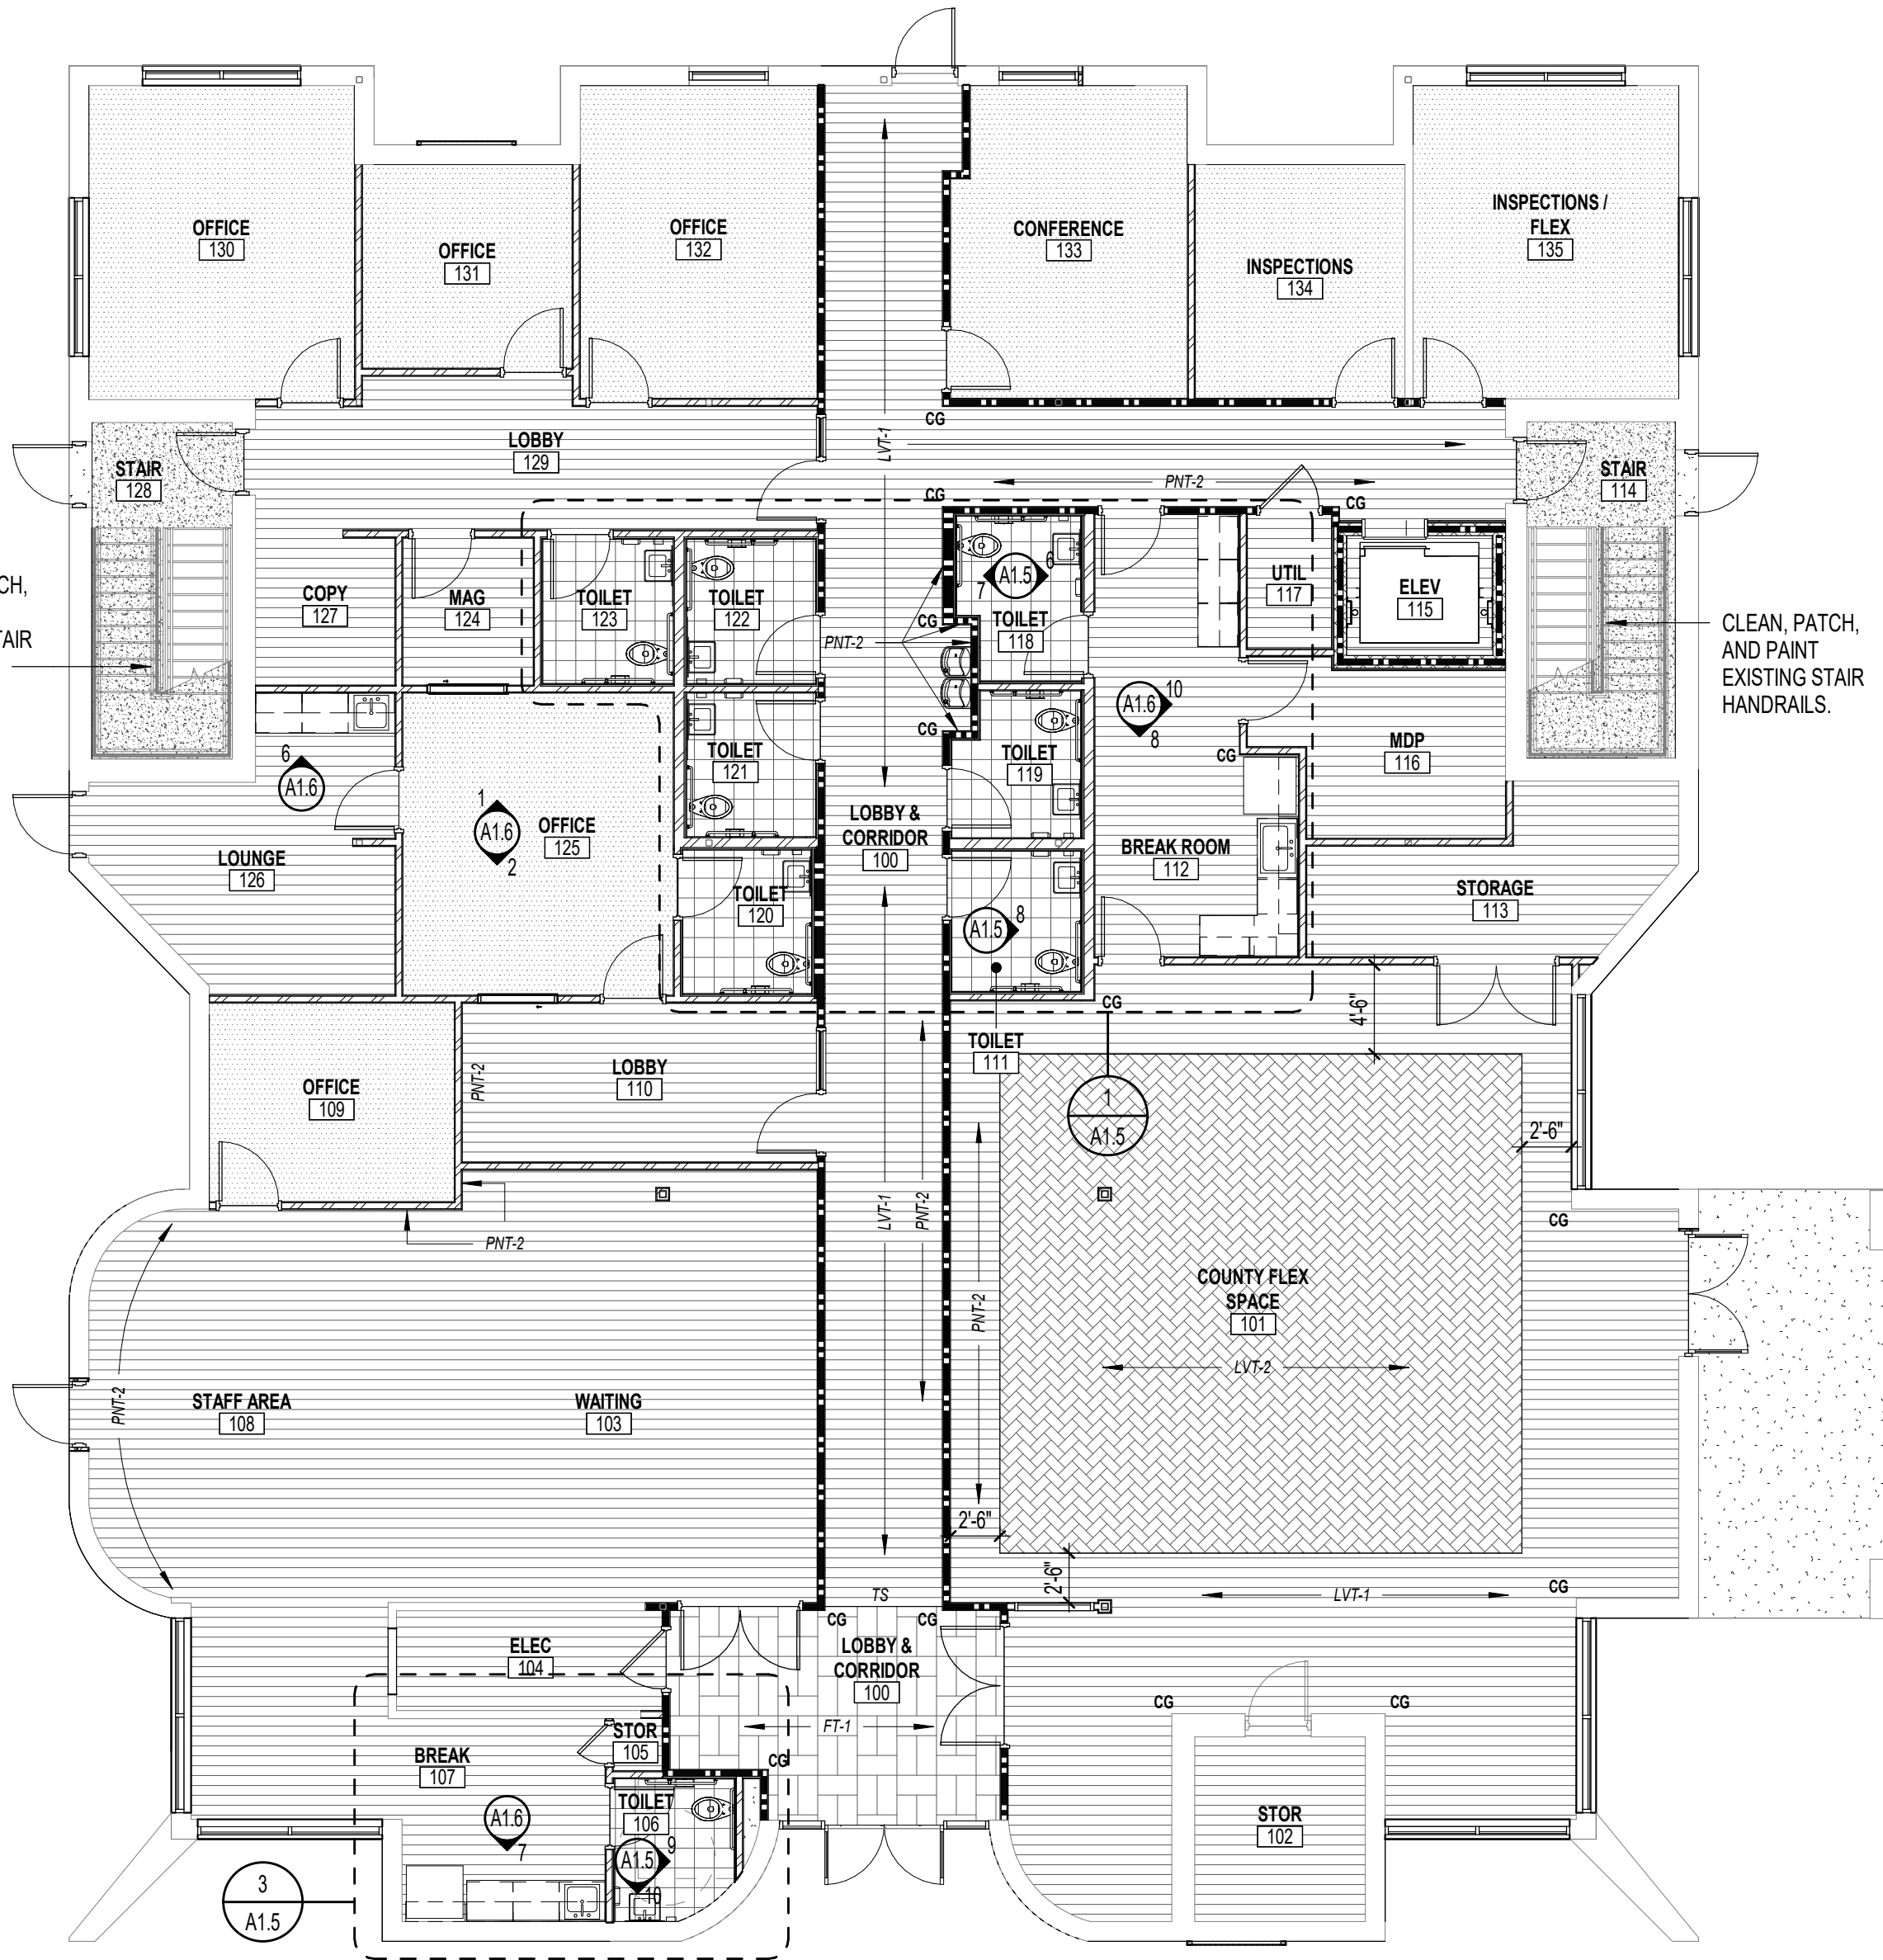

CLEAN, PATCH, AND PAINT EXISTING STAIR HANDRAILS.

1
A1.4
FIRST FLOOR FINISH PLAN
1/8" = 1'-0"

FINISH LEGEND

	NOTE: WALL FINISHES ARE BASED ON PLAN DIRECTION (PLAN N, E, S, W). **PLAN DIRECTION REFERS TO ORIENTATION ON THIS SHEET.**
--	--

WALL FINISH:				
LEGEND:	MARK:	DESCR:	BASIS OF DESIGN:	NOTES:
-	PNT-1	WALL PAINT	SW7000 IBIS WHITE	OWNER TO APPROVE ALL PAINT COLORS BEFORE THEY ARE PROCURED AND INSTALLED.
-	PNT-1E	EPOXY PAINT	SW7000 IBIS WHITE	
-	PNT-2	WALL PAINT	SW6522 SPORTY BLUE	
	WT-1	WALL TILE	TRINITY TILE: SOLENE WHITE / TEXTURED 12" X 24"	

WALL BASE:				
LEGEND:	MARK:	DESCR:	BASIS OF DESIGN:	NOTES:
-	RB	RUBBER BASE	JOHNSONITE	
-	TB	TILE BASE	SOLENE BULLNOSE WHITE / TEXTURED	

FLOOR FINISH:				
LEGEND:	MARK:	DESCR:	BASIS OF DESIGN:	NOTES:
	LVT-1	LUXURY VINYL TILE / PLANK	MOHAWK: SECOYA 2.5 CHIMNEY OAK 917 STAGGERED PLANK INSTALL	INSTALL ALL LVT IN THE DIRECTION SHOWN ON THE FINISH PLAN.
	LVT-2	LUXURY VINYL TILE / PLANK	MOHAWK: SECOYA 2.5 CHIMNEY OAK 917 HERRINGBONE INSTALL	INSTALL ALL LVT IN THE DIRECTION SHOWN ON THE FINISH PLAN.
	CPT-1	CARPET TILE	TARKETT: ATTRACT AFFINITY (24201)	
	FT-1	FLOOR TILE	DALTILE: PORTFOLIO CHARCOAL 12" X 24"	INSTALL IN WOVEN PATTERN AS SHOWN ON THE PLAN. ADJUST EDGE ALIGNMENT AS NECESSARY TO MINIMIZE WASTE.
	FT-2	FLOOR TILE	DALTILE: PORTFOLIO CHARCOAL 12" X 12"	
	RF-1	RUBBER FLOORING	JOHNSONITE: COLOR SPLASH COZY CANYON CG (VF8)	

SURFACE FINISH:				
LEGEND:	MARK:	DESCR:	BASIS OF DESIGN:	NOTES:
-	PL	PLASTIC LAMINATE	ARBORITE: OBSCURE OAK (W496 CW)	
-	QZ	QUARTZ	HANSTONE: ANTELLO (L0804)	

CEILING FINISH:				
LEGEND:	MARK:	DESCR:	BASIS OF DESIGN:	NOTES:
-	ACT-1	ACOUSTIC CEILING TILE	SIZE: 2' x 2' COLOR: BY ARCHITECT	SEE SPECS.
-	GYP	-	GYPSUM WALL / CEILING BOARD	SEE SPECS.

FINISH PLAN NOTES

- PATTERNS IN THE ABOVE LEGEND APPLY TO FINISH FLOOR PLAN AND INTERIOR ELEVATIONS ONLY.
- SEE INTERIOR ELEVATIONS FOR FULL EXTENT OF WALL FINISHES AS KEYED IN PLANS. SEE FINISH SCHEDULE AND SPECIFICATIONS FOR ADDITIONAL INFORMATION.
- VERIFY ALL DIMENSIONS AND CONDITIONS PRIOR TO INSTALLATION OF FINISHES.
- TS = FURNISH AND INSTALL TRANSITION STRIP AT ALL FLOOR MATERIAL CHANGES AS SHOWN OR AS REQUIRED.
- HEIGHT AND PROFILE OF ALL TRANSITIONS STRIPS SHALL COMPLY WITH HANDICAP CODE.
- COORDINATE LOCATION OF ALL TRANSITION STRIPS WITH EXISTING AND NEW CONDITIONS, WHERE POSSIBLE. LOCATE TRANSITION STRIPS UNDER DOOR SLABS. NO EXPOSED SLAB PERMITTED IN FINISHED AREAS.
- COORDINATE SIZE OF ALL TRANSITION STRIPS WITH FINISH MATERIALS.
- COLOR FOR ALL TRANSITION STRIPS SHALL BE AS SELECTED BY ARCHITECT FROM MANUFACTURER'S FULL RANGE.
- PROVIDE CORNER GUARDS AS INDICATED (CG). SEE SPECS FOR DETAIL.
- MANUFACTURERS INDICATED ABOVE REPRESENT THE BASIS OF DESIGN; SEE SPECIFICATION SECTION 01 60 00 - PRODUCT REQUIREMENTS FOR SUBSTITUTION REQUESTS.

EQUIPMENT SCHEDULE & NOTES

- ALL EQUIPMENT LISTED ABOVE IS TO BE O.S.C.I. (OWNER SUPPLIED, CONTRACTOR INSTALLED) AND SHALL BE FURNISHED BY THE OWNER AND INSTALLED BY CONTRACTOR. COORDINATE INSTALLATION WITH MANUFACTURER'S CUT SHEETS PROVIDED BY OWNER.
- FINAL CONNECTION OF O.S.C.I. EQUIPMENT SHALL BE BY THE CONTRACTOR.
- UTILITY CONNECTIONS SHALL BE FURNISHED AND INSTALLED BY THE CONTRACTOR AS DELINEATED IN THE PLANS AND AS REQUIRED TO MAKE EQUIPMENT OPERATIONAL.
- ALL STRUCTURAL SUPPORT AND CONNECTIONS SHALL BE FURNISHED AND INSTALLED BY THE CONTRACTOR AS DELINEATED IN THE PLANS.
- FURNISH AND INSTALL ALL BLOCKING AS REQUIRED FOR PROPER INSTALLATION OF ALL WALL MOUNTED EQUIPMENT. COORDINATE SIZE AND LOCATION OF BLOCKING WITH EQUIPMENT/OWNER.
- ALL ITEMS NOT TAGGED ON EQUIPMENT PLAN INCLUDING MISCELLANEOUS TABLES, CHAIRS, DESKS AND OFFICE FURNITURE SHALL BE FURNISHED AND INSTALLED BY THE OWNER AND ARE NOT INCLUDED IN CONTRACT.


RENOVATION FOR:

**CRAVEN COUNTY GOVERNMENT CENTER
EAST**


CRAVEN COUNTY
1208 E. MAIN STREET, HAVELock, NORTH CAROLINA 28532

**OAKLEY
COLLIER
OCA
ARCHITECTS**

107 Condevwood Road, Rocky Mount, NC 27884 (P) 252.931.2500
205 W. Main Street, Raleigh, NC 27601

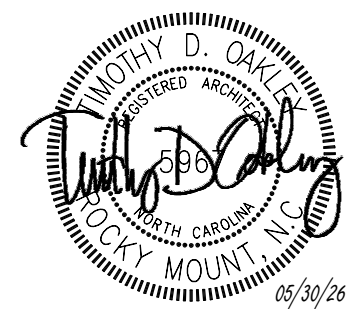


GENERAL NOTE: Prior to construction start, Contractor shall verify & be responsible for all Dimensions.		
Revisions		
 Description Date		
Date MAY 30 2026	Project No. 25012	
Drawn By ACR	Sheet No. A1.4	
Checked By DG		
Sheet Title FINISH PLANS		

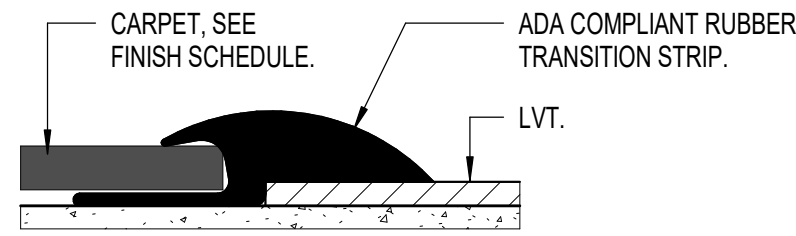


4 CARPET/LVT TRANSITION

12" = 1'-0"

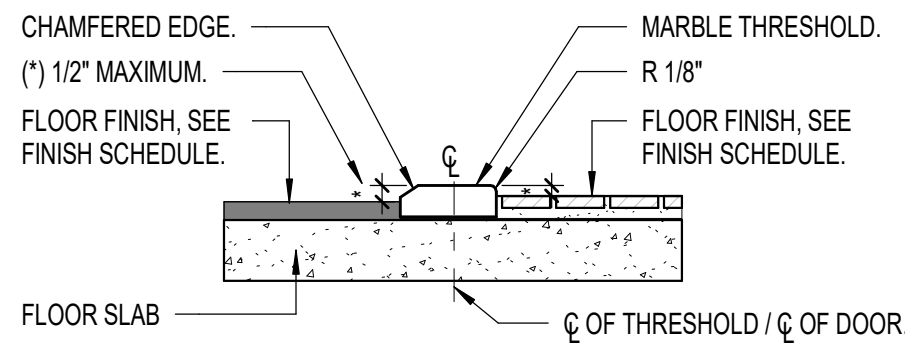


5 MARBLE THRESHOLD

3" = 1'-0"

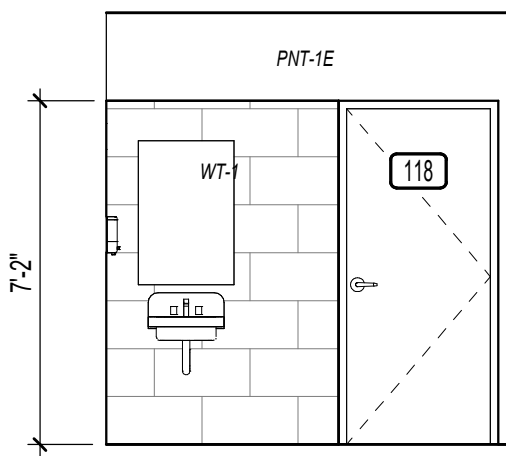


6 T118E

1/4" = 1'-0"

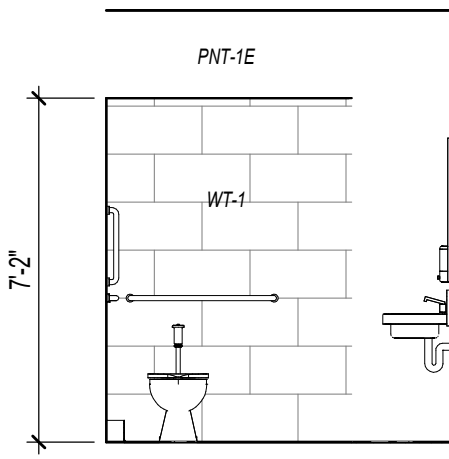


9 T106E

1/4" = 1'-0"

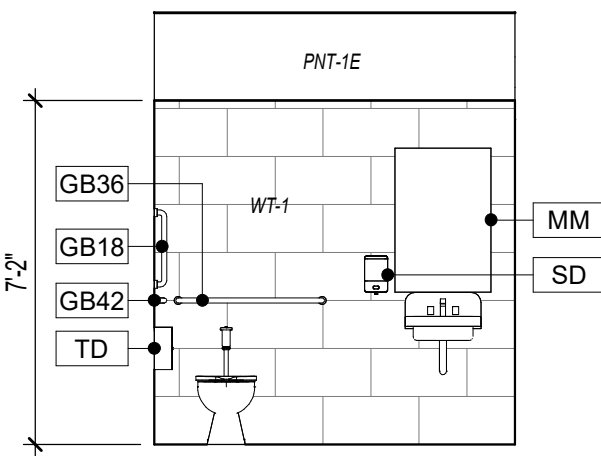


13 T206W

1/4" = 1'-0"

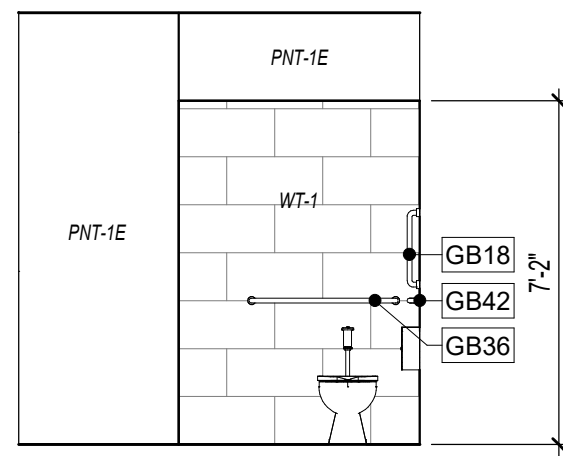


7 T118W

1/4" = 1'-0"

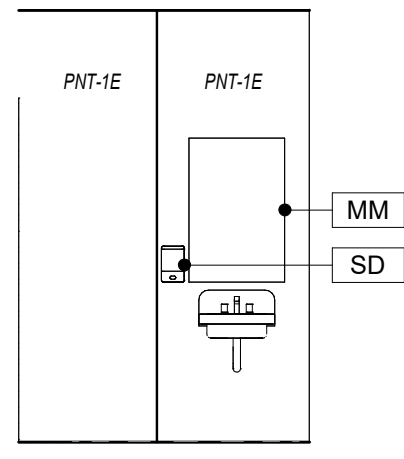

10 T106S

1/4" = 1'-0"

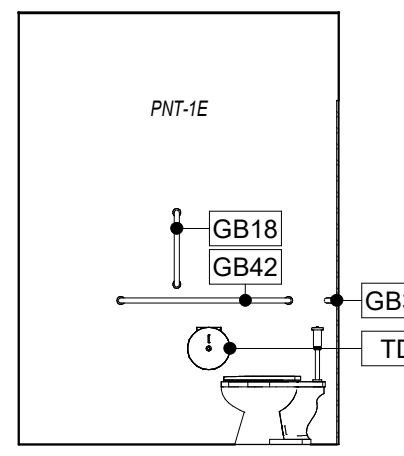


14 T206S

1/4" = 1'-0"


8 TYPICAL TOILET

1/4" = 1'-0"

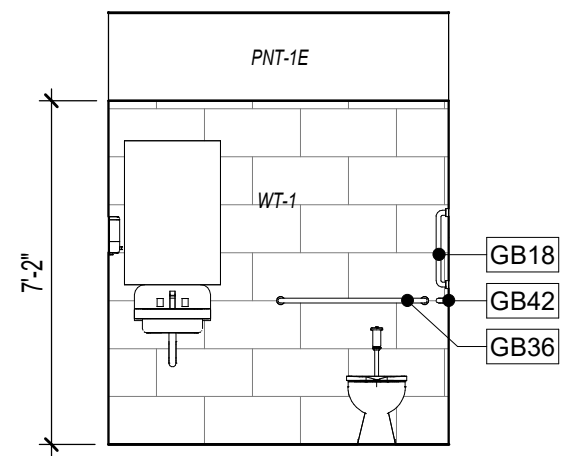


11 TCA W245

3" = 1'-0"

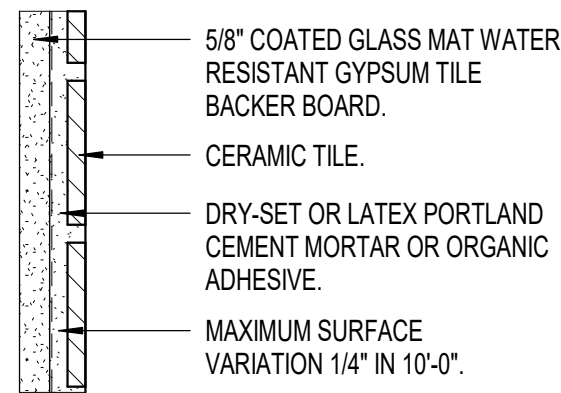


15 EWC

3/8" = 1'-0"

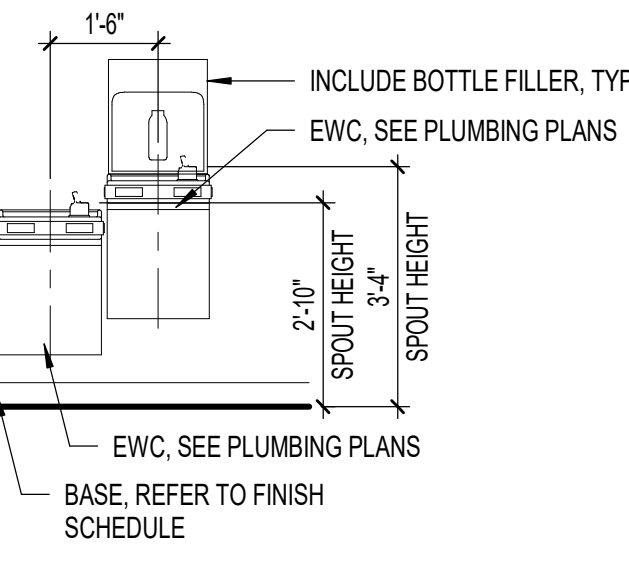


3 FIRST FLOOR ENLARGED DMV BREAK

1/4" = 1'-0"

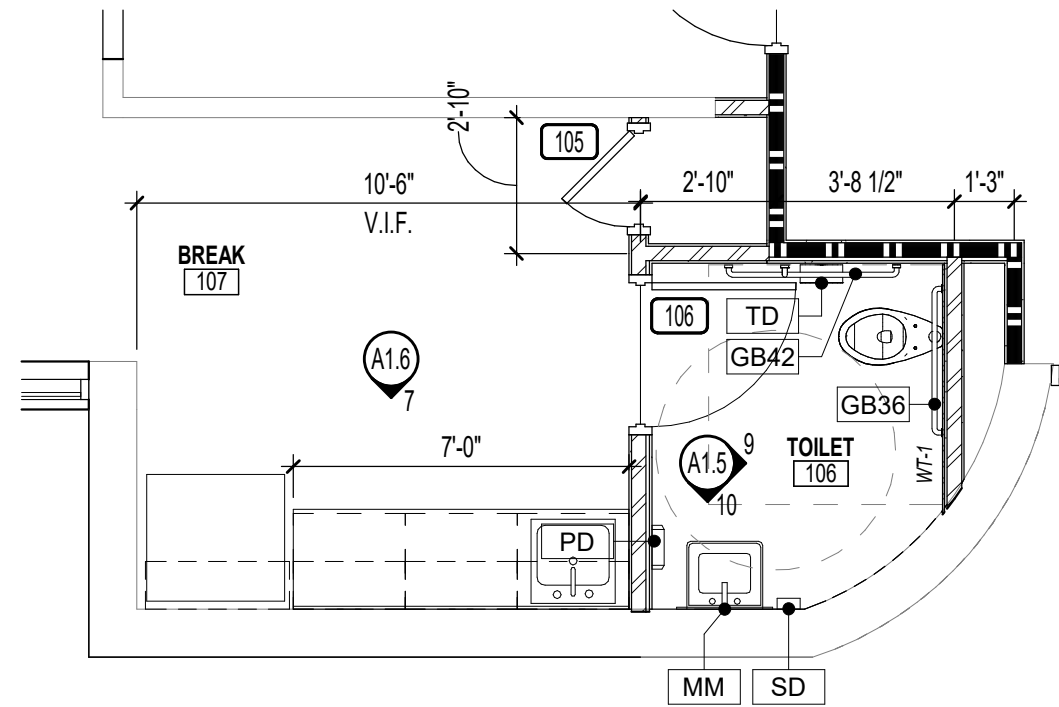


12 TCA F122

3" = 1'-0"

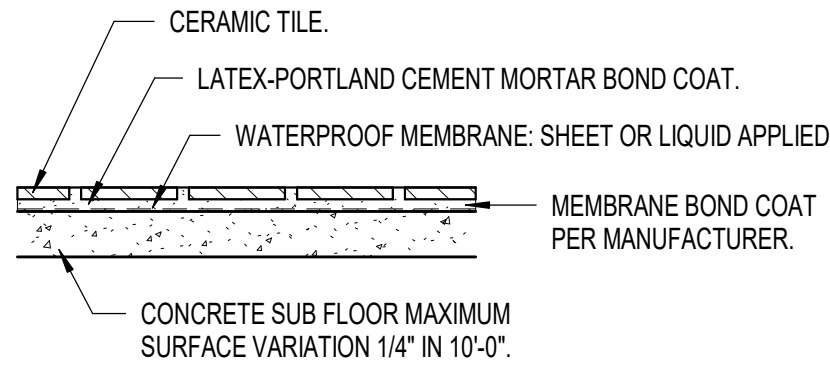


16 FLOOR TO WALL TILE

6" = 1'-0"

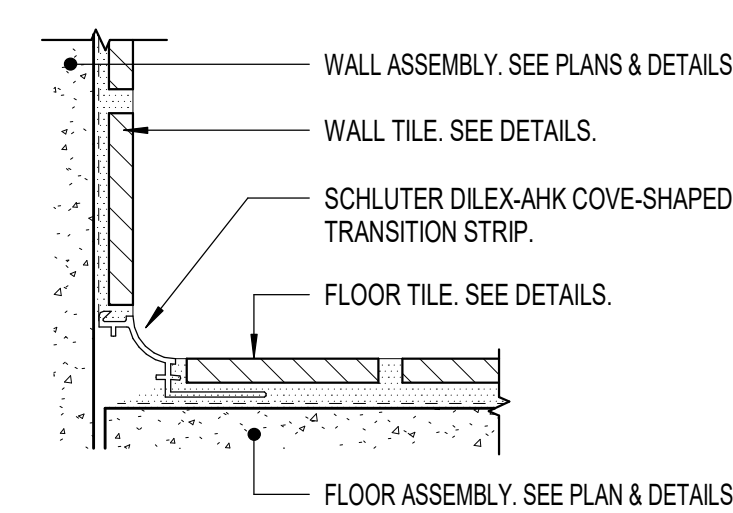

HC ACCESSORIES LEGEND

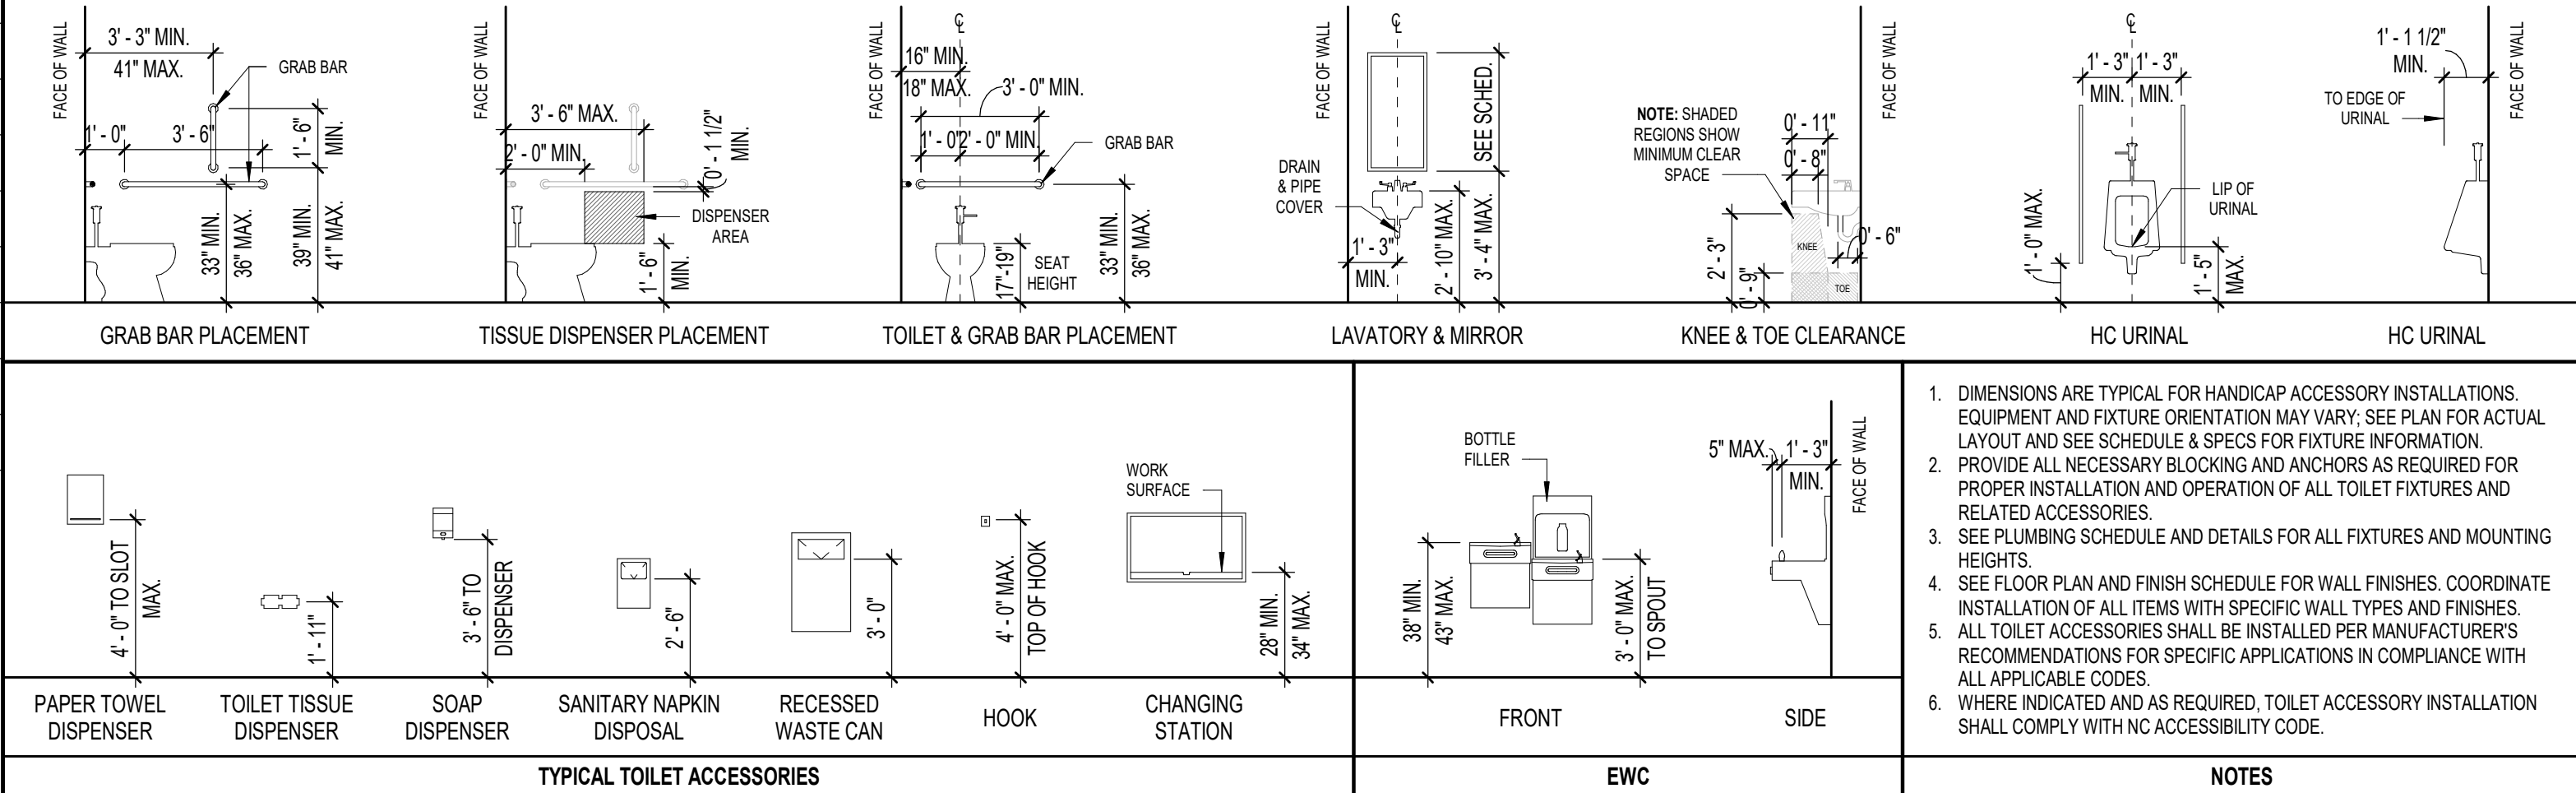

RENOVATION FOR:


CRAVEN COUNTY GOVERNMENT CENTER
EAST

CRAVEN COUNTY

1208 E. MAIN STREET, HAVELOCK, NORTH CAROLINA 28532

OAKLEY
COLLIER
ARCHITECTS
OCA


107 Condemned Road, Rocky Mount, NC 27884 (P) 252.931.2500
205 W. Main Street, Raleigh, NC 27601

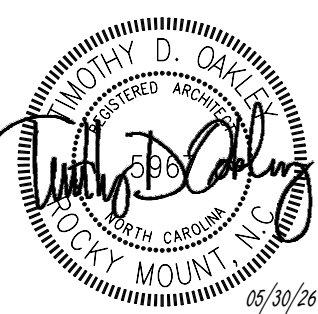


GENERAL NOTE:
Prior to construction start, Contractor shall verify & be responsible for all Dimensions.

Revisions
Description Date


Date
MAY 30 2026
Project No.
25012
Drawn By
ACR
Sheet No.
A1.5
Checked By
DG
Sheet Title
ENLARGED PLANS & TOILET ELEVATIONS

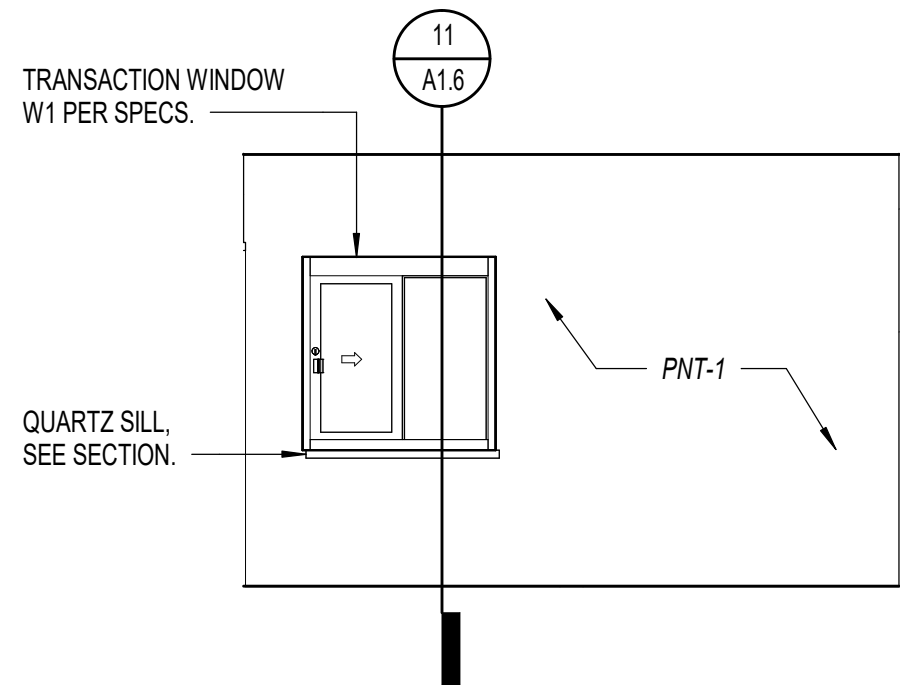


1
A1.6
125N ELEVATION
1/4" = 1'-0"

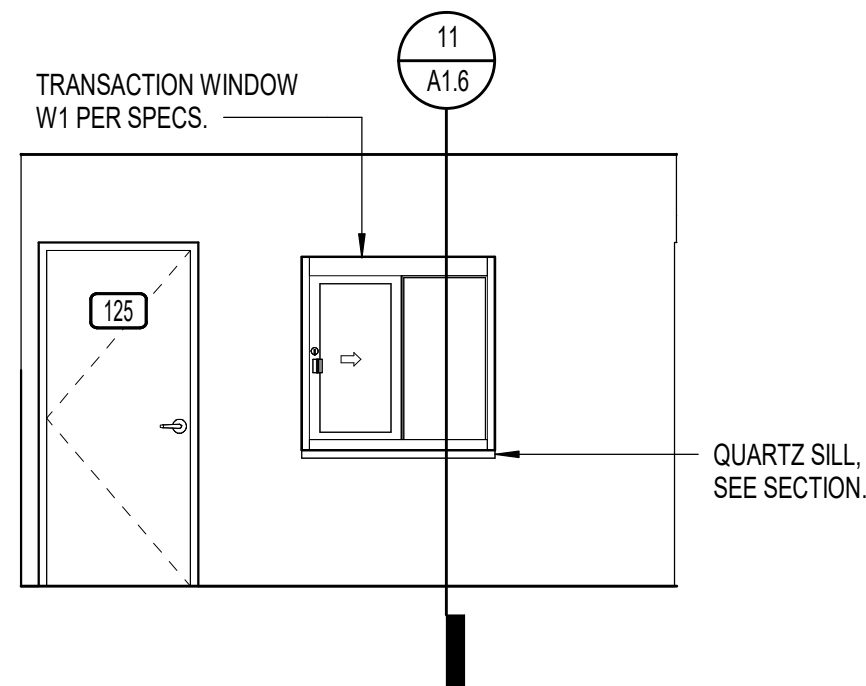


2
A1.6
125S ELEVATION
1/4" = 1'-0"

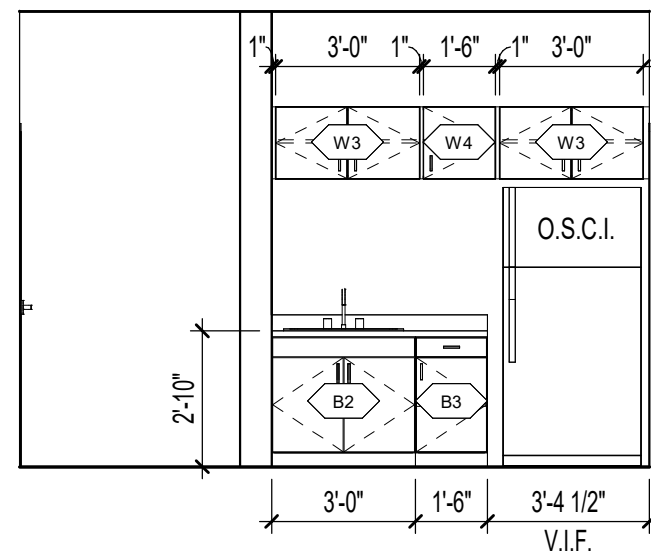


3
A1.6
204S ELEVATION
1/4" = 1'-0"

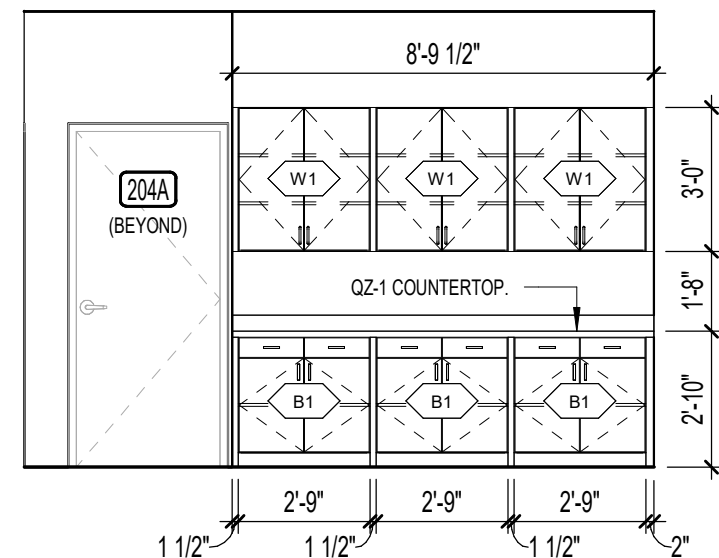


4
A1.6
204N ELEVATION
1/4" = 1'-0"

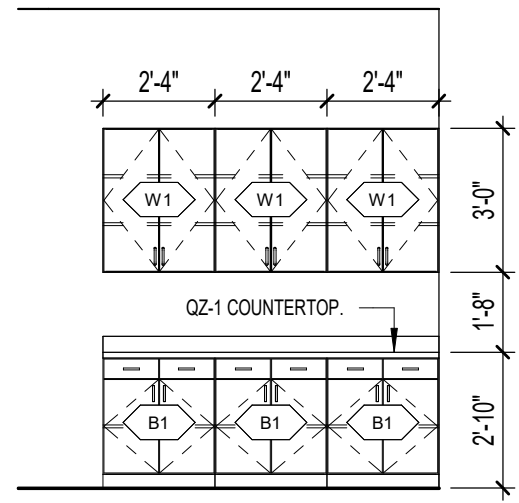


5
A1.6
217W ELEVATION
1/4" = 1'-0"

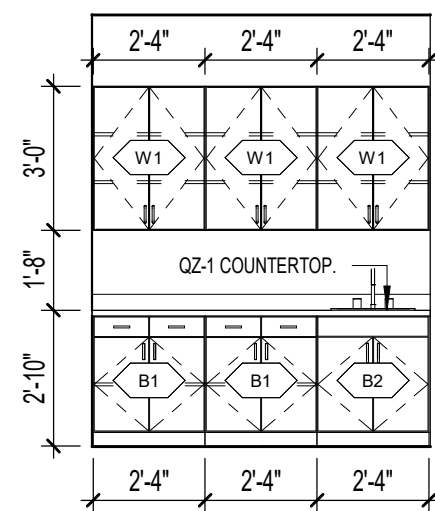


6
A1.6
126N ELEVATION
1/4" = 1'-0"

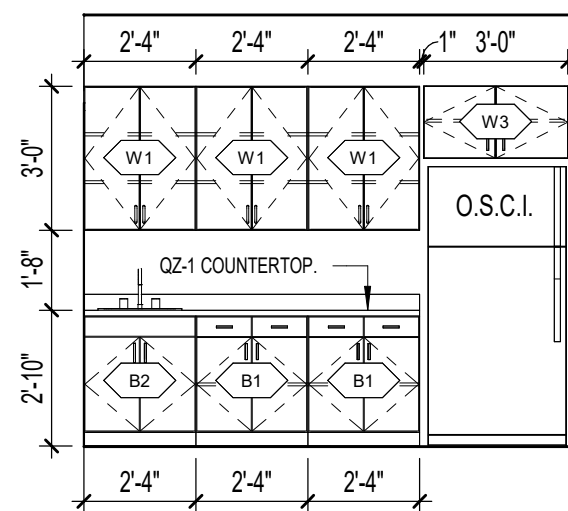


7
A1.6
107S ELEVATION
1/4" = 1'-0"

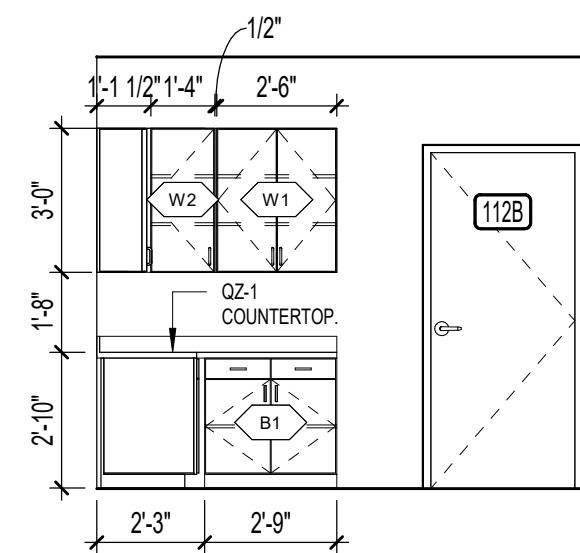


8
A1.6
112S ELEVATION
1/4" = 1'-0"

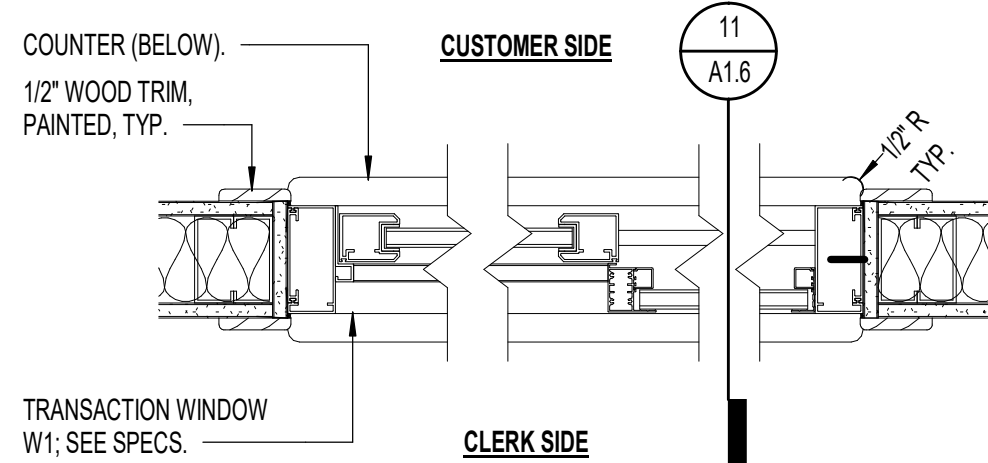


9
A1.6
TRANSACTION - JAMB SECTION
1 1/2" = 1'-0"

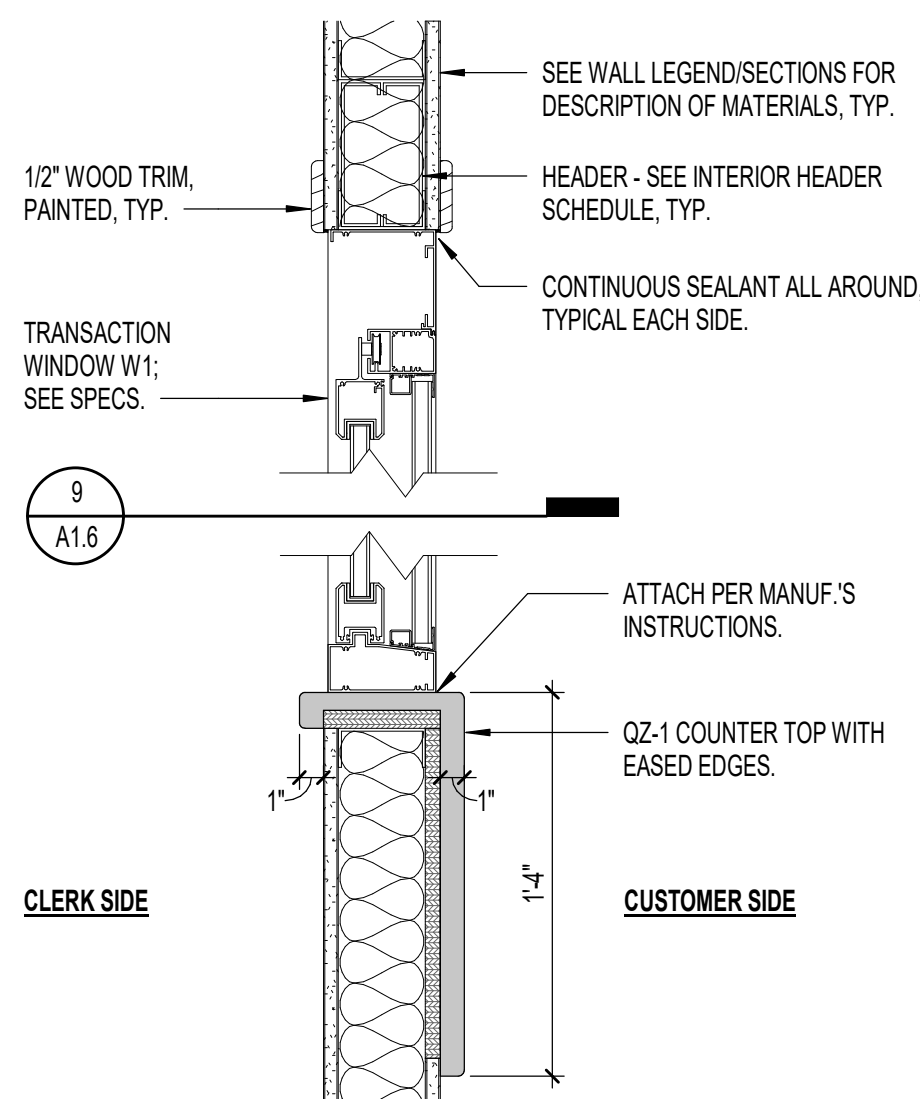


11
A1.6
TRANSACTION - HEAD & SILL
1 1/2" = 1'-0"

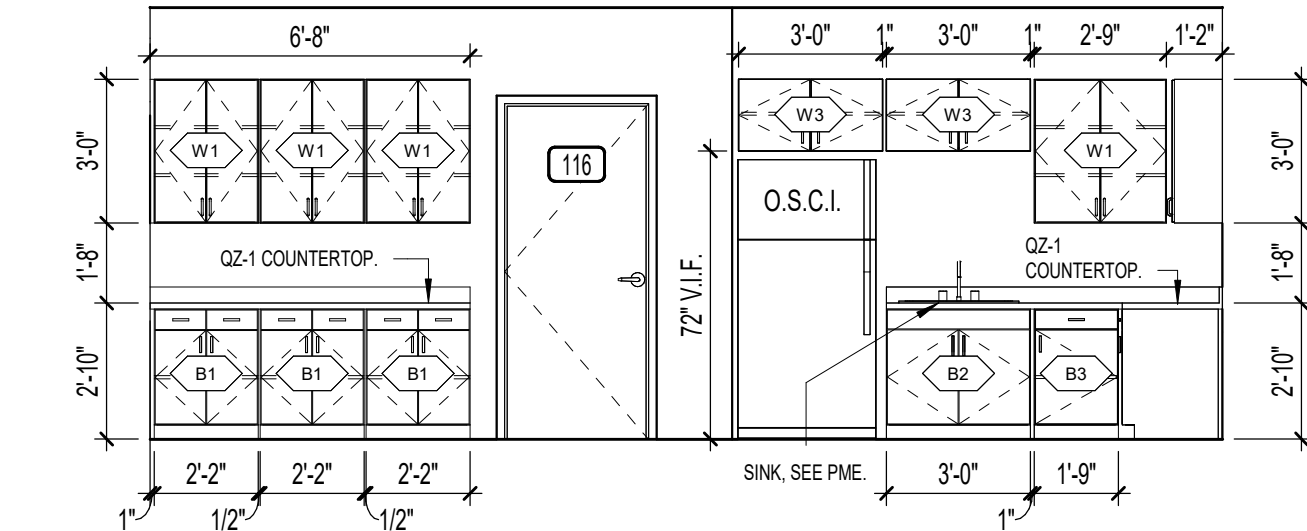

10
A1.6
112E ELEVATION
1/4" = 1'-0"

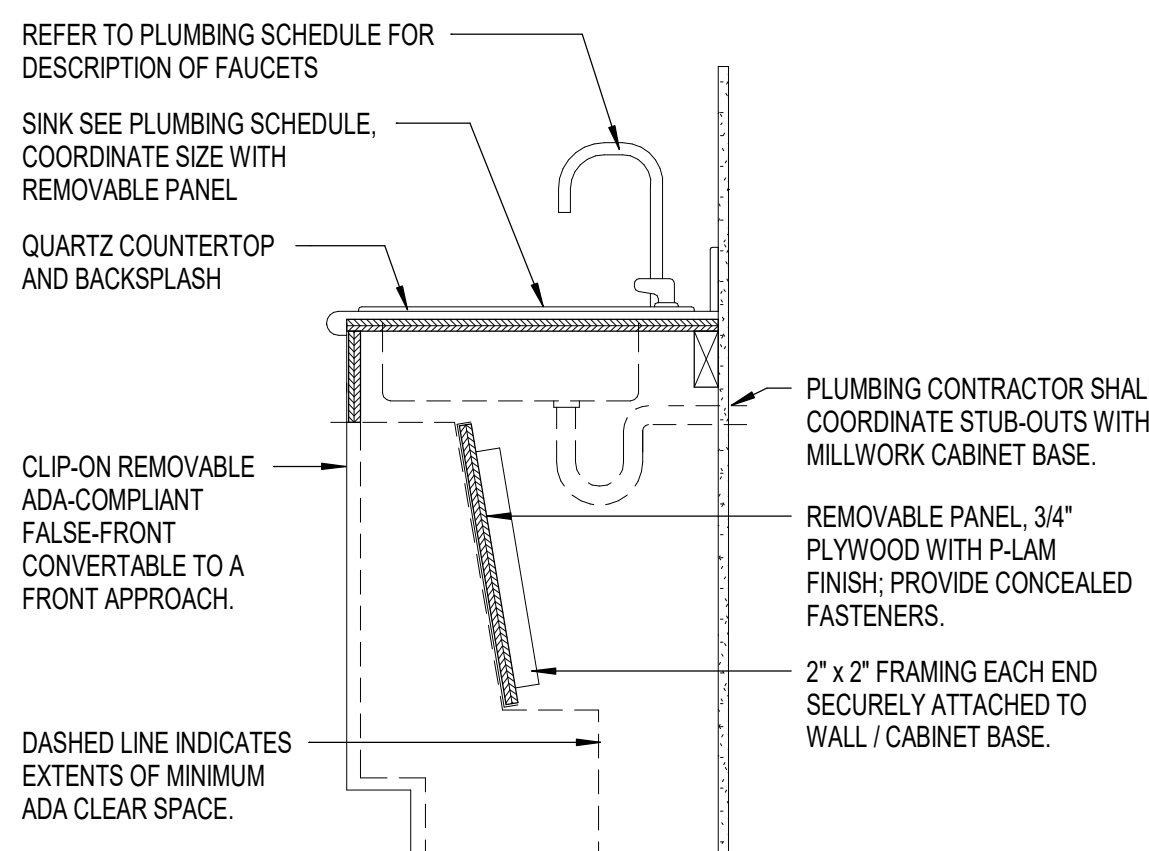

12
A1.6
ADA SINK CABINETY
1" = 1'-0"

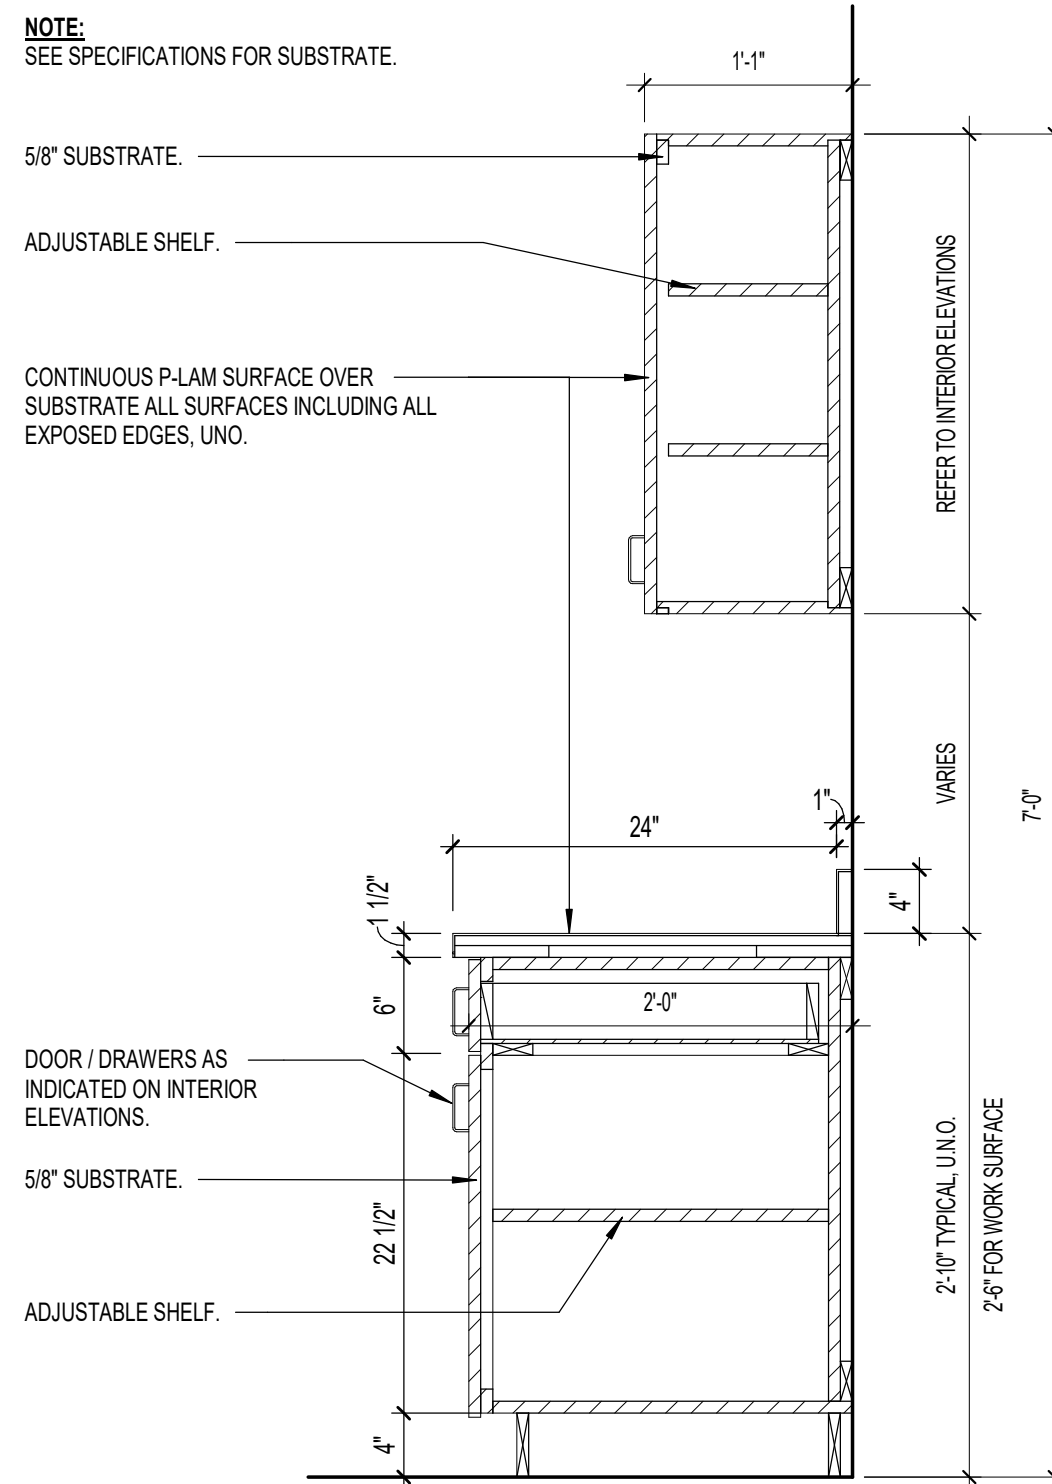

13
A1.6
CASEWORK SECTION, U.O.N.
1" = 1'-0"

CABINETY NOTES

1. PROVIDE PLASTIC LAMINATE FINISH (PL-1) ON ALL EXPOSED SURFACES INCLUDING DOOR AND DRAWER EDGES. COLOR AND PATTERN AS SELECTED BY ARCHITECT FROM MANUFACTURER'S FULL RANGE.
2. PROVIDE QUARTZ FINISH ON ALL COUNTER TOPS UNLESS NOTED OTHERWISE. COLOR AND PATTERN AS SELECTED BY ARCHITECT FROM MANUFACTURER'S FULL RANGE.
3. PROVIDE MELAMINE FINISH ON ALL INTERIOR SURFACES AS SPECIFIED. COLOR AS SELECTED BY OWNER FROM MANUFACTURER'S FULL RANGE.
4. PROVIDE STANDARD "WIRE" DOOR AND DRAWER PULLS, TYPICAL.
5. PROVIDE CONCEALED HINGES FOR ALL DOORS, TYPICAL.
6. PROVIDE FULL EXTENSION SLIDES ON ALL DRAWERS.
7. PROVIDE 3/4" MELAMINE FINISH ADJUSTABLE SHELVING FOR ALL UPPER AND BASE CABINETS AS INDICATED, TYPICAL. PRE-DRILL HOLES AT 1 1/4" O.C. AND PROVIDE METAL SHELF CLIPS.
8. PROVIDE 3/4" THICK DRAWER AND DOOR FACES, TYPICAL.
9. PROVIDE FILLER PANELS AS NECESSARY.
10. FIELD VERIFY ALL DIMENSIONS, SQUARE AND PLUMB OF WALLS TO ENSURE PROPER FIT OF ALL CABINETY, TYPICAL.
11. SUBMIT SHOP DRAWINGS PER SPECIFICATIONS OF ALL CABINETY AND RELATED ITEMS FOR REVIEW PRIOR TO FABRICATION, TYPICAL.
12. FURNISH AND INSTALL ALL BLOCKING AS REQUIRED FOR PROPER INSTALLATION OF ALL CABINETY, COORDINATE INSTALLATION OF BLOCKING WITH CABINET SUPPLIER.
13. ALL APPLICANCES WILL BE FURNISHED BY THE OWNER AND INSTALLED BY THE CONTRACTOR. VERIFY APPLIANCE SIZES WITH MANUFACTURER'S CUT SHEETS. CUT SHEETS SHALL BE PROVIDED BY THE OWNER.

CASEWORK NOTES & LEGENDS


MARK	DESCRIPTION
B1	2'-0" DEEP BASE CABINET; TWO HINGED DOORS AND TWO 6" HIGH DRAWERS AND ONE ADJUSTABLE SHELF. PROVIDE FIXED VERTICAL DIVIDER IN UNITS MORE THAN 3'-0" WIDE. HEIGHT/WIDTH VARIES.
B2	2'-0" SINK CABINET; TWO HINGED DOORS WITH ATTACHED BASEBOARD. SEE SECTION THROUGH TYPICAL ADA SINK CABINETY. CABINET IS TO HAVE A REMOVABLE FALSE FRONT TO CONVERT TO AN ADA-COMPLIANT FRONT APPROACH.
B3	2'-0" DEEP BASE CABINET; ONE HINGED DOOR WITH ONE ADJUSTABLE SHELF; ONE 6" HIGH DRAWER. HEIGHT/WIDTH VARIES.
W1	1'-0" DEEP WALL CABINET; TWO HINGED DOORS & TWO ADJUSTABLE SHELVES. PROVIDE FIXED VERTICAL DIVIDER IN UNITS MORE THAN 3'-0" WIDE. HEIGHT/WIDTH VARIES. FOR HEIGHTS OVER 4'-0" INCREASE TO THREE ADJUSTABLE SHELVES.
W1	1'-0" DEEP WALL CABINET; ONE HINGED DOOR & TWO ADJUSTABLE SHELVES. HEIGHT/WIDTH VARIES. FOR HEIGHTS OVER 4'-0" INCREASE TO THREE ADJUSTABLE SHELVES.
W3	1'-0" DEEP WALL CABINET; TWO HINGED DOORS & ONE ADJUSTABLE SHELF. PROVIDE FIXED VERTICAL DIVIDER IN UNITS MORE THAN 3'-0" WIDE. HEIGHT/WIDTH VARIES. FOR HEIGHTS OVER 4'-0" INCREASE TO THREE ADJUSTABLE SHELVES.
W4	1'-0" DEEP WALL CABINET; ONE HINGED DOOR & ONE ADJUSTABLE SHELF. HEIGHT/WIDTH VARIES.
1. ALL CASEWORK SHOWN IS MANUFACTURED PLASTIC LAMINATE CASEWORK, TYPICAL UNLESS NOTED OTHERWISE.	
2. PROVIDE SUPPORT BRACKETS AS REQUIRED/RECOMMENDED BY MANUFACTURER.	
3. GC TO PROVIDE ALL BLOCKING REQUIRED BY CASEWORK MANUFACTURER.	
4. PROVIDE LOCKS ON CASEWORK WHERE NOTED IN ELEVATIONS.	

RENOVATION FOR:

**CRAVEN COUNTY GOVERNMENT CENTER
EAST**

CRAVEN COUNTY
1208 E. MAIN STREET, HAVELock, NORTH CAROLINA 28532


**OAKLEY
COLLIER
ARCHITECTS**
OCA
107 Condevwood Road, Rocky Mount, NC 27884 (P) 252.931.2500
205 W. Main Street, Raleigh, NC 27601

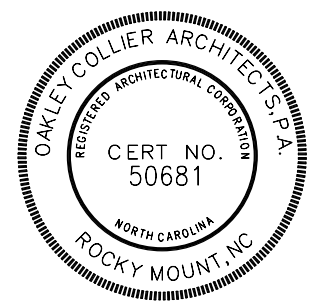


GENERAL NOTE:
Prior to construction start, Contractor shall verify & be responsible for all Dimensions.

Revisions
Description Date


Date
MAY 30 2026
Project No.
25012
Drawn By
ACR
Sheet No.
A1.6
Checked By
DG
Sheet Title
CASEWORK ELEVATIONS & DETAILS

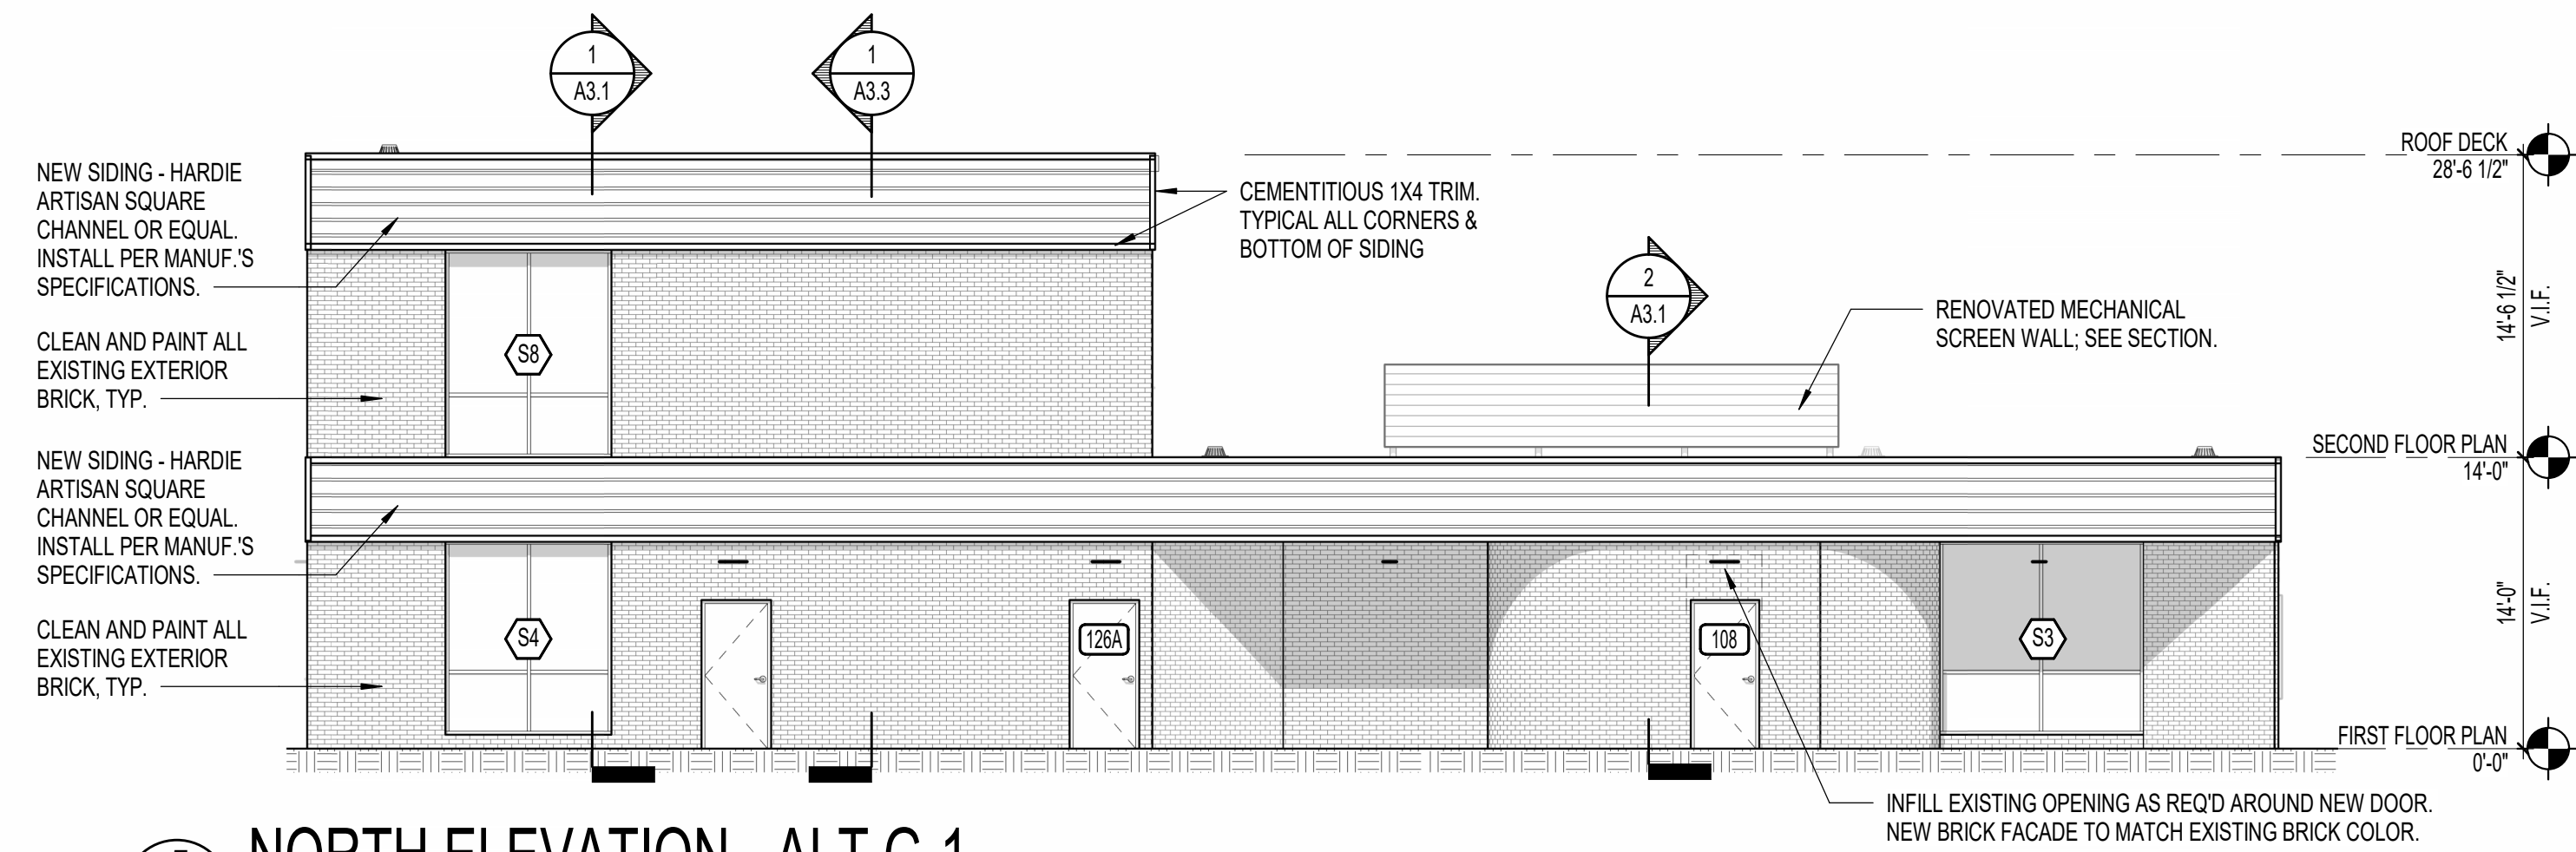


5 NORTH ELEVATION - ALT G-1
A2.1 1/8" = 1'-0"

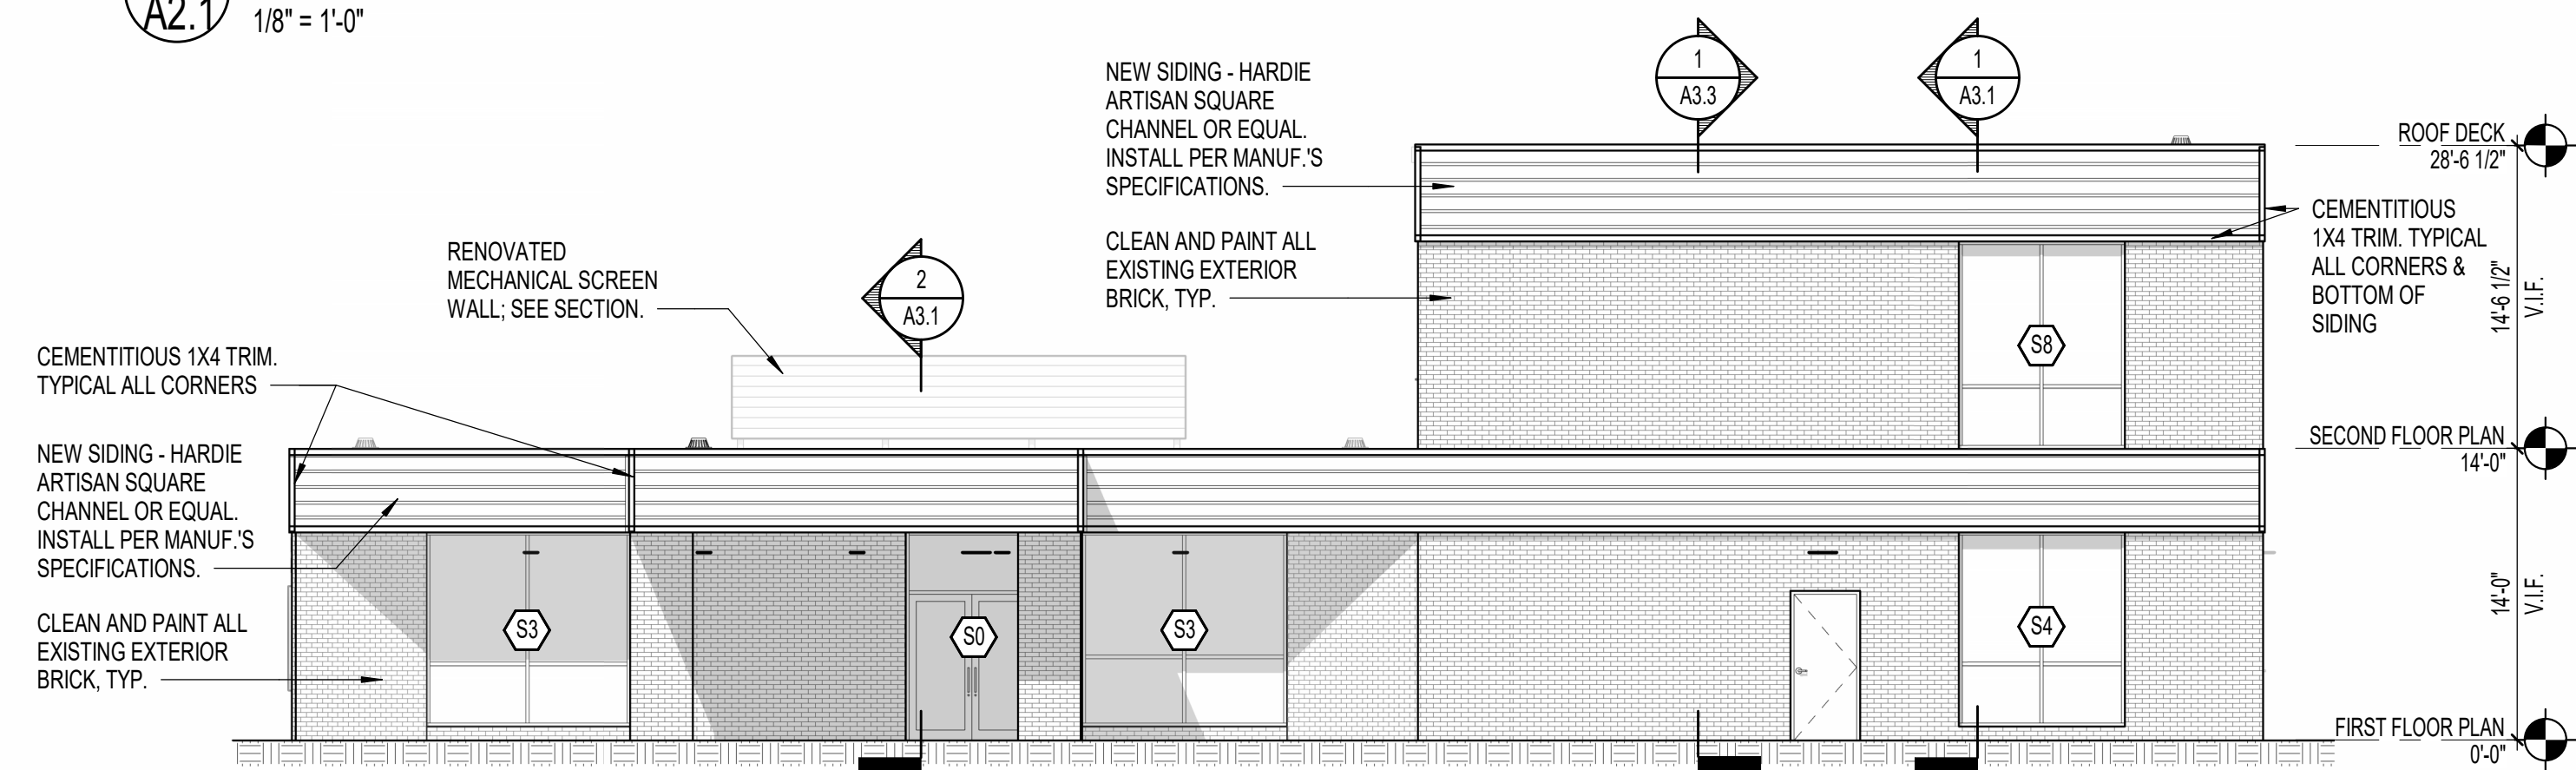


6 SOUTH ELEVATION - ALT G-1
A2.1 1/8" = 1'-0"

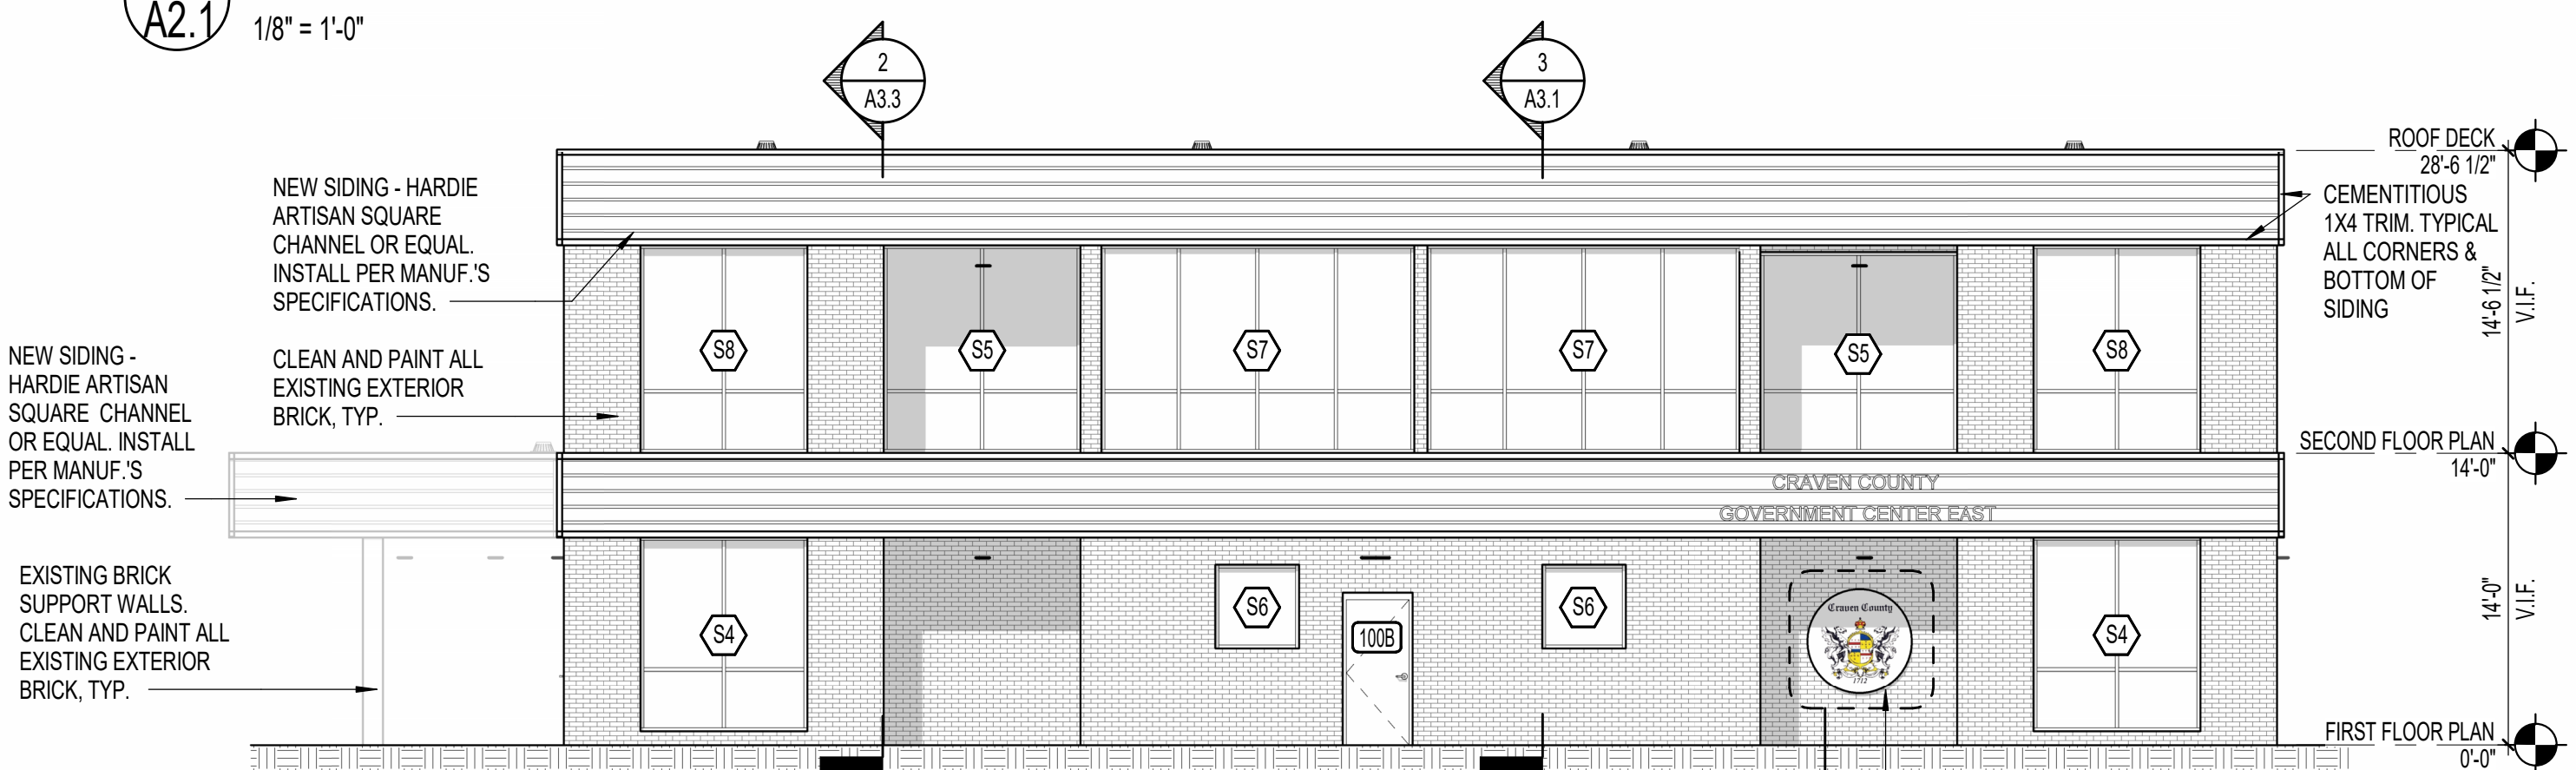


7 EAST ELEVATION - ALT G-1
A2.1 1/8" = 1'-0"

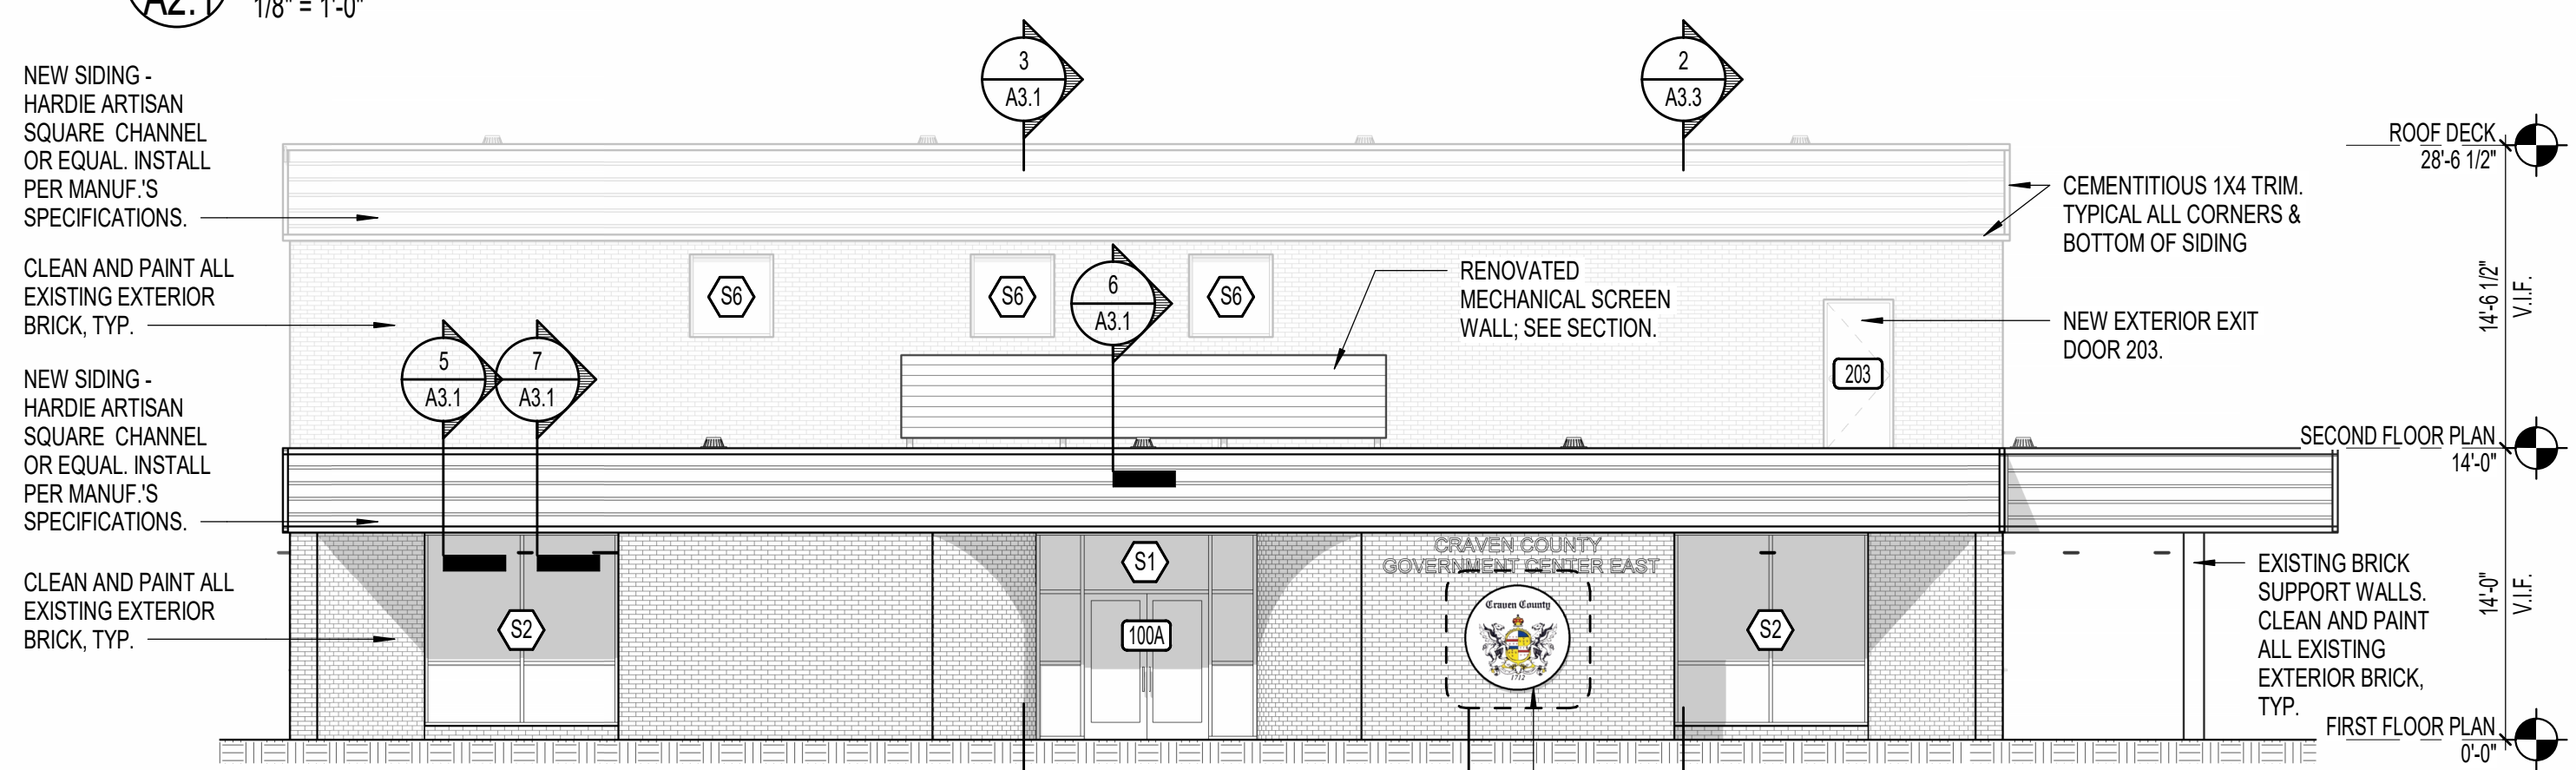


8 WEST ELEVATION - ALT G-1
A2.1 1/8" = 1'-0"

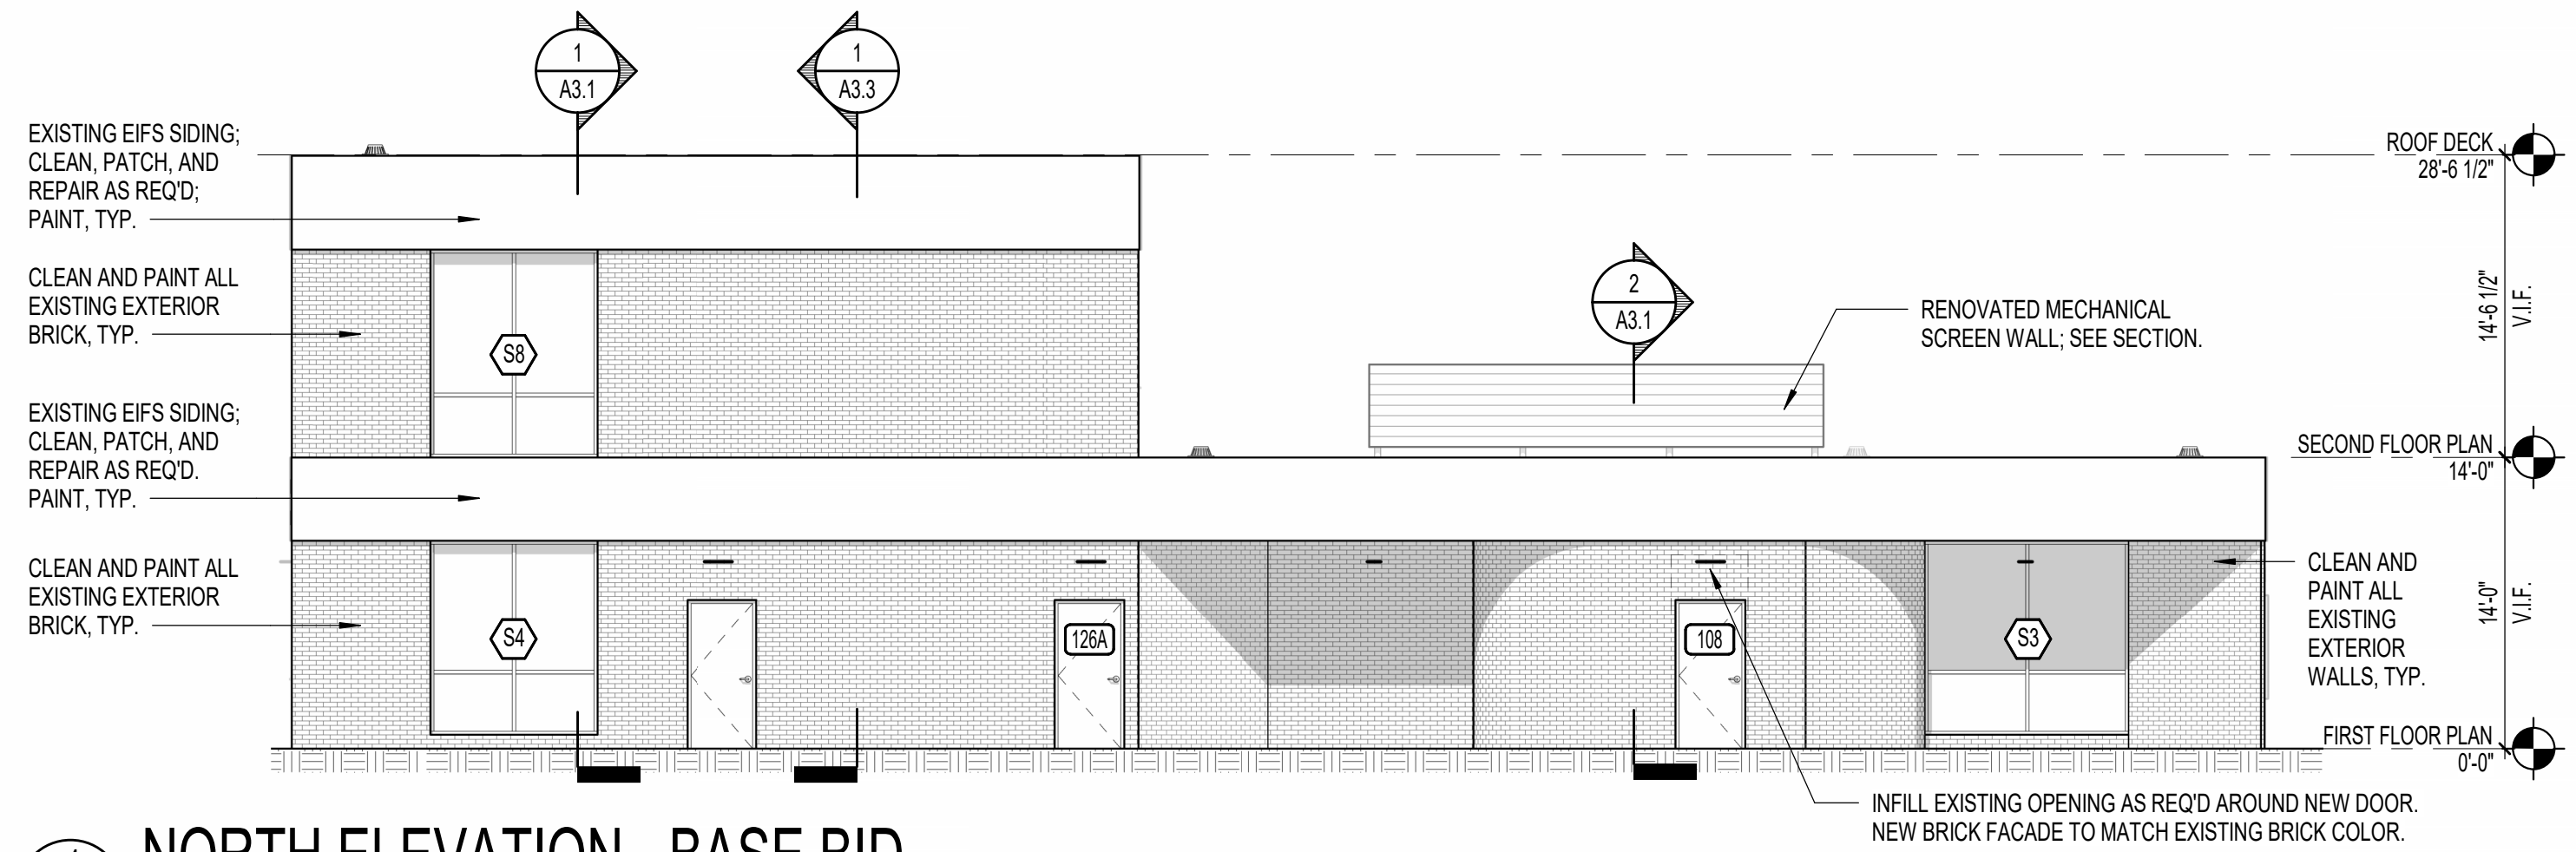


1 NORTH ELEVATION - BASE BID
A2.1 1/8" = 1'-0"

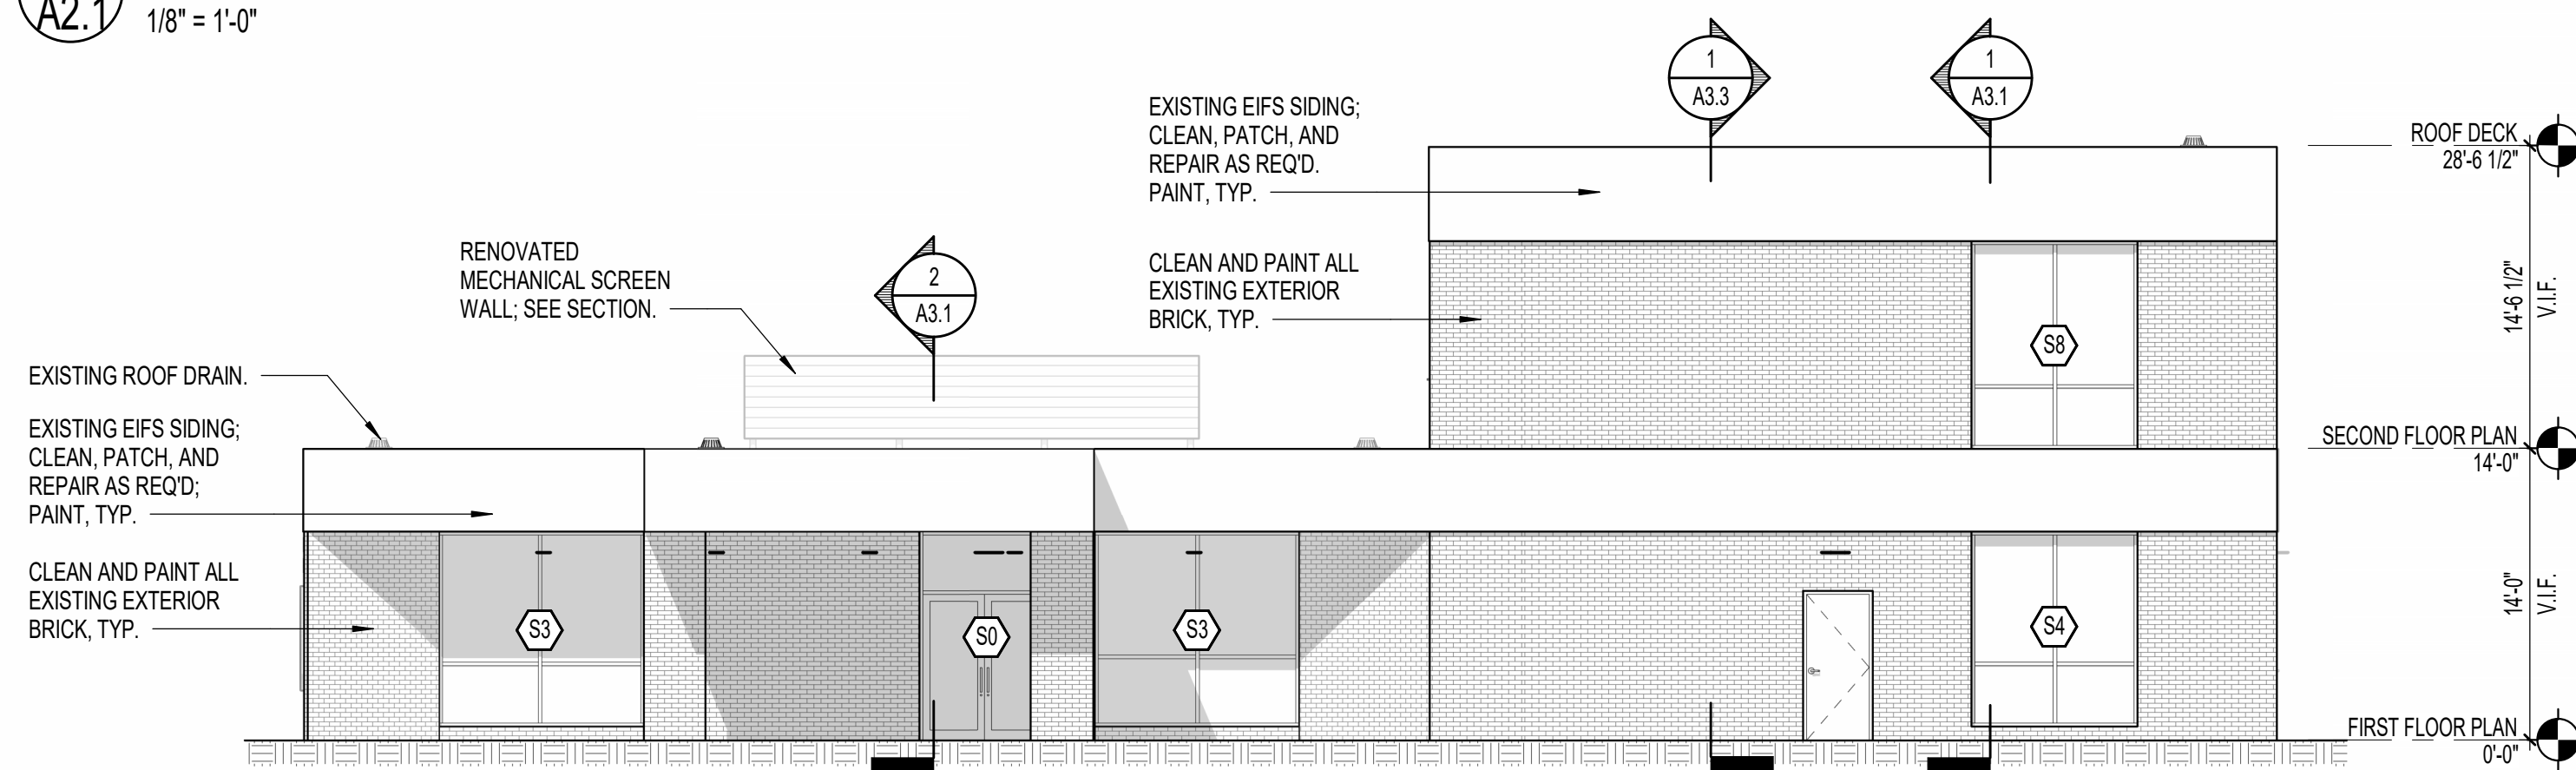

2 SOUTH ELEVATION - BASE BID
A2.1 1/8" = 1'-0"

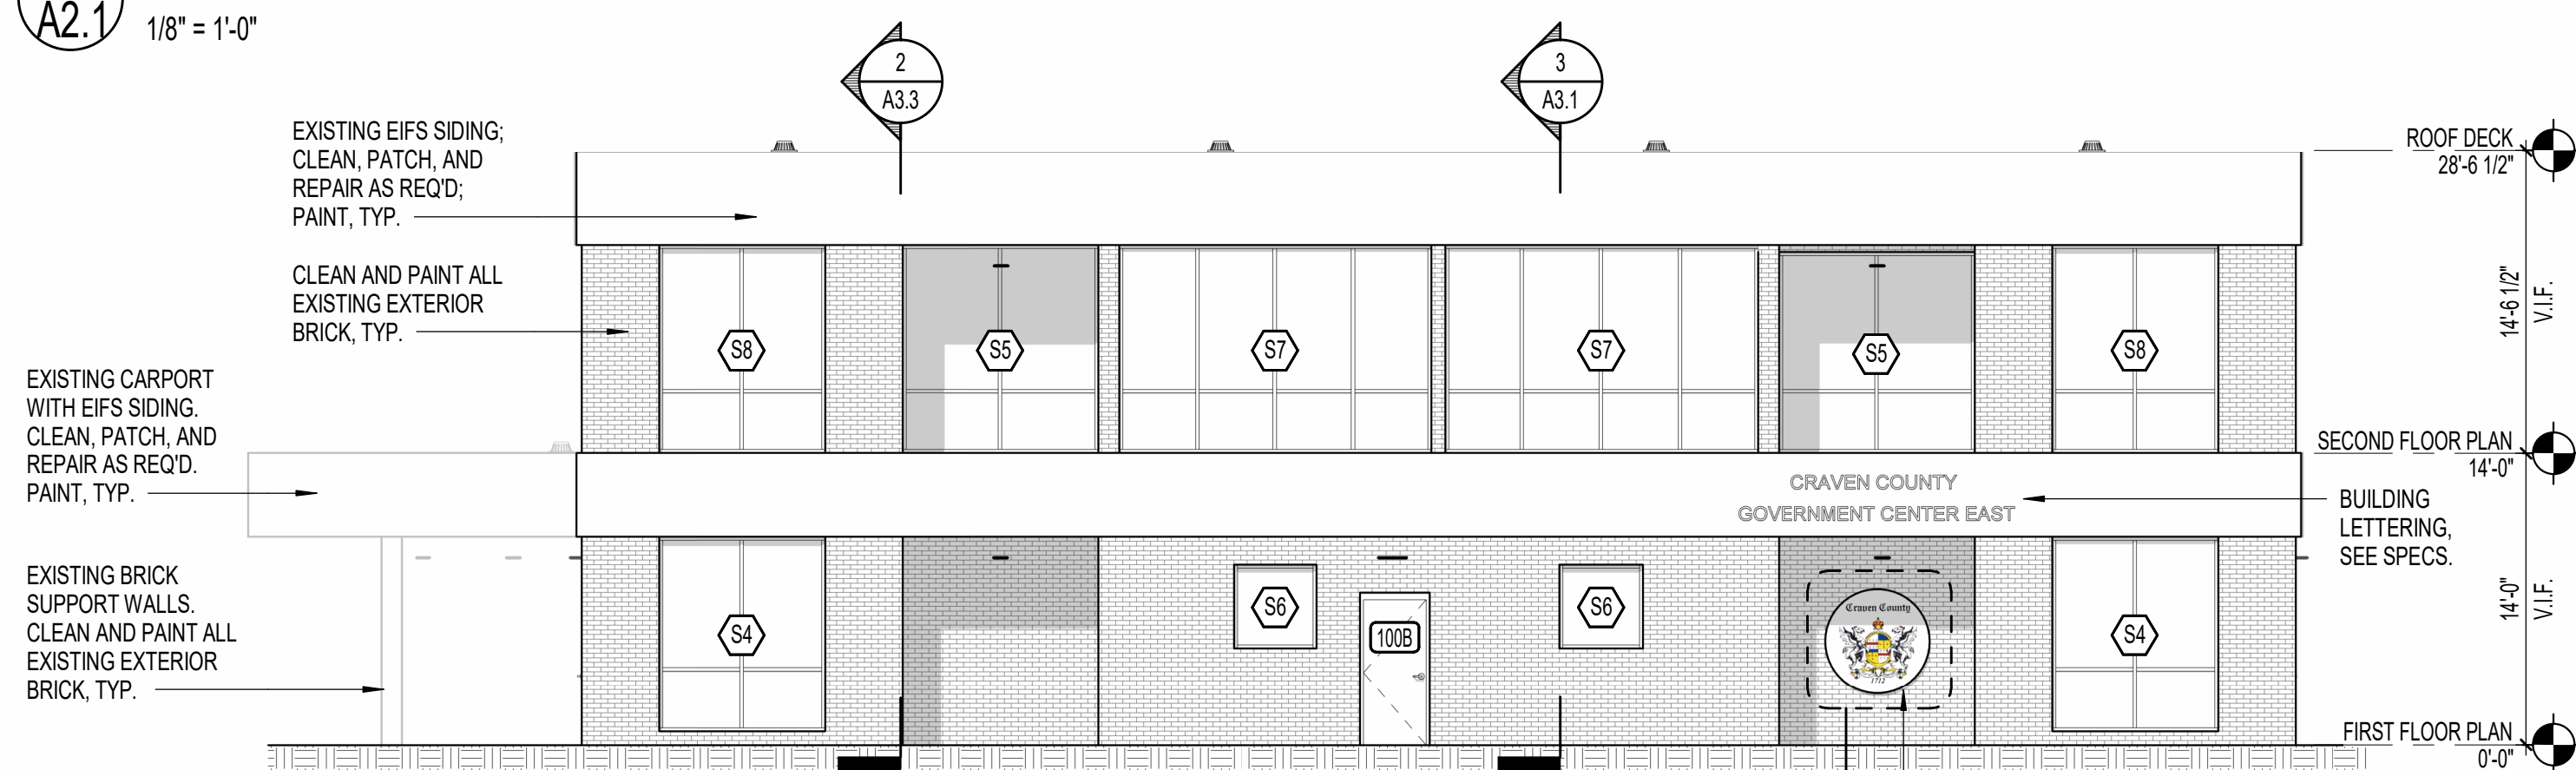


3 EAST ELEVATION - BASE BID
A2.1 1/8" = 1'-0"

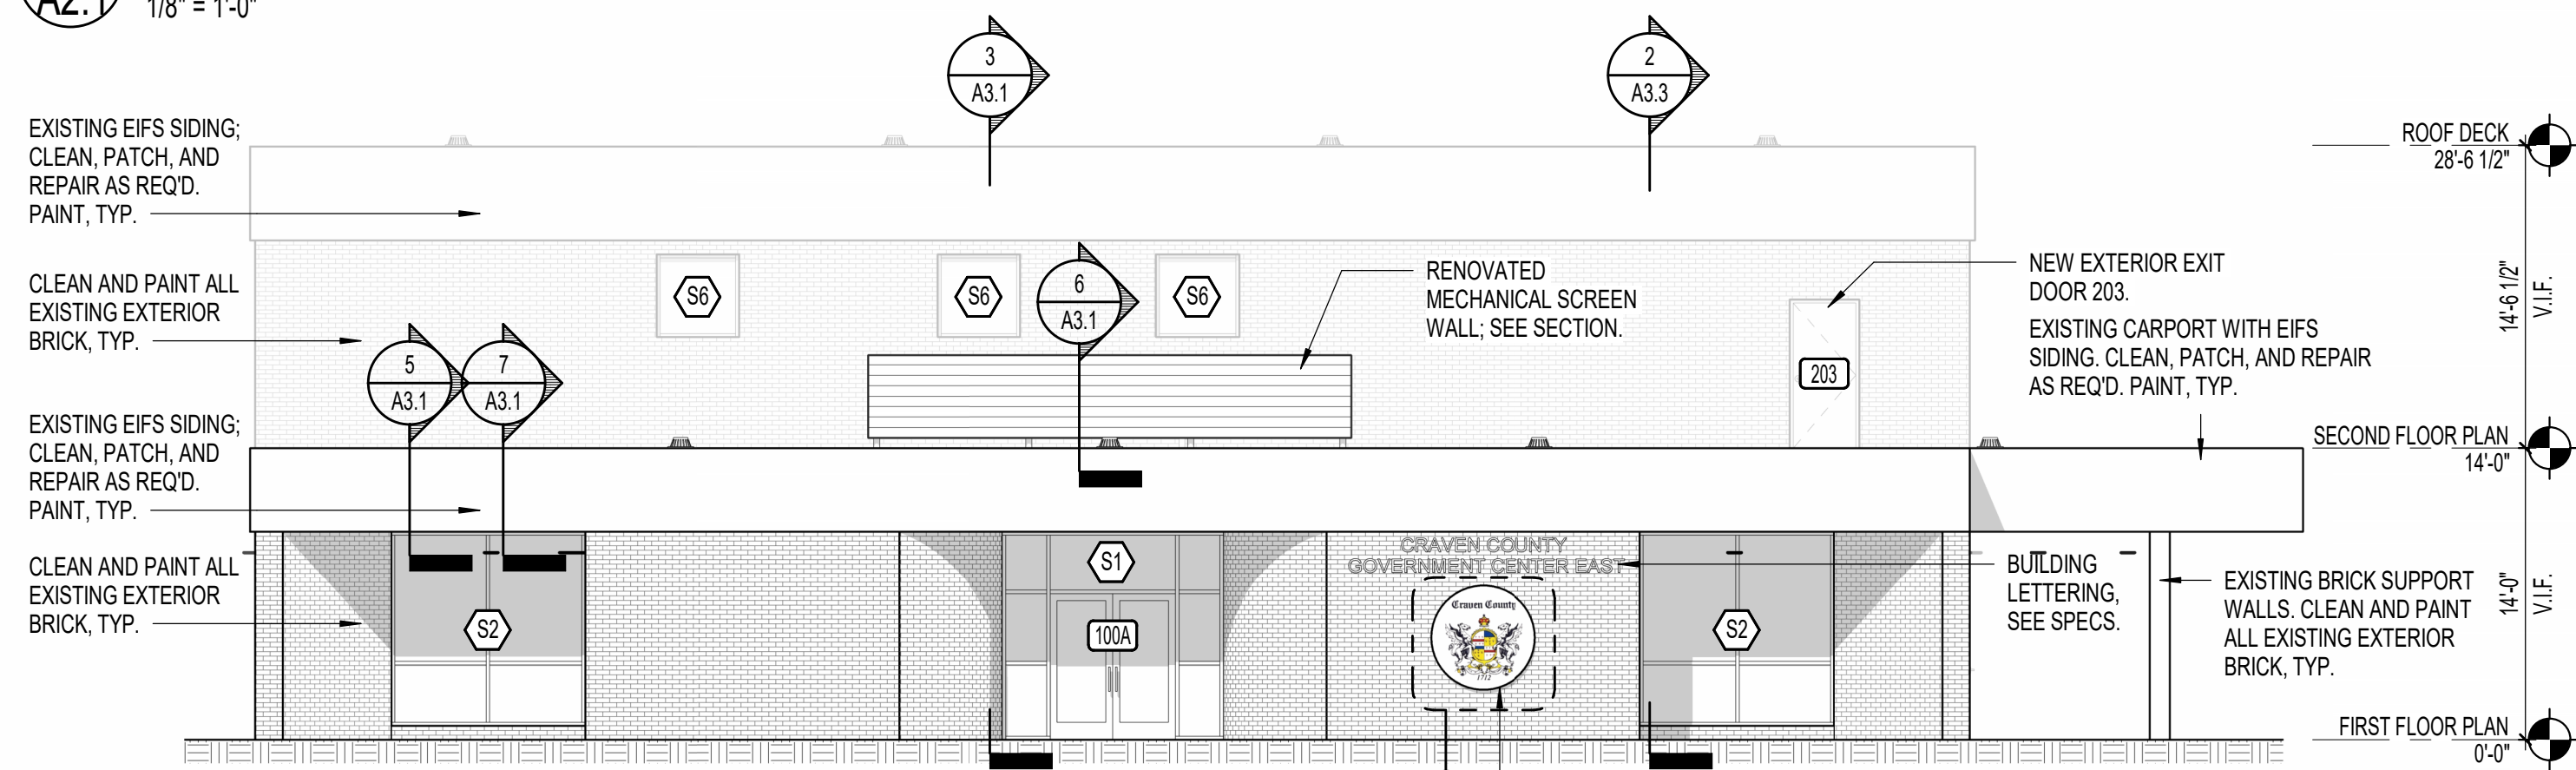


4 WEST ELEVATION - BASE BID
A2.1 1/8" = 1'-0"


Copyright © 2025 Oakley Collier Architects. These drawings are of the property of the Architect for use under his supervision. No reproduction or other use is allowed without permission.

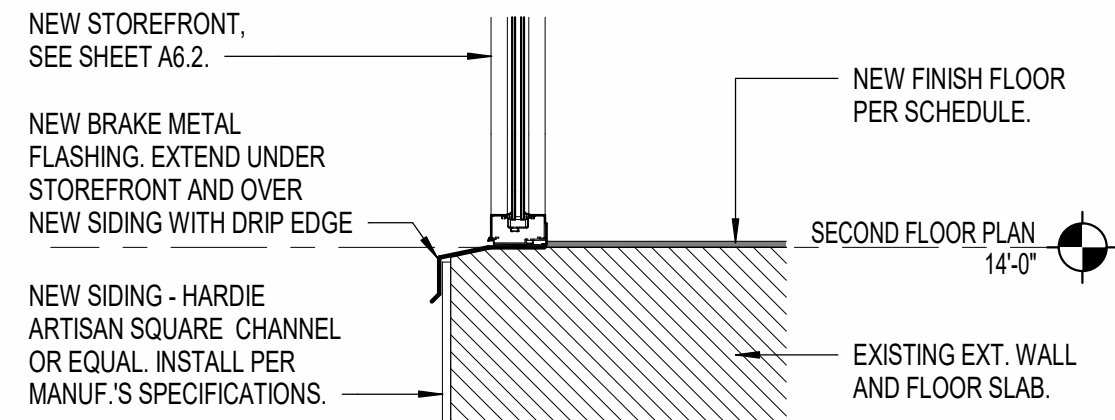


4 SECOND FLOOR STOREFRONT SILL
3/4" = 1'-0"

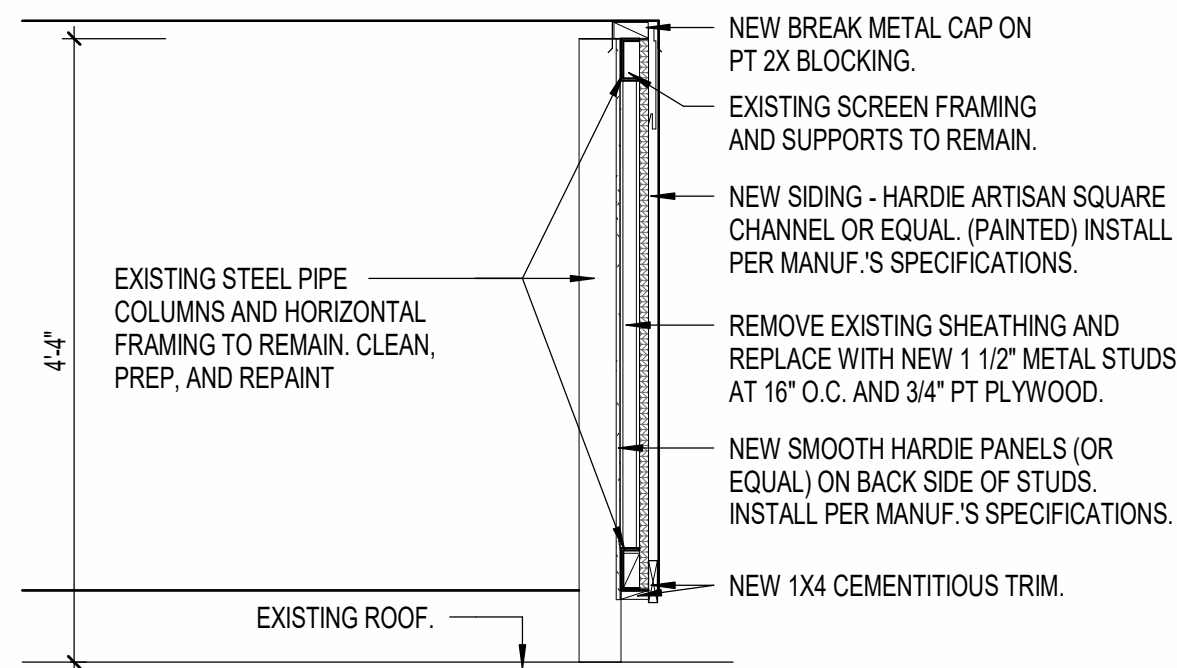

6 SCREEN WALL RENO - BASE BID
3/4" = 1'-0"

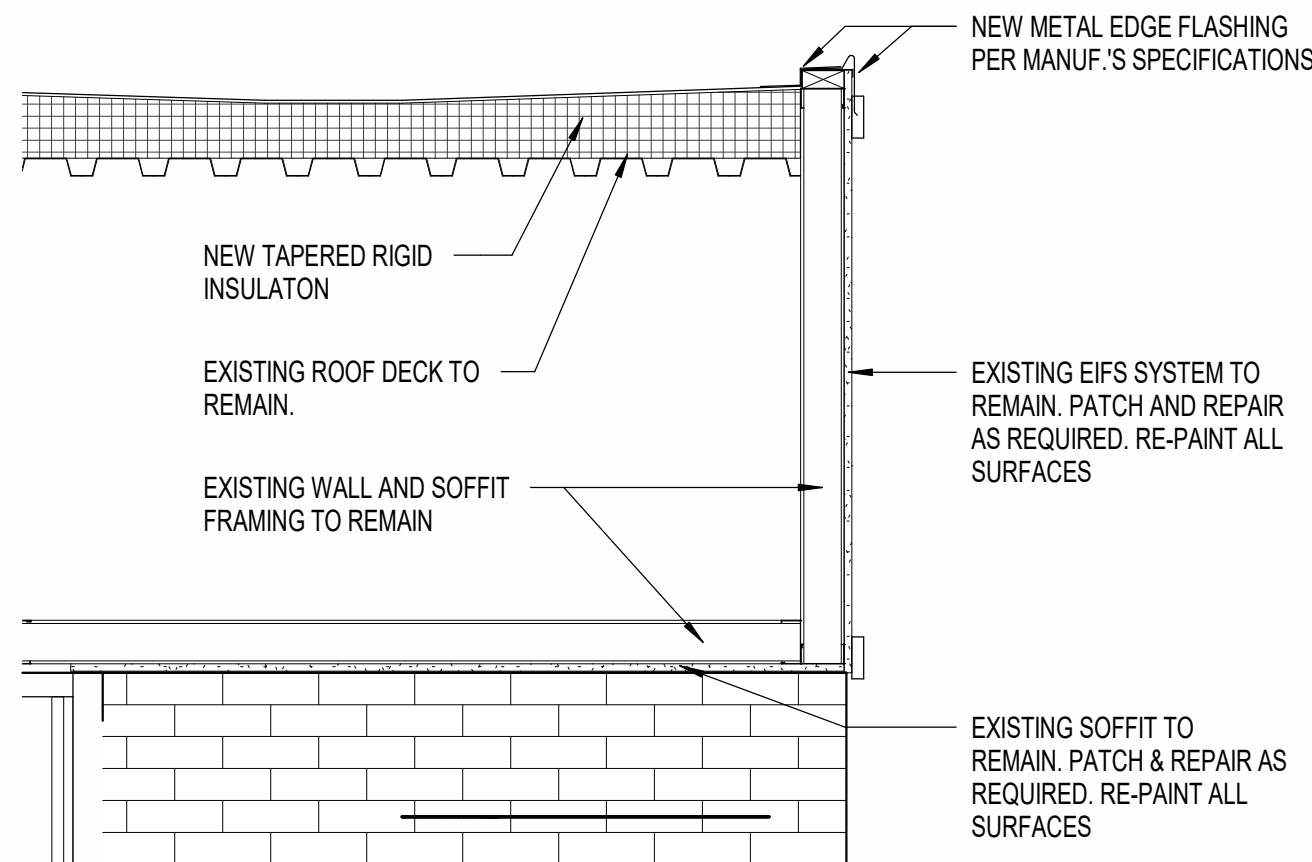


5 WALL SECTION - BASE BID
3/4" = 1'-0"

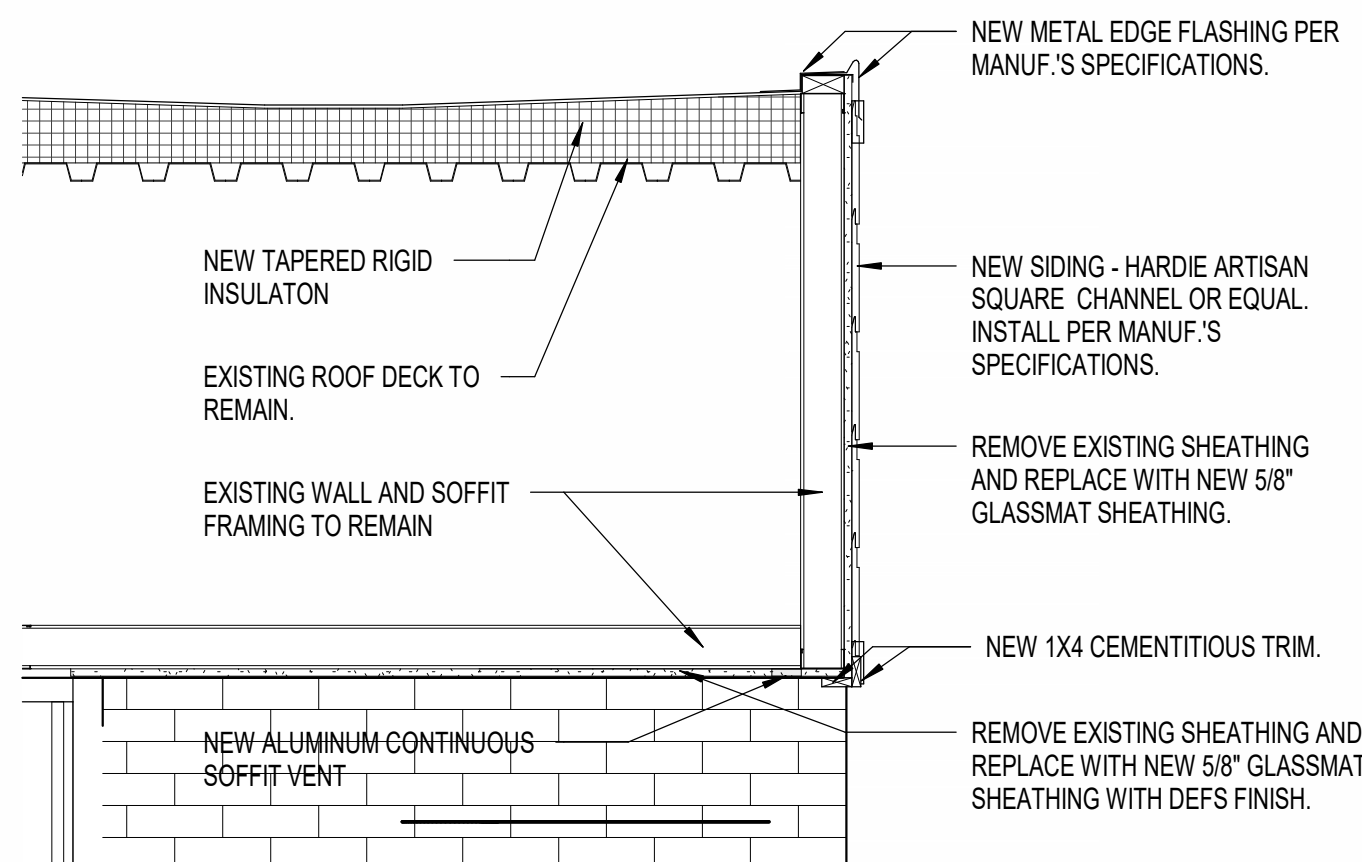


7 WALL SECTION - ALTERNATE G-1
3/4" = 1'-0"




1 E/W BUILDING SECTION 1
1/8" = 1'-0"

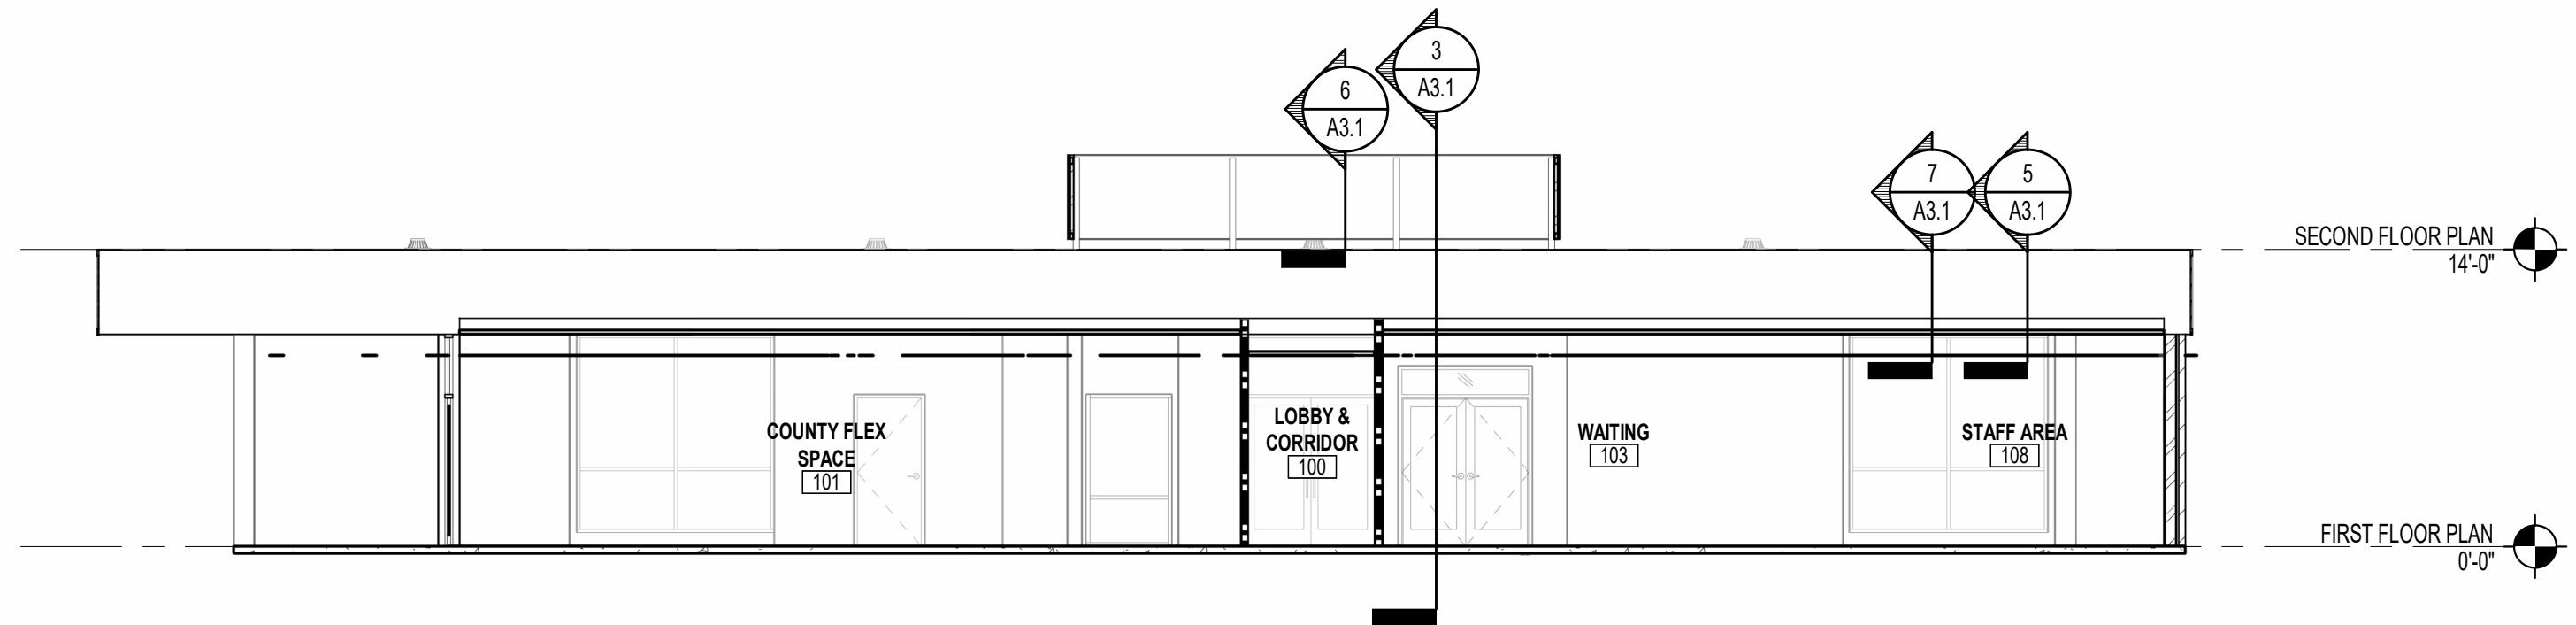

2 E/W BUILDING SECTION 2
1/8" = 1'-0"

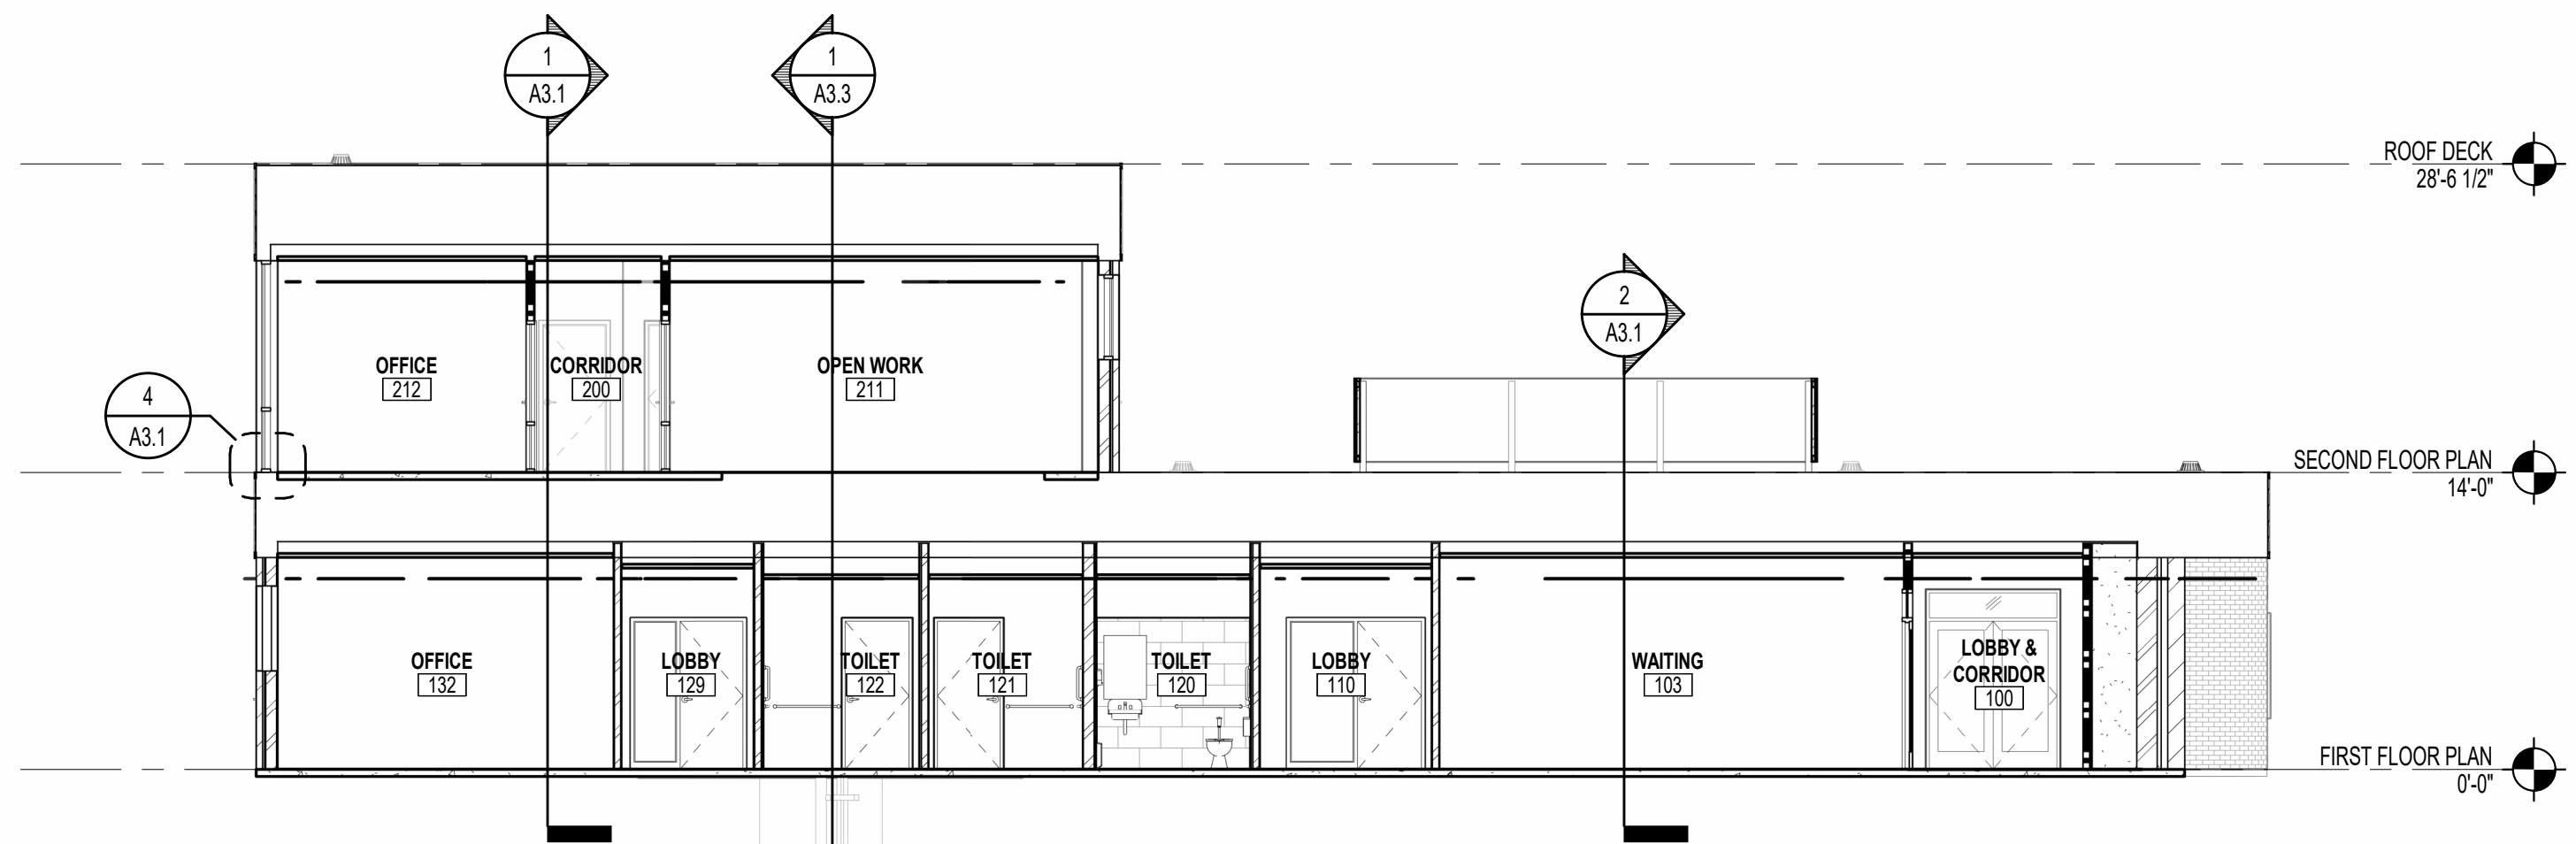

3 N/S BUILDING SECTION 1
1/8" = 1'-0"

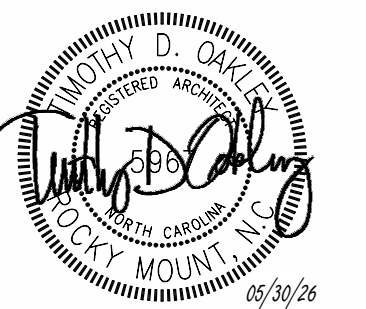


GENERAL NOTE:
Prior to construction start, Contractor shall verify & be responsible for all Dimensions.


Revisions	Description	Date

Date MAY 30 2026	Project No. 25012
Drawn By ACR	Sheet No. A3.1
Checked By DG	
Sheet Title BUILDING SECTIONS & DETAILS	


Copyright © 2025 Oakley Collier Architects. These drawings are of the property of the Architect for use under his supervision. No reproduction or other use is allowed without permission.

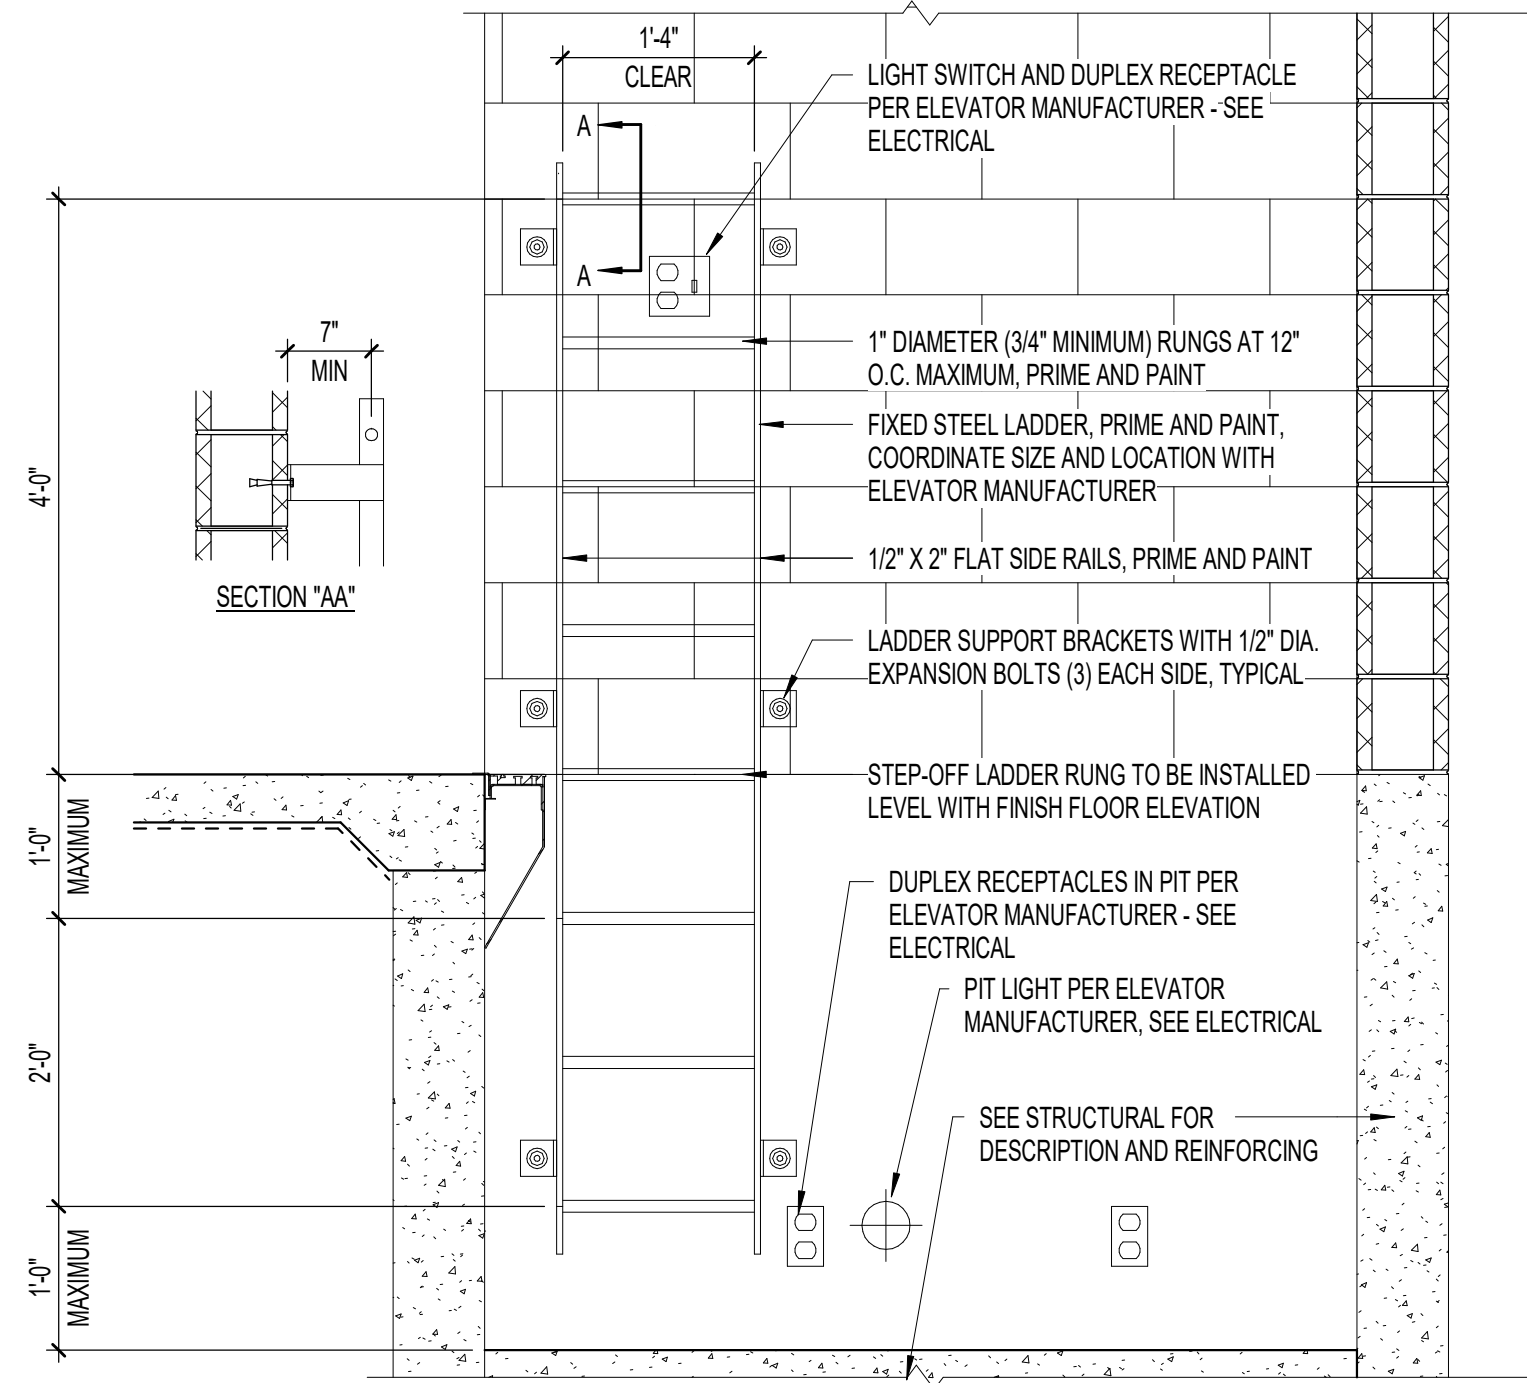


3
A3.3
ELEVATOR PIT DETAIL
3/4" = 1'-0"

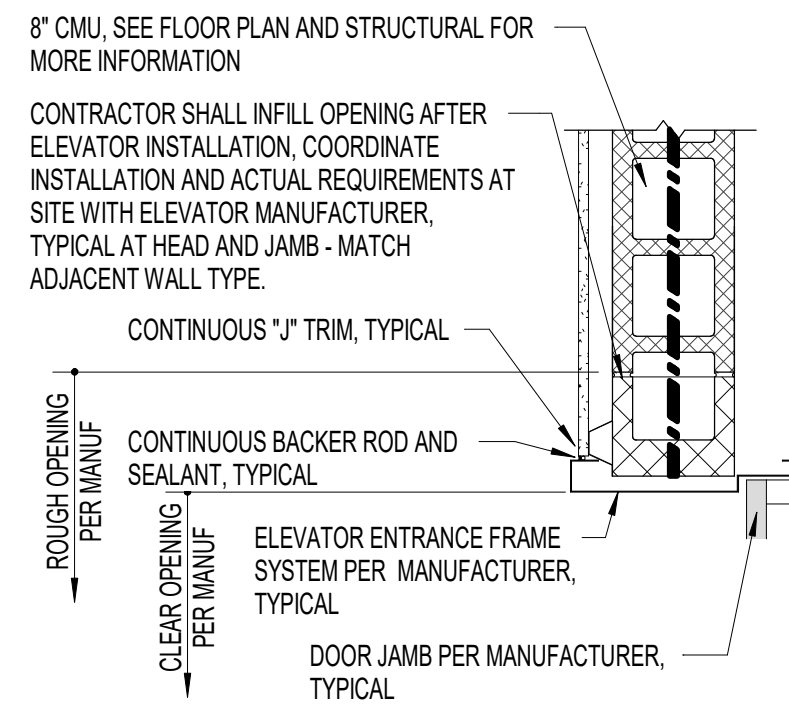


4
A3.3
ELEVATOR JAMB DETAIL
1" = 1'-0"

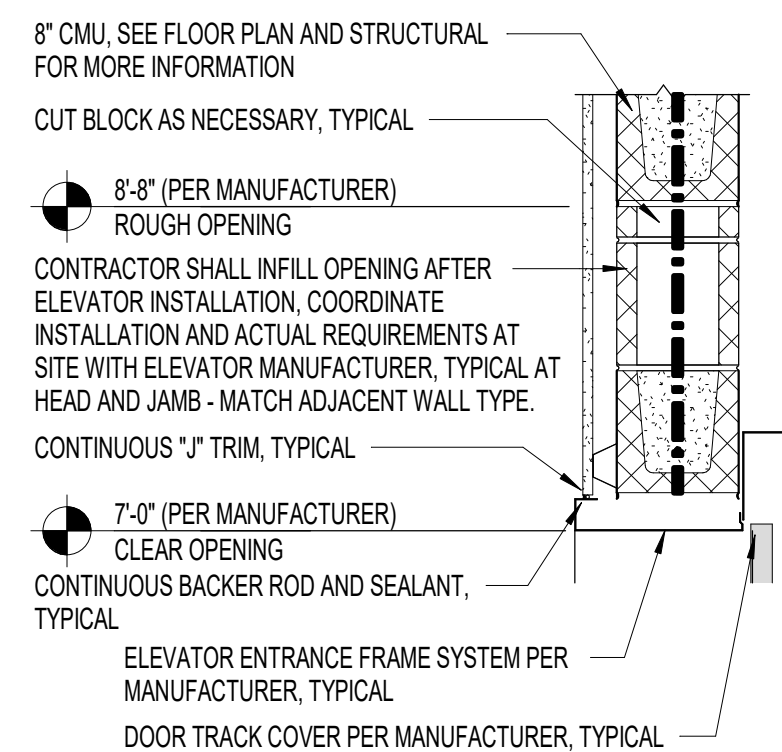


5
A3.3
ELEVATOR HEAD DETAIL
1" = 1'-0"

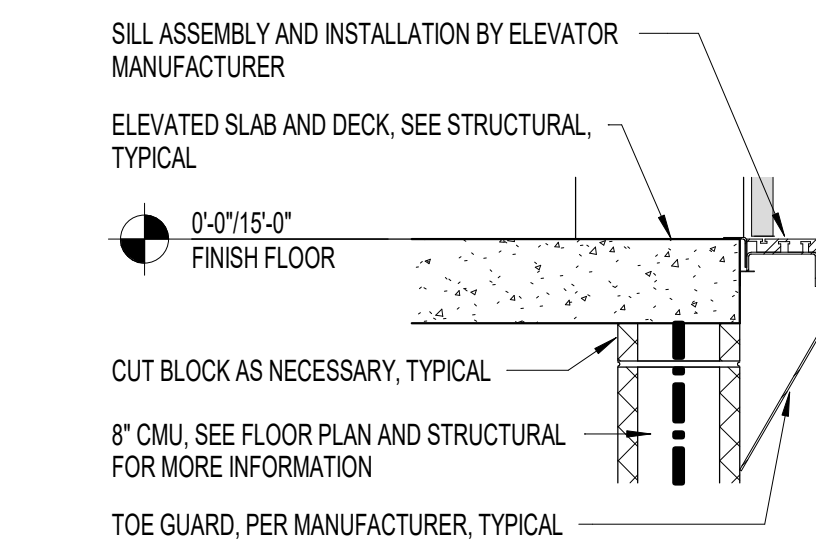

6
A3.3
ELEVATOR SILL DETAIL
1" = 1'-0"

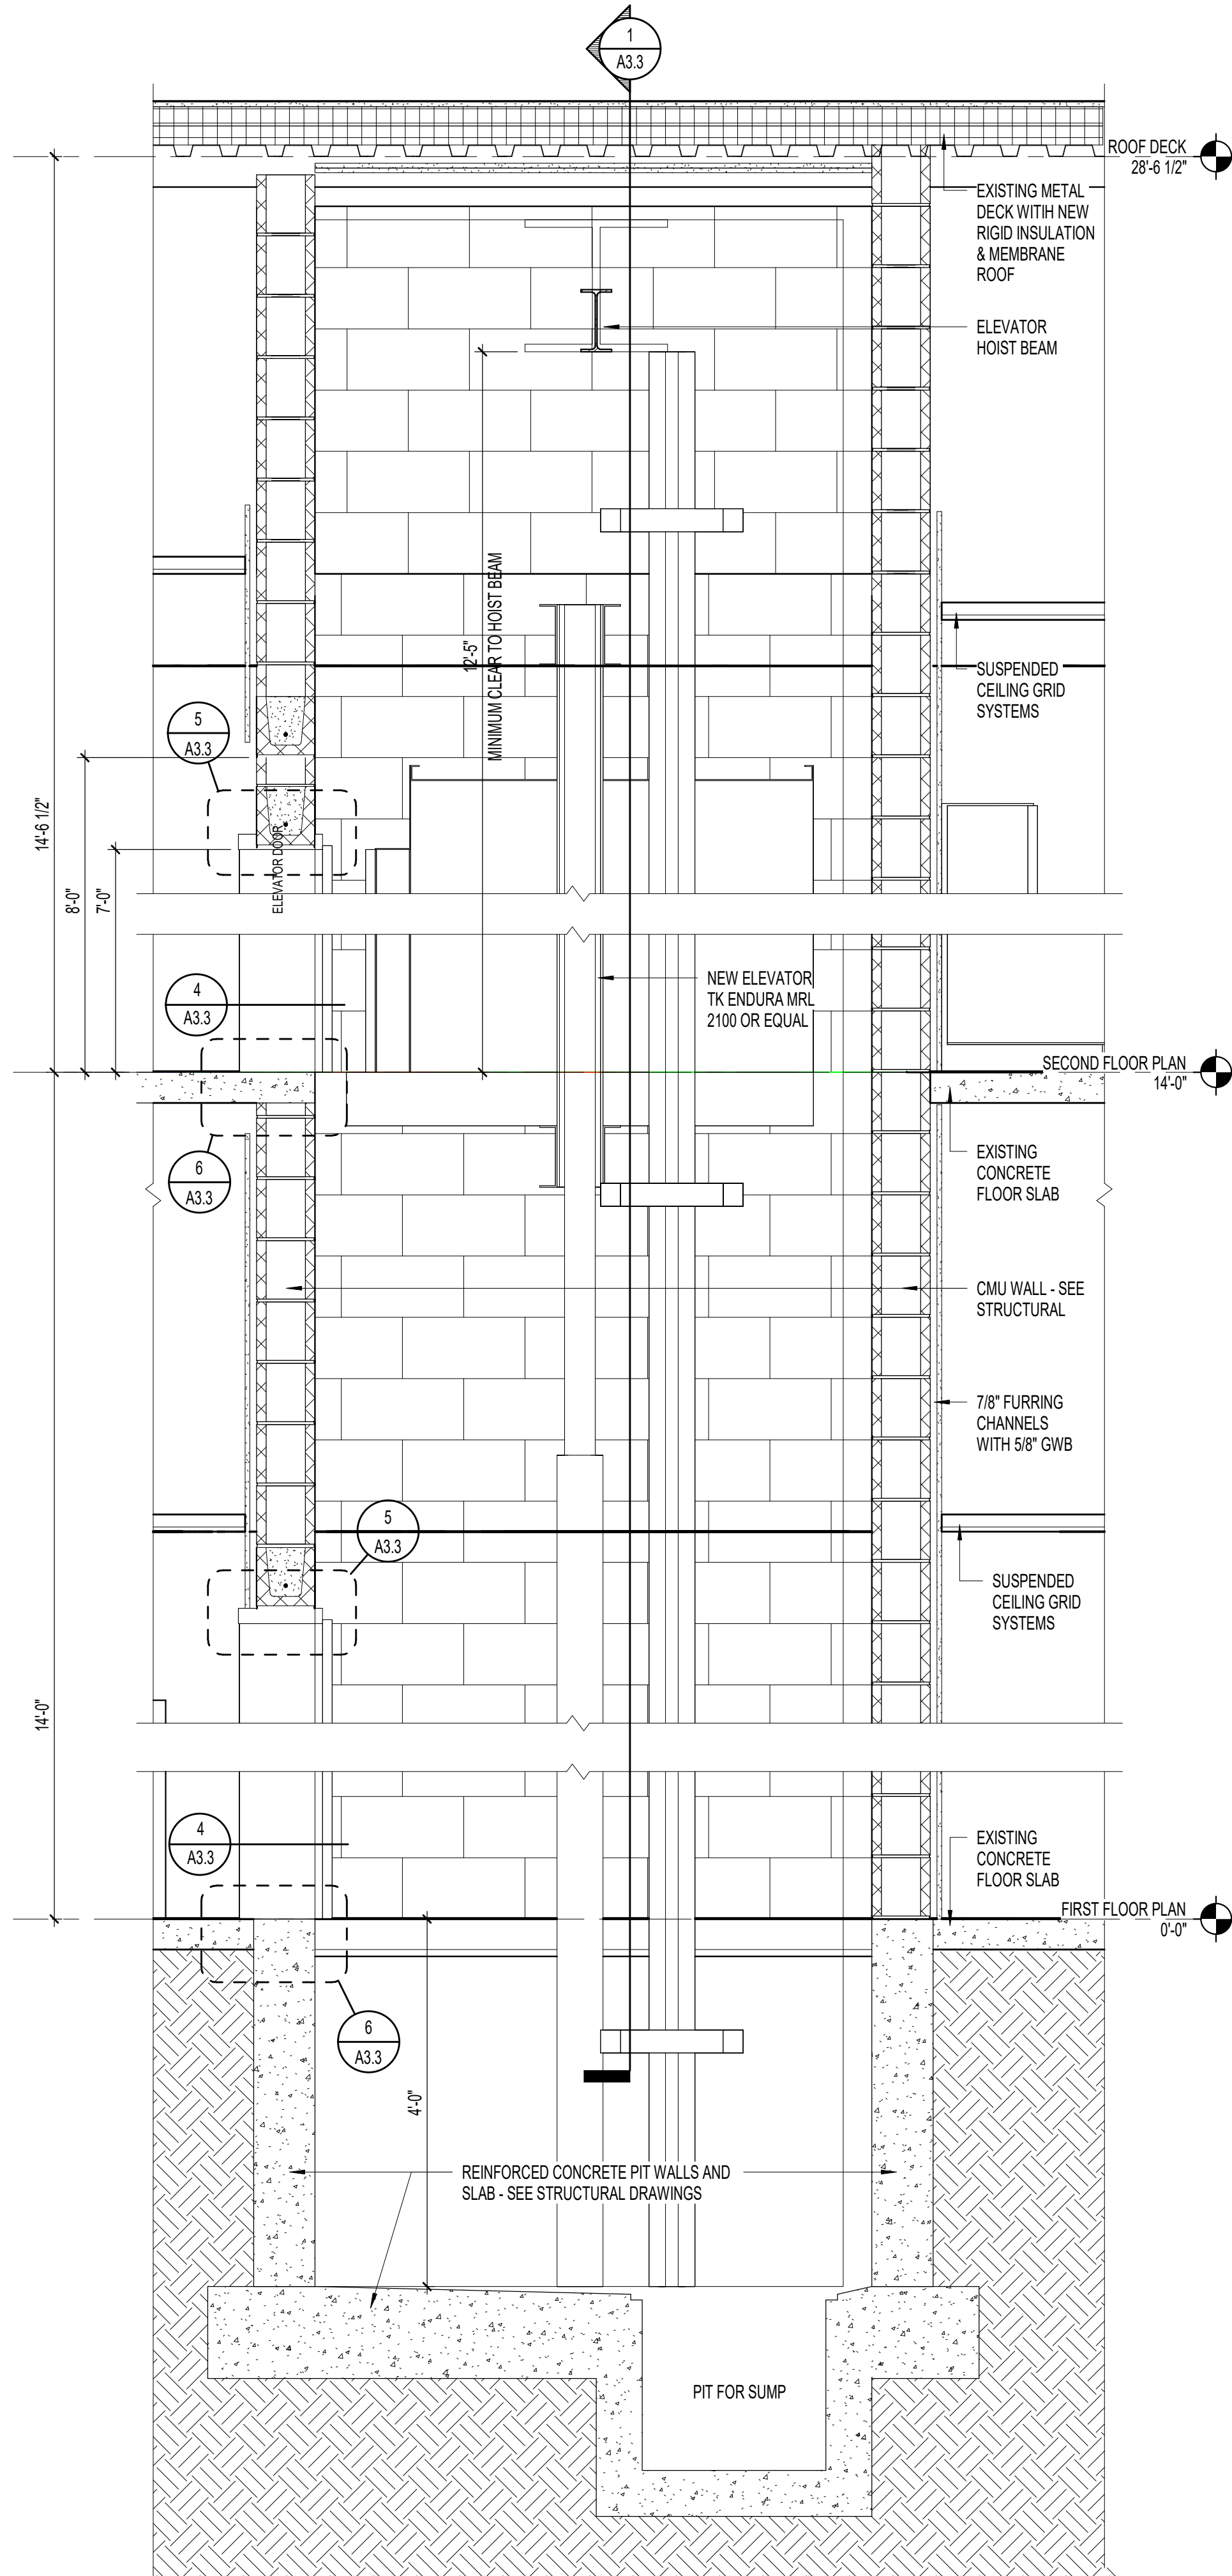

2
A3.3
ELEVATOR SECTION N/S
3/4" = 1'-0"

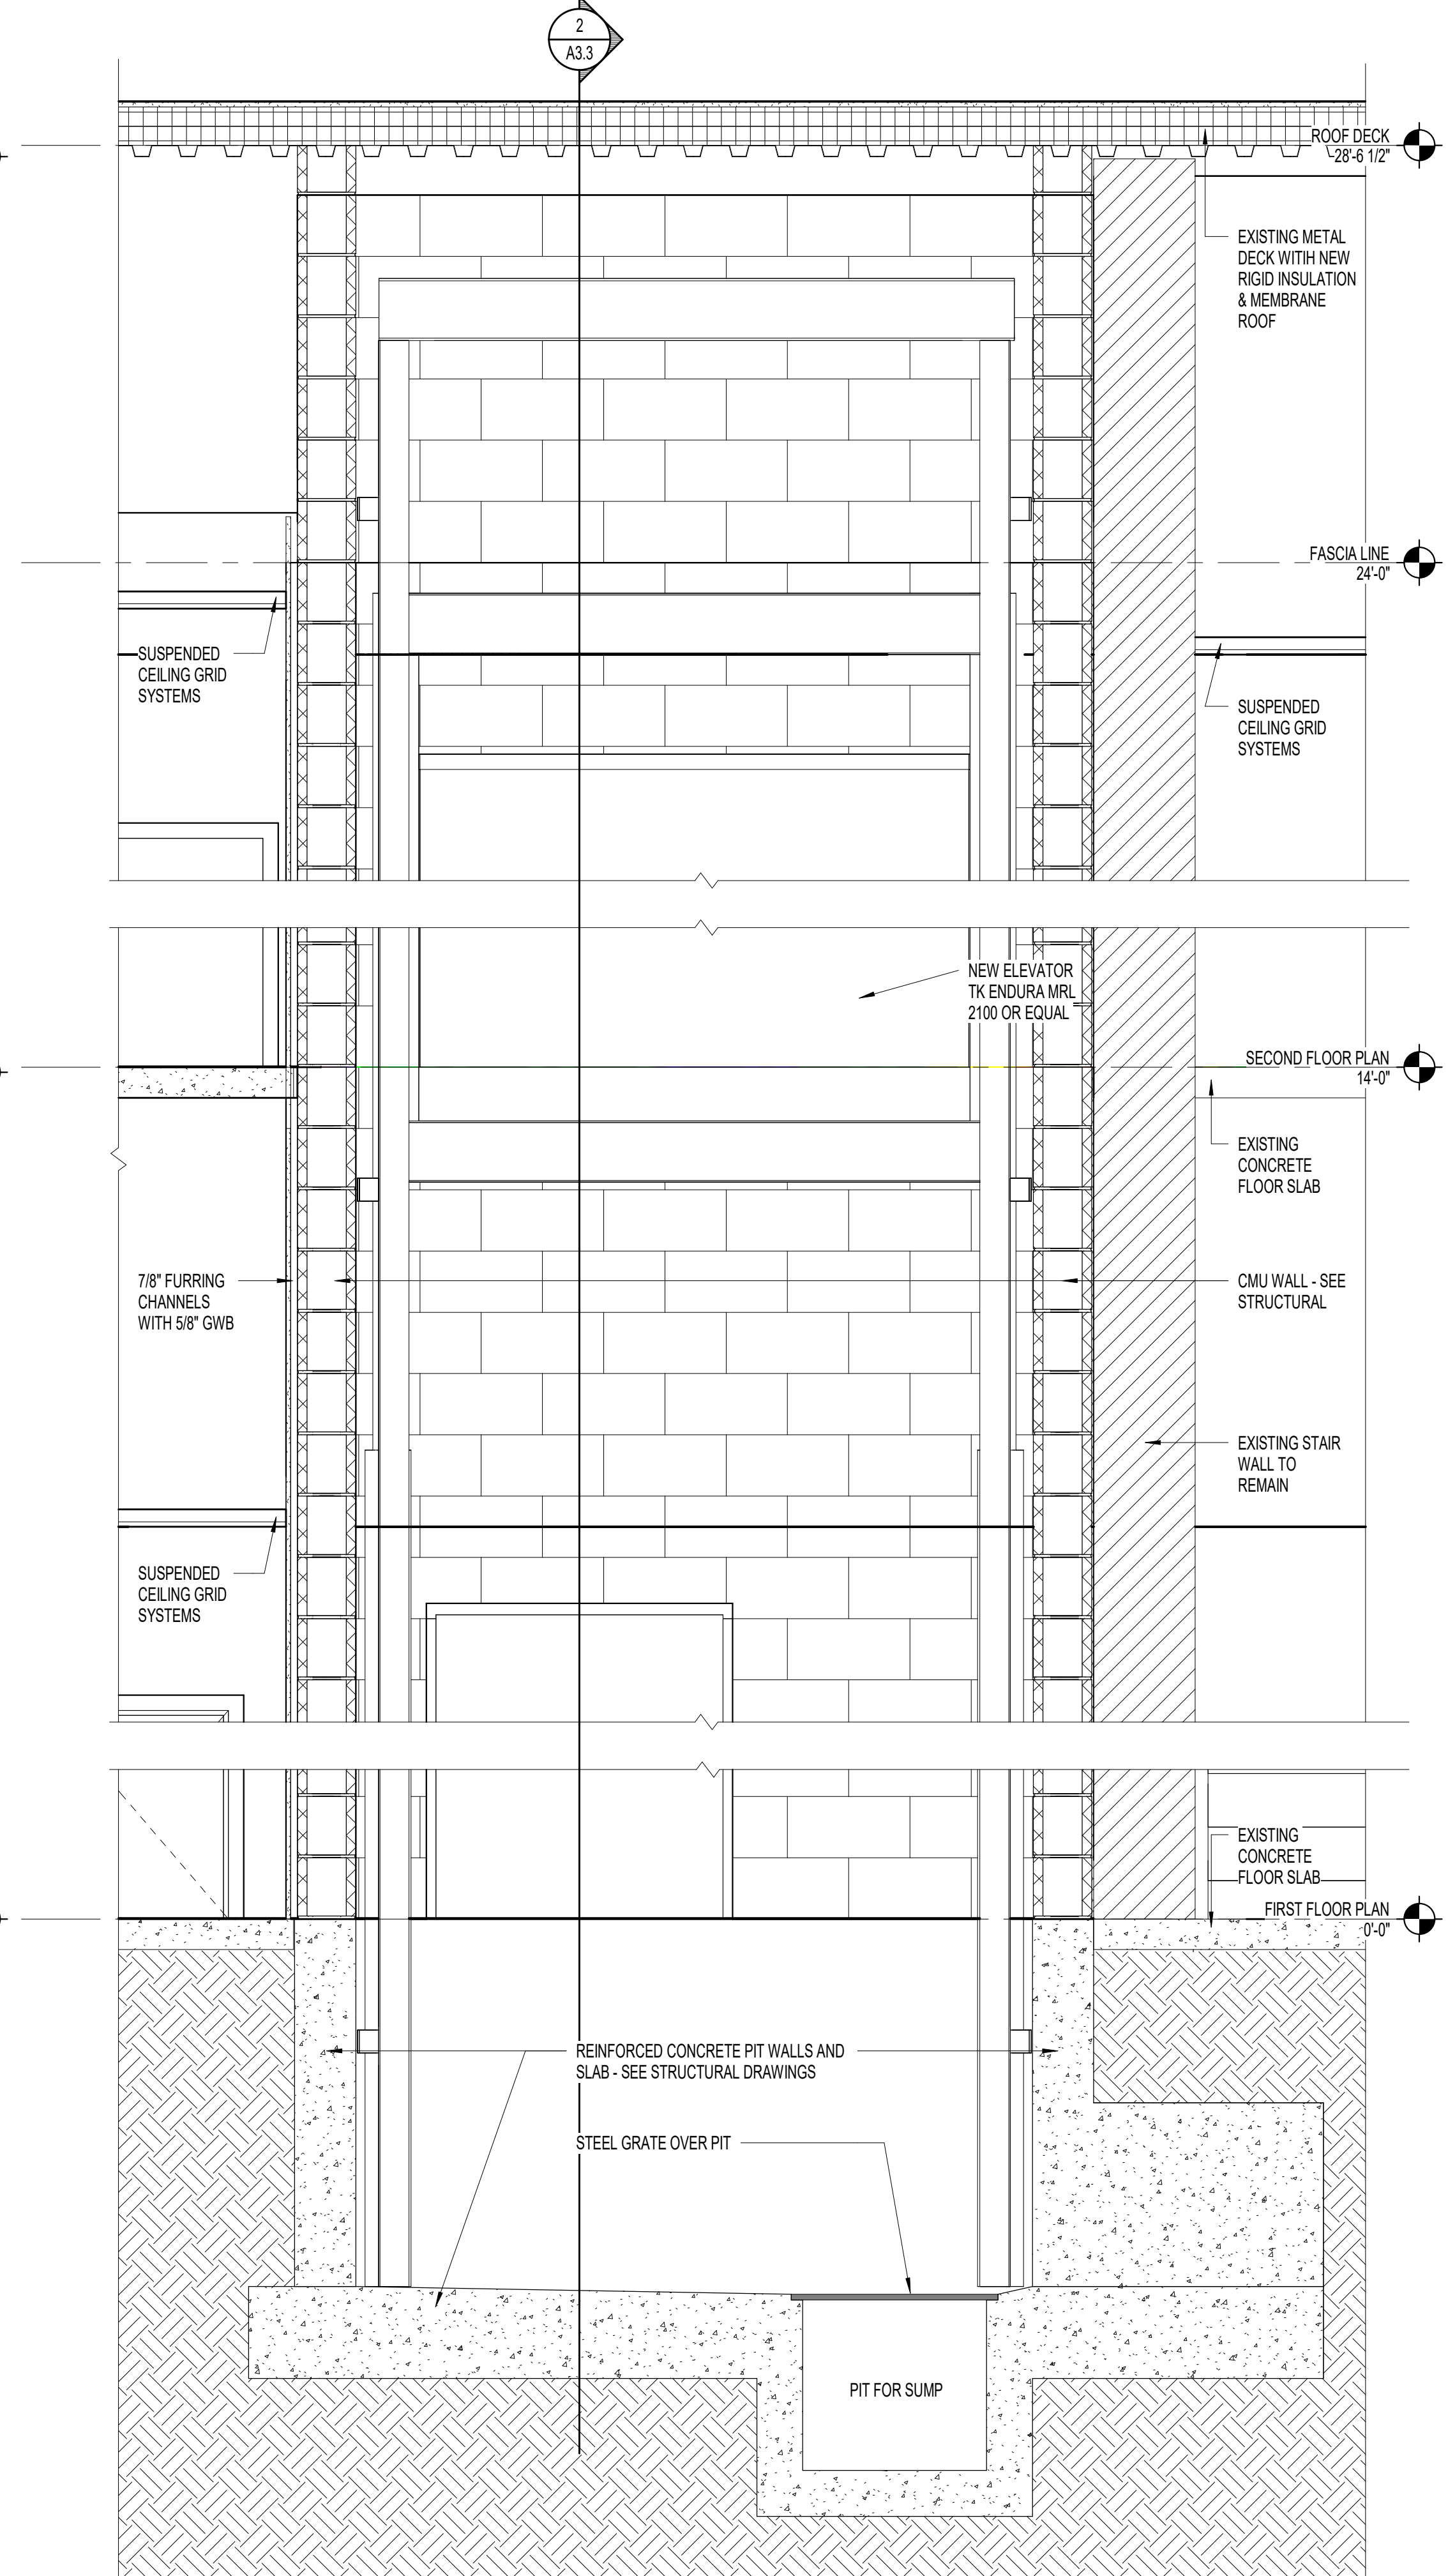

1
A3.3
ELEVATOR SECTION E/W
3/4" = 1'-0"


FULL HEIGHT JACK STUDS, SEE —
HEADER SCHEDULE FOR QUANTITY.

TOP AND BOTTOM TRACK GAGE
SHALL MATCH HEADER GAGE.


UNPUNCHED STUDS, SIZE AND GAGE PER SCHEDULE.

2"x2"x16 GAGE CLIP ANGLES X1/2" LESS THAN
STUD WIDTH; ATTACH WITH (3) #10 SCREWS ON
EACH LEG TO HEADER AND JAMB STUDS.


JAMB STUDS, SEE HEADER SCHEDULE FOR QUANTITY.

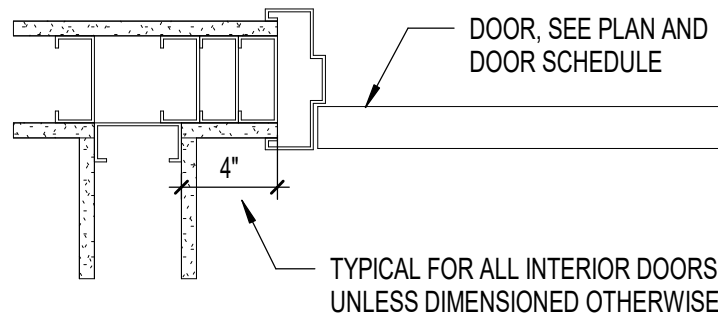

1 TYP
A6.1 1/2" = 1'-0"
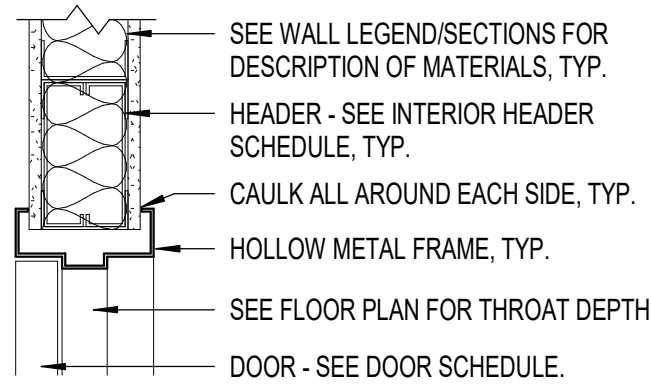
$$1/2'' = 1'-0''$$


3 HEAD
A6.1 1 1/2" = 1'-
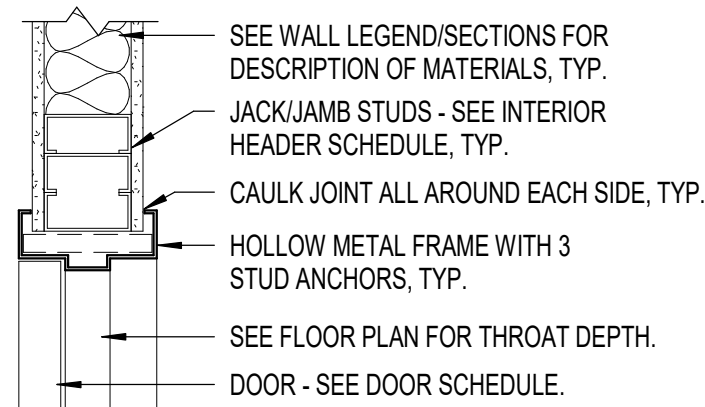
$$1\frac{1}{2}'' = 1'-0$$


2 DOO
A6.1 1 1/2" = 1'-

$$1\frac{1}{2}'' = 1'-0''$$

4 JAMES
A6.1 1 1/2" = 1'-

$$1\frac{1}{2}'' = 1'-0''$$




OPENING	SIZE	JACK	JAMB
0'-0" TO 5'-0"	3 5/8" X 20 GA.	2	2
5'-1" TO 7'-0"	6" X 20 GA.	2	2
7'-1" TO 10'-0"	8" X 20 GA.	2	3
10'-1" TO 18'-0"	10" X 16 GA.	3	4
18'-1" TO 25'-0"	12" X 16 GA.	3	4

ALL BOXED HEADERS SHALL BE SIZED TO FIT WALL SIZES SHOWN
ARE MINIMUMS.

PROVIDE JACK AND JAMB STUDS AT EACH INTERIOR HEADER LOCATION AS SCHEDULED UNLESS NOTED OTHERWISE ON ARCHITECTURAL OR STRUCTURAL PLANS.

SEE STRUCTURAL PLANS FOR ALL EXTERIOR HEADERS.

DOOR NUMBER	SIZE			DOOR DESCRIPTION					FRAME DESCRIPTION				REMARKS	DOOR NUMBER
	WIDTH	HEIGHT	THICKNESS	MATERIAL	FINISH	GLAZING	ELEVATION	RATING	MATERIAL	FINISH	ELEVATION	RATING		
100A	6'-0"	7'-0"	1 3/4"	ALUM	PRE-FINISHED	SEE STOREFRONT ELEV.	S1	N/A	ALUM	PRE-FINISHED	S1	N/A	MAIN ENTRY DOOR.	100A
100B	3'-0"	7'-0"	1 3/4"	HM	PAINTED	NONE	D1	N/A	HM	PAINTED	F2	N/A		NO EXTERIOR ENTRY HARDWARE. PANIC HARDWARE RATED ASSEMBLY.
101A	6'-0"	7'-0"	1 3/4"	S.C. WOOD	STAINED	BY MANUF.	D7	20 MIN	HM	PAINTED	F4	20 MIN		
101B	6'-0"	7'-0"	1 3/4"	ALUM	PRE-FINISHED	SEE STOREFRONT ELEV.	S0	N/A	ALUM	PRE-FINISHED	S0	N/A		EXISTING VAULT DOOR TO REMAIN. DEACTIVATE LOCKING MECHANISM.
102	3'-0"	7'-0"	1 3/4"	ETR	ETR	ETR	ETR	ETR	ETR	ETR	ETR	ETR		
103	6'-0"	7'-0"	1 3/4"	S.C. WOOD	STAINED	BY MANUF.	D7	20 MIN	HM	PAINTED	F4	20 MIN		RATED ASSEMBLY.
104	3'-0"	7'-0"	1 3/4"	S.C. WOOD	STAINED	NONE	D1	20 MIN	HM	PAINTED	F1	20 MIN		
105	2'-0"	7'-0"	1 3/4"	S.C. WOOD	STAINED	NONE	D2	N/A	HM	PAINTED	F1	20 MIN		LOUVERED DOOR.
106	3'-0"	7'-0"	1 3/4"	S.C. WOOD	STAINED	NONE	D1	N/A	HM	PAINTED	F1	N/A	SOUND SEALS REQUIRED.	
108	3'-0"	7'-0"	1 3/4"	HM	PAINTED	NONE	D1	N/A	HM	PAINTED	F2	N/A		INFILL SURROUNDING WALL WITH BRICK FACADE TO MATCH EXISTING.
109	3'-0"	7'-0"	1 3/4"	S.C. WOOD	STAINED	SG-CT	D3	N/A	HM	PAINTED	F1	N/A		
110	3'-0"	7'-0"	1 3/4"	S.C. WOOD	STAINED	RSG-CT	D5	20 MIN	HM	PAINTED	F3	N/A		
111	3'-0"	7'-0"	1 3/4"	S.C. WOOD	STAINED	NONE	D1	20 MIN	HM	PAINTED	F1	20 MIN	SOUND SEALS REQUIRED.	
112A	3'-0"	7'-0"	1 3/4"	S.C. WOOD	STAINED	RSG-CT	D3	20 MIN	HM	PAINTED	F1	20 MIN		
112B	3'-0"	7'-0"	1 3/4"	S.C. WOOD	STAINED	NONE	D1	N/A	HM	PAINTED	F1	N/A		
113	6'-0"	7'-0"	1 3/4"	S.C. WOOD	STAINED	NONE	D6	N/A	HM	PAINTED	F1	N/A		
114A	3'-0"	7'-0"	1 3/4"	HM	PAINTED	NONE	D1	N/A	HM	PAINTED	F2	N/A		
114B	3'-0"	7'-0"	1 3/4"	HM	PAINTED	RSG-CT	D3	60 MIN	HM	PAINTED	F2	60 MIN		
116	3'-0"	7'-0"	1 3/4"	S.C. WOOD	STAINED	NONE	D1	N/A	HM	PAINTED	F1	N/A		
117	3'-0"	7'-0"	1 3/4"	S.C. WOOD	STAINED	NONE	D1	20 MIN	HM	PAINTED	F1	N/A		
118	3'-0"	7'-0"	1 3/4"	S.C. WOOD	STAINED	NONE	D1	N/A	HM	PAINTED	F1	N/A	SOUND SEALS REQUIRED.	
119	3'-0"	7'-0"	1 3/4"	S.C. WOOD	STAINED	NONE	D1	20 MIN	HM	PAINTED	F1	20 MIN		SOUND SEALS REQUIRED.
120	3'-0"	7'-0"	1 3/4"	S.C. WOOD	STAINED	NONE	D1	N/A	HM	PAINTED	F1	N/A	SOUND SEALS REQUIRED.	
121	3'-0"	7'-0"	1 3/4"	S.C. WOOD	STAINED	NONE	D1	20 MIN	HM	PAINTED	F1	20 MIN		SOUND SEALS REQUIRED.
122	3'-0"	7'-0"	1 3/4"	S.C. WOOD	STAINED	NONE	D1	20 MIN	HM	PAINTED	F1	20 MIN	SOUND SEALS REQUIRED.	
123	3'-0"	7'-0"	1 3/4"	S.C. WOOD	STAINED	NONE	D1	N/A	HM	PAINTED	F1	N/A		SOUND SEALS REQUIRED.
124	3'-0"	7'-0"	1 3/4"	S.C. WOOD	STAINED	SG-CT	D3	N/A	HM	PAINTED	F1	N/A		
125	3'-0"	7'-0"	1 3/4"	S.C. WOOD	STAINED	SG-CT	D3	N/A	HM	PAINTED	F1	N/A		
126A	3'-0"	7'-0"	1 3/4"	HM	PAINTED	NONE	D1	N/A	HM	PAINTED	F1	N/A		
126B	3'-0"	7'-0"	1 3/4"	S.C. WOOD	STAINED	SG-CT	D3	N/A	HM	PAINTED	F1	N/A		
128A	3'-0"	7'-0"	1 3/4"	HM	PAINTED	NONE	D1	N/A	HM	PAINTED	F2	N/A		
128B	3'-0"	7'-0"	1 3/4"	HM	PAINTED	RSG-CT	D3	60 MIN	HM	PAINTED	F2	60 MIN		
129	3'-0"	7'-0"	1 3/4"	S.C. WOOD	STAINED	RSG-CT	D5	20 MIN	HM	PAINTED	F3	20 MIN		

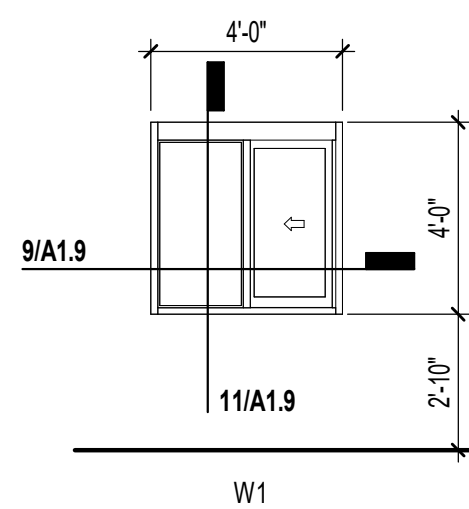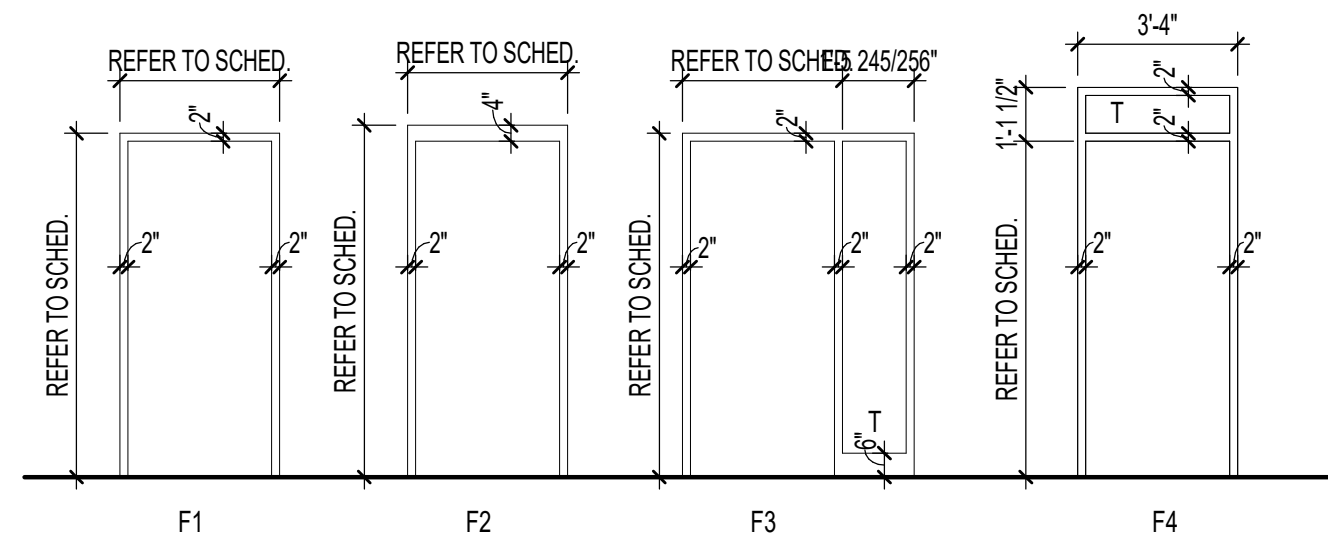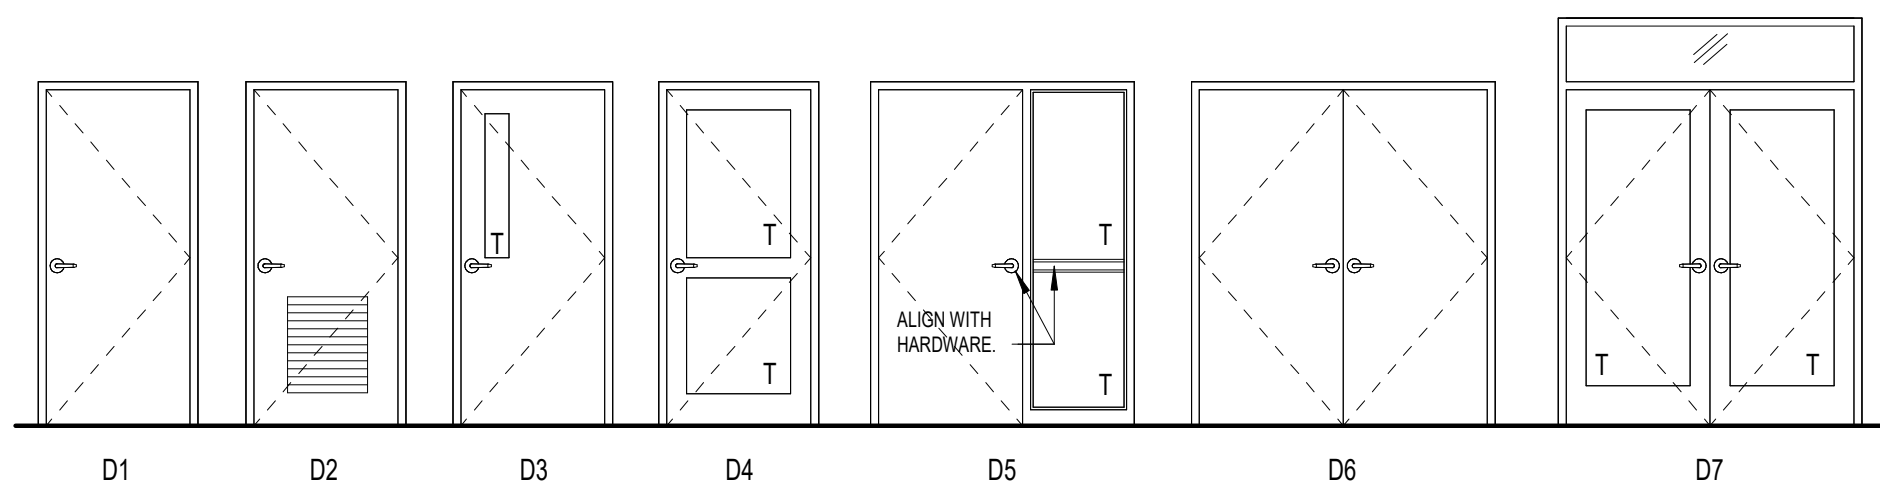
$$1/4'' = 1'-0''$$

$$1/4" = 1'-0"$$

$$1/4'' = 1'-0''$$

1. ALL HARDWARE SHALL MEET ALL APPLICABLE HANDICAP CODES.
2. TEMPERED GLAZING SHALL BE USED AS NOTED AND AS REQUIRED BY CODE.
3. EXTERIOR DOOR GLAZING SHALL BE 5/8" TEMPERED INSULATING, TYPICAL, U.O.
4. EXTERIOR DOOR GLAZING SHALL BE TINTED TO MATCH STOREFRONT GLAZING
5. FURNISH AND INSTALL DOOR CLOSERS AS SCHEDULED IN COMPLIANCE WITH ALL APPLICABLE CODES.
6. ALL HOLLOW METAL DOOR FRAMES SHALL BE FULLY WELDED TYPE, FACTORY PRIMED, AND FIELD PAINTED. COLOR PER ARCHITECT. INSTALL PER MANUFACTURER FOR PROPER INSTALLATION AND OPERATION FOR SPECIFIC APPLICATIONS.
7. ALL WOOD DOOR SHALL BE STAIN GRADE, SPECIES, AND COLOR PER ARCHITECT.
8. ALL ALUMINUM STOREFRONT AND DOORS SHALL BE PREFINISHED COLOR AS SELECTED BY ARCHITECT FROM MANUFACTURER'S FULL RANGE OF COLORS.
9. DOOR THRESHOLDS SHALL BE 1/2" MAXIMUM HEIGHT.
10. ALL EXISTING DOORS, ASSOCIATED DOOR HARDWARE, AND FRAMES TO REMAIN SHALL BE ACCESSED PRIOR TO RENOVATION. ALL EXISTING DOORS, DOOR HARDWARE, AND FRAMES TO REMAIN SHALL BE CLEANED & REFURBISHED TO MATCH PROJECT STANDARDS.

LEGEND		DESIGNATIONS	
IG	INSULATED GLASS	IG - 1 IG - 2	TINTED TINTED TEMPERED
SG	SAFETY GLASS	SG - C SG - CT	CLEAR CLEAR, TEMPERED
RSG	RATED SAFETY GLASS	RSG-C RSG-CT	RATED SAFETY GLASS, CLEAR RATED SAFETY GLASS, CLEAR, TEMPERED

RENOVATION FOR.

RENOVATION FOR:
CRAVEN COUNTY GOVERNMENT CENTER

EAST

CRAVEN COUNTY

1208 E. MAIN STREET, HAVELOCK, NORTH CAROLINA 28532





**OAKLEY
COLLIER
ARCHITECTS**

OCA


09 Candlewood Road, Rocky Mount, NC 27804 (P) 252.937.2500
205 W. Martin Street, Raleigh, NC 27601

109 Candlewood Road, Rocky Mount, NC 27804 (P) 252.937.2500
205 W. Martin Street, Raleigh, NC 27601


Copyright © 2025 Oakley Collier Architects. These drawings are of the property of the Architect for use under his supervision. No reproduction or other use is allowed without permission.

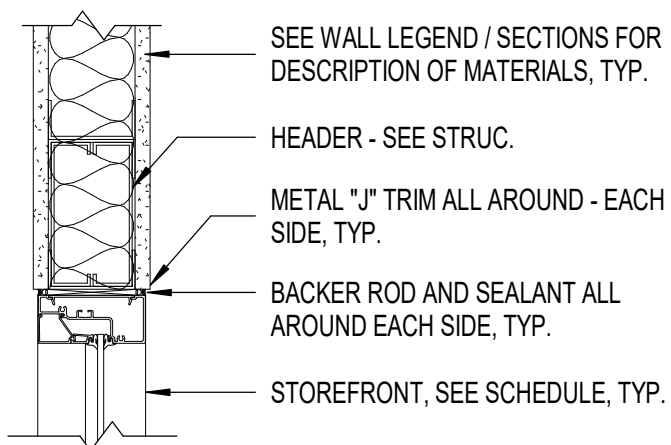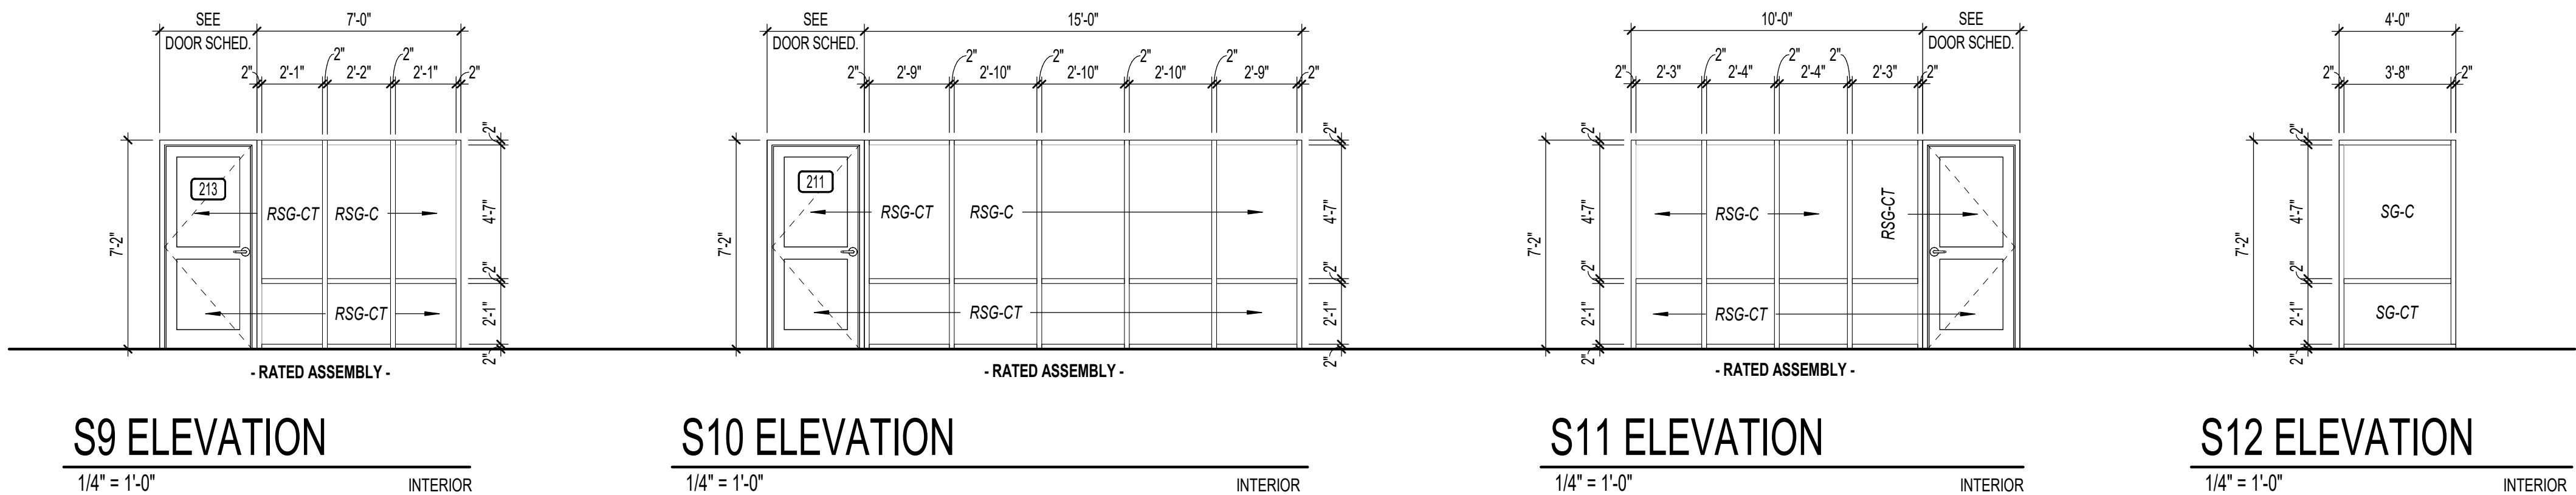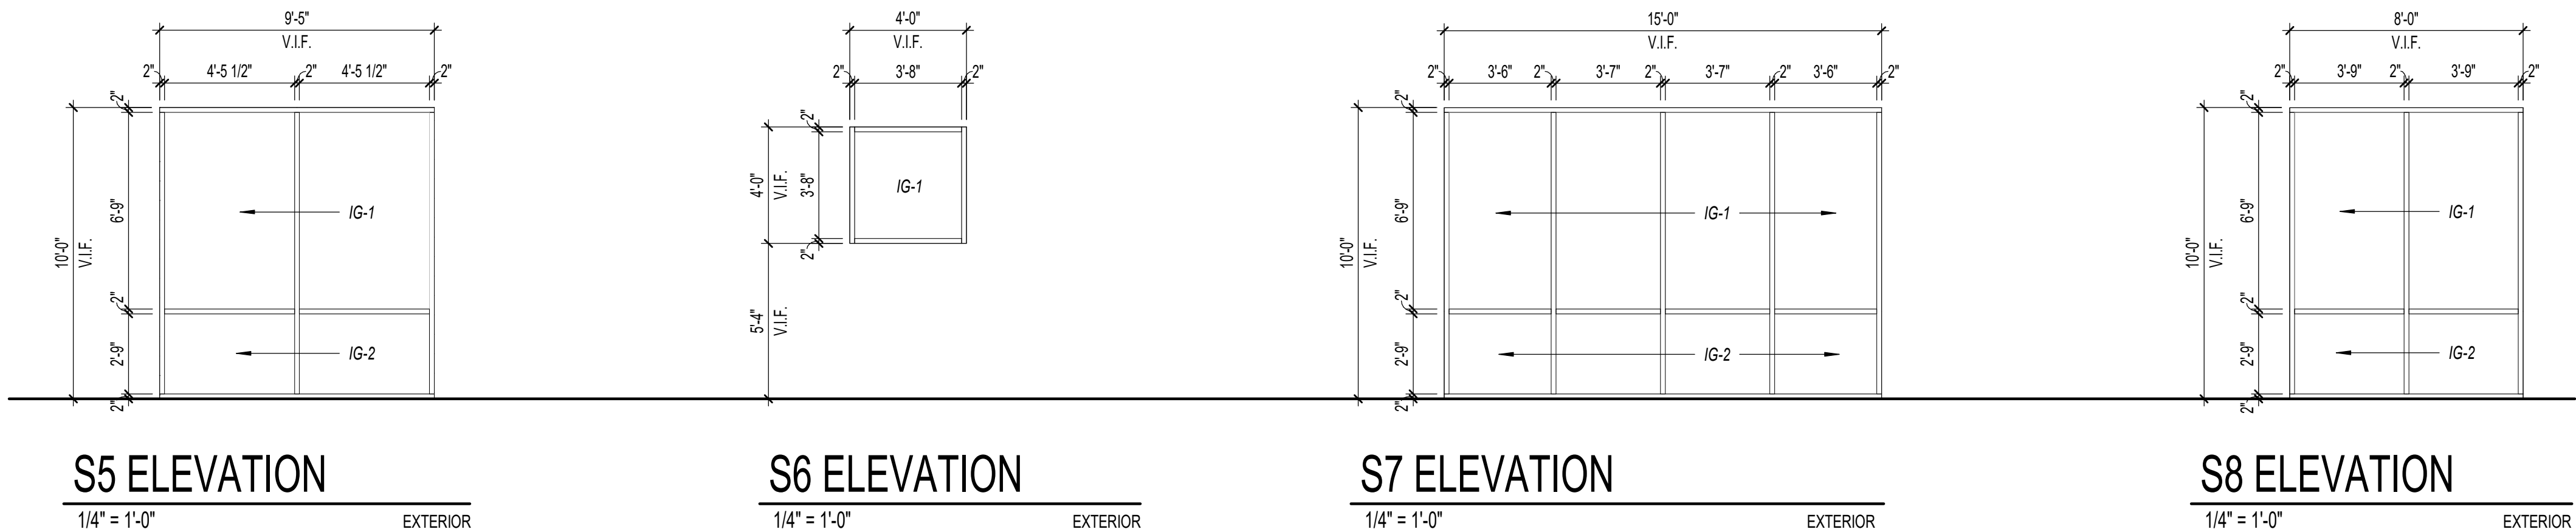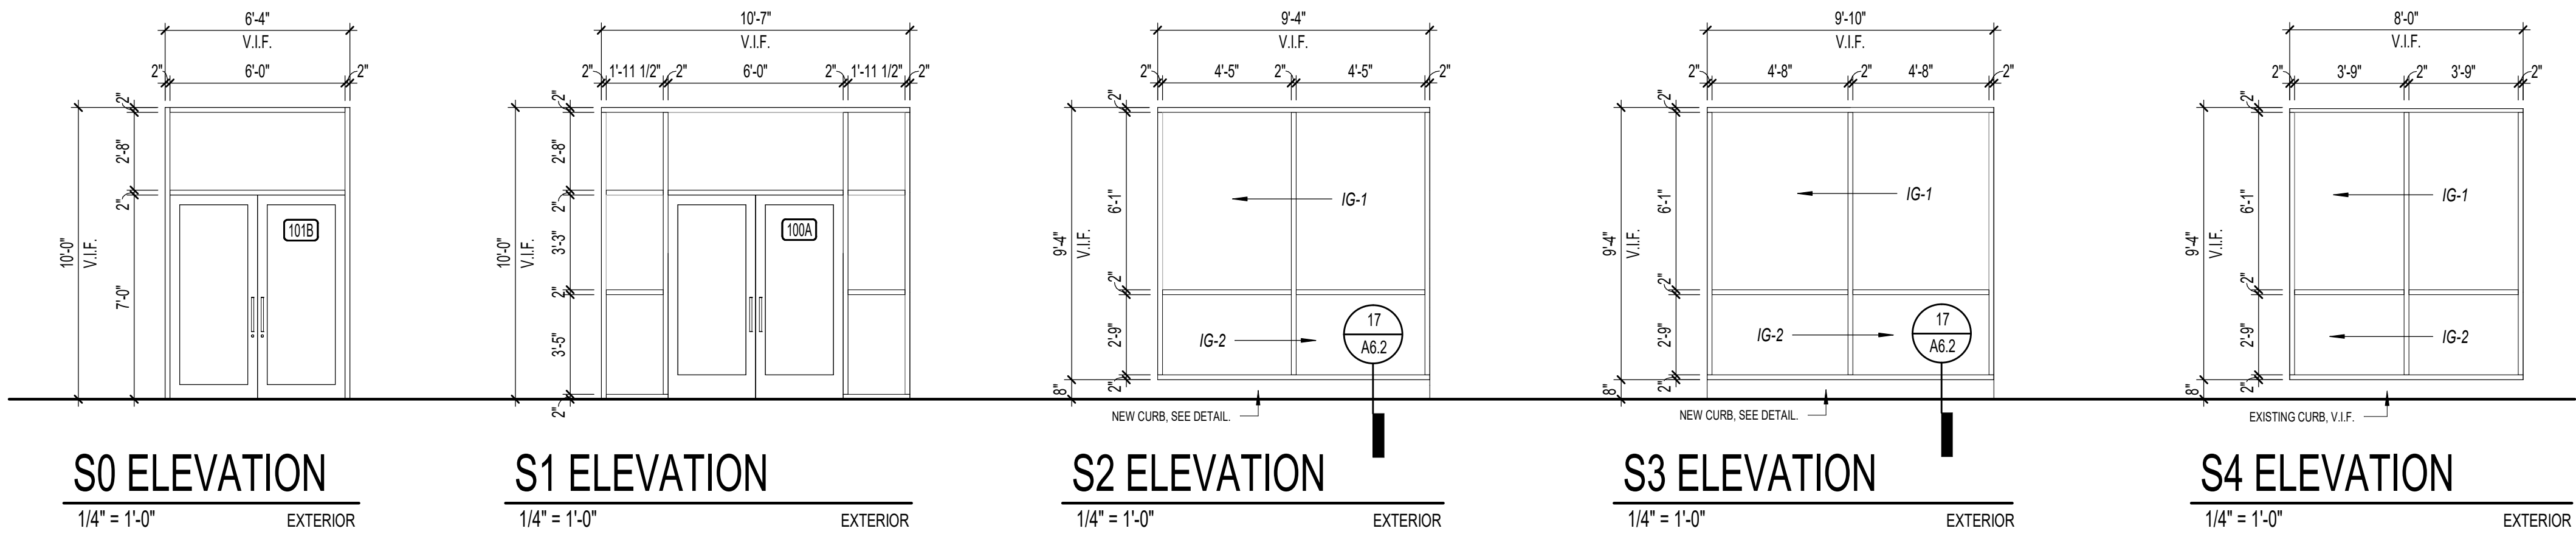


11
A6.2 INT. STOREFRONT HEAD
1 1/2" = 1'-0"

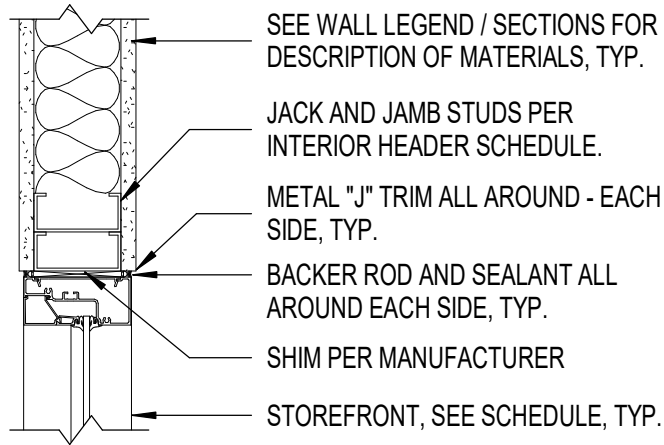

15
A6.2 INT. STOREFRONT JAMB
1 1/2" = 1'-0"

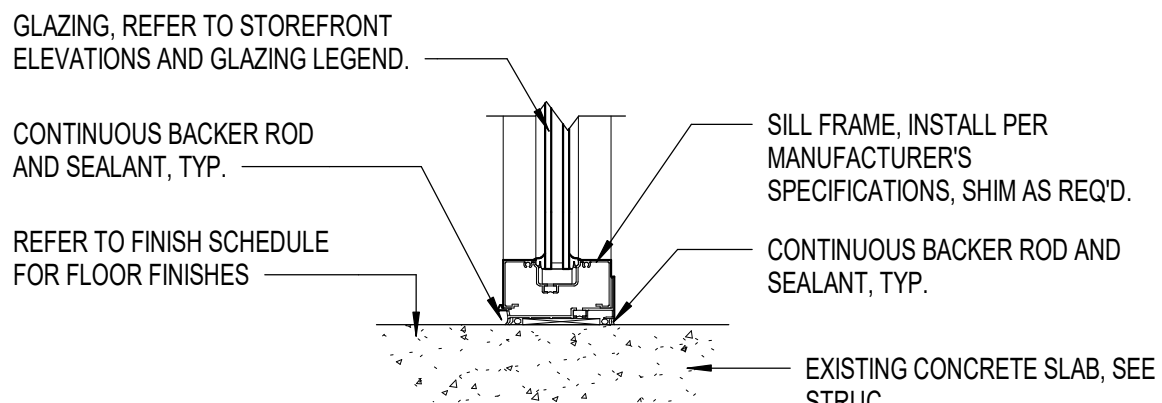

16
A6.2 INT. STOREFRONT SILL
1 1/2" = 1'-0"

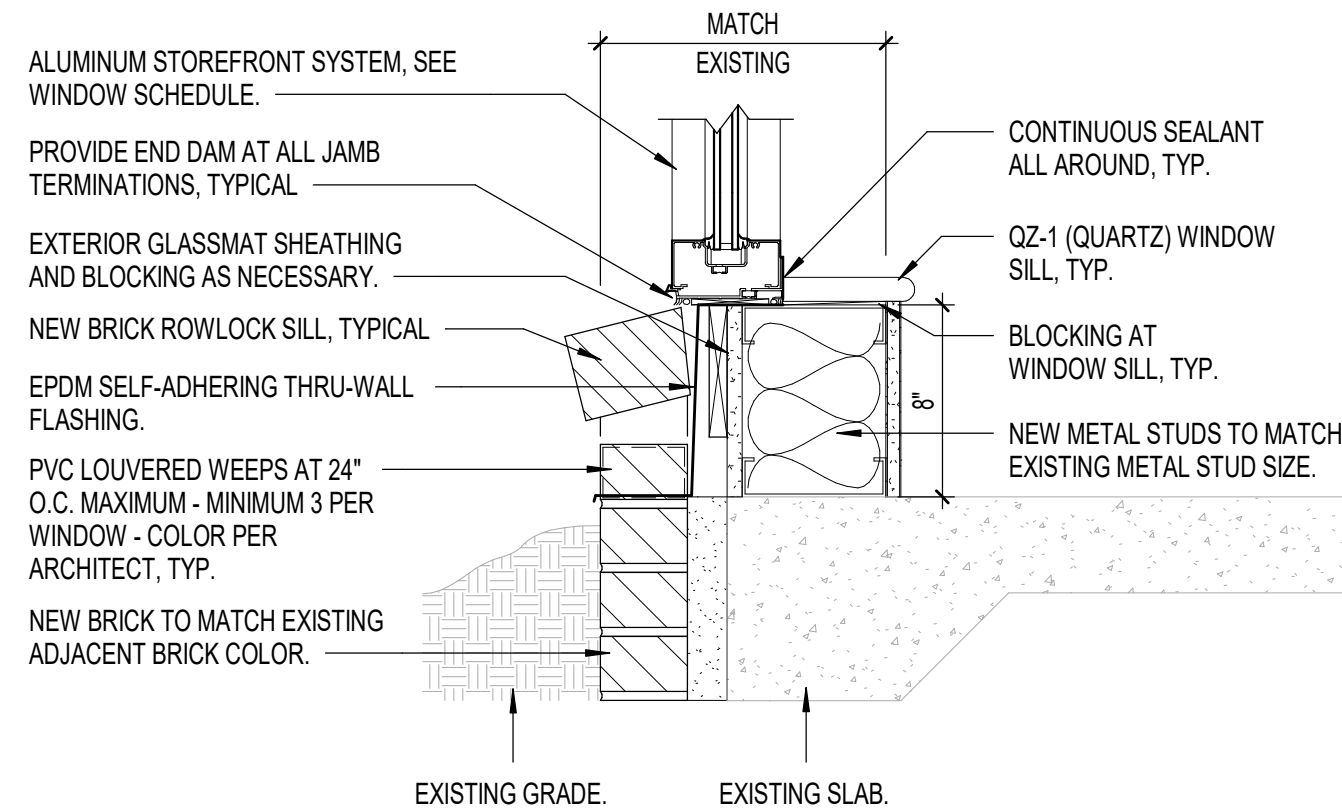

17
A6.2 EXT. STOREFRONT SILL
1 1/2" = 1'-0"

STOREFRONT NOTES


1. VERIFY ALL EXISTING ROUGH OPENINGS IN FIELD BEFORE PROCURING STOREFRONT.
2. ALL EXTERIOR STOREFRONT GLAZING SHALL BE OUTSIDE GLAZED 1" INSULATING TINTED GLASS AS NOTED IN SCHEDULE, TYPICAL.
3. PROVIDE ALL NECESSARY FRAME ANCHORS AS REQUIRED FOR SPECIFIC INSTALLATIONS.
4. ALL GLAZING WITHIN 24" OF VERTICAL EDGE OF DOORS SHALL BE TEMPERED. TEMPERED GLAZING SHALL BE USED AS NOTED AND AS REQUIRED BY CODE.
5. ALL FRAMING SYSTEMS SHALL BE DESIGNED, ENGINEERED AND FABRICATED BY THE SYSTEM MANUFACTURER TO MEET ALL APPLICABLE CODES. SHOP DRAWINGS SHALL BE SUBMITTED FOR REVIEW PRIOR TO FABRICATION.
6. ALL FRAMING DIMENSIONS AS SHOWN ARE ROUGH OPENING DIMENSIONS. CONTRACTOR SHALL VERIFY AND BE RESPONSIBLE FOR EXACT FINISH DIMENSION AT JOB SITE PRIOR TO FABRICATION.
7. HORIZONTAL LOUVER BLINDS SHALL BE FURNISHED AND INSTALLED ON ALL EXTERIOR WINDOWS.

GLAZING

LEGEND		DESIGNATIONS	
IG	INSULATED GLASS	IG - 1	TINTED
		IG - 2	TINTED TEMPERED
SG	SAFETY GLASS	SG - C	CLEAR
		SG - CT	CLEAR, TEMPERED
RSG	RATED SAFETY GLASS	RSG-C	RATED SAFETY GLASS, CLEAR
		RSG-CT	RATED SAFETY GLASS, CLEAR, TEMPERED

RENOVATION FOR:

**CRAVEN COUNTY GOVERNMENT CENTER
EAST**
CRAVEN COUNTY
1208 E. MAIN STREET, HAVELOCK, NORTH CAROLINA 28532

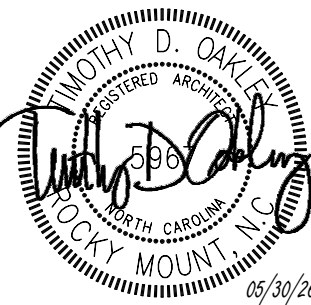

GENERAL NOTE:
Prior to construction start. Contractor shall verify & be responsible for all Dimensions.

Revisions
Description Date

Date
MAY 30 2026

Project No.
25012

Drawn By
ACR

Sheet No.
A6.2

Checked By
DG

Sheet Title
STOREFRONT
ELEVATIONS

VIEW KEY:

NAME → LEVEL NAME
10'-0" → HEIGHT ABOVE PROJECT 0'-0"

KEYNOTE: INDICATES NOTE USED TO DESCRIBE ADDITIONAL INFORMATION ABOUT WORK REQUIRED, SPECIFIC TO THE SHEET AND/OR DETAIL

INDICATES DIRECTION OF TRUE NORTH
PLAN OR DETAIL NUMBER
PLAN OR DETAIL NAME
1/8" = 1'-0" → PLAN OR DETAIL SCALE

VIEW NAME

SIM → INDICATES SIMILAR DETAIL REFERENCED IN MULTIPLE LOCATIONS
1 → DETAIL REFERRED TO BY SECTION CUT
M101 → SHEET DETAIL IS LOCATED ON → T101

LINE TYPE AND TAG KEY:

NEW WORK BY THIS CONTRACTOR (WIDE LINE)
 _____ NEW
 - - - - - EXISTING TO BE REMOVED (SHORT DASHED PATTERN)
 - - - - - NEW UNDERFLOOR OR UNDERGROUND (LONG DASHED PATTERN)

EXISTING TO REMAIN OR WORK BY OTHERS (NARROW LINE)
 _____ EXISTING
 - - - - - EXISTING TO BE REMOVED BY OTHERS (SHORT DASHED PATTERN)
 - - - - - EXISTING UNDERFLOOR OR UNDERGROUND (LONG DASHED PATTERN)

HALFTONING DOES NOT MODIFY SCOPE.

TAG-E TAGS WITH DASH 'E' INDICATES THE REFERENCED OBJECT IS EXISTING

TAG-1 UNDERLINED TAG INDICATES OBJECT IS IN-SCOPE. IF NEW, ADDITIONAL INFORMATION IS AVAILABLE IN A SCHEDULE, MATERIAL LIST, OR SYMBOL LIST

⊕ → INDICATES AN EXISTING SYSTEM'S POINT OF CONNECTION/REMOVAL

SYMBOL LIST - PIPE ACCESSORIES	
SYMBOL	DESCRIPTION
	PIPE DOWN AND PIPE UP / UP AND DOWN
	REDUCER
	SHOCK ABSORBER
	SHUTOFF VALVE

SYMBOL LIST - PLUMBING SYSTEMS	
SYMBOL	DESCRIPTION
CW	COLD WATER - POTABLE
HW	HOT WATER - POTABLE
SAN	SANITARY DRAINAGE

MECHANICAL RENOVATION NOTES:

THESE NOTES APPLY TO ALL MECHANICAL SHEETS AND TRADES, INCLUDING BUT NOT LIMITED TO, FIRE PROTECTION, PLUMBING, MEDICAL GAS, VENTILATION, PIPING AND TEMPERATURE CONTROL.

1. EXISTING CONDITIONS ARE SHOWN BASED ON INFORMATION OBTAINED FROM FIELD SURVEYS, EXISTING BUILDING DOCUMENTS, AND STAFF. VERIFY EXISTING CONDITIONS AND REPORT ANY CONFLICTS BEFORE PROCEEDING.
2. NOT ALL EXISTING DUCTWORK AND PIPING IS SHOWN. VERIFY EXISTING CONDITIONS BEFORE ATTEMPTING TO REMOVE OR RELOCATED TO ALLOW ACCESS TO THEIR AREA OF WORK.
3. FIELD VERIFY THE AVAILABLE CLEARANCES FOR DUCTWORK AND PIPING BEFORE FABRICATION, RISES AND DROPS MAY BE NECESSARY BECAUSE OF EXISTING FIELD CONDITIONS.
4. EACH CONTRACTOR SHALL FIELD VERIFY ACCESSIBILITY TO THE AREA OF THEIR WORK AND SHALL NOTIFY THE **GENERAL CONTRACTOR** PRIOR TO BIDDING IF OTHER UTILITIES ARE ENCOUNTERED.
5. THE GENERAL CONTRACTOR IS RESPONSIBLE FOR CUTTING, REMOVAL AND PATCHING OF ROOFS, WALLS, AND FLOORS ASSOCIATED WITH WORK BY ALL CONTRACTORS. CONTRACTORS SHALL NOTIFY THE GC OF AFFECTED AREAS PRIOR TO BIDDING/EACH CONTRACTOR SHALL CUT AND PATCH ROOFS, WALLS, AND FLOORS ASSOCIATED WITH THEIR WORK.
6. HAVE EXISTING MECHANICAL SYSTEMS DIFFER FROM THOSE SHOWN ON THE PROJECT DRAWINGS AND CREATE CONFLICTS WITH NEW EQUIPMENT, PIPING, OR DUCTWORK INSTALLATIONS, THE CONTRACTOR SHALL PROVIDE DETAILED DOCUMENTATION (SUCH AS SKETCHES, PHOTOS, AND DIMENSIONS) ALONG WITH RECOMMENDATIONS TO RESOLVE THE CONFLICT. THIS INFORMATION MUST BE SUBMITTED TO THE ENGINEER FOR REVIEW AND APPROVAL. NO WORK RELATED TO THE CONFLICT SHALL PROCEED UNTIL AN APPROVED RESOLUTION IS PROVIDED BY THE ENGINEER.
7. PROVIDE TEMPORARY CONNECTIONS TO MAINTAIN EXISTING SYSTEMS IN SERVICE DURING CONSTRUCTION. MAINTAIN ACCESS TO EXISTING MECHANICAL INSTALLATIONS THAT REMAIN ACTIVE.
8. OBTAIN PERMISSION FROM OWNER BEFORE SHUTTING DOWN ANY SYSTEM FOR AN OTHER REASON. MAINTAIN SERVICE TO ALL COMPONENTS THAT ARE TO REMAIN UNTIL NEW SYSTEMS ARE INSTALLED.
9. MAINTAIN EXISTING SYSTEM IN SERVICE UNTIL NEW SYSTEM IS COMPLETE AND READY FOR TIE IN AND SWITCHOVER. DRAIN SYSTEM ONLY TO MAKE SWITCHOVERS AND CONNECTIONS. OBTAIN PERMISSION FROM OWNER BEFORE PARTIALLY OR COMPLETELY DRAINING SYSTEM. MAKE CHANGEOVER TO NEW SYSTEMS WITH MINIMUM OUTAGE. DISCONNECT AND REMOVE MECHANICAL DEVICES AND EQUIPMENT SERVING EQUIPMENT THAT HAVE BEEN REMOVED.
10. PROPERLY RECLAIM AND DISPOSE OF ALL REFRIGERANT IN REMOVED EQUIPMENT/ REFRIGERANT PIPING. RECLAIMED REFRIGERANT SHALL HAVE DOCUMENTATION AS REQUIRED BY THE AUTHORITY HAVING JURISDICTION (AHJ).

PLUMBING GENERAL NOTES:

1. THE SYMBOLS AND THE MATERIAL LIST ARE FOR THE CONVENIENCE OF THE CONTRACTOR. CONTRACTOR SHALL VERIFY QUANTITIES AND FURNISH ALL MATERIALS REQUIRED FOR FULLY OPERATIONAL SYSTEMS, WHETHER SPECIFIED OR NOT.
2. CATALOG NUMBERS SHALL NOT BE CONSIDERED COMPLETE, BUT ARE GIVEN AS AN AID TO THE CONTRACTOR AND TO INDICATE THE QUALITY REQUIRED. CONTRACTOR IS RESPONSIBLE FOR A COMPLETE DESCRIPTION OF MATERIAL ON THESE DRAWINGS AND IN THE SPECIFICATIONS BEFORE ORDERING. THE DESCRIPTION OF THE MATERIAL TAKES PRECEDENCE OVER THE CATALOG NUMBER. THE FIRST MANUFACTURER LISTED IS THE BASIS OF DESIGN.
3. CONTRACTOR SHALL VERIFY THAT FIXTURES SUPPLIED ARE APPROVED PER ALL APPLICABLE STATE, LOCAL AND GOVERNING AUTHORITIES.
4. ALL FIXTURES SHALL CONFORM TO FEDERAL AC S.3874
5. INVERT ELEVATIONS ARE FROM EXISTING DRAWINGS AND MAY NOT BE ACCURATE. VERIFY ALL ELEVATIONS BEFORE BEGINNING WORK.
6. VERIFY UNDERGROUND PIPE SIZES, INVERT ELEVATIONS, AND LOCATIONS PRIOR TO BEGINNING ANY WORK.
7. REFER TO THE PLUMBING ROUGH-IN SCHEDULE FOR THE SIZES OF BRANCH PIPES TO PLUMBING FIXTURES.
8. EXISTING CONDITIONS ON DEMOLITION PLANS ARE PROVIDED TO INDICATE THE GENERAL SCOPE OF ITEMS TO BE REMOVED. REFER TO SPECIFICATION SECTION 22 05 05 FOR ADDITIONAL DEMOLITION INFORMATION.
9. REPAIR, PATCH, CUT AND PATCH EXISTING AS REQUIRED FOR NEW OR DEMOLITION WORK UNLESS NOTED OTHERWISE. REFER TO SPECIFICATION SECTION 22 05 05 FOR ADDITIONAL INFORMATION.

MECHANICAL GENERAL NOTES:

THESE NOTES APPLY TO ALL MECHANICAL SHEETS AND TRADES, INCLUDING BUT NOT LIMITED TO, FIRE PROTECTION, PLUMBING, MEDICAL GAS, VENTILATION, PIPING AND TEMPERATURE CONTROL.

1. DRAWINGS SHOWING LOCATIONS OF EQUIPMENT, DUCTWORK, PIPING, ETC. ARE DIAGRAMMATIC AND MAY NOT ALWAYS REFLECT EXACT INSTALLATION CONDITIONS. INSTALLATIONS SHOW THE GENERAL ARRANGEMENT OF DUCTWORK, PIPING, EQUIPMENT, ETC., AND MAY NOT INDICATE THE EXACT LOCATION OF EQUIPMENT OR PIPING FOR COMPLETE DRAWINGS. THE DRAWINGS SHALL BE FOLLOWED AS CLOSELY AS ACTUAL BUILDING CONSTRUCTION AND THE WORK OF OTHERS WILL PERMIT.
2. CATALOG AND MODEL NUMBERS SHALL NOT BE CONSIDERED COMPLETE, BUT ARE GIVEN AS AN AID TO THE CONTRACTOR AND TO INDICATE THE QUALITY REQUIRED. CONTRACTOR SHALL BE RESPONSIBLE FOR OBTAINING THE EQUIPMENT SPECIFIED OR REFERRED TO IN THESE DRAWINGS AND IN THE SPECIFICATIONS BEFORE ORDERING. THE DESCRIPTION OF THE MATERIAL AND SCHEDULED PERFORMANCE TAKES PRECEDENCE OVER THE MODEL NUMBER. THE FIRST MANUFACTURER SCHEDULED IS THE BASIS OF DESIGN.
3. DETERMINATION OF QUANTITIES OF MATERIAL AND EQUIPMENT REQUIRED SHALL BE MADE BY THE CONTRACTOR FROM THE DOCUMENTS, WHERE MATERIAL AND/OR QUANTITY DISCREPANCIES ARISE BETWEEN DRAWINGS, SCHEDULES AND/OR SPECIFICATIONS, THE HIGHER QUALITY GREATER NUMBER SHALL GOVERN.
4. DO NOT SCALE DRAWINGS. VERIFY ALL DIMENSIONS AND CLEARANCES FROM ARCHITECTURAL, STRUCTURAL, SUBMITTALS, AND OTHER APPROPRIATE DRAWINGS OR PHYSICAL DIMENSIONS FROM THE DOCUMENTS, WHERE MATERIAL AND/OR QUANTITY DISCREPANCIES ARISE BETWEEN DRAWINGS, SCHEDULES AND/OR SPECIFICATIONS.
5. COORDINATE ALL WORK WITH ALL OTHER TRADES PRIOR TO INSTALLATION TO PROVIDE CLEARANCES REQUIRED FOR OPERATION, MAINTENANCE, CODE COMPLIANCE, AND TO VERIFY NON-INTERFERENCE WITH OTHER WORK. DO NOT FABRICATE PRIOR TO VERIFICATION OF NECESSARY CLEARANCES FOR ALL TRADES. BRING ANY INTERFERENCES TO THE CONTRACTOR'S ATTENTION TO THE ARCHITECT/ENGINEER BEFORE PROCEEDING WITH FABRICATION OR EQUIPMENT ORDERS.
6. REVIEW SPACE REQUIREMENTS OF EQUIPMENT SPECIFIED OR SUBSTITUTED AND MAKE REASONABLE ACCOMMODATIONS IN LAYOUT AND POSITIONING TO PROVIDE PROPER ACCESS.
7. ALL CHANGES REQUIRED TO ELIMINATE CONFLICTS OR THAT RESULT FROM A FAILURE TO COORDINATE SHALL BE MADE BY THE CONTRACTOR WITHOUT ADDITIONAL COST OR EXPENSE TO OTHERS.
8. EACH CONTRACTOR IS RESPONSIBLE FOR ALL COSTS ASSOCIATED WITH ELECTRICAL CHANGES REQUIRED FOR EQUIPMENT PROPOSED THAT DIFFERS FROM THE BASIS OF DESIGN.
9. REFER TO ARCHITECTURAL REFLECTED CEILING PLAN, ELECTRICAL, TECHNOLOGY AUDIOVISUAL, AND OTHER MECHANICAL PLANS FOR EXACT LOCATIONS OF ALL CEILING MOUNTED DEVICES, OTHER THAN SPRINKLERS.
10. EACH CONTRACTOR IS RESPONSIBLE FOR DAMAGE CAUSED BY THEIR ACTIONS TO WALLS, FLOORS, CEILINGS, AND ROOFS. THE CONTRACTOR WHOSE WORK CAUSES DAMAGE IS RESPONSIBLE FOR PATCHING TO MATCH ORIGINAL CONSTRUCTION, FIRE RATING, AND FINISH.
11. IN AREAS WITH DRYWALL CEILINGS COORDINATE LOCATIONS OF ACCESS PANELS WITH THE GC FOR ACCESS TO VALVES, DUCTWORK ACCESSORIES, DAMPERS, ETC. COORDINATE PANELS, TIES AND FINISH WITH ARCHITECT. NOTIFY THE GC OF THE REQUIRED ACCESS PANELS PRIOR TO BIDDING.
12. SEAL ALL FLOOR, WALL, AND ROOF PENETRATIONS AIRTIGHT WHERE CONDUITS, PIPING, AND DUCTS PENETRATE. **PENETRATIONS THROUGH EXTERIOR WALLS AND ROOF SHALL BE SEALED AIRTIGHT WITH WATERPROOFING MATERIALS RECOMMENDED BY MANUFACTURER FOR OUTDOOR USE.**
13. GAUGE ALL FLOOR, WALL, AND ROOF PENETRATIONS OF FULL HEIGHT NON-FIRE RATED WALL, PARTITION, FLOOR, AND ROOF ASSEMBLIES. THIS IS ESSENTIAL TO PREVENT NOISE TRANSMISSION FROM ONE ROOM TO ANOTHER AND TO PROVIDE THE DESIRED NC LEVELS WITHIN ROOMS.
14. WHERE PIPES AND DUCTS ARE SHOWN TO PENETRATE FLOORS, PROVIDE SLEEVED OPENING WITH TOP EDGE RAISED ABOVE FLOOR SURFACE IN ACCORDANCE WITH ALL RELEVANT SPEC SECTIONS. SEAL SLEEVE PERIMETER TO BE WATER TIGHT.
15. EQUIPMENT SIZES AND SERVICE CLEARANCE REQUIREMENTS VARY AMONG DIFFERENT MANUFACTURERS. CONSULT APPROVED SHOP DRAWINGS FOR EQUIPMENT SIZES AND REQUIRED SERVICE CLEARANCES. COORDINATE WITH LAYOUT OF EQUIPMENT PADS, PIPING, DUCTWORK, ETC.
16. DO NOT BLOCK TIE, PULL OR EQUIPMENT SERVICE CLEARANCES.
17. MAINTAIN A MINIMUM WORKING CLEARANCE OF 3'-6" IN FRONT OF ALL ELECTRICAL EQUIPMENT REQUIRING MAINTENANCE, INSPECTION, AND TESTING INCLUDING BUT NOT LIMITED TO PANELS, DISTRIBUTION PANELS, SWITCHBOARDS, MOTOR CONTROL CENTERS, TRANSFORMERS, AND ELECTRICAL DISTRIBUTION TUBES.
18. MAINTAIN THE DEDICATED ELECTRICAL EQUIPMENT ACCESS DEFINED BY THE WIDTH / DEPTH OF ELECTRICAL EQUIPMENT MEASURED FROM THE FLOOR TO A HEIGHT 6'-0" ABOVE THE EQUIPMENT OR THE STRUCTURAL CEILING, WHICHEVER IS LOWER. SYSTEMS FOREIGN TO THE ELECTRICAL DISTRIBUTION SYSTEM ARE NOT ALLOWED IN THE DEDICATED ELECTRICAL SERVICE INCLUDING DUCTWORK.
19. PROVIDE CONCRETE EQUIPMENT PADS FOR ALL FLOOR-MOUNTED EQUIPMENT. PADS SHALL EXTEND A MINIMUM OF 6 INCHES BEYOND ALL SIDES OF EQUIPMENT, UNLESS SUCH EXTENSION WOULD ENCROACH ON REQUIRED WORKING CLEARANCES AT CONTROL PANELS OR ELECTRICAL EQUIPMENT. PROVIDE 1/2-INCH CHAMFER (45-DEGREE) OR 1/2-INCH RADIUS ON ALL HORIZONTAL EDGES.
20. DO NOT EXCEED 1/2-INCH SPACING AND A MINIMUM SPACING OF 2'-0" ON CENTER WHEN ATTACHING TO METAL ROOF DECKING (LIMITATION NOT REQUIRED WITH CONCRETE ON METAL DECK). THIS 25 LBS. LOAD AND 2'-0" SPACING INCLUDE ADJACENT ELECTRICAL AND ARCHITECTURAL ITEMS HANGING FROM DECK. IF THE HANGER RESTRICTIONS CANNOT BE ACHIEVED, THE SUBMITTAL FRAMING OFF STEEL FRAMINGS SHALL BE ADDED, AND HANGERS EMBEDDED IN CONCRETE SHALL BE CRACKED CONCRETE APPROVED IN ACCORDANCE WITH SPECIFICATIONS.

APPLICABLE CODES	
CONTRACTOR SHALL COMPLY WITH APPLICABLE CODES AND LOCAL AMENDMENTS INCLUDING, BUT NOT LIMITED TO, THE FOLLOWING:	
ELECTRICAL CODE:	NEC 2020
ENERGY CONSERVATION CODE:	NCECC 2018

CONTRACTOR ABBREVIATION KEY	
ABBR:	DESCRIPTION:
A.C.	ASBESTOS ABATEMENT CONTRACTOR
A.V.C.	AUDIO/VISUAL CONTRACTOR
C.C.	CIVIL CONTRACTOR
C.M.	CONSTRUCTION MANAGER
E.C.	ELECTRICAL CONTRACTOR
F.P.C.	FIRE PROTECTION CONTRACTOR
F.S.C.	FOOD SERVICE CONTRACTOR
G.C.	GENERAL CONTRACTOR
H.C.	HEATING CONTRACTOR
M.C.	MECHANICAL CONTRACTOR
N.C.C.	NURSE CALL CONTRACTOR
P.C.	PLUMBING CONTRACTOR
S.C.	SECURITY CONTRACTOR
T.C.	TECHNOLOGY CONTRACTOR
T.C.C.	TEMPERATURE CONTROLS CONTRACTOR
V.C.	VENTILATION CONTRACTOR

PLUMBING ROUGH-IN SCHEDULE

NOTES: (APPLIES TO ALL PLUMBING FIXTURES LISTED BELOW)

1) SIZES SHOWN ARE MINIMUMS. LARGER SIZES SHOWN ON THE DRAWING SHALL DICTATE THE ROUGH-IN SIZE. 2) SANITARY RISERS UP IN WALL TO FIXTURES SHALL BE A MINIMUM OF 2". 3) DOMESTIC WATER BRANCH PIPING OUTSIDE OF THE WALL/CHASE SHALL BE A MINIMUM OF 3/4". 4) UNLESS NOTED OTHERWISE, ONLY THE FINAL RISE-DROP SHALL BE SMALLER. 4) FINAL SANITARY SIZE SHALL MATCH P-TRAP SIZE (REFER TO MATERIAL LIST).

TAG NAME	DESCRIPTION	CW	HW	SAN	VENT
EW-C-1	ELECTRIC WATER COOLER	1/2"	-	1 1/2"	1 1/2"
FD-1	FLOOR DRAIN	-	-	3"	1 1/2"
IM-1	ICE MAKER BOX	1/2"	1/2"	-	-
L-1	LAVATORY	1/2"	1/2"	1 1/2"	1 1/2"
MB-1	MOP BASIN	1/2"	1/2"	2"	1 1/2"
RD-E	FLOOR DRAIN	-	-	3"	2"
SK-1	SINK	1/2"	1/2"	1 1/2"	1 1/2"
WC-1	WATER CLOSET	1"	-	4"	2"

PLUMBING SLOPE REQUIREMENTS:	
BASED ON PLUMBING CODE: [CPC-2019][UPC-2018]	
INTERIOR:	
SANITARY WASTE:	1/4" PER FOOT
GREASE WASTE:	1/4" PER FOOT
STORM (GRAVITY):	1/8" PER FOOT
CONDENSATE AND INDIRECT DRAINAGE:	1/8" PER FOOT
SANITARY AND GREASE VENT:	NO SPECIFIC PITCH, PITCH TO FIXTURES
DOMESTIC WATER:	NO SPECIFIC PITCH, PITCH TO FIXTURES
PLUMBING SLOPE REQUIREMENTS:	
BASED ON PLUMBING CODE: [IPC-2018]	
INTERIOR:	
SANITARY WASTE:	$\leq 2-1/2^{\circ}$ or 1/4" PER FOOT $\geq 3^{\circ}$ or 1/8" PER FOOT $\geq 8^{\circ}$ or 1/16" PER FOOT
GREASE WASTE:	1/4" PER FOOT
STORM (GRAVITY):	1/8" PER FOOT
CONDENSATE AND INDIRECT DRAINAGE:	1/8" PER FOOT
SANITARY AND GREASE VENT:	NO SPECIFIC PITCH, PITCH TO FIXTURES
DOMESTIC WATER:	NO SPECIFIC PITCH, PITCH TO FIXTURES

PLUMBING SHEET INDEX	
P000	PLUMBING COVERSHEET
P101	DEMOLITION PLAN - PLUMBING
P102	ROOF DEMOLITION PLAN - PLUMBING
P201	FLOOR PLAN - PLUMBING
P202	ROOF PLAN - PLUMBING
P300	PLUMBING DETAILS
P400	PLUMBING SCHEDULES
GRAND TOTAL: 7	

**OAKLEY
COLLIER
ARCHITECTS**



OCA

107 Candlewood Road, Rocky Mount, NC 27804 (P) 252.937.2500
205 W. Martin Street, Raleigh, NC 27601

109 Candlewood Road, Rocky Mount, NC 27804 (P) 252.937.2500
205 W. Martin Street, Raleigh, NC 27601

RENOVATION FOR:
CRAVEN COUNTY GOVERNMENT CENTER

CRAVEN COUNTY
1208 E. MAIN STREET, HAVELOCK, NORTH CAROLINA 28532

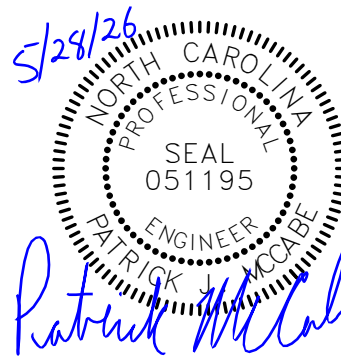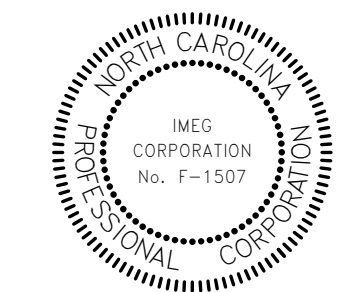


GENERAL NOTE:
Prior to construction start. Contractor shall verify & be responsible for all Dimensions.


Revisions		
	Description	Date

Date 05-28-26	Project No. 26001727.00
Drawn By FEA	Sheet No. P000
Checked By	


Sheet Title
PLUMBING COVERSHEET

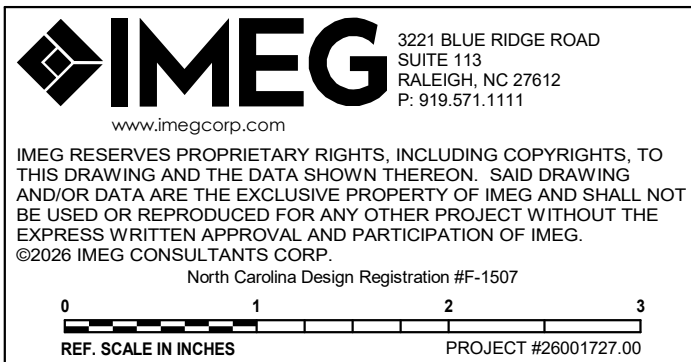

Copyright © 2025 Oakley Collier Architects. These drawings are of the property of the Architect for use under his supervision. No reproduction or other use is allowed without permission.

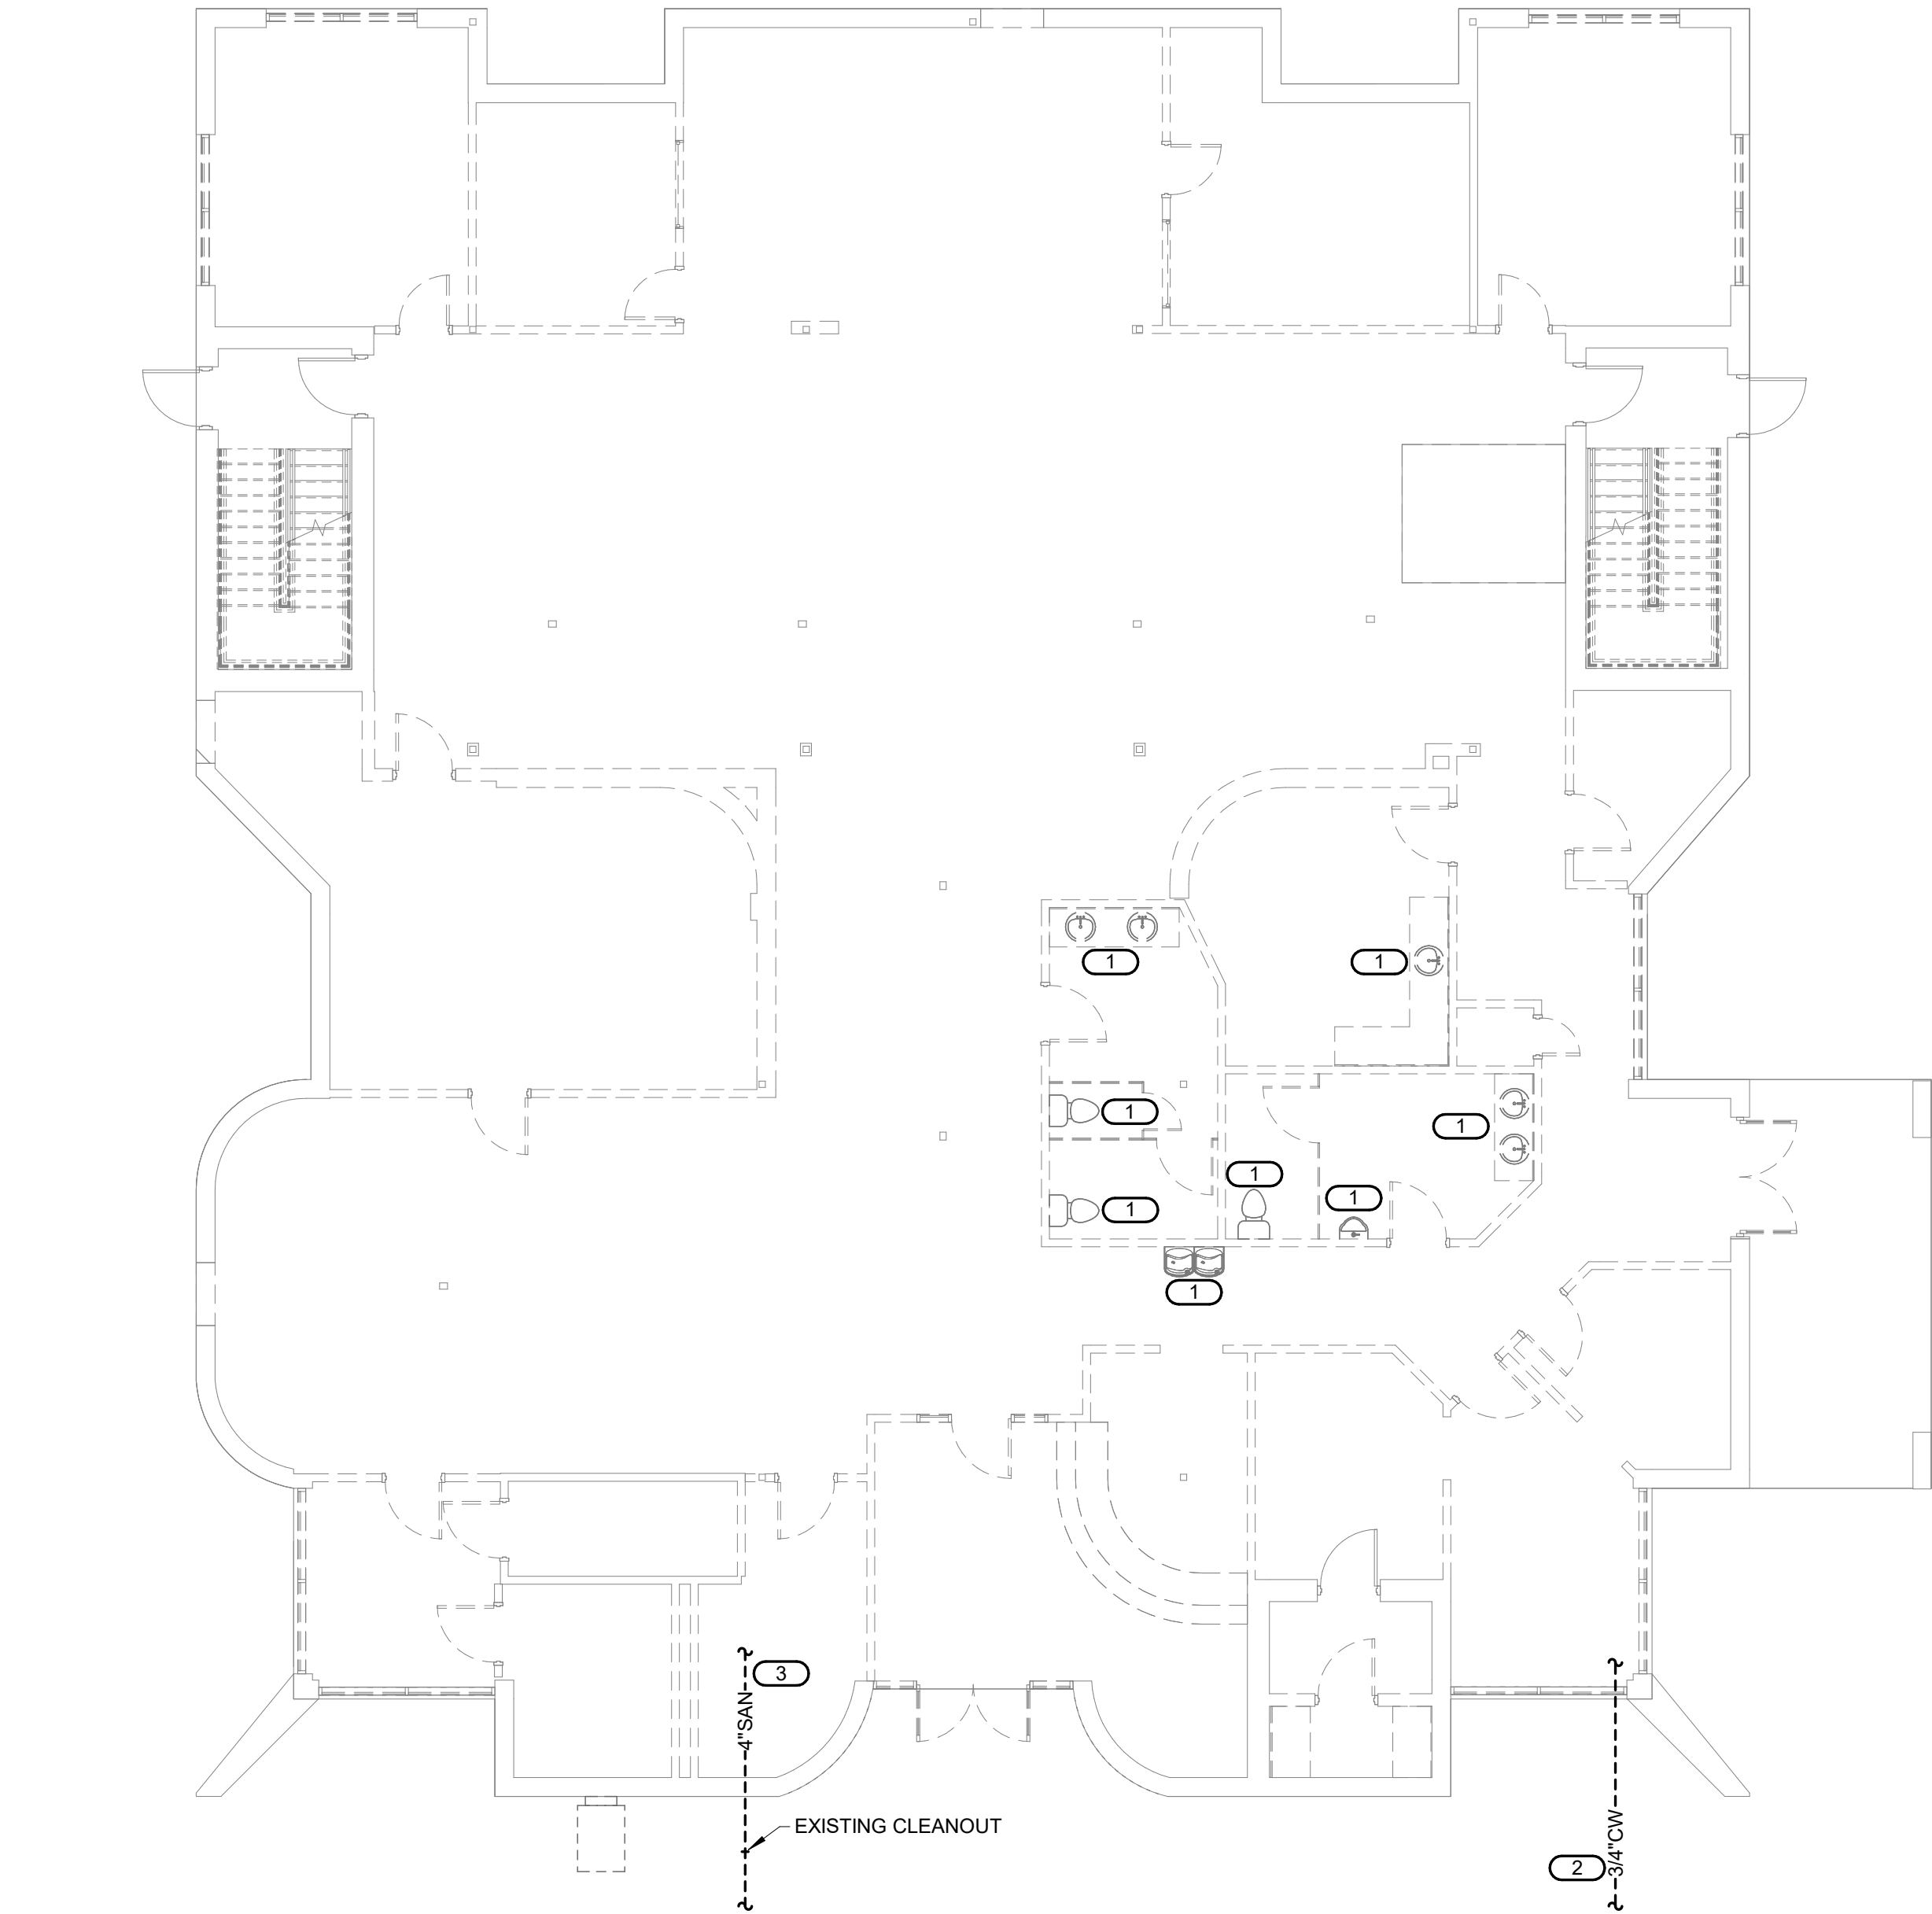

1 FIRST FLOOR DEMOLITION PLAN - PLUMBING
1/8" = 1'-0"

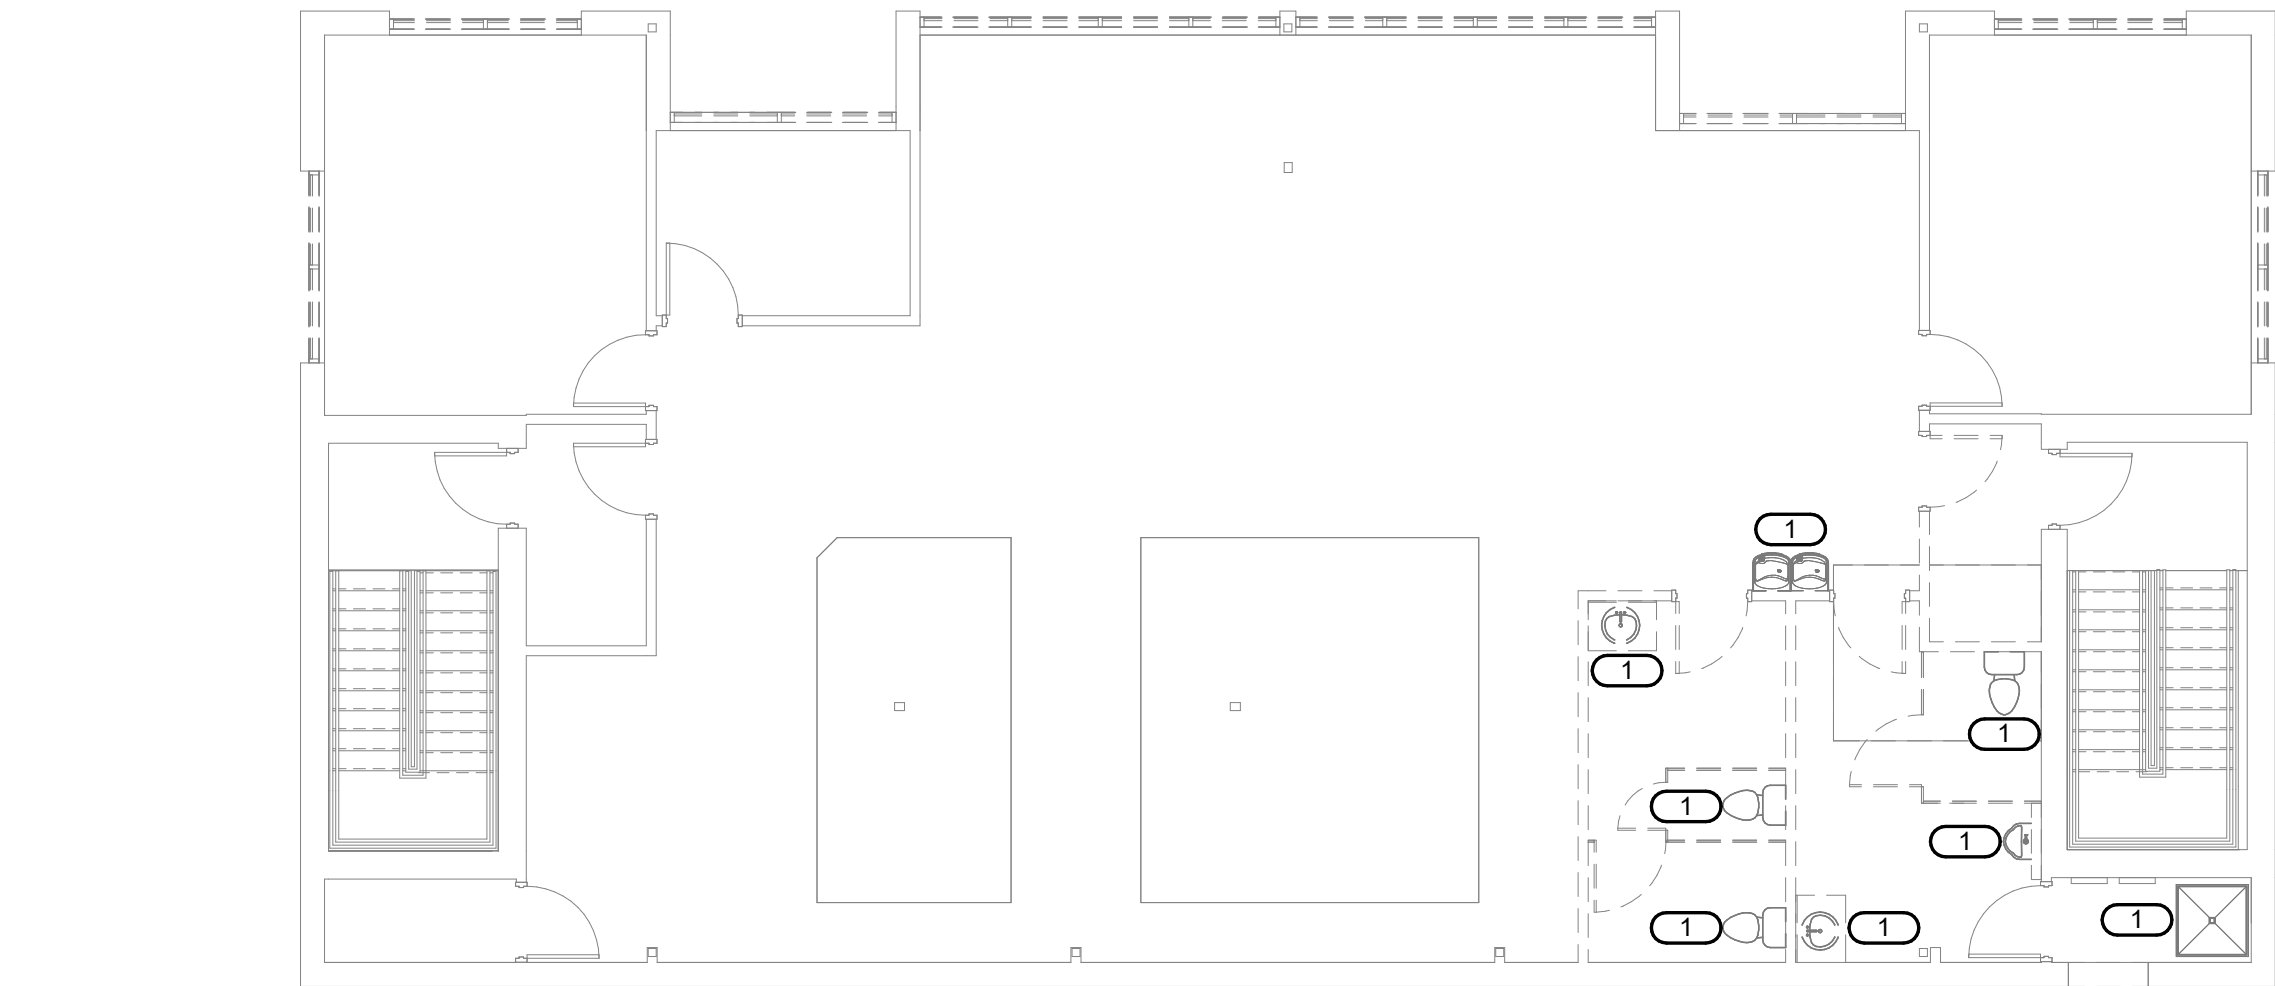

2 SECOND FLOOR DEMOLITION PLAN - PLUMBING
1/8" = 1'-0"

- KEYNOTES:** (#
1. REMOVE PLUMBING FIXTURE, APPURTENANCES, AND RELATED WATER PIPING. CAP WASTE AND VENT PIPING AS REQUIRED.
 2. EXISTING WATER LINE TO BE REPLACED INSIDE AND OUTSIDE BUILDING, INCLUDING WATER HEATER AND APPURTENANCES. SEE SIT PLAN FOR WATER METER REPLACEMENT.
 3. EXISTING 4" SANITARY SEWER LINE TO REMAIN.

IMEG
www.imegcorp.com
3221 BLUE RIDGE ROAD
SUITE 113
RALEIGH, NC 27612
P. 919.971.1111



IMEG RESERVES PROPRIETARY RIGHTS, INCLUDING COPYRIGHTS, TO THIS DRAWING AND THE DATA SHOWN THEREON. SAID DRAWING AND/OR DATA ARE THE EXCLUSIVE PROPERTY OF IMEG AND SHALL NOT BE USED OR REPRODUCED FOR ANY OTHER PROJECT WITHOUT THE EXPRESS WRITTEN APPROVAL AND PARTICIPATION OF IMEG.
©2026 IMEG CONSULTANTS CORP.
North Carolina Design Registration #F-1507

0 1 2 3
REF. SCALE IN INCHES PROJECT #26001727.00

RENOVATION FOR:

**CRAVEN COUNTY GOVERNMENT CENTER
EAST**

CRAVEN COUNTY
1208 E. MAIN STREET, HAVELOCK, NORTH CAROLINA 28532

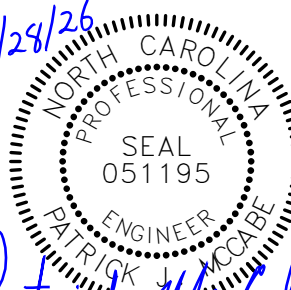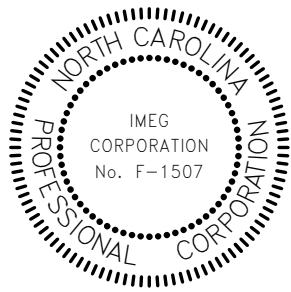

GENERAL NOTE:
Prior to construction start. Contractor shall verify & be responsible for all Dimensions.

Revisions		
#	Description	Date
Date	Project No.	
05-28-26	26001727.00	
Drawn By	Sheet No.	
FEA	P101	
Checked By	Sheet Title	
DRD	DEMOLITION PLAN - PLUMBING	


**OAKLEY
COLLIER
ARCHITECTS**
OCA
109 Candlewood Road, Rocky Mount, NC 27804 (P) 252.937.2500
205 W. Martin Street, Raleigh, NC 27601

Copyright © 2025 Oakley Collier Architects. These drawings are of the property of the Architect for use under his supervision. No reproduction or other use is allowed without permission.

1

ROOF DEMOLITION PLAN - PLUMBING

1/8" = 1'-0"

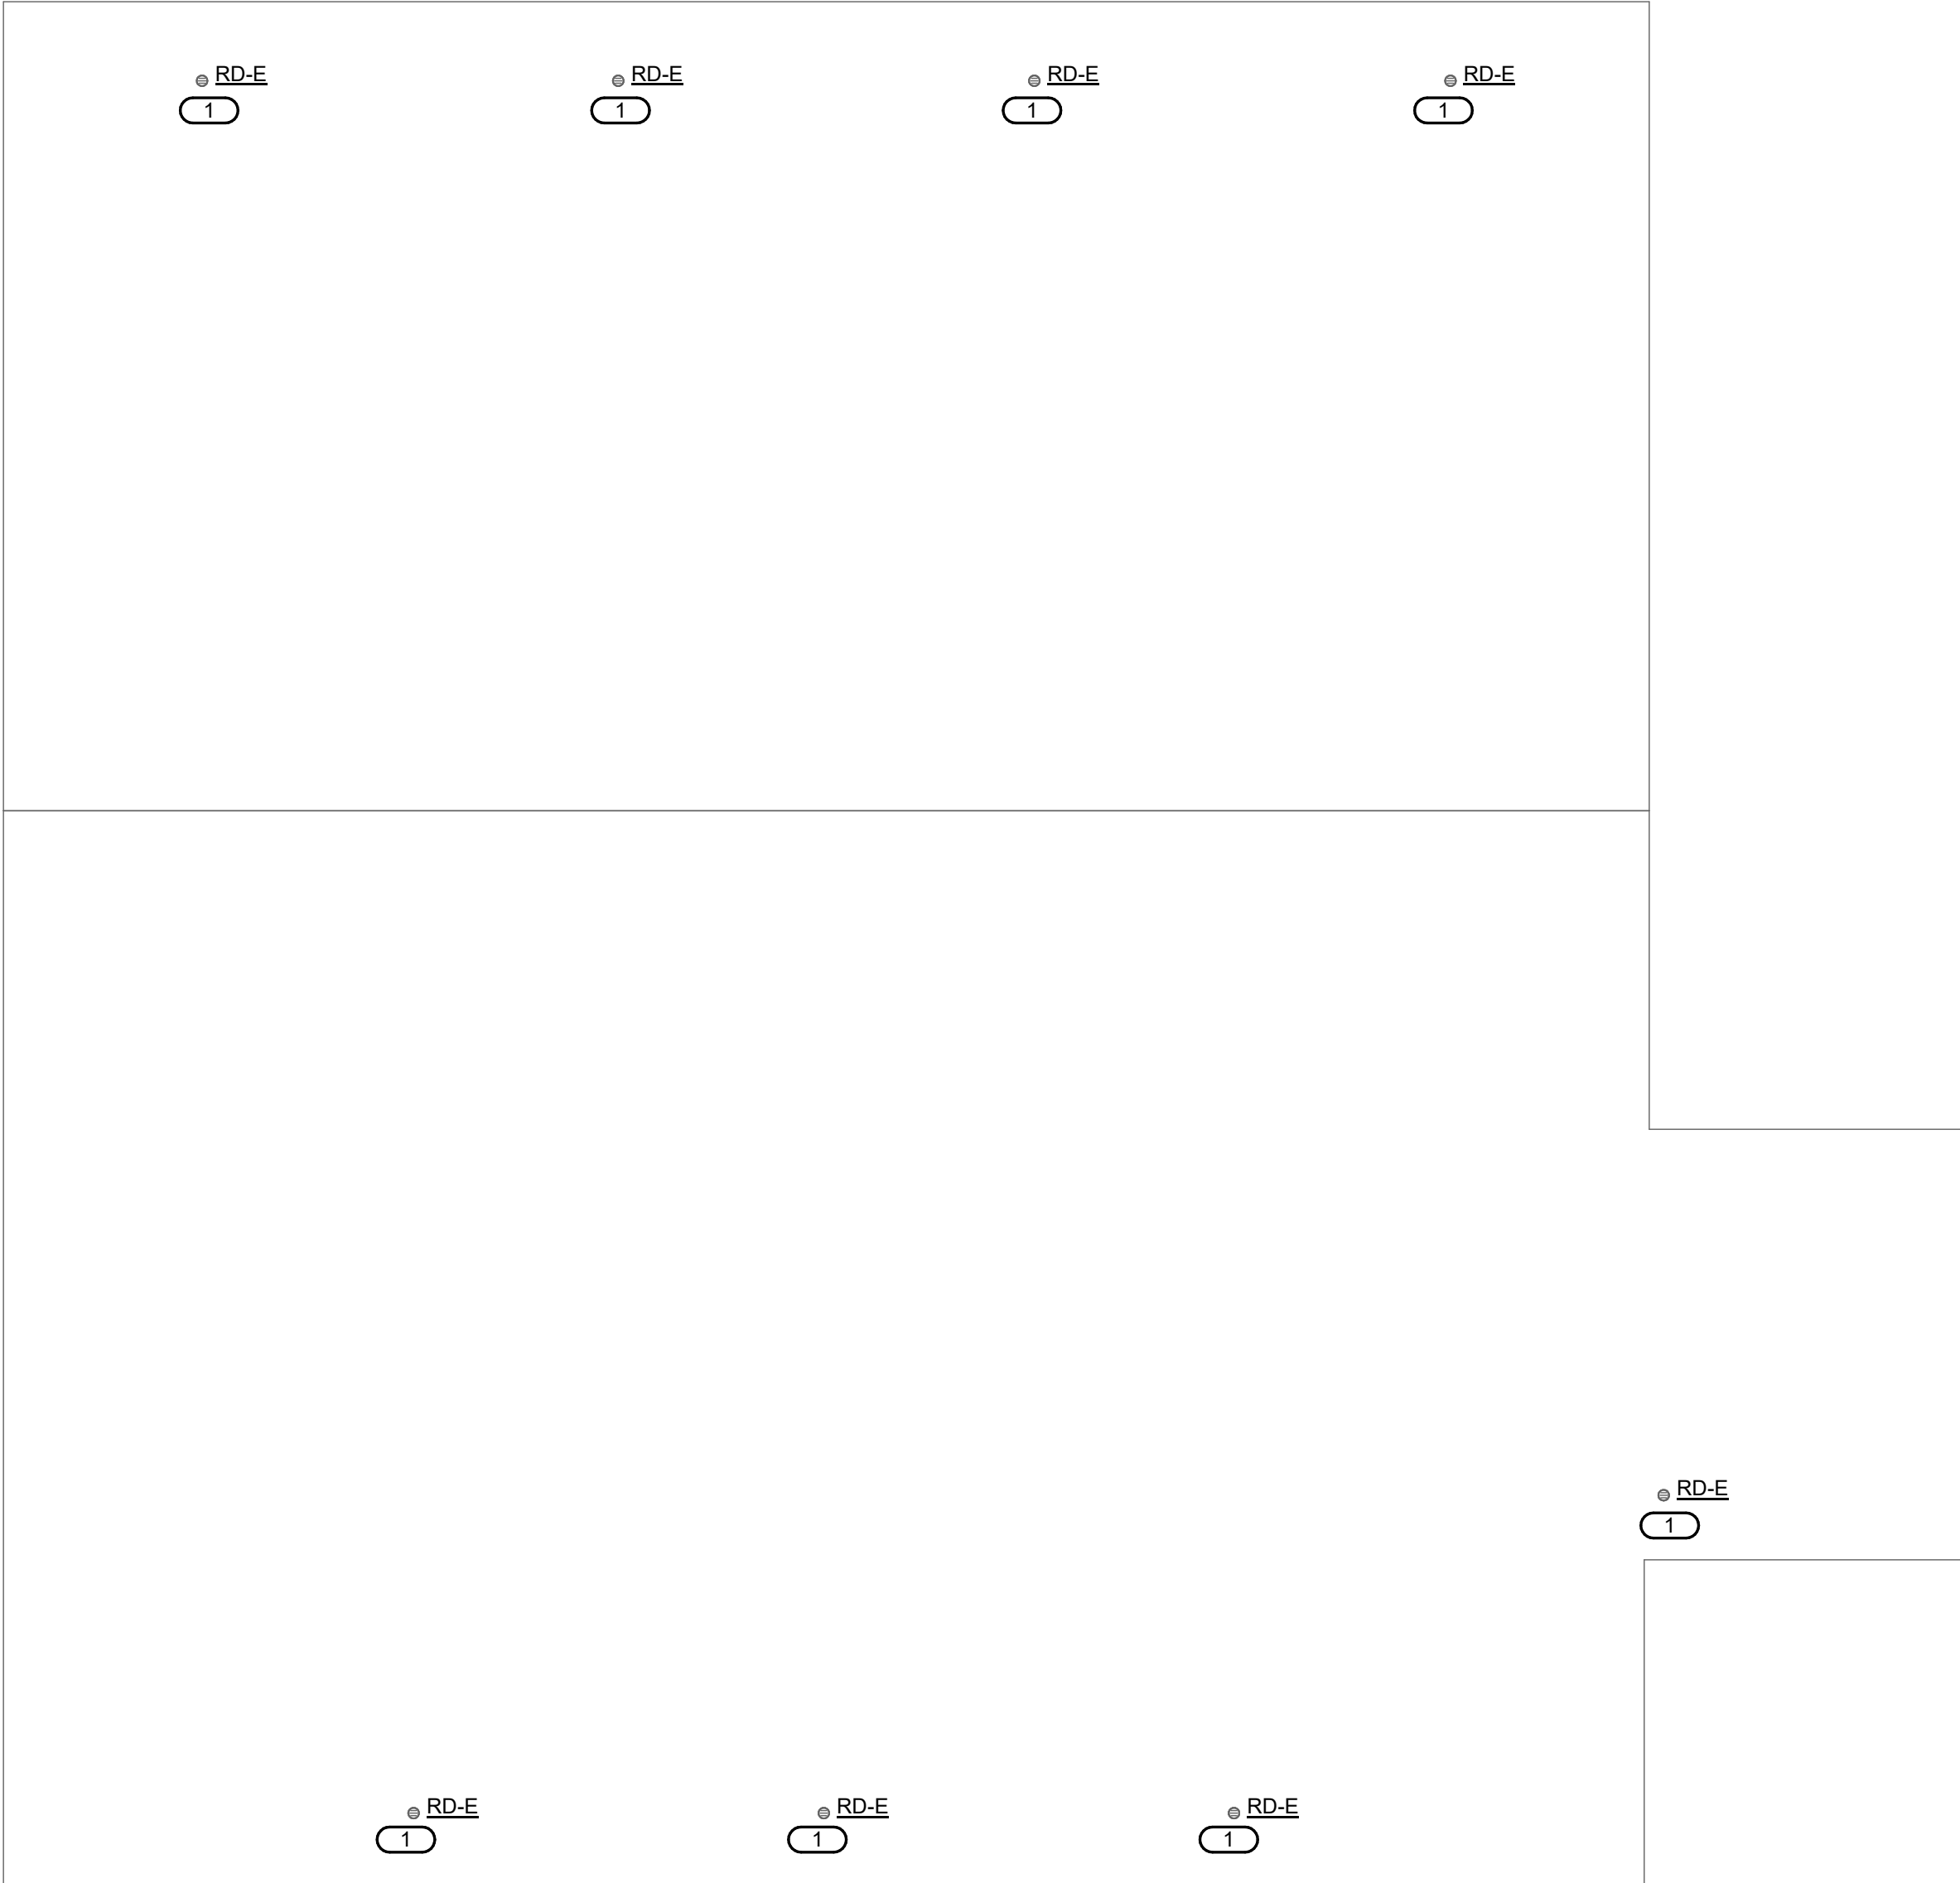

KEYNOTES:

#

1. EXISTING ROOF DRAINS AND ROOF DRAIN LEADER LINES TO REMAIN. PLUMBING CONTRACTOR TO FIELD VERIFY EXACT LOCATIONS.



3221 BLUE RIDGE ROAD
SUITE 113
RALEIGH, NC 27612
P. 919.971.1111

www.imegcorp.com

IMEG RESERVES PROPRIETARY RIGHTS, INCLUDING COPYRIGHTS, TO THIS DRAWING AND THE DATA SHOWN THEREON. SAID DRAWING AND/OR DATA ARE THE EXCLUSIVE PROPERTY OF IMEG AND SHALL NOT BE USED OR REPRODUCED FOR ANY OTHER PROJECT WITHOUT THE EXPRESS WRITTEN APPROVAL AND PARTICIPATION OF IMEG.
©2026 IMEG CONSULTANTS CORP.

North Carolina Design Registration #F-1507

0123



REF. SCALE IN INCHES

PROJECT #26001727.00

RENOVATION FOR:

CRAVEN COUNTY GOVERNMENT CENTER
EAST

CRAVEN COUNTY
1208 E. MAIN STREET, HAVELOCK, NORTH CAROLINA 28532

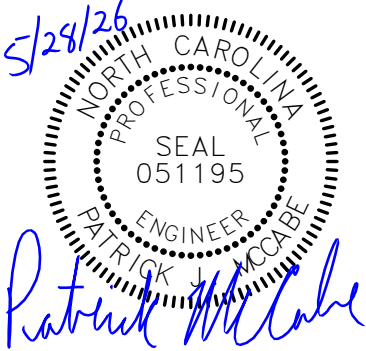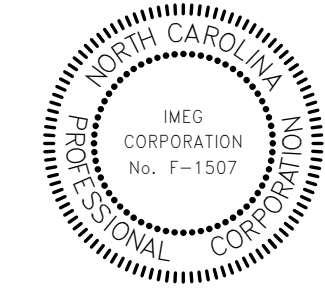

GENERAL NOTE: Prior to construction start, Contractor shall verify & be responsible for all Dimensions.		
Revisions		
#	Description	Date
Date	Project No.	
05-28-26	26001727.00	
Drawn By	Sheet No.	
FEA	P102	
Checked By		
DRD		
Sheet Title		
ROOF DEMOLITION PLAN - PLUMBING		

OCA


OAKLEY COLLIER ARCHITECTS

109 Candlewood Road, Rocky Mount, NC 27804 (P) 252.937.2500
205 W. Martin Street, Raleigh, NC 27601

Copyright © 2025 Oakley Collier Architects. These drawings are of the property of the Architect for use under his supervision. No reproduction or other use is allowed without permission.


1 FIRST FLOOR PLAN - PLUMBING

1/8" = 1'-0"

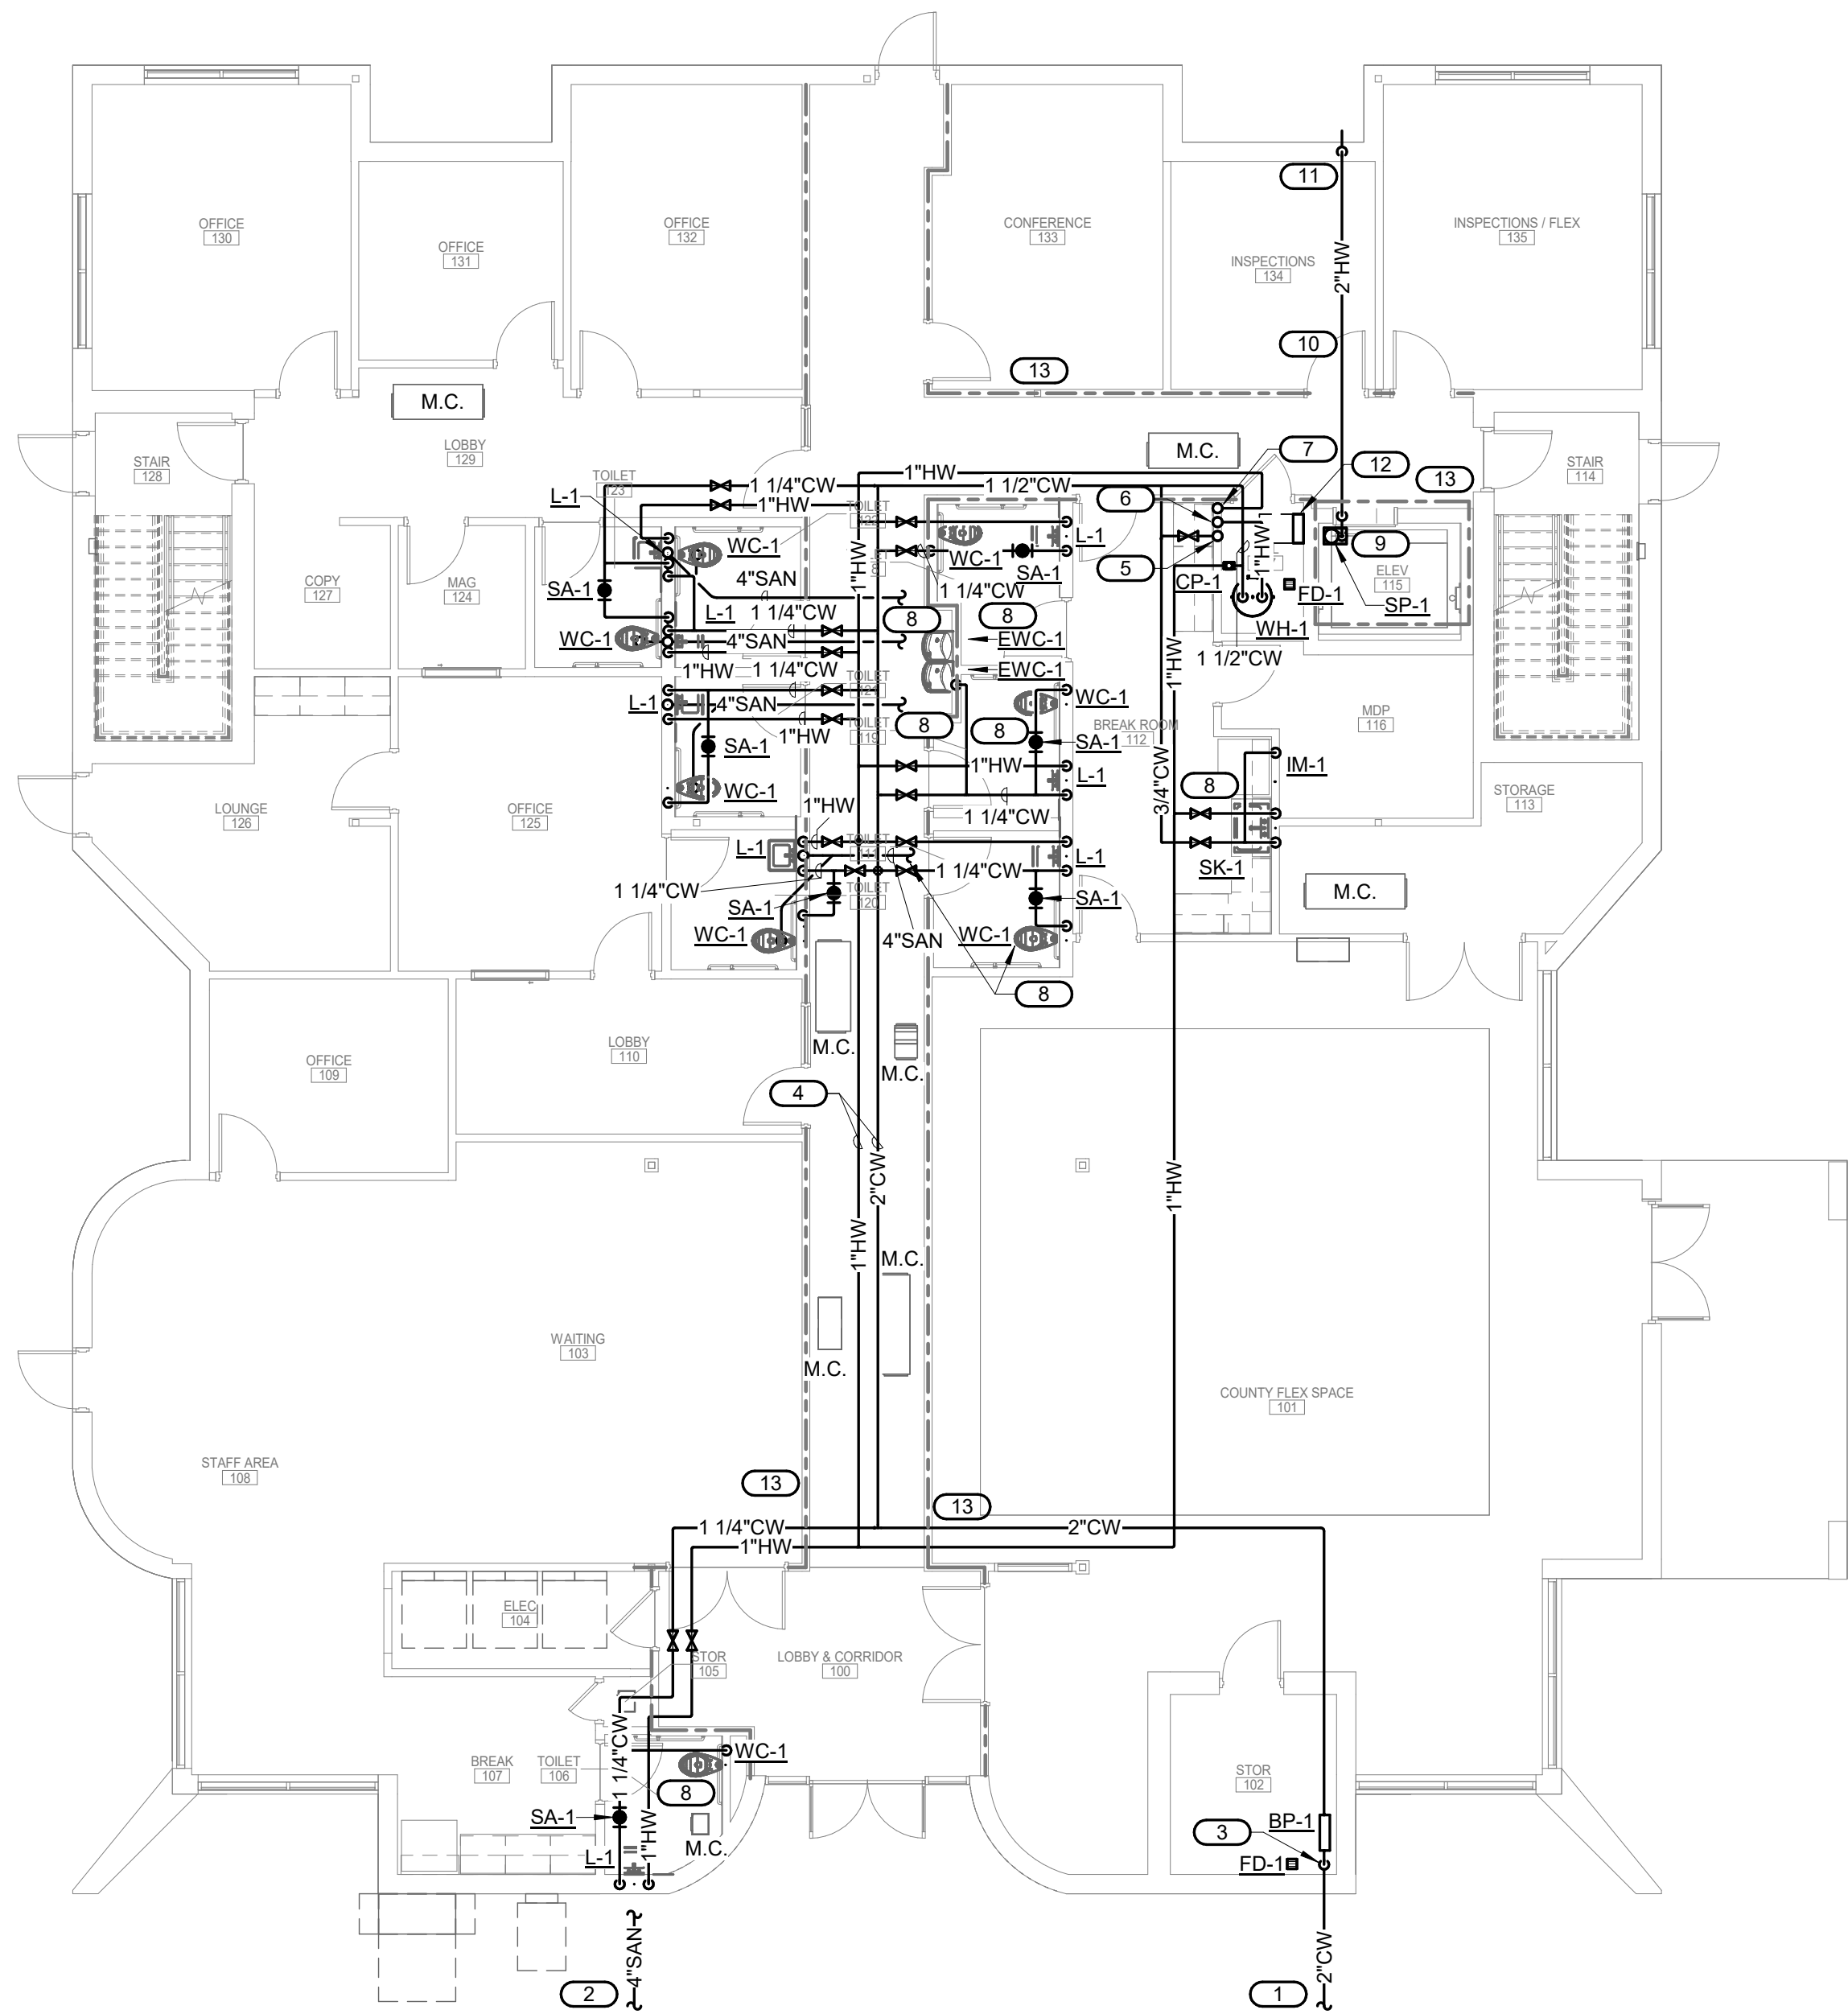

2 SECOND FLOOR PLAN - PLUMBING

1/8" = 1'-0"

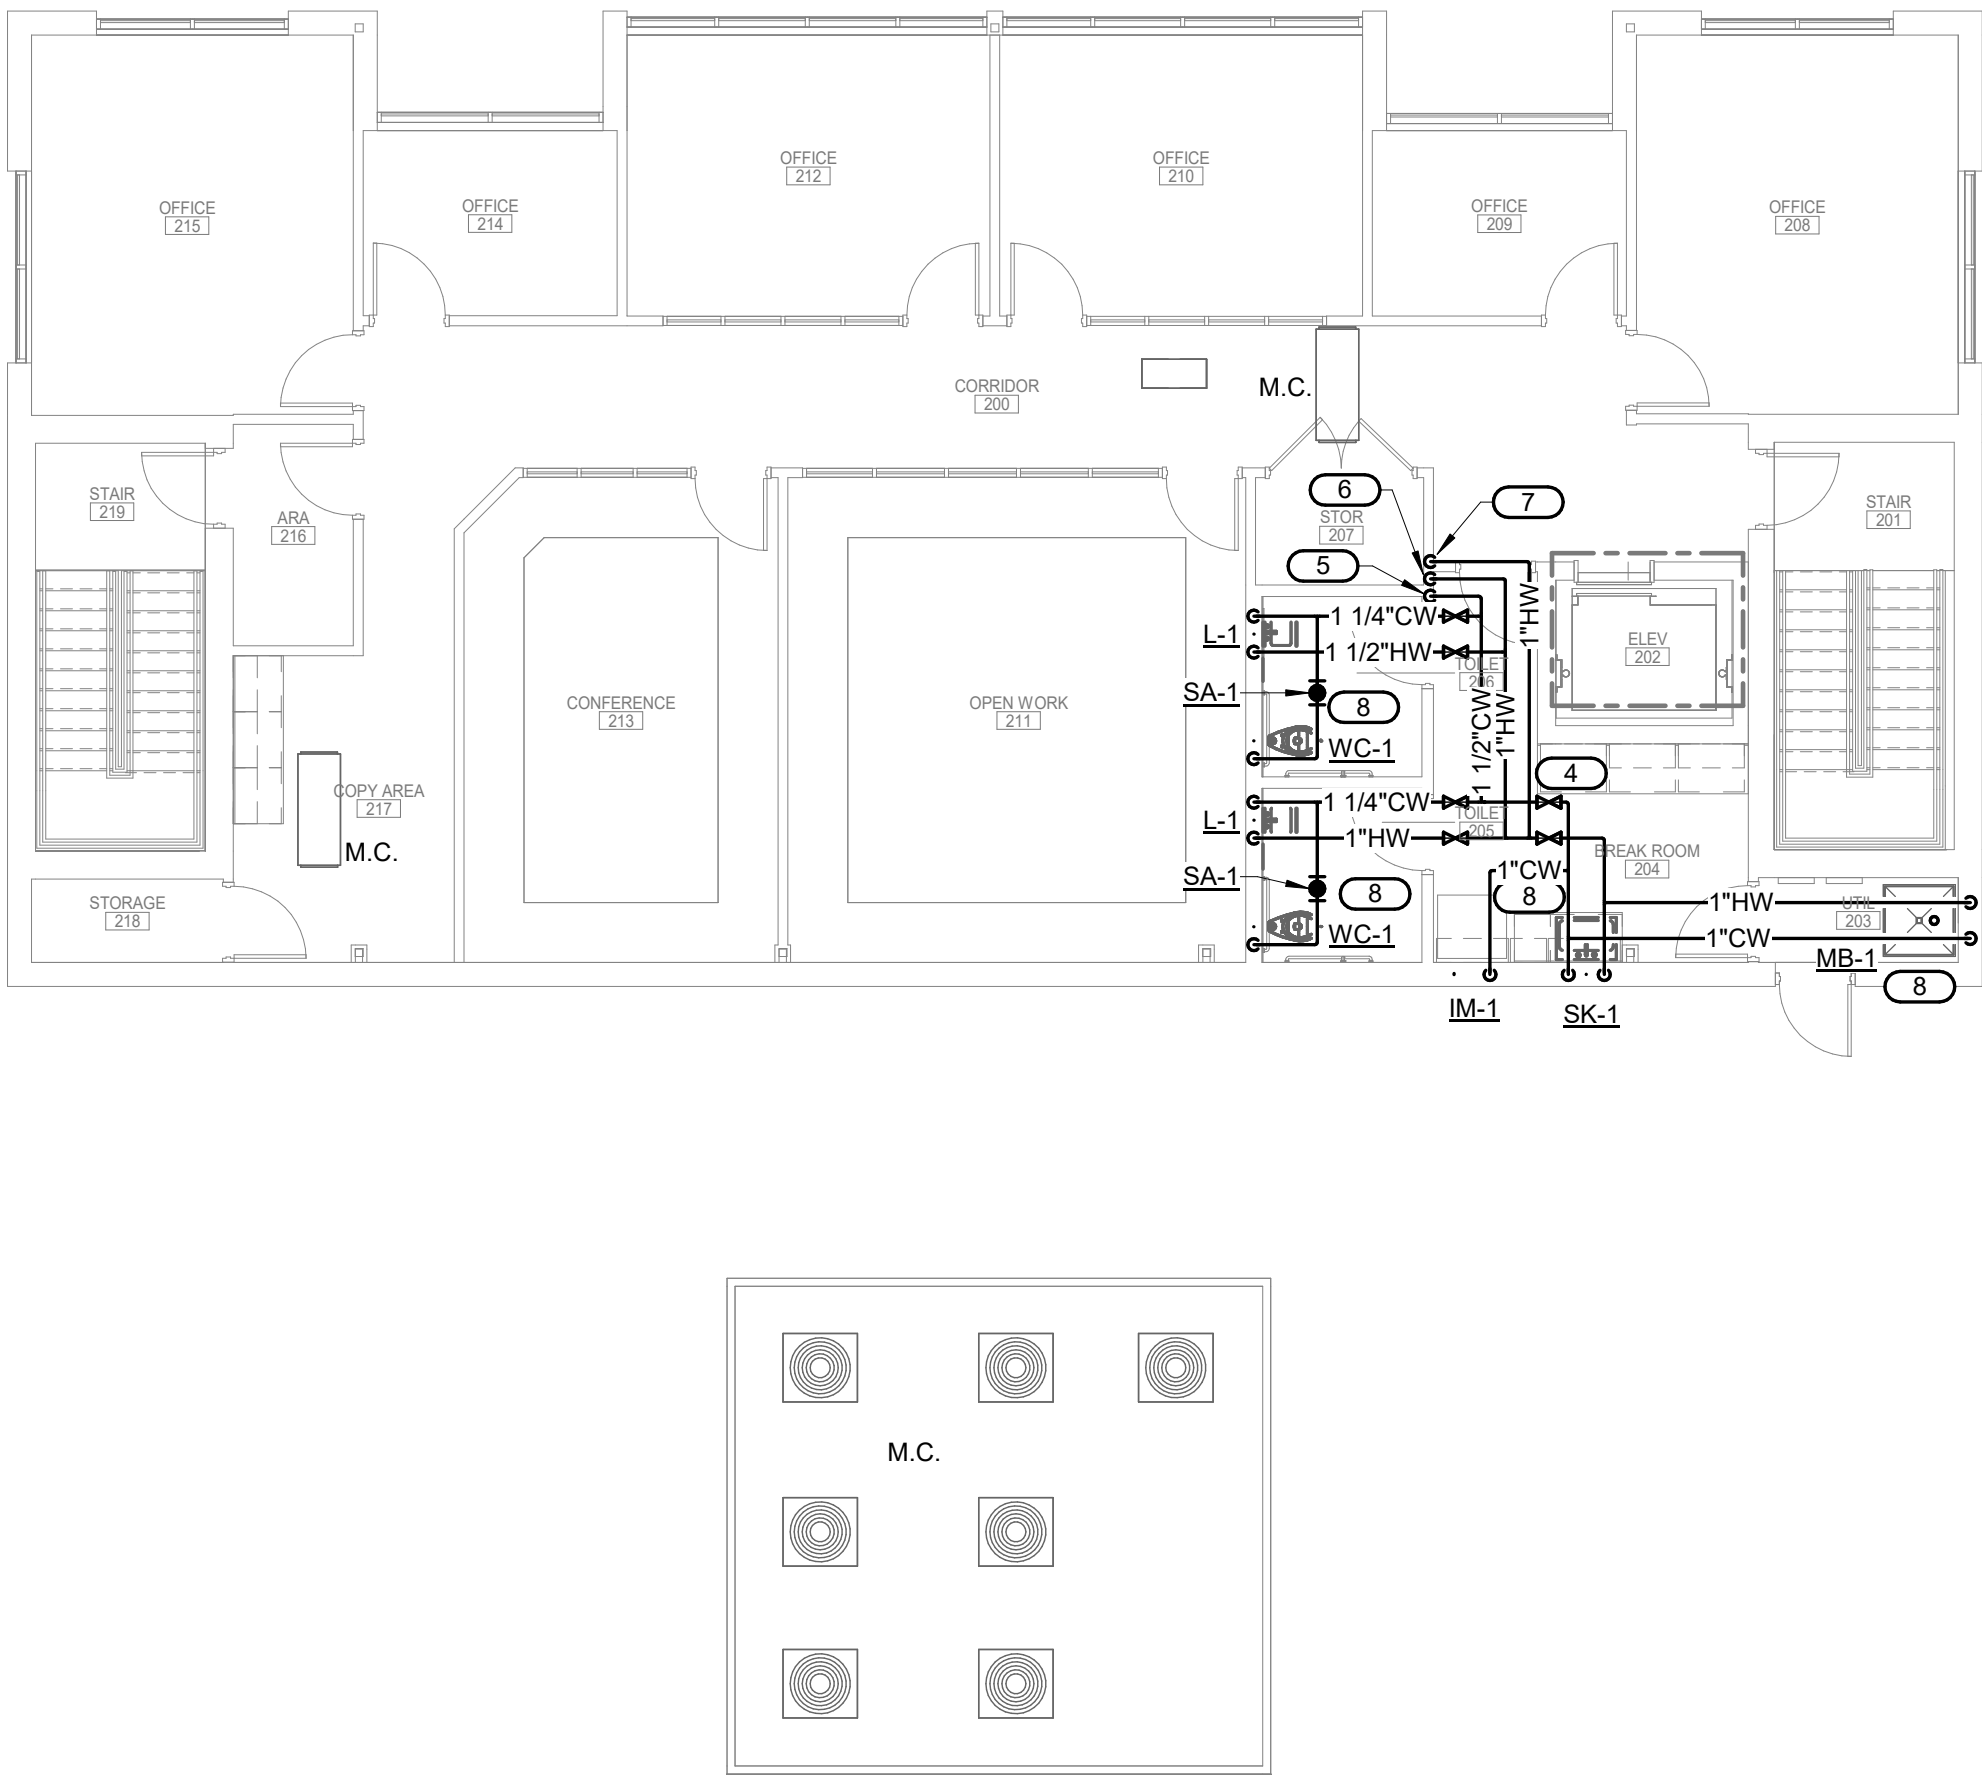

KEYNOTES: #

1. REPLACE BUILDINGS EXISTING COLD WATER PIPING WITH NEW 2" WATER LINE. PLUMBING CONTRACTORS WORK BEGINS 5'-0" OUTSIDE BUILDING. SEE SITE PLAN FOR CONTINUATION.
2. EXISTING SANITARY SEWER PIPE TO REMAIN. PLUMBING CONTRACTOR TO SCOPE BUILDINGS EXISTING LINE AND REPAIR PIPING LEAKS OR DAMAGE AS REQUIRED.
3. NEW 2" WATER LINE TO RISE UP FROM BELOW FINISHED FLOOR TO BACKFLOW PREVENTER (BP-1). PROVIDE WITH BUILDING SHUT OFF VALVE.
4. NEW WATER PIPING LOCATED ABOVE FINISHED CEILING. COORDINATE LOCATION WITH MECHANICAL AND ELECTRICAL CONTRACTORS.
5. 1 1/2" COLD WATER LINE UP TO SECOND FLOOR.
6. 1" HOT WATER LINE UP TO SECOND FLOOR.
7. 1" HOT WATER LINE DOWN FROM SECOND FLOOR.
8. CONNECT TO EXISTING WASTE AND VENT PIPING IN THIS AREA. FIELD VERIFY EXACT LOCATION. CAP UNUSED WASTE AND VENT PIPING AS REQUIRED.
9. SUMP PUMP (SP-1) LOCATED IN SUMP PIT, SUMP PIT BY GENERAL CONTRACTOR.
10. ROUTE 2" FORCED MAIN ABOVE FINISHED CEILING. COORDINATE LOCATION WITH MECHANICAL AND ELECTRICAL CONTRACTORS.
11. DROP DOWN IN WALL AND SPILL ON GRADE. PROVIDE WITH SPLASH BLOCK.
12. ELEVATOR SUMP PUMP ALARM ON WALL.
13. 1-HR RATED FIRE WALL.

IMEG
www.imegcorp.com
3221 BLUE RIDGE ROAD
SUITE 113
RALEIGH, NC 27612
P. 919.971.1111

IMEG RESERVES PROPRIETARY RIGHTS, INCLUDING COPYRIGHTS, TO THIS DRAWING AND THE DATA SHOWN THEREON. SAID DRAWING AND/OR DATA ARE THE EXCLUSIVE PROPERTY OF IMEG AND SHALL NOT BE USED OR REPRODUCED FOR ANY OTHER PROJECT WITHOUT THE EXPRESS WRITTEN APPROVAL AND PARTICIPATION OF IMEG.
©2026 IMEG CONSULTANTS CORP.
North Carolina Design Registration #E-1507



0 1 2 3
REF. SCALE IN INCHES PROJECT #26001727.00

RENOVATION FOR:

CRAVEN COUNTY GOVERNMENT CENTER
EAST

CRAVEN COUNTY

1208 E. MAIN STREET, HAVELOCK, NORTH CAROLINA 28532

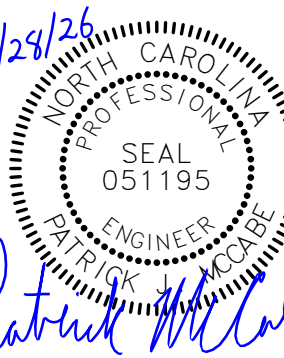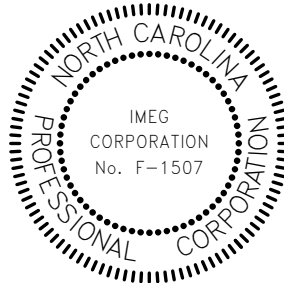

GENERAL NOTE:
Prior to construction start, Contractor shall verify & be responsible for all Dimensions.


Revisions		
#	Description	Date
Date	Project No.	
05-28-26	26001727.00	
Drawn By	Sheet No.	
FEA	P201	
Checked By		
DRD		
	Sheet Title	
	FLOOR PLAN - PLUMBING	

OAKLEY
COLLIER
ARCHITECTS
OCA

109 Candlewood Road, Rocky Mount, NC 27804 (P) 252.937.2500
205 W. Martin Street, Raleigh, NC 27601

Copyright © 2025 Oakley Collier Architects. These drawings are of the property of the Architect for use under his supervision. No reproduction or other use is allowed without permission.

1 ROOF PLAN - PLUMBING
1/8" = 1'-0"

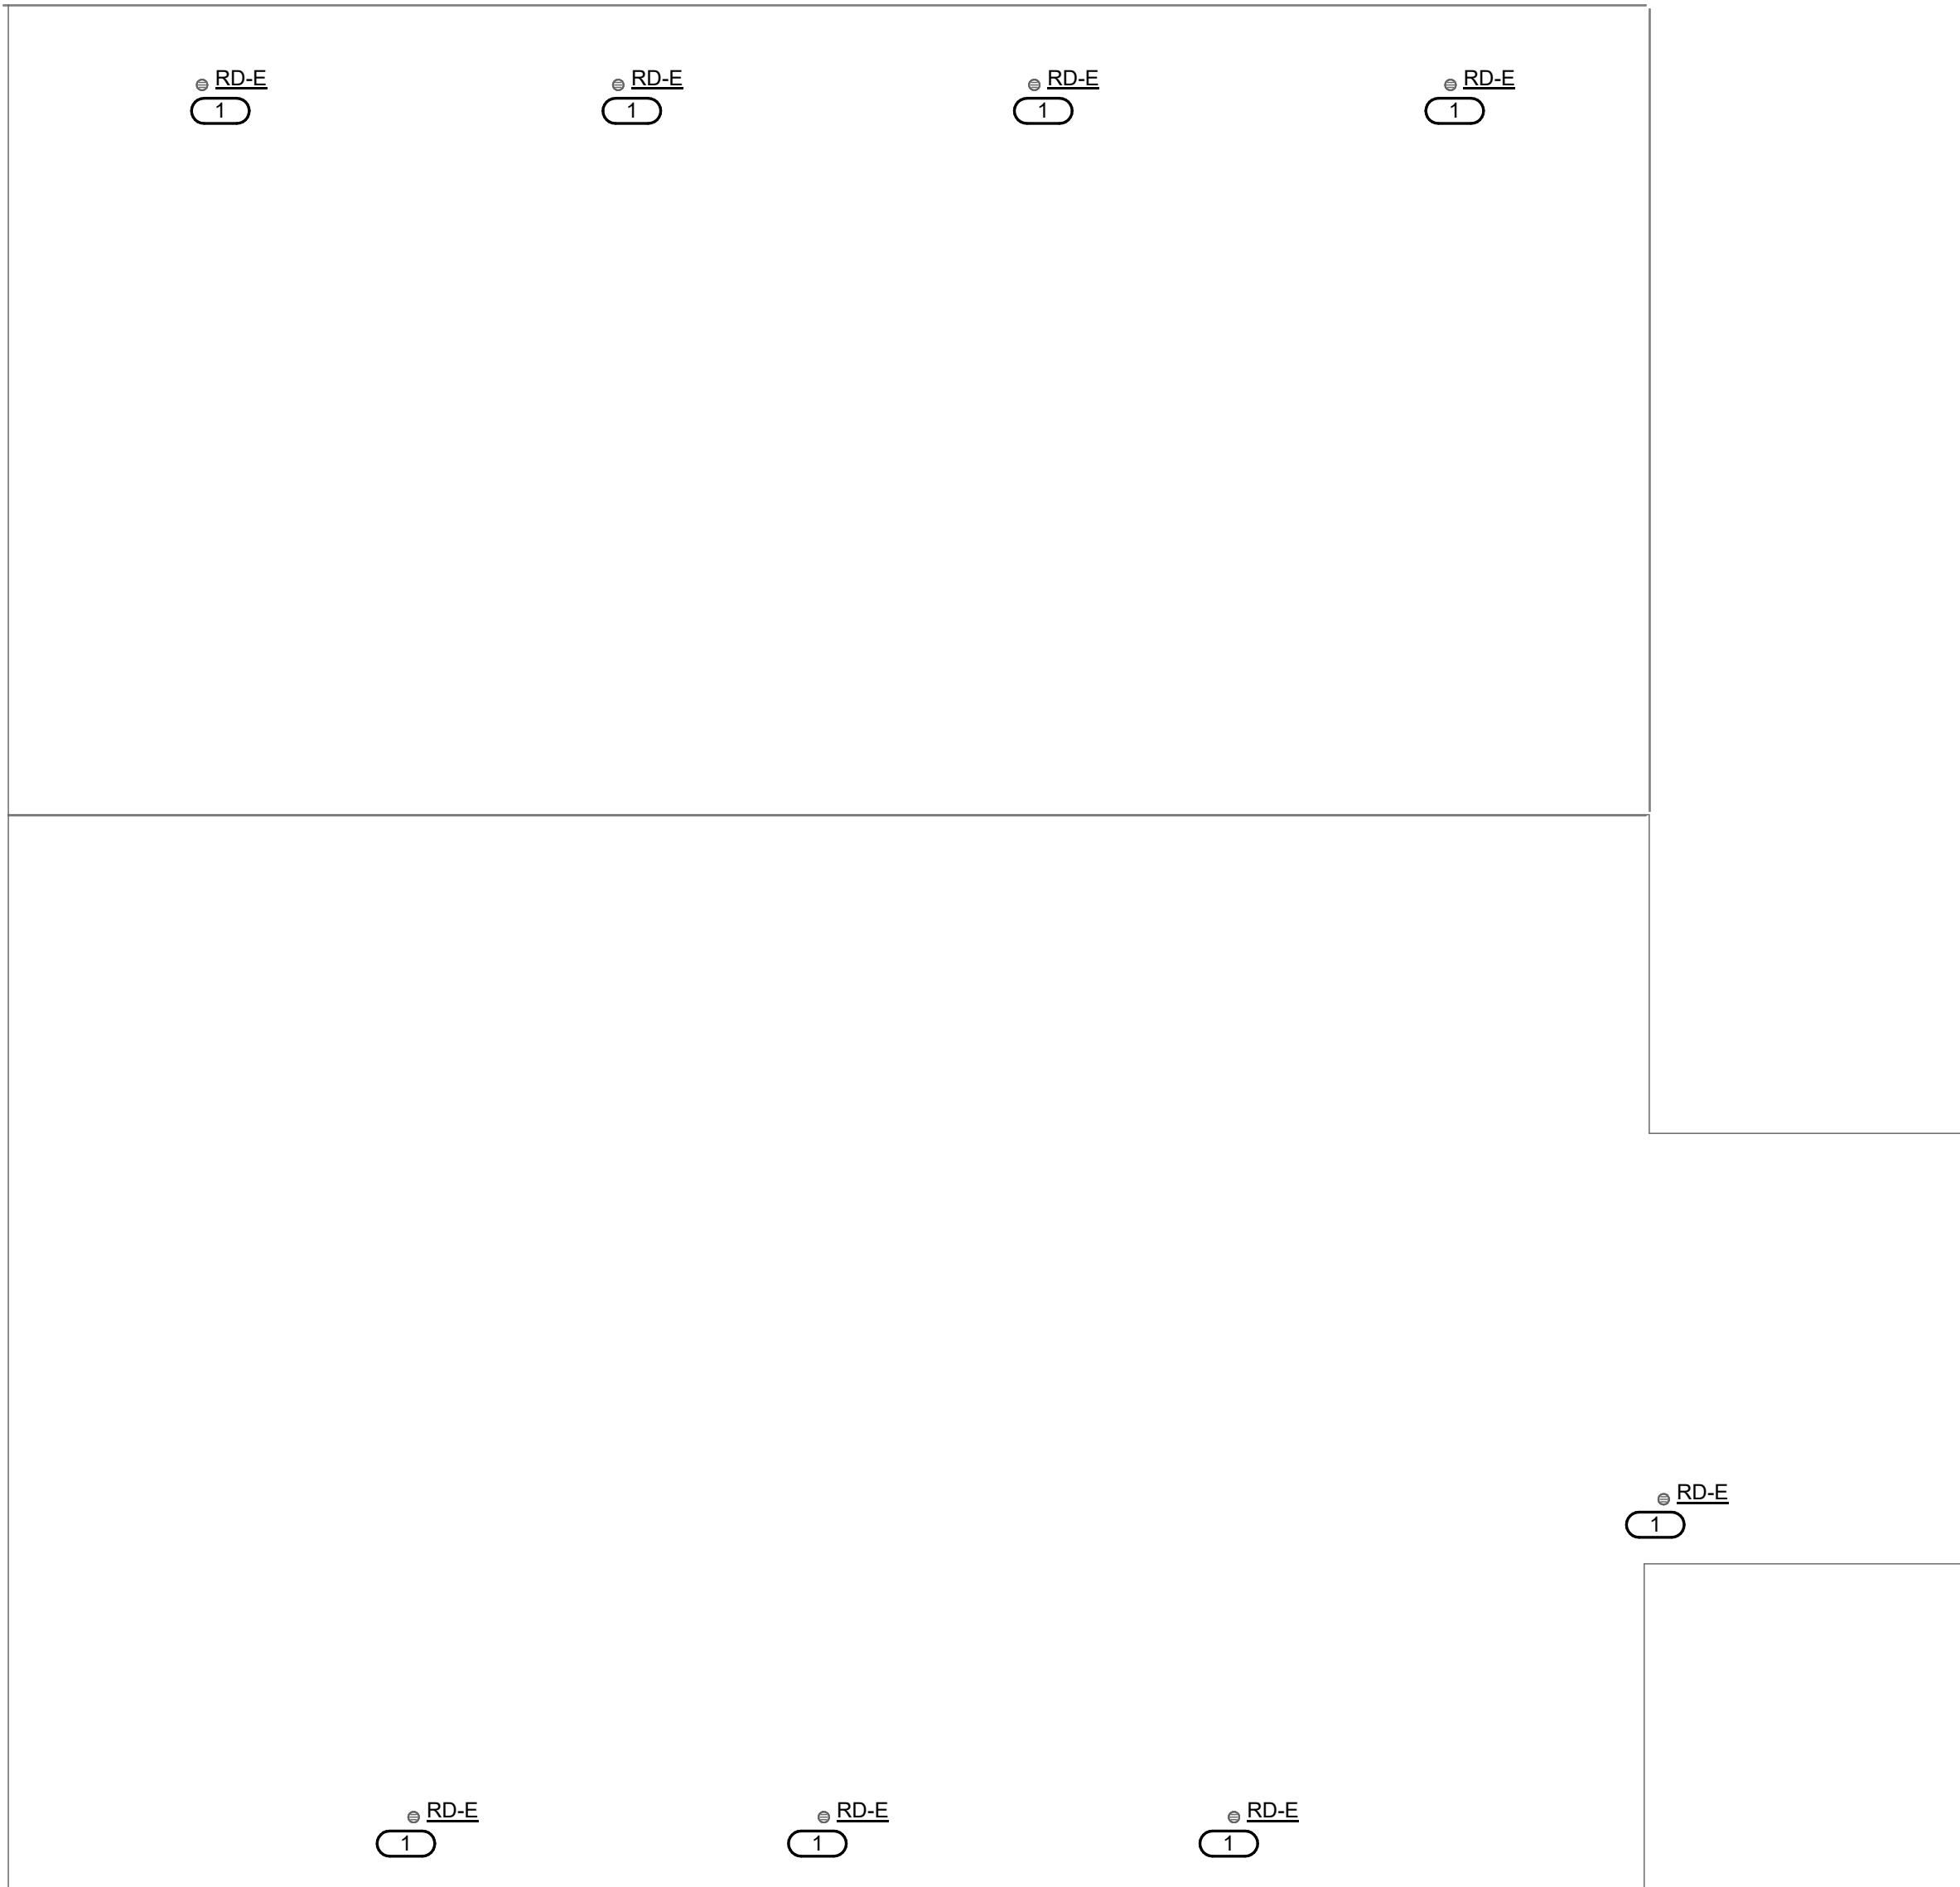

KEYNOTES: #

1. EXISTING ROOF DRAINS AND ROOF DRAIN LEADER LINES TO REMAIN. PLUMBING CONTRACTOR TO CLEAN AND REFURBISH ROOF DRAINS TO LIKE NEW CONDITION AND FIELD VERIFY CONDITION OF ROOF DRAIN LEADERS AND MAKE REPAIRS AS REQUIRED.

IMEG
www.imegcorp.com
3221 BLUE RIDGE ROAD
SUITE 113
RALEIGH, NC 27612
P. 919.971.1111

IMEG RESERVES PROPRIETARY RIGHTS, INCLUDING COPYRIGHTS, TO THIS DRAWING AND THE DATA SHOWN THEREON. SAID DRAWING AND/OR DATA ARE THE EXCLUSIVE PROPERTY OF IMEG AND SHALL NOT BE USED OR REPRODUCED FOR ANY OTHER PROJECT WITHOUT THE EXPRESS WRITTEN APPROVAL AND PARTICIPATION OF IMEG.
©2026 IMEG CONSULTANTS CORP.



North Carolina Design Registration #F-1507

0 1 2 3
REF. SCALE IN INCHES PROJECT #26001727.00

RENOVATION FOR:

CRAVEN COUNTY GOVERNMENT CENTER
EAST


CRAVEN COUNTY
1208 E. MAIN STREET, HAVELOCK, NORTH CAROLINA 28532

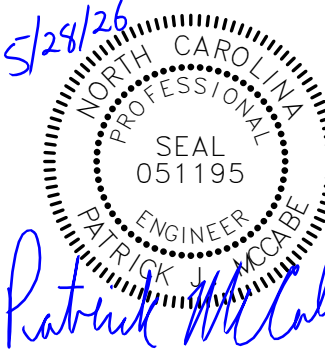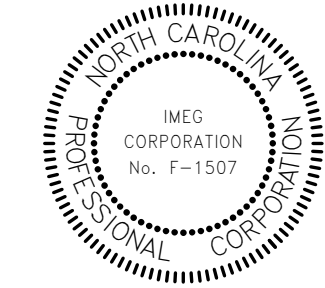

GENERAL NOTE:
Prior to construction start, Contractor shall verify & be responsible for all Dimensions.


Revisions		
#	Description	Date
Date		Project No.
05-28-26		26001727.00
Drawn By		Sheet No.
FEA		P202
Checked By		
DRD		Sheet Title
ROOF PLAN - PLUMBING		

OCA
OAKLEY COLLIER ARCHITECTS
109 Candlewood Road, Rocky Mount, NC 27804 (P) 252.937.2500
205 W. Martin Street, Raleigh, NC 27601

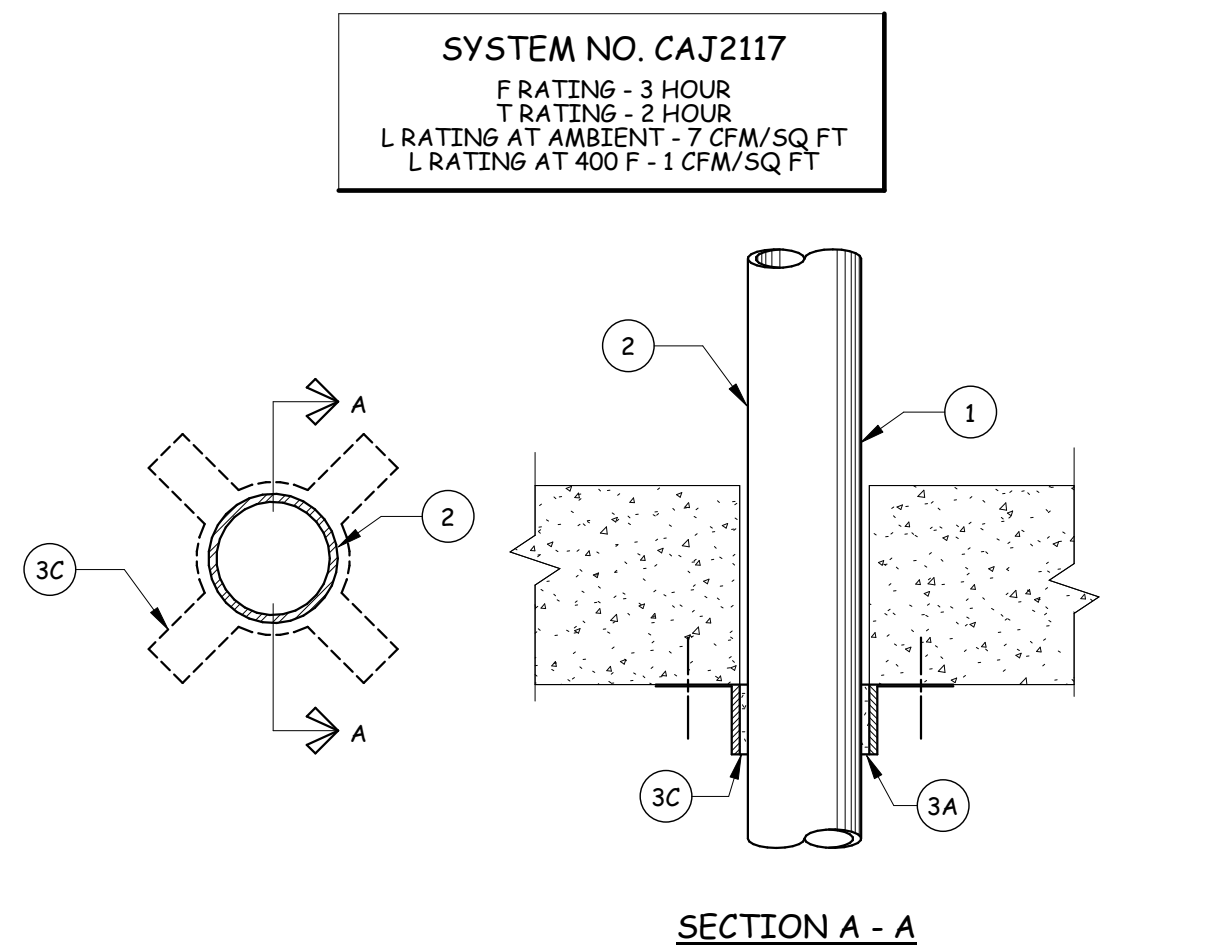




- 1 FLOOR OR WALL ASSEMBLY-LIGHTWEIGHT OR NORMAL WEIGHT (100-150 PCF) CONCRETE, MIN THICKNESS OF SOLID CONCRETE FLOOR OR WALL ASSEMBLY IS 4-1/2 IN. WALL MAY ALSO BE CONSTRUCTED OF ANY UL CLASSIFIED CONCRETE BLOCKS*, DIAM OF OPENING TO BE MAX 1/2 IN. LARGER THAN DIAM OF NONMETALLIC PIPE (ITEM 2). MAX DIAM OF OPENING IS 5 IN. SEE CONCRETE BLOCKS (CAJ21) CATEGORY IN FIRE RESISTANCE DIRECTORY FOR NAMES OF MANUFACTURERS.
- 2 NONMETALLIC PIPE-NOM 4 IN. DIAM (OR SMALLER) SCHEDULE 40 SOLID-CORE POLYVINYL CHLORIDE (PVC) PIPE OR SDIR7 CHLORINATED POLYVINYL CHLORIDE (CPVC) PIPE FOR USE IN CLOSED (PROCESS OR SUPPLY) OR VENTED (DRAIN, WASTE OR VENT) PIPING SYSTEMS. A MAX OF ONE NONMETALLIC PIPE IS PERMITTED IN THE FIRESTOP SYSTEM. THE PIPE SHALL BE CENTERED IN THE THROUGH OPENING. PIPE TO BE RIGIDLY SUPPORTED ON BOTH SIDES OF WALL OR FLOOR ASSEMBLY.
- 3 FIRESTOP SYSTEM-THE DETAILS OF THE FIRESTOP SYSTEM SHALL BE AS FOLLOWS:
A. FILL, VOID OR CAVITY MATERIALS*-WRAP STRIP-NOM 1/4 IN. THICK INTUMESCENT ELASTOMERIC MATERIAL FACED ON ONE SIDE WITH ALUMINUM FOIL, SUPPLIED IN 2 IN. WIDE STRIPS, NOM 2 IN. WIDE STRIPS TIGHTLY WRAPPED AROUND NONMETALLIC PIPE (FOIL SIDE EXPOSED) WITH THE TOP EDGES BUTTED AGAINST THE UNDERSIDE OF THE CONCRETE FLOOR. SUFFICIENT LAYERS OF WRAP STRIP SHALL BE INSTALLED TO LAP A MIN OF 3/16 IN. ON THE CONCRETE AROUND THE ENTIRE PERIMETER OF THE THROUGH OPENING. FOR NOM 1/2 IN. TO NOM 1-1/2 IN. DIAM PIPES, A MIN OF ONE LAYER OF WRAP STRIP IS REQUIRED. FOR NOM 2, 2-1/2 IN. AND 3 IN. DIAM PIPES, A MIN OF TWO LAYERS OF WRAP STRIP IS REQUIRED. FOR NOM 3-1/2 IN. AND 4 IN. DIAM PIPES, A MIN OF THREE LAYERS OF WRAP STRIP IS REQUIRED. EACH LAYER OF WRAP STRIP TO BE INSTALLED WITH BUTTED SEAM WITH BUTTED SEAMS IN SUCCESSIVE LAYERS STAGGERED. WRAP STRIP LAYERS TEMPORARILY HELD IN POSITION USING ALUMINUM FOIL TAPE, STEEL WIRE TIE, OR EQUIVALENT. IN WALL ASSEMBLIES, THE WRAP STRIP IS TO BE INSTALLED IN THE SAME MANNER USED FOR FLOOR ASSEMBLIES, BUT IT SHALL BE INSTALLED SYMMETRICALLY ON BOTH SIDES OF THE WALL ASSEMBLY. MINNESOTA MINING & MFG. CO.-FS-195+
B. FILL, VOID OR CAVITY MATERIALS*-CAULK OR PUTTY-(NOT SHOWN)-GENEROUS BEAD OF CAULK OR PUTTY TO BE APPLIED TO OUTER PERIMETER OF WRAP STRIP AT ITS INTERFACE WITH FLOOR OR WALL SURFACE(S). MINNESOTA MINING & MFG. CO.-CP 25WB+ CAULK, TYPE MP+ PUTTY. (NOTE: L RATINGS APPLY ONLY WHEN TYPE CP 25WB+ CAULK IS USED.)
C. STEEL COLLAR-NOM 2 IN. DEEP COLLAR WITH 1-1/4 IN. WIDE BY 2 IN. LONG ANCHOR TABS AND MIN 1/2 IN. LONG TABS TO RETAIN WRAP STRIP LAYERS. COILS OF PRECUT 0.016 IN. THICK (30 GAUGE) GALV SHEET STEEL AVAILABLE FROM WRAP STRIP MANUFACTURER. AS AN ALTERNATE, COLLAR MAY BE FIELD-FABRICATED FROM MIN 0.016 IN. THICK (30 GAUGE) GALV SHEET STEEL IN ACCORDANCE WITH INSTRUCTIONS SUPPLIED BY WRAP STRIP MANUFACTURER. STEEL COLLAR, WITH ANCHOR TABS BENT OUTWARD 90 DEG, WRAPPED TIGHTLY AROUND WRAP STRIP LAYERS WITH MIN 1 IN. OVERLAP AT SEAM. WITH STEEL COLLAR ANCHOR TABS PRESSED TIGHTLY AGAINST FLOOR OR WALL SURFACE(S), COMPRESS COLLAR AROUND LAYERS USING A MIN 1/2 IN. WIDE BY 0.028 IN. THICK STAINLESS STEEL BAND CLAMP WITH WORM DRIVE TIGHTENING MECHANISM AT THE COLLAR MIDHEIGHT. SECURE COLLAR TO FLOOR OR WALL SURFACE(S) WITH 1/4 IN. DIAM BY MIN 1-1/2 IN. LONG STEEL EXPANSION BOLTS, OR EQUIVALENT. IN CONTACT WITH STEEL NUTS AND MIN 1-1/4 IN. DIAM STEEL FENDER WASHERS. TWO ANCHOR BOLTS, SYMMETRICALLY LOCATED, ARE REQUIRED FOR NOM 1/2 IN. TO NOM 2 IN. DIAM PIPES. THREE ANCHOR BOLTS, SYMMETRICALLY LOCATED, ARE REQUIRED FOR NOM 3 IN. DIAM PIPES. FOUR ANCHOR BOLTS, SYMMETRICALLY LOCATED, ARE REQUIRED FOR NOM 3-1/2 IN. AND 4 IN. DIAM PIPES. AS A FINAL STEP, BEND RETAINER TABS 90 DEG TOWARD PIPE TO LOCK WRAP STRIP LAYERS IN POSITION.
D. FIRESTOP DEVICE*-(NOT SHOWN)-AS AN ALTERNATE TO ITEMS A AND C WHEN NOM 1-1/2, 2, 3 OR 4 IN. DIAM NONMETALLIC PIPE FIRESTOP DEVICE CONSISTING OF A SHEET-STEEL SPLIT COLLAR LINED WITH INTUMESCENT MATERIAL AND PROVIDED WITH STEEL CLIPS FOR ATTACHMENT MAY BE USED. FIRESTOP DEVICE TO BE INSTALLED ON UNDERSIDE OF FLOOR OR ON BOTH SIDES OF WALL IN ACCORDANCE WITH THE ACCOMPANYING INSTALLATION INSTRUCTIONS. MINNESOTA MINING & MFG. CO.-TYPES PPD 150, PPD 200, PPD 300, PPD 400.
*BEARING THE UL CLASSIFICATION MARKING

5 PENETRATION DETAIL
12" = 1'-0"

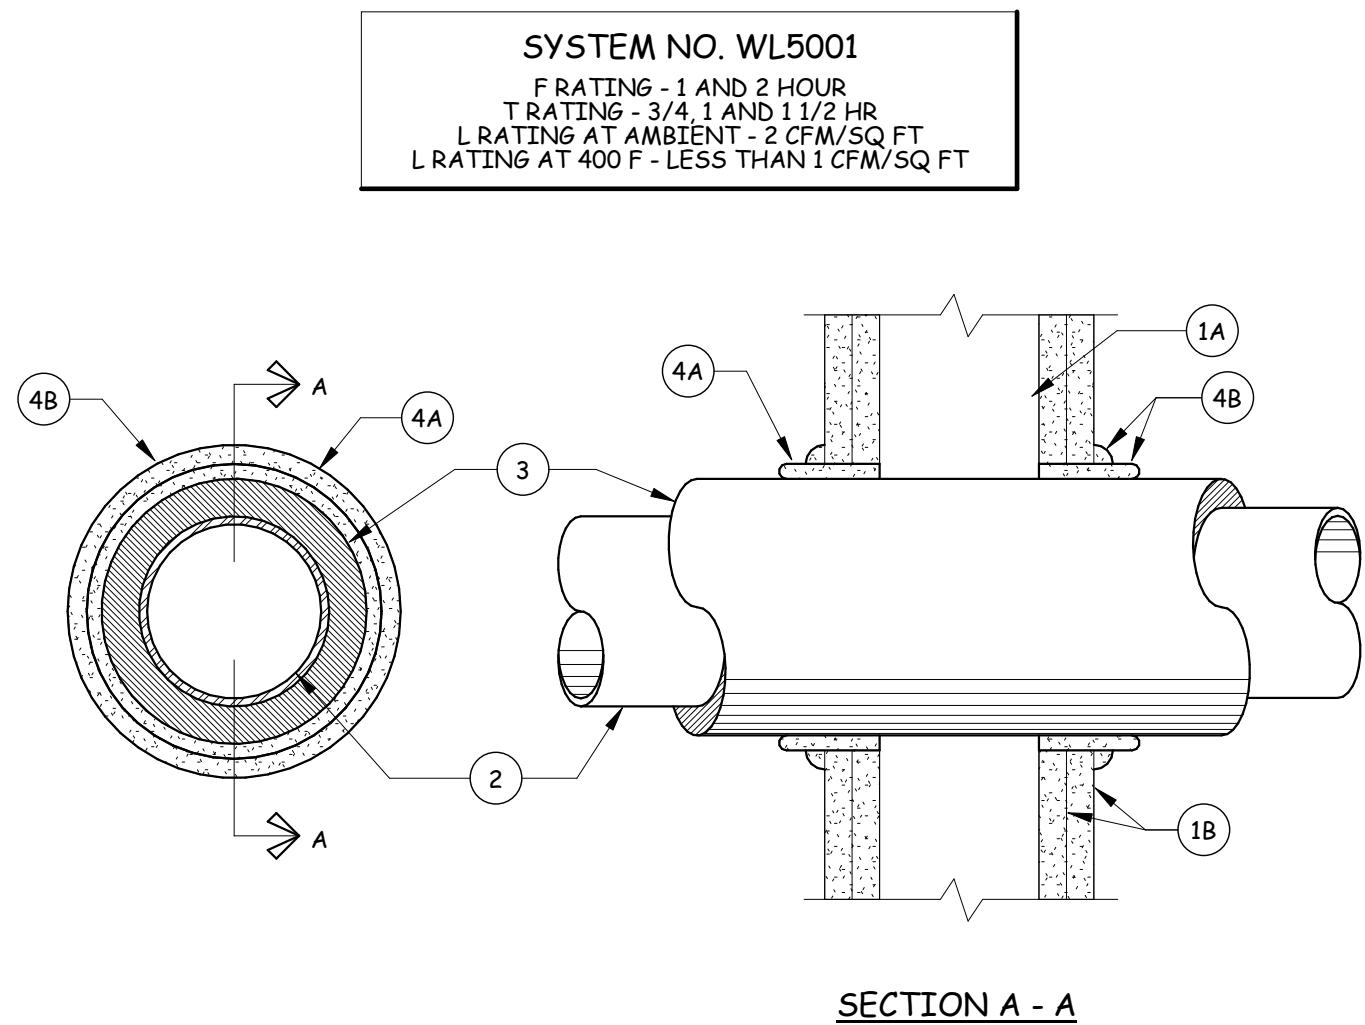

- 1 WALL ASSEMBLY-THE 1 OR 2 HR FIRE-RATED GYPSUM WALLBOARD/STUD WALL ASSEMBLY SHALL BE CONSTRUCTED OF THE MATERIALS AND IN THE MANNER DESCRIBED IN THE INDIVIDUAL U300 OR U400 SERIES WALL OR PARTITION DESIGN IN THE UL FIRE RESISTANCE DIRECTORY AND SHALL INCLUDE THE FOLLOWING CONSTRUCTION FEATURES:
A. STUDS-WALL FRAMING MAY CONSIST OF EITHER WOOD STUDS OR STEEL CHANNEL STUDS. WOOD STUDS TO CONSIST OF NOM 2 BY 4 IN. LUMBER SPACED 16 IN. OC WITH NOM 2 BY 4 IN. LUMBER END PLATES AND CROSS BRACES. STEEL STUDS TO BE MIN 3-5/8 IN. WIDE BY 1-3/8 IN. DEEP CHANNELS SPACED MAX 24 IN. OC.
B. WALLBOARD, GYPSUM*-NOM 5/8 IN. THICK, 4 FT WIDE WITH SQUARE OR TAPERED EDGES. THE GYPSUM WALLBOARD TYPE, THICKNESS, NUMBER OF LAYERS, FASTENER TYPE AND SHEET ORIENTATION SHALL BE AS SPECIFIED IN THE INDIVIDUAL U300 OR U400 SERIES DESIGN IN THE UL FIRE RESISTANCE DIRECTORY. MAX DIAM OF OPENING IS 14-1/2 IN. FOR WOOD STUD WALLS AND 18 IN. FOR STEEL STUD WALLS. THE HOURLY F RATING OF THE FIRESTOP SYSTEM IS 1 HR WHEN INSTALLED IN A 1 HR FIRE RATED WALL AND 2 HR WHEN INSTALLED IN A 2 HR FIRE RATED WALL.
- 2 THROUGH PENETRANTS-ONE METALLIC PIPE OR TUBING TO BE CENTERED WITHIN THE FIRESTOP SYSTEM. PIPE OR TUBING TO BE RIGIDLY SUPPORTED ON BOTH SIDES OF WALL ASSEMBLY. THE FOLLOWING TYPES AND SIZES OF METALLIC PIPES OR TUBING MAY BE USED:
A. STEEL PIPE-NOM 12 IN. DIAM (OR SMALLER) SCHEDULE 10 (OR HEAVIER) STEEL PIPE
B. COPPER TUBING-NOM 6 IN. DIAM (OR SMALLER) TYPE L (OR HEAVIER) COPPER TUBING
C. COPPER PIPE-NOM 6 IN. DIAM (OR SMALLER) REGULAR (OR HEAVIER) COPPER PIPE
- 3 PIPE COVERING*-NOM 1 OR 2 IN. THICK HOLLOW CYLINDRICAL HEAVY DENSITY (MIN 3.5 PCF) GLASS FIBER UNITS JACKETED ON THE OUTSIDE WITH AN ALL SERVICE JACKET. LONGITUDINAL JOINTS SEALED WITH METAL FASTENERS OR FACTORY-APPLIED SELF-SEALING LAP TAPE. TRANSVERSE JOINTS SEALED WITH METAL FASTENERS OR WITH BUTT STRIP TAPE SUPPLIED WITH THE PRODUCT. WHEN NOM 1 IN. THICK PIPE COVERING IS USED, THE ANNULAR SPACE BETWEEN THE PIPE COVERING AND THE CIRCULAR CUTOUT IN THE GYPSUM WALLBOARD LAYERS ON EACH SIDE OF THE WALL SHALL BE MIN 1/4 IN. TO MAX 3/8 IN. WHEN NOM 2 IN. THICK PIPE COVERING IS USED, THE ANNULAR SPACE BETWEEN THE PIPE COVERING AND THE CIRCULAR CUTOUT IN THE GYPSUM WALLBOARD LAYERS ON EACH SIDE OF THE WALL SHALL BE MIN 1/2 IN. TO MAX 3/4 IN. SEE PIPE AND EQUIPMENT COVERING MATERIALS (BR6U) CATEGORY IN BUILDING MATERIALS DIRECTORY FOR NAMES OF MANUFACTURERS. ANY PIPE COVERING MATERIAL MEETING THE ABOVE SPECIFICATIONS AND BEARING THE UL CLASSIFICATION MARKING WITH A FLAME SPREAD INDEX OF 25 OR LESS AND A SMOKE DEVELOPED INDEX OF 50 OR LESS MAY BE USED. THE HOURLY F RATING OF THE FIRESTOP SYSTEM IS 3/4 HR WHEN NOM 1 IN. THICK PIPE COVERING IS USED. THE HOURLY F RATING OF THE FIRESTOP SYSTEM IS 1 HR AND 1 1/2 HR WHEN NOM 2 IN. THICK PIPE COVERING IS USED WITH 1 HR AND 2 HR FIRE RATED WALLS, RESPECTIVELY.
- 4 FIRESTOP SYSTEM-INSTALLED SYMMETRICALLY ON BOTH SIDES OF WALL ASSEMBLY. THE DETAILS OF THE FIRESTOP SYSTEM SHALL BE AS FOLLOWS:
A. FILL, VOID OR CAVITY MATERIALS*-WRAP STRIP-NOM 1/4 IN. THICK INTUMESCENT ELASTOMERIC MATERIAL FACED ON ONE SIDE WITH ALUMINUM FOIL, SUPPLIED IN 2 IN. WIDE STRIPS, NOM 2 IN. WIDE STRIP TIGHTLY WRAPPED AROUND PIPE COVERING (FOIL SIDE OUT) WITH SEAM BUTTED. WRAP STRIP LAYER SECURELY BOUND WITH STEEL WIRE OR ALUMINUM FOIL TAPE AND SLID INTO ANNULAR SPACE APPROX 1-1/4 IN. SUCH THAT APPROX 3/4 IN. OF THE WRAP STRIP WIDTH PROTRUDES FROM THE WALL SURFACE. ONE LAYER OF WRAP STRIP IS REQUIRED WHEN NOM 1 IN. THICK PIPE COVERING IS USED. TWO LAYERS OF WRAP STRIP ARE REQUIRED WHEN NOM 2 IN. THICK PIPE COVERING IS USED. MINNESOTA MINING & MFG. CO.-FS-195+
B. FILL, VOID OR CAVITY MATERIALS*-CAULK-MIN 1/4 IN. DIAM CONTINUOUS BEAD APPLIED TO THE WRAP STRIP/WALL INTERFACE AND TO THE EXPOSED EDGE OF THE WRAP STRIP LAYER APPROX 3/4 IN. FROM THE WALL SURFACE. MINNESOTA MINING & MFG. CO.-CP 25WB+
*BEARING THE UL CLASSIFICATION MARKING

4 PENETRATION DETAIL
12" = 1'-0"

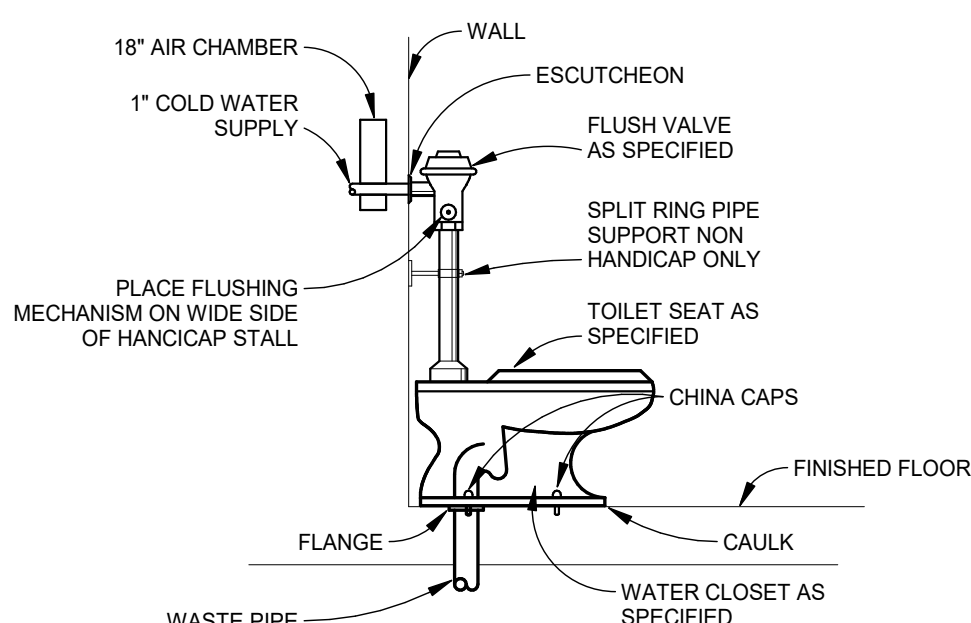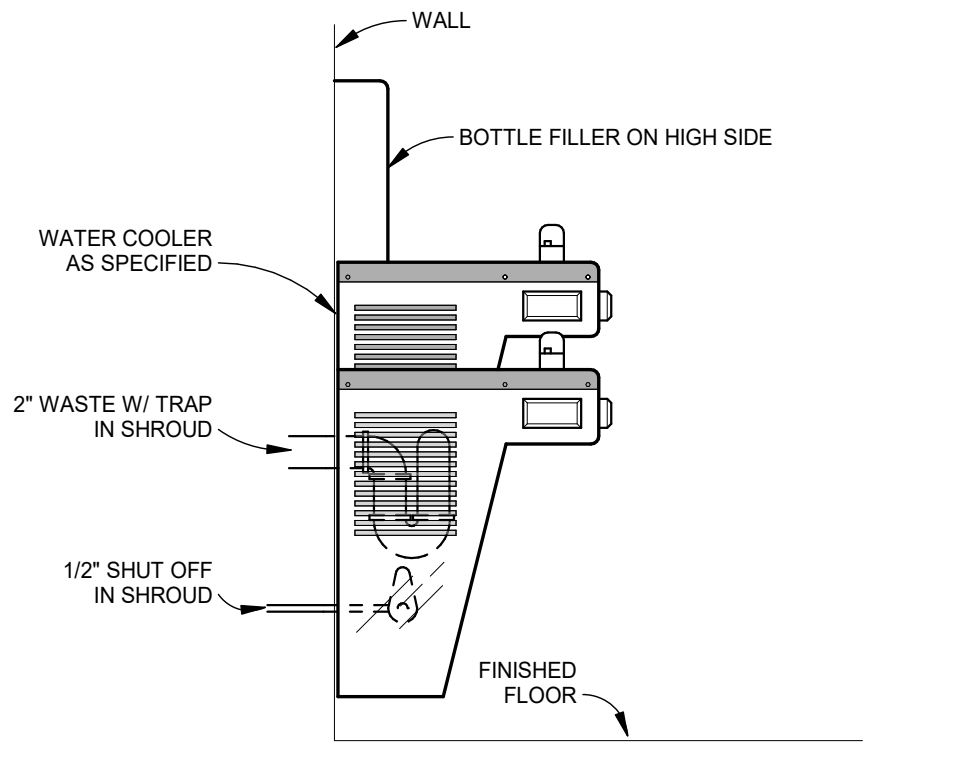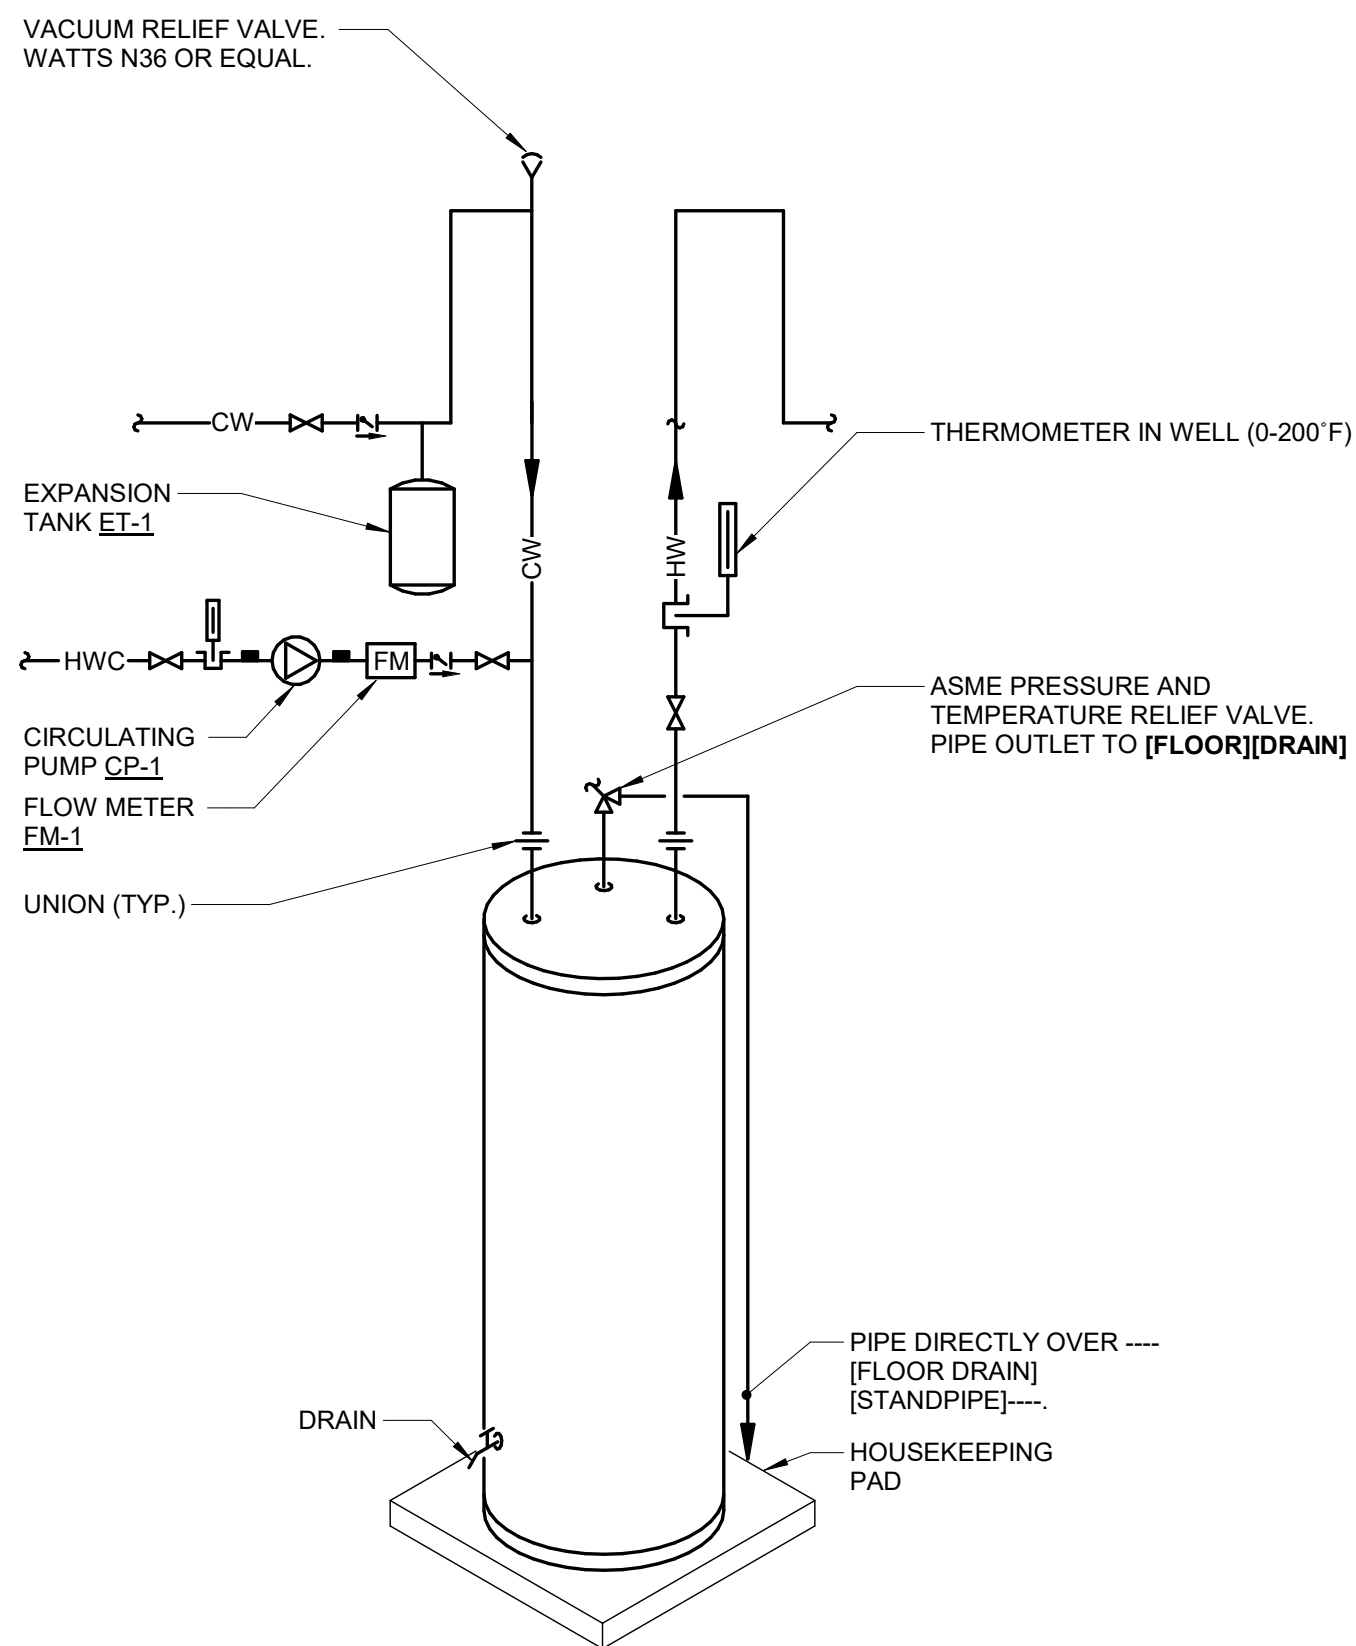

IMEG
www.imegcorp.com
3221 BLUE RIDGE ROAD
SUITE 113
RALEIGH, NC 27612
P. 919.971.1111
IMEG RESERVES PROPRIETARY RIGHTS, INCLUDING COPYRIGHTS, TO THIS DRAWING AND THE DATA SHOWN THEREON. SAID DRAWING AND/OR DATA ARE THE EXCLUSIVE PROPERTY OF IMEG AND SHALL NOT BE USED OR REPRODUCED FOR ANY OTHER PROJECT WITHOUT THE EXPRESS WRITTEN APPROVAL AND PARTICIPATION OF IMEG.
©2026 IMEG CONSULTANTS CORP.
North Carolina Design Registration #E-1507
0 1 2 3
REF. SCALE IN INCHES PROJECT #26001727.00

PLUMBING MATERIAL LIST		
TAG NAME	DESCRIPTION	MANUFACTURER AND MODEL
BP-1	LEAD FREE, DOUBLE CHECK VALVE WITH BALL VALVES AND STRAINER. MOUNT 24" ABOVE FINISHED FLOOR.	BACKFLOW PREVENTOR - WATTS (LF007MIQT-S), WILKINS (350XL-S), FEBCO (LF850)
CP-1	RECIRCULATING PUMP SHALL BE 1/6 HORSEPOWER, 120 VOLT, SINGLE PHASE. PROVIDE PUMP WITH MOUNTING BRACKET, TIMER, AQUASTAT AND DISCONNECT. DISCONNECT WIRING BY LICENSED ELECTRICAL CONTRACTOR.	PUMP - B&G (PL36).
EW-1	PROVIDE WITH FRONT AND SIDE CONTROLS, SHUT-OFF VALVE, CARRIER, AND TRAP. PROVIDE STAINLESS STEEL FINISH. PROVIDE WITH BOTTLE FILLER.	ELECTRIC WATER COOLER - ELKAY (LZSTL8WS), OASIS (P8SBFSL), HALSEY TAYLOR (HTHB-HACDBLPV-WF)
FD-1	FLOOR DRAIN TO HAVE A 3" WASTE BOTTOM OUTLET, CAST IRON BODYWITH ADJUSTABLE COLLAR, POLISHED 6" x 6" NICKEL BRONZE SQUARE HEELPROOF STRAINER, AND 1/2" TRAP PRIMER CONNECTION.	FLOOR DRAIN - ZURN (ZN415S), WATTS (FD-100-M), MIFAB (F11000-1)
IM-1	PLASTIC ICE MAKER BOX WITH 1/4 TURN BRASS BALL VALVE WITH HAMMER ARRESTOR - COPPER SWEAT AND SUPPLY TUBE TO REFRIGERATOR. COORDINATE MOUNTING HEIGHT WITH ARCHITECT.	ICE MAKER BOX - OATEY CO. (38570), GUY GRAY (AB9700 HA), SIOUX CHIEF (696-G-1010MF)
L-1	WALL HUNG LAVATORY SHALL BE MADE OF VITREOUS CHINA WITH A WHITE FINISH, HAVE 4" CENTERS, AN OVERFLOW. SEE ARCHITECTURAL DRAWINGS FOR MOUNTING HEIGHT. DECK MOUNTED FAUCET SHALL BE CHROME FINISH, SINGLE LEVER, 4" CENTERS, WITH 3/8" COPPER SUPPLY TUBE INLETS, AND PROVIDED WITH AN AERATOR. RIGID SUPPLY KIT SHALL INCLUDE CHROME PLATED BRASS STOPS WITH THREADED CONNECTIONS, FULL TURN BRASS STEM, REDUCER, AND FLANGE. INLET SHALL BE 3/8" IPS. OUTLET SHALL BE 3/8" IPS. P-TRAP SHALL BE CHROME PLATED CAST BRASS BODY WITH CLEANOUT, CAST BRASS ELBOW AND CAST BRASS SLIP NUT, AND FLANGE. PROVIDE WITH OFFSET DRAIN, TRUEBRO LAV SHIELD, WALL HANGER, AND WATER TEMPERATURE LIMITING DEVICE THAT CONFORMS TO ASSE 1070 OR CSA B125.3.	LAVATORY - AMERICAN STANDARD (0356.041), KOHLER (K-2032-0), ZURN TRIM - DELTA (523LF-HGMHDF), CHICAGO FAUCET (2200-4), MOEN (8470). TRAP - MCGUIRE (8902), DEARBORN BRASS (702-1), KOHLER (K-8999). SUPPLY - MCGUIRE (158LK), BRASS CRAFT (R1912AC), KOHLER (K-7605-P-CP).
MB-1	MOP RECEPTOR SHALL BE 24" x 24" x 12" DEEP WITH ONE PIECE STAINLESS STEEL CAP, NO FLANGES.	MOP BASIN - STERN WILLIAMS (SB-900), FIAT (TSB100). TRIM - STERN WILLIAMS (T-10-VB), CHICAGO FAUCETS (897RCF), MOEN (8124). HOSE - STERN WILLIAMS (T-35), FIAT (832AA). MOP BRACKET - STERN WILLIAMS (T-40), FIAT (889CC).
SA-1	SHOCK ABSORBERS SHALL HAVE A STAINLESS STEEL CASING. FLEXIBLE MECHANICAL BELLOW. PRESSURIZED INERT GAS CHAMBER AND CERTIFICATION STAMP AS CONFORMING TO STANDARD PDI WH-201 OF THE PLUMBING AND DRAINAGE INSTITUTE.	SHOCK ABSORBER - JOSAM (75000), WADE (4480), ZURN (Z1700)
SK-1	SINK IS TO BE 18 GAUGE STAINLESS STEEL, SELF-RIMMING. DECK MOUNTED FAUCET SHALL BE CHROME FINISHED, WITH 1/2" INLET AND PROVIDED WITH AN AERATOR. RIGID SUPPLY KIT SHALL INCLUDE CHROME PLATED BRASS STOPS WITH THREADED CONNECTIONS AND FLANGE. INLET AND OUTLET SHALL BE 3/8" IPS. PROVIDE WITH MCGUIRE PROWRAP INSULATOR. PROVIDE WITH SPRAYER, DISHWASHER CONNECTION, AND DISPOSAL IF REQUIRED BY ARCHITECT.	SINK - ELKAY (LR-3319), JUST (DL-1933-A-GR). SINK TRIM - DELTA (400), MOEN (7437), KOHLER. TRAP - MCGUIRE (8902), DEARBORN BRASS (702-1), KOHLER (K8999). SUPPLY - MCGUIRE (170), BRASSCRAFT (CS400AC), KOHLER (K-76-6-P). STRAINER - ELKAY (LK-99), JUST (JB-99), DEARBORN (L7).
SP-1	ZOELLER OIL SMART SYSTEM INCLUDES: SUMP PUMP, PUMP SWITCH, SENSOR, AND ALARM. SUMP PUMP, 1/2 HP, 120 VOLT, SINGLE PHASE, 52 GPM @ 20' HEAD. PROVIDE WITH CHECK VALVE AND DISCONNECT. WIRING BY LICENSED ELECTRICAL CONTRACTOR. PROVIDE WITH ZOELLER OIL SMART PUMP SWITCH, ALARM, AND SENSOR.	SUMP PUMP - ZOELLER (S40-0007)
WC-1	FLOOR MOUNTED, FLUSH VALVE TOILET SHALL BE MADE OF VITREOUS CHINA WITH A WHITE FINISH AND A 1/2" ROUGH-IN AND 1 1/2" TOP SPUD. SEAT SHALL BE EXTRA HEAVY WEIGHT SOLID PLASTIC WITH OPEN FRONT LESS COVER FOR ELONGATED BOWL. EXPOSED CHROME PLATED FLUSH VALVE WITH 1 1/2" CHROME PLATED SPUD COUPLING AND FLANGE, THE FLUSH VALVE MECHANISM SHALL BE PLACED ON THE WIDE SIDE OF THE STALL.	WATER CLOSET - AMERICAN STANDARD (2305.100), KOHLER (K-96057-0), SLOAN (ST-2029). FLUSH VALVE - SLOAN (111), DELANY (F402-1), ZURN (Z6000-WS1). SEAT - BEMIS (1655SSC), CHURCH (9500C), KOHLER (K-4670-C-0).
WH-1	ELECTRIC WATER HEATER SHALL HAVE A 40 GALLON STORAGE CAPACITY, AN ELECTRIC INPUT OF 4.5 KW AT 208 VOLT, SINGLE PHASE AND A RECOVERY OF 19 GPH AT A 100° RISE. PROVIDE WITH THERMOSTATIC MIXING VALVE SET AT 110°F. EXPANSION TANK AND HEAVY DUTY FUSIBLE DISCONNECT. WIRING BY LICENSED ELECTRICAL CONTRACTOR. WATER HEATER TO BE PROVIDED WITH HEAT TRAPS AND MEET THE ENERGY EFFICIENCY REQUIREMENT PER 2018 NORTH CAROLINA STATE BUILDING CODE; ENERGY CONSERVATION CODE.	WATER HEATER - STATE INDUSTRIES (PCE 40 20LSA), A.O. SMITH, LOCHINVAR.

PLUMBING FIXTURE UNIT SCHEDULE									
TAG NAME	DESCRIPTION	COLD WATER		HOT WATER		SUPPLY WATER		DRAINAGE	
		EA.	TOTAL	EA.	TOTAL	EA.	TOTAL	EA.	TOTAL
EW-1	ELECTRIC WATER COOLER	0.3	0.6	0	0	0.3	0.6	0.5	1
FD-1	FLOOR DRAIN	0	0	0	0	0	0	2	4
IM-1	ICE MAKER BOX	1	2	0	0	1	2	0	0
L-1	LAVATORY	0.5	5	0.5	5	0.7	7	1	10
MB-1	MOP BASIN	2.3	2.3	2.3	2.3	3	3	2	2
SK-1	SINK	1	2	1	2	1.4	2.8	2	4
WC-1	WATER CLOSET	10	100	0	0	10	100	6	60
GRAND TOTALS		111.9		9.3		115.4		81	



3221 BLUE RIDGE ROAD
SUITE 113
RALEIGH, NC 27612
P. 919.971.1111

www.imegcorp.com

IMEG RESERVES PROPRIETARY RIGHTS, INCLUDING COPYRIGHTS, TO THIS DRAWING AND THE DATA SHOWN THEREON. SAID DRAWING AND/OR DATA ARE THE EXCLUSIVE PROPERTY OF IMEG AND SHALL NOT BE USED OR REPRODUCED FOR ANY OTHER PROJECT WITHOUT THE EXPRESS WRITTEN APPROVAL AND PARTICIPATION OF IMEG.
©2026 IMEG CONSULTANTS CORP.

North Carolina Design Registration #E-1507

0123

REF. SCALE IN INCHES

PROJECT #26001727.00

OAKLEY COLIER ARCHITECTS

OCA


109 Candlewood Road, Rocky Mount, NC 27804 (P) 252.937.2500
205 W. Martin Street, Raleigh, NC 27601

RENOVATION FOR:

CRAVEN COUNTY GOVERNMENT CENTER EAST

CRAVEN COUNTY

1208 E. MAIN STREET, HAVELOCK, NORTH CAROLINA 28532

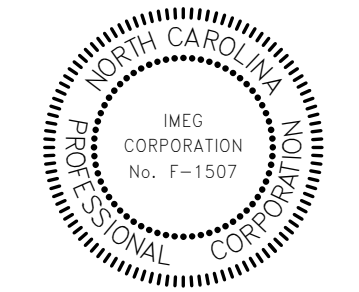

GENERAL NOTE:
Prior to construction start, Contractor shall verify & be responsible for all Dimensions.

Revisions

#	Description	Date
---	-------------	------

Date

05-28-26

Project No.

26001727.00

Drawn By

FEA

Sheet No.

Checked By

DRD

P400

Sheet Title

PLUMBING SCHEDULES

Copyright © 2025 Oakley Collier Architects. These drawings are of the property of the Architect for use under his supervision. No reproduction or other use is allowed without permission.

NAME

10'-0"

HEIGHT ABOVE PROJECT 0'-0"

1

KEYNOTE: INDICATES NOTE USED TO DESCRIBE ADDITIONAL INFORMATION ABOUT WORK REQUIRED, SPECIFIC TO THE SHEET AND/OR DETAIL

INDICATES DIRECTION OF TRUE NORTH

PLAN OR DETAIL NUMBER

PLAN OR DETAIL NAME

1

VIEW NAME

1/8" = 1'-0"

PLAN OR DETAIL SCALE

INDICATES SIMILAR DETAIL REFERENCED IN MULTIPLE LOCATIONS

DETAIL REFERRED TO BY SECTION CUT

SHEET DETAIL IS LOCATED ON

1

2

3

4

M101

T101

LINE TYPE AND TAG KEY:

NEW WORK BY THIS CONTRACTOR (WIDE LINE)
NEW
----- EXISTING TO BE REMOVED (SHORT DASHED PATTERN)
--- NEW UNDERFLOOR OR UNDERGROUND (LONG DASHED PATTERN)

EXISTING TO REMAIN OR WORK BY OTHERS (NARROW LINE)
EXISTING
----- EXISTING TO BE REMOVED BY OTHERS (SHORT DASHED PATTERN)
--- EXISTING UNDERFLOOR OR UNDERGROUND (LONG DASHED PATTERN)

HALFTONING DOES NOT MODIFY SCOPE.

TAG-E TAGS WITH DASH 'E' INDICATES THE REFERENCED OBJECT IS EXISTING

TAG-1 UNDERLINED TAG INDICATES OBJECT IS IN-SCOPE. IF NEW, ADDITIONAL INFORMATION IS AVAILABLE IN A SCHEDULE, MATERIAL LIST, OR SYMBOL LIST

INDICATES AN EXISTING SYSTEM'S POINT OF CONNECTION/REMOVAL

FIRE / SMOKE BARRIER DESIGNATIONS

FIRE AND SMOKE SEPARATIONS ARE NOT SHOWN ON THESE DOCUMENTS. CONTRACTOR SHALL REVIEW THE ARCHITECTURAL PLANS AND DETERMINE THE LOCATIONS OF ALL FIRE AND SMOKE PARTITIONS, BARRIERS, AND WALLS. THIS INCLUDES FLOOR RATINGS. PRICING SHALL INCLUDE ALL MATERIALS AND LABOR REQUIRED TO MAINTAIN THE RATINGS OF ALL RATED SEPARATIONS, WHETHER SHOWN ON THE ENGINEERING PLANS OR NOT.

APPLICABLE CODES	
CONTRACTOR SHALL COMPLY WITH APPLICABLE CODES AND LOCAL AMENDMENTS INCLUDING, BUT NOT LIMITED TO, THE FOLLOWING:	
ELECTRICAL CODE:	NEC 2020
ENERGY CONSERVATION CODE:	NCECC 2018

CONTRACTOR ABBREVIATION KEY	
ABBR:	DESCRIPTION:
A.C.	ASBESTOS ABATEMENT CONTRACTOR
A.V.C.	AUDIO/VISUAL CONTRACTOR
C.C.	CIVIL CONTRACTOR
C.M.	CONSTRUCTION MANAGER
E.C.	ELECTRICAL CONTRACTOR
F.P.C.	FIRE PROTECTION CONTRACTOR
F.S.C.	FOOD SERVICE CONTRACTOR
G.C.	GENERAL CONTRACTOR
H.C.	HEATING CONTRACTOR
M.C.	MECHANICAL CONTRACTOR
N.C.C.	NURSE CALL CONTRACTOR
P.C.	PLUMBING CONTRACTOR
S.C.	SECURITY CONTRACTOR
T.C.	TECHNOLOGY CONTRACTOR
T.C.C.	TEMPERATURE CONTROLS CONTRACTOR
V.C.	VENTILATION CONTRACTOR

MECHANICAL SYSTEMS, SERVICE SYSTEMS AND EQUIPMENT METHOD OF COMPLIANCE

PREScriptive ☒ ENERGY COST BUDGET ☐

THERMAL ZONE: 3A

EXTERIOR DESIGN CONDITIONS
winter dry bulb: 23F
summer dry bulb: 91°F
relative humidity: 64%

INTERIOR DESIGN CONDITIONS
winter dry bulb: 70°F
summer dry bulb: 75°F
relative humidity: 50%

BUILDING HEATING LOAD: BLOCK LOAD = 49.7 MBH

BUILDING COOLING LOAD: BLOCK LOAD = 234 MBH (19.5 TONS)

MECHANICAL SPACING CONDITIONING SYSTEM
Unitary:
description of unit:
heating efficiency:
cooling efficiency:
heat output of unit:
cooling output of unit:
Boiler:
total boiler capacity: If oversized state reason.
Chiller:
total chiller capacity: If oversized state reason.

LIST EQUIPMENT EFFICIENCIES: SEE SCHEDULES ON SHEET(S)

EQUIPMENT SCHEDULES WITH MOTORS (MECHANICAL SYSTEMS)
motor horsepower:
number of phases:
minimum efficiency:
motor type:
of poles:

DESIGNER STATEMENT
To the best of my knowledge and belief, the design of this building complies with the mechanical systems, service systems and equipment requirements of the North Carolina State Energy Code,

Patrick McCabe
SIGNED: _____

NAME: Pat J McCabe, P.E.

TITLE: Professional Engineer

OUTSIDE AIR SUMMARY

REQUIRED:
SS-1: 110;((0.06*145 SF) + (5*3 PPL)) + 111;((0.06*175 SF) + (5*1 PPL)) + 112;((0.06*208 SF) + (7.5*3 PPL)) = 75 CFM
SS-2: 100;((0.06*431 SF)) + 108;((0.06*125 SF) + (5*1 PPL)) + 107;((0.06*367SF) + (7.5*8 PPL)) + 109;((0.06*495 SF) + (5*32 PPL)) = 311 CFM
SS-3: 134;((0.06*1394 SF) + (7.5*14 PPL)) + 129;((0.06*275 SF) + (7.5*8 PPL)) + 133;((0.12*117 SF)) = 273 CFM
SS-4: 119;((0.06*211 SF) + (5*2 PPL)) + 120;((0.06*212 SF) + (5*1 PPL)) + 121;((0.06*109 SF) + (7.5*8 PPL)) + 122;((0.06*189 SF) + (5*1 PPL)) = 124 CFM
SS-5: 100;((0.06*416 SF)) + 123;((0.06*184 SF) + (5*9 PPL)) + 124;((0.06*125) + 125;((0.06*216) = 122 CFM
SS-6: 213;((0.06*500 SF) + (7.5*10 PPL)) + 217;((0.06*388 SF) + (5*4 PPL)) + 218;((0.06*262 SF) + (5*8 PPL)) + 219;((0.06*140 SF) + 200; (0.06*218 SF) = 226
SS-7: OFFICE;((0.06*946 SF) + (5*6 PPL)) + 200;((0.06*218 SF) = 100 CFM
TOTAL REQUIRED = 1,231 CFM
PROVIDED:
SS-1: 100 CFM
SS-2: 350 CFM
SS-3: 300 CFM
SS-4: 150 CFM
SS-5: 150 CFM
SS-6: 250 CFM
SS-7: 150 CFM
TOTAL PROVIDED = 1,450 CFM

SYMBOL LIST - SENSORS	
SYMBOL	DESCRIPTION
	HUMIDISTAT
	THERMOSTAT
	TIME CLOCK

HVAC SHEET INDEX	
M000	HVAC COVERSHEET - PP, V
M101	FIRST FLOOR PLAN - HVAC
M102	SECOND FLOOR PLAN - HVAC
M201	HVAC DETAILS
M202	HVAC DETAILS
M301	HVAC SCHEDULES
GRAND TOTAL: 6	

SYMBOL LIST - VENTILATION

SYMBOL	DESCRIPTION
SG-1 8/115	AIR TERMINAL PROPERTIES - TAG / NECK SIZE/CFM
	DUCT DOWN, DUCT UP

HVAC ABBREVIATION KEY

ABBR:	DESCRIPTION:
AD	ACCESS DOOR
AFF	ABOVE FINISHED FLOOR
C	COMMON
CO	CLEANOUT
CFSD	CONTROL/FIRE/SMOKE DAMPER
DN	DOWN
DPG (0-2")	DIFFERENTIAL PRESSURE GAUGE (RANGE)
DPS	DIFFERENTIAL PRESSURE SWITCH
EP	ELECTRICAL TO PNEUMATIC VALVE
FD	FIRE DAMPER
FOB	FLAT ON BOTTOM
FOT	FLAT ON TOP
FSD	FIRE/SMOKE DAMPER
MV	MIXING VALVE
N.C.	NORMALLY CLOSED
NIC	NOT IN CONTRACT
N.O.	NORMALLY OPEN
PS	PRESSURE SWITCH
SCCR	SHORT CIRCUIT CURRENT RATING
SD	SMOKE DAMPER
TAB	TERMINAL AIR BOX
TD	TRANSFER DUCT
TYP	TYPICAL
UC-1	DOOR UNDERCUT BY OTHERS (1" TYPICAL)
UON	UNLESS OTHERWISE NOTED

VENTILATION GENERAL NOTES:

1. UNLESS NOTED OTHERWISE, THE SIZE OF EACH BRANCH DUCT TO AN AIR TERMINAL (E.G. GRILLE, REGISTER, DIFFUSER), SHALL MATCH THE INLET SIZE.
2. UNLESS NOTED OTHERWISE, DUCT SIZES SHOWN ON DRAWINGS ARE INSIDE CLEAR DIMENSIONS. MAINTAIN CLEAR DIMENSIONS INSIDE ANY LINING
3. ALIGN TEMPERATURE SENSORS WITH LIGHT SWITCHES WHEN IN CLOSE PROXIMITY TO EACH OTHER.
4. PROVIDE ACCESS DOORS AT ALL DUCT MOUNTED EQUIPMENT.
5. EXISTING AIR INLET AND OUTLET CFM SHOWN ON DRAWINGS ARE FROM EXISTING DRAWINGS, AND ARE FOR REFERENCE ONLY. CONTRACTOR SHALL USE PRE-BALANCE VALUES, AND NOT EXISTING CFM SHOWN ON DRAWINGS.
6. CONTRACTOR MAY REUSE PORTIONS OF EXISTING DUCT PROVIDED SIZES AND PRESSURE CLASSES ARE CORRECT, DUCT IS THOROUGHLY CLEANED AND FREE OF DEFECTS, AND ALL TRANSVERSE JOINTS, LONGITUDINAL SEAMS, AND DUCT WALL PENETRATIONS ARE SEALED AS SPECIFIED FOR NEW DUCTWORK.

MECHANICAL RENOVATION NOTES:

THESE NOTES APPLY TO ALL MECHANICAL SHEETS AND TRADES, INCLUDING BUT NOT LIMITED TO, FIRE PROTECTION, PLUMBING, MEDICAL GAS, VENTILATION, PIPING AND TEMPERATURE CONTROL.
1. EXISTING CONDITIONS ARE SHOWN BASED ON INFORMATION OBTAINED FROM FIELD SURVEYS, EXISTING BUILDING DOCUMENTS, AND STAFF. VERIFY EXISTING CONDITIONS AND REPORT ANY CONFLICTS BEFORE PROCEEDING.
2. NOT ALL EXISTING DUCTWORK AND PIPING IS SHOWN. VERIFY EXISTING CONDITIONS BEFORE STARTING WORK. NOTIFY ENGINEER OF ANY CONFLICTS WITH NEW WORK.
3. FIELD VERIFY THE AVAILABLE CLEARANCES FOR DUCTWORK AND PIPING BEFORE FABRICATION. RISES AND DROPS MAY BE NECESSARY BECAUSE OF EXISTING FIELD CONDITIONS.
4. EACH CONTRACTOR SHALL FIELD VERIFY ACCESSIBILITY TO THE AREA OF THEIR WORK AND SHALL NOTIFY THE GENERAL CONTRACTOR PRIOR TO BIDDING IF OTHER UTILITIES ARE REQUIRED TO BE REMOVED OR RELOCATED TO ALLOW ACCESS TO THEIR AREA OF WORK.
5. THE GENERAL CONTRACTOR IS RESPONSIBLE FOR CUTTING, REMOVAL AND PATCHING OF ROOFS, WALLS, AND FLOORS ASSOCIATED WITH WORK BY ALL CONTRACTORS. CONTRACTORS SHALL NOTIFY THE GC OF AFFECTED AREAS PRIOR TO BIDDING EACH CONTRACTOR SHALL CUT AND PATCH ROOFS, WALLS, AND FLOORS ASSOCIATED WITH THEIR WORK.
6. WHERE EXISTING MECHANICAL SYSTEMS DIFFER FROM THOSE SHOWN ON THE PROJECT DRAWINGS AND CREATE CONFLICTS WITH NEW EQUIPMENT, PIPING, OR DUCTWORK INSTALLATIONS, THE CONTRACTOR SHALL PROVIDE DETAILED DOCUMENTATION (SUCH AS SKETCHES, PHOTOS, AND DIMENSIONS) ALONG WITH RECOMMENDATIONS TO RESOLVE THE CONFLICT. THIS INFORMATION MUST BE SUBMITTED TO THE ENGINEER FOR REVIEW AND APPROVAL. NO WORK RELATED TO THE CONFLICT SHALL PROCEED UNTIL AN APPROVED RESOLUTION IS PROVIDED BY THE ENGINEER.
7. PROVIDE TEMPORARY CONNECTIONS TO MAINTAIN EXISTING SYSTEMS IN SERVICE DURING CONSTRUCTION. MAINTAIN ACCESS TO EXISTING MECHANICAL INSTALLATIONS THAT REMAIN ACTIVE.
8. OBTAIN PERMISSION FROM OWNER BEFORE SHUTTING DOWN ANY SYSTEM FOR ANY REASON. MAINTAIN SERVICE TO ALL COMPONENTS THAT ARE TO REMAIN UNTIL NEW SYSTEMS ARE INSTALLED.
9. MAINTAIN EXISTING SYSTEM IN SERVICE UNTIL NEW SYSTEM IS COMPLETE AND READY FOR TIE IN AND SWITCHOVER. DRAIN SYSTEM ONLY TO MAKE SWITCHOVERS AND CONNECTIONS. OBTAIN PERMISSION FROM OWNER BEFORE PARTIALLY OR COMPLETELY DRAINING SYSTEM. MAKE CHANGEOVER TO NEW SYSTEMS WITH MINIMUM OUTAGE.
10. DISCONNECT AND REMOVE MECHANICAL DEVICES AND EQUIPMENT SERVING EQUIPMENT THAT HAS BEEN REMOVED.
11. PROPERLY RECLAIM AND DISPOSE OF ALL REFRIGERANT IN REMOVED EQUIPMENT/ REFRIGERANT PIPING. RECLAIMED REFRIGERANT SHALL HAVE DOCUMENTATION AS REQUIRED BY THE AUTHORITY HAVING JURISDICTION (AHJ).

MECHANICAL GENERAL NOTES:

THESE NOTES APPLY TO ALL MECHANICAL SHEETS AND TRADES, INCLUDING BUT NOT LIMITED TO, FIRE PROTECTION, PLUMBING, MEDICAL GAS, VENTILATION, PIPING AND TEMPERATURE CONTROL.
1. DRAWINGS SHOWING LOCATIONS OF EQUIPMENT, DUCTWORK, PIPING, ETC. ARE DIAGRAMMATIC AND MAY NOT ALWAYS REFLECT EXACT INSTALLATION CONDITIONS. DRAWINGS SHOW THE GENERAL ARRANGEMENT OF DUCTWORK, PIPING, EQUIPMENT, ETC., AND MAY NOT INCLUDE ALL OFFSETS AND FITTINGS REQUIRED FOR COMPLETE INSTALLATION. THE DRAWINGS SHALL BE FOLLOWED AS CLOSELY AS ACTUAL BUILDING CONSTRUCTION AND THE WORK OF OTHERS WILL PERMIT.
2. CATALOG AND MODEL NUMBERS SHALL NOT BE CONSIDERED COMPLETE, BUT ARE GIVEN AS AN AID TO THE CONTRACTOR AND TO INDICATE THE QUALITY REQUIRED. CONTRACTOR IS RESPONSIBLE FOR THE COMPLETE DESCRIPTION OF MATERIAL SCHEDULED ON THESE DRAWINGS AND IN THE SPECIFICATIONS BEFORE ORDERING. THE DESCRIPTION OF THE MATERIAL AND SCHEDULED PERFORMANCE TAKES PRECEDENCE OVER THE MODEL NUMBER. THE FIRST MANUFACTURER SCHEDULED IS THE BASIS OF DESIGN.
3. DETERMINATION OF QUANTITIES OF MATERIAL AND EQUIPMENT REQUIRED SHALL BE MADE BY THE CONTRACTOR FROM THE DOCUMENTS, WHERE MATERIAL AND/OR QUANTITY DISCREPANCIES ARISE BETWEEN DRAWINGS, SCHEDULES AND/OR SPECIFICATIONS, THE HIGHER QUALITY/ GREATER NUMBER SHALL GOVERN.
4. DO NOT SCALE DRAWINGS. VERIFY ALL DIMENSIONS AND CLEARANCES FROM ARCHITECTURAL, STRUCTURAL, SUBMITTALS, AND OTHER APPROPRIATE DRAWINGS OR PHYSICALLY AT SITE. REVIEW ALL DRAWINGS, INCLUDING THOSE OF OTHER TRADES.
5. COORDINATE ALL WORK WITH ALL OTHER TRADES PRIOR TO INSTALLATION TO PROVIDE CLEARANCES REQUIRED FOR OPERATION, MAINTENANCE, CODE COMPLIANCE, AND TO VERIFY NON-INTERFERENCE WITH OTHER WORK. DO NOT FABRICATE PRIOR TO VERIFICATION OF NECESSARY CLEARANCES FOR ALL TRADES. BRING ANY INTERFERENCES OR CONFLICTS TO THE ATTENTION OF THE ARCHITECT/ENGINEER BEFORE PROCEEDING WITH FABRICATION OR EQUIPMENT ORDERS.
6. REVIEW SPACE REQUIREMENTS OF EQUIPMENT SPECIFIED OR SUBSTITUTED AND MAKE REASONABLE ACCOMMODATIONS IN LAYOUT AND POSITIONING TO PROVIDE PROPER ACCESS.
7. ANY CHANGES REQUIRED TO ELIMINATE CONFLICTS OR THAT RESULT FROM A FAILURE TO COORDINATE SHALL BE MADE BY THE CONTRACTOR WITHOUT ADDITIONAL COST OR EXPENSE TO OTHERS.
8. EACH CONTRACTOR IS RESPONSIBLE FOR ALL COSTS ASSOCIATED WITH ELECTRICAL CHANGES REQUIRED FOR EQUIPMENT PROPOSED THAT DIFFERS FROM THE BASIS OF DESIGN.
9. REFER TO ARCHITECTURAL REFLECTED CEILING PLAN, ELECTRICAL, TECHNOLOGY AUDIO/VISUAL, AND OTHER MECHANICAL PLANS FOR EXACT LOCATIONS OF ALL CEILING MOUNTED DEVICES, OTHER THAN SPRINKLERS.
10. EACH CONTRACTOR IS RESPONSIBLE FOR DAMAGE CAUSED BY THEIR ACTIONS TO WALLS, FLOORS, CEILINGS, AND ROOFS. THE CONTRACTOR WHOSE WORK CAUSES DAMAGE IS RESPONSIBLE FOR PATCHING TO MATCH ORIGINAL CONSTRUCTION, FIRE RATING, AND FINISH.
11. IN AREAS WITH DRYWALL CEILINGS COORDINATE LOCATIONS OF ACCESS PANELS WITH THE GC FOR ACCESS TO VALVES, DUCTWORK ACCESSORIES, DAMPERS, ETC. COORDINATE PANEL TYPE AND COLOR WITH ARCHITECT. NOTIFY THE GC OF THE REQUIRED ACCESS PANELS PRIOR TO BIDDING.
12. SEAL ALL FLOOR, WALL, AND ROOF PENETRATIONS AIRTIGHT WHERE CONDUITS, PIPING, AND DUCTS PENETRATE. PENETRATIONS THROUGH EXTERIOR WALLS AND ROOF SHALL BE SEALED AIRTIGHT WITH WATERPROOFING MATERIALS RECOMMENDED BY MANUFACTURER FOR OUTDOOR USE.
13. CAULK ALL PIPE AND DUCT PENETRATIONS OF FULL HEIGHT NON-FIRE RATED WALL, PARTITION, FLOOR, AND ROOF ASSEMBLIES. THIS IS ESSENTIAL TO PREVENT NOISE TRANSMISSION FROM ONE ROOM TO ANOTHER AND TO PROVIDE THE DESIRED NC LEVELS WITHIN ROOMS.
14. WHERE PIPES AND DUCTS ARE SHOWN TO PENETRATE FLOORS, PROVIDE SLEEVED OPENINGS WITH THE TOP EDGE RAISED ABOVE FLOOR SURFACE IN ACCORDANCE WITH ALL RELEVANT SPEC SECTIONS. SEAL SLEEVE PERIMETER TO BE WATERTIGHT.
15. EQUIPMENT SIZES AND SERVICE CLEARANCE REQUIREMENTS VARY AMONG DIFFERENT MANUFACTURERS. CONSULT APPROVED SHOP DRAWINGS FOR EQUIPMENT SIZES AND REQUIRED SERVICE CLEARANCES. COORDINATE WITH LAYOUT OF EQUIPMENT PADS, PIPING, DUCTWORK, ETC.
16. DO NOT BLOCK TUBE PULL OR EQUIPMENT SERVICE CLEARANCES.
17. MAINTAIN A MINIMUM WORKING CLEARANCE OF 3'-6" IN FRONT OF ALL ELECTRICAL EQUIPMENT REQUIRING MAINTENANCE, INSPECTION, AND TESTING INCLUDING BUT NOT LIMITED TO PANELS, DISTRIBUTION PANELS, SWITCHBOARDS, MOTOR CONTROL CENTERS, TRANSFORMERS, EQUIPMENT DISCONNECTS AND STARTERS.
18. MAINTAIN THE DEDICATED ELECTRICAL EQUIPMENT SPACE DEFINED BY THE WIDTH / DEPTH OF ELECTRICAL EQUIPMENT MEASURED FROM THE FLOOR TO A HEIGHT 6'-0" ABOVE THE EQUIPMENT OR THE STRUCTURAL CEILING, WHICHEVER IS LOWER. SYSTEMS FOREIGN TO THE ELECTRICAL DISTRIBUTION SYSTEM ARE NOT ALLOWED IN THE DEDICATED ELECTRICAL SPACE INCLUDING: DUCTWORK, PIPING, ETC.
19. PROVIDE CONCRETE EQUIPMENT PADS FOR ALL FLOOR-MOUNTED EQUIPMENT. PADS SHALL EXTEND A MINIMUM OF 6 INCHES BEYOND ALL SIDES OF EQUIPMENT, UNLESS SUCH EXTENSION WOULD ENCROACH ON REQUIRED WORKING CLEARANCES AT CONTROL PANELS OR ELECTRICAL EQUIPMENT. PROVIDE 1/2-INCH CHAMFER (45-DEGREE) OR 1/2-INCH RADIUS AT ALL HORIZONTAL EDGES.
20. DO NOT EXCEED 25 LBS PER HANGER AND A MINIMUM SPACING OF 2'-0" ON CENTER WHEN ATTACHING TO METAL ROOF DECKING (LIMITATION NOT REQUIRED WITH CONCRETE ON METAL DECK). THIS 25 LBS. LOAD AND 2'-0" SPACING INCLUDE ADJACENT ELECTRICAL AND ARCHITECTURAL ITEMS HANGING FROM DECK. IF THE HANGER RESTRICTIONS CANNOT BE ACHIEVED, SUPPLEMENTAL FRAMING OF STEEL FRAMING SHALL BE ADDED. ANCHORS EMBEDDED IN CONCRETE SHALL BE CRACKED CONCRETE APPROVED IN ACCORDANCE WITH SPECIFICATIONS.

MECHANICAL DEMOLITION GENERAL NOTE:

MECHANICAL CONTRACTOR SHALL DEMOLISH ALL EXISTING MECHANICAL EQUIPMENT AND ALL ASSOCIATED DUCTWORK, AIR DISTRIBUTION, CONTROLS, ETC. CONTRACTOR SHALL PATCH ALL EXISTING PENETRATIONS THRU ROOF / WALLS AS REQUIRED.

IMEG

www.imegcorp.com

IMEG RESERVES PROPRIETARY RIGHTS, INCLUDING COPYRIGHTS, TO THIS DRAWING AND THE DATA SHOWN THEREON. SAID DRAWING AND/OR DATA ARE THE EXCLUSIVE PROPERTY OF IMEG AND SHALL NOT BE USED OR REPRODUCED FOR ANY OTHER PROJECT WITHOUT THE EXPRESS WRITTEN APPROVAL AND PARTICIPATION OF IMEG.
©2026 IMEG CONSULTANTS CORP.
North Carolina Design Registration #E-1507

3221 BLUE RIDGE ROAD
SUITE 113
RALEIGH, NC 27612
P. 919.971.1111

0 1 2 3

REF. SCALE IN INCHES PROJECT #26001727.00

OAKLEY COLLIER ARCHITECTS

OCA

109 Candlewood Road, Rocky Mount, NC 27804 (P) 252.937.2500
205 W. Martin Street, Raleigh, NC 27601

RENOVATION FOR:

CRAVEN COUNTY GOVERNMENT CENTER EAST

CRAVEN COUNTY
1208 E. MAIN STREET, HAVELock, NORTH CAROLINA 28532

GENERAL NOTE:
Prior to construction start, Contractor shall verify & be responsible for all Dimensions.


Revisions
Description Date

Date: 05-28-26 Project No: 26001727.00
Drawn By: PJM Sheet No:
Checked By: GWD M000
Sheet Title:
HVAC COVERSHEET - PP, V

5/29/26

Copyright © 2025 Oakley Collier Architects. These drawings are of the property of the Architect for use under his supervision. No reproduction or other use is allowed without permission.

1 FIRST FLOOR PLAN - HVAC
1/8" = 1'-0"

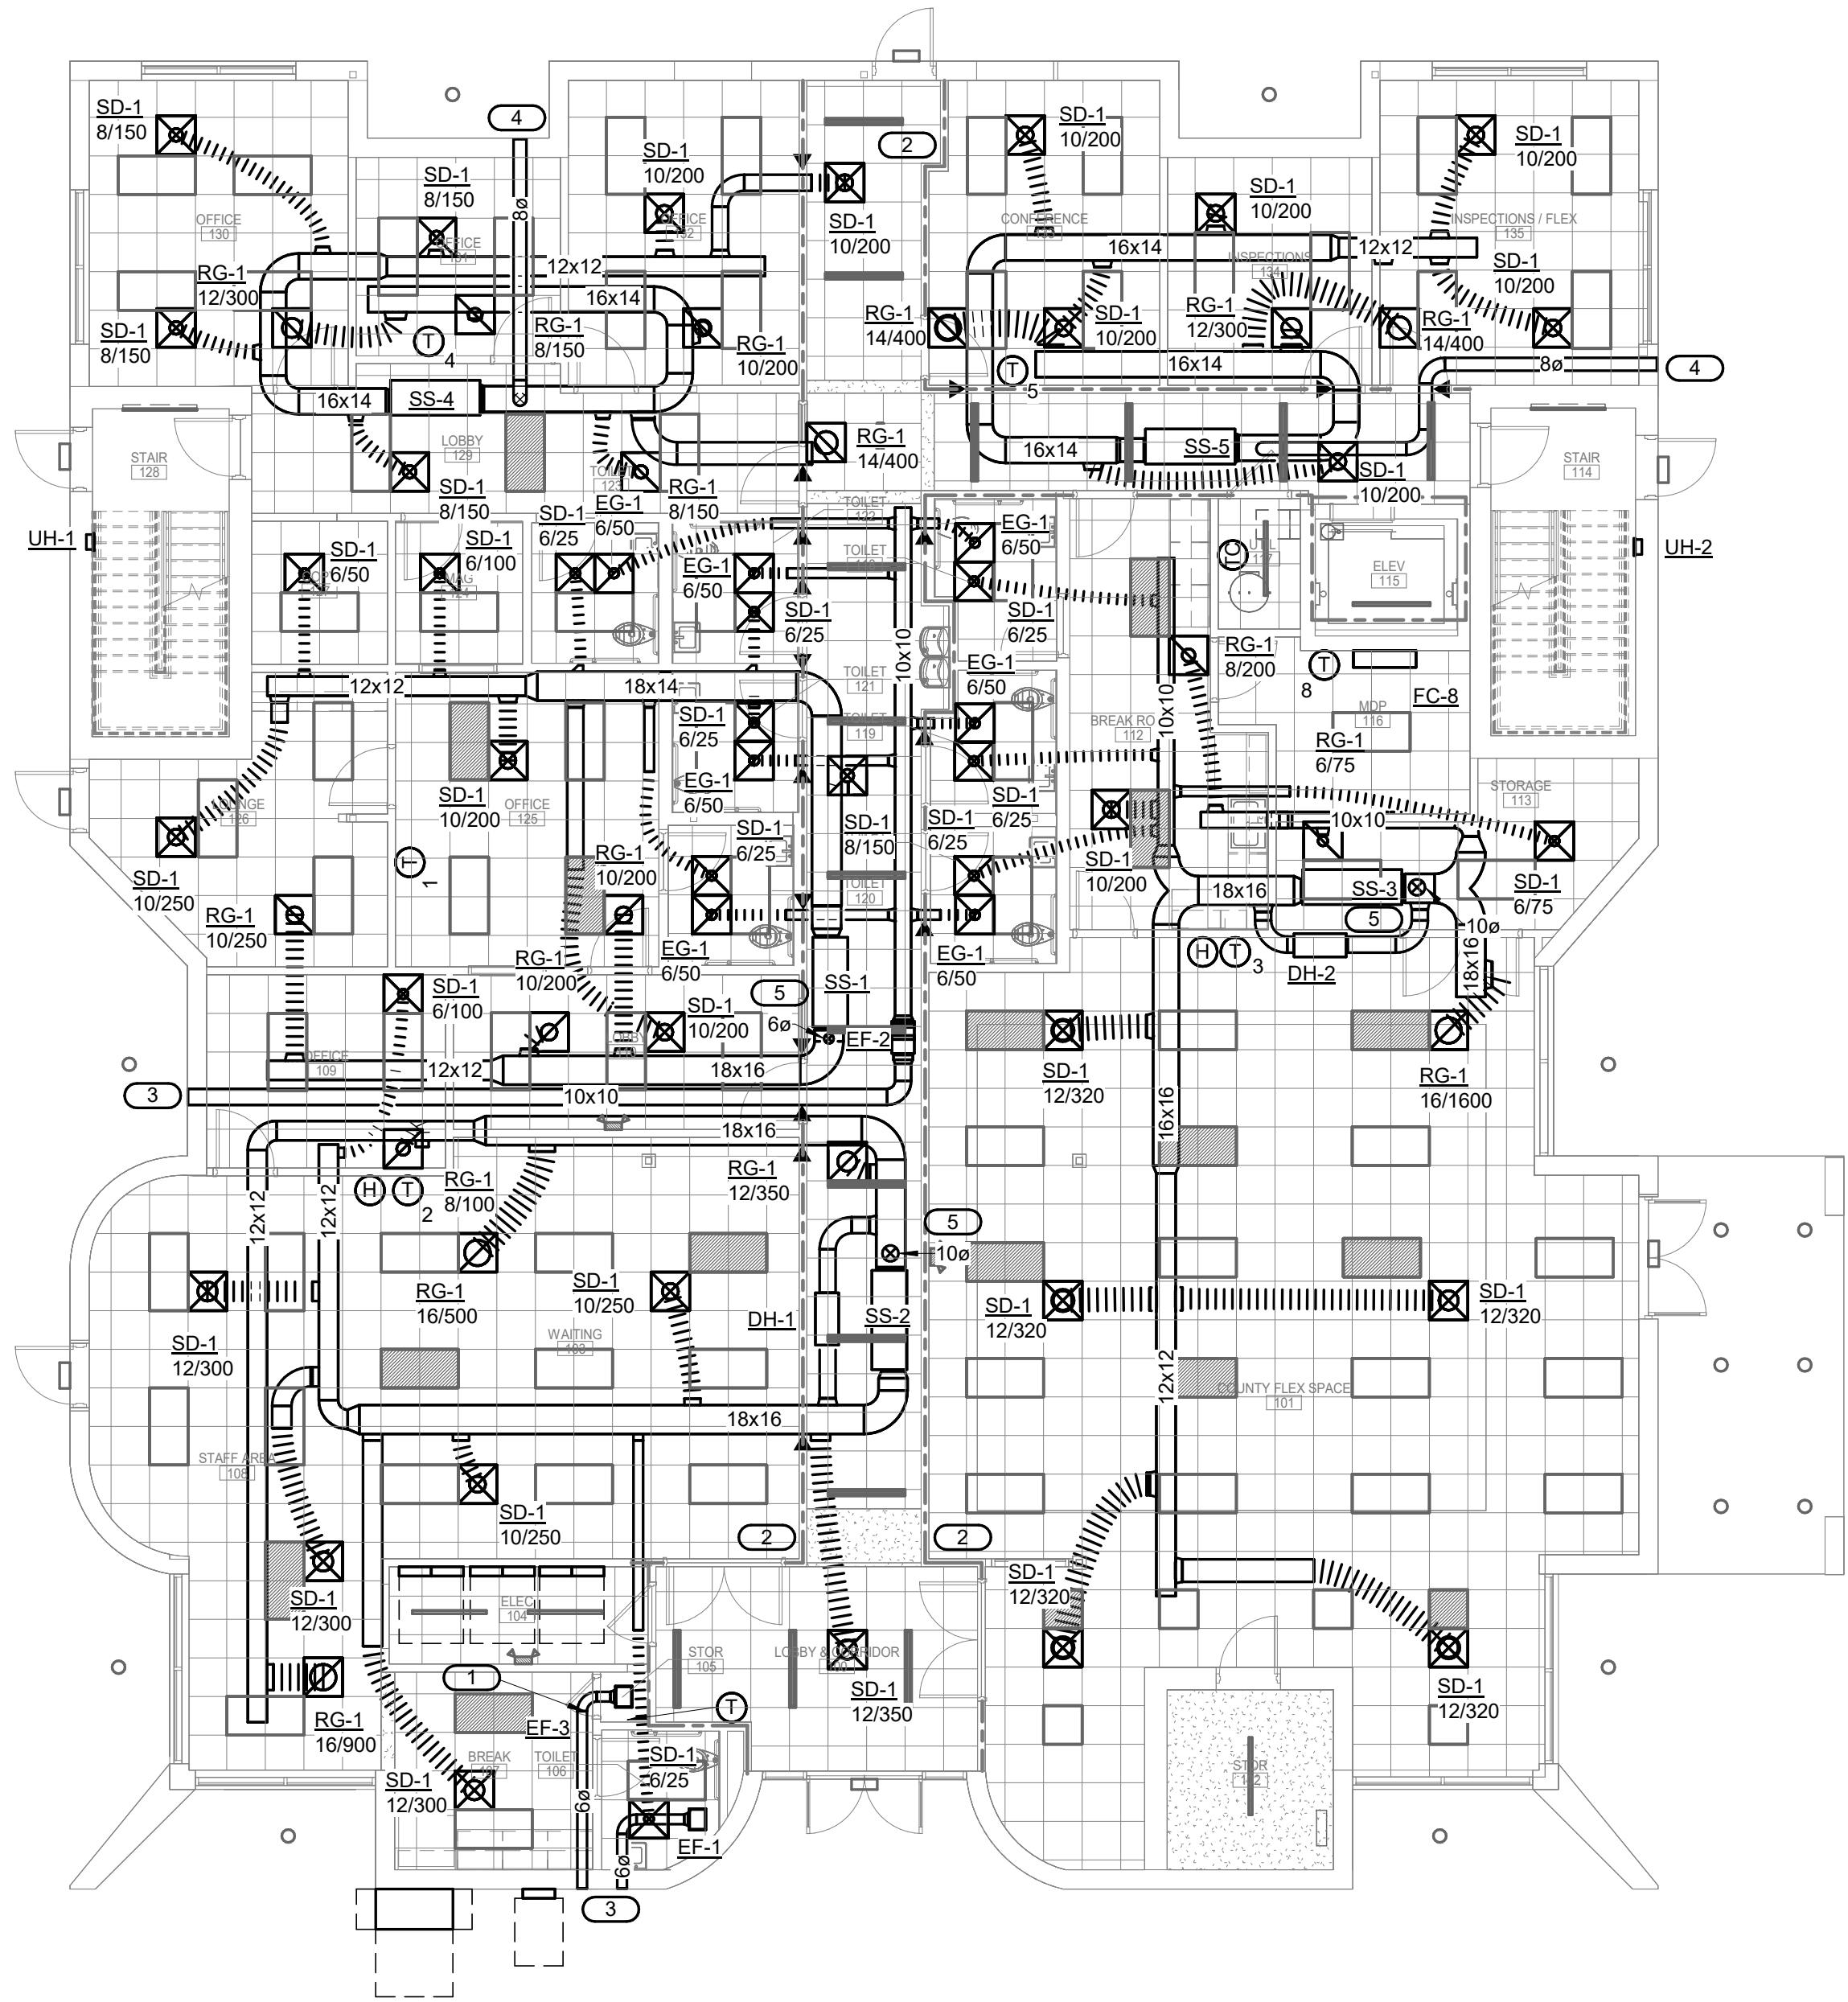

- KEYNOTE: #
1. PROVIDE LOUVERED DOOR.
 2. 1-HR RATED WALL, TYPICAL.
 3. TERMINATE EXHAUST WITH WALL CAP.
 4. TERMINATE OUTSIDE AIR WITH WALL CAP.
 5. OUTSIDE AIR DUCT TO ROOF CAP. SEE SIZE ON DOCUMENT.

IMEG
www.imegcorp.com
3221 BLUE RIDGE ROAD
SUITE 113
RALEIGH, NC 27612
P. 919.971.1111



IMEG RESERVES PROPRIETARY RIGHTS, INCLUDING COPYRIGHTS, TO THIS DRAWING AND THE DATA SHOWN THEREON. SAID DRAWING AND/OR DATA ARE THE EXCLUSIVE PROPERTY OF IMEG AND SHALL NOT BE USED OR REPRODUCED FOR ANY OTHER PROJECT WITHOUT THE EXPRESS WRITTEN APPROVAL AND PARTICIPATION OF IMEG.
©2026 IMEG CONSULTANTS CORP.
North Carolina Design Registration #F-1507

0 1 2 3
REF. SCALE IN INCHES PROJECT #26001727.00

RENOVATION FOR:

CRAVEN COUNTY GOVERNMENT CENTER
EAST

CRAVEN COUNTY
1208 E. MAIN STREET, HAVELOCK, NORTH CAROLINA 28532

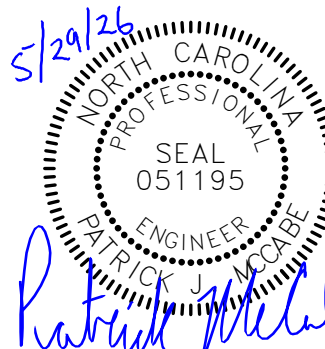
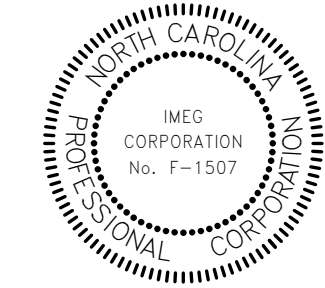


GENERAL NOTE:
Prior to construction start, Contractor shall verify & be responsible for all Dimensions.

Revisions		
#	Description	Date
Date	Project No.	
05-28-26	26001727.00	
Drawn By	Sheet No.	
PJM		
Checked By	M101	
GWD		
Sheet Title		
FIRST FLOOR PLAN - HVAC		

OAKLEY COLLIER ARCHITECTS
OCA
109 Candlewood Road, Rocky Mount, NC 27804 (P) 252.937.2500
205 W. Martin Street, Raleigh, NC 27601

1 SECOND FLOOR PLAN - HVAC
1/8" = 1'-0"

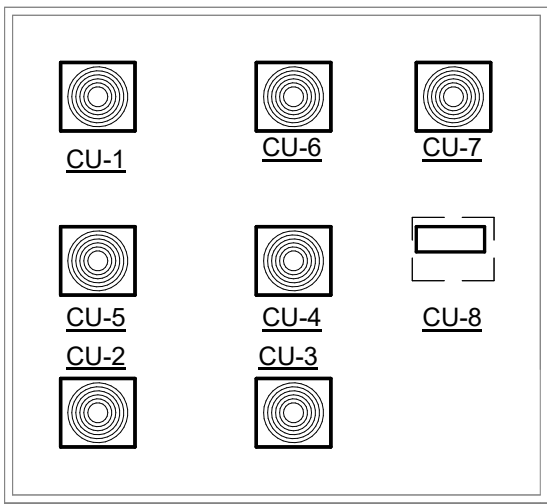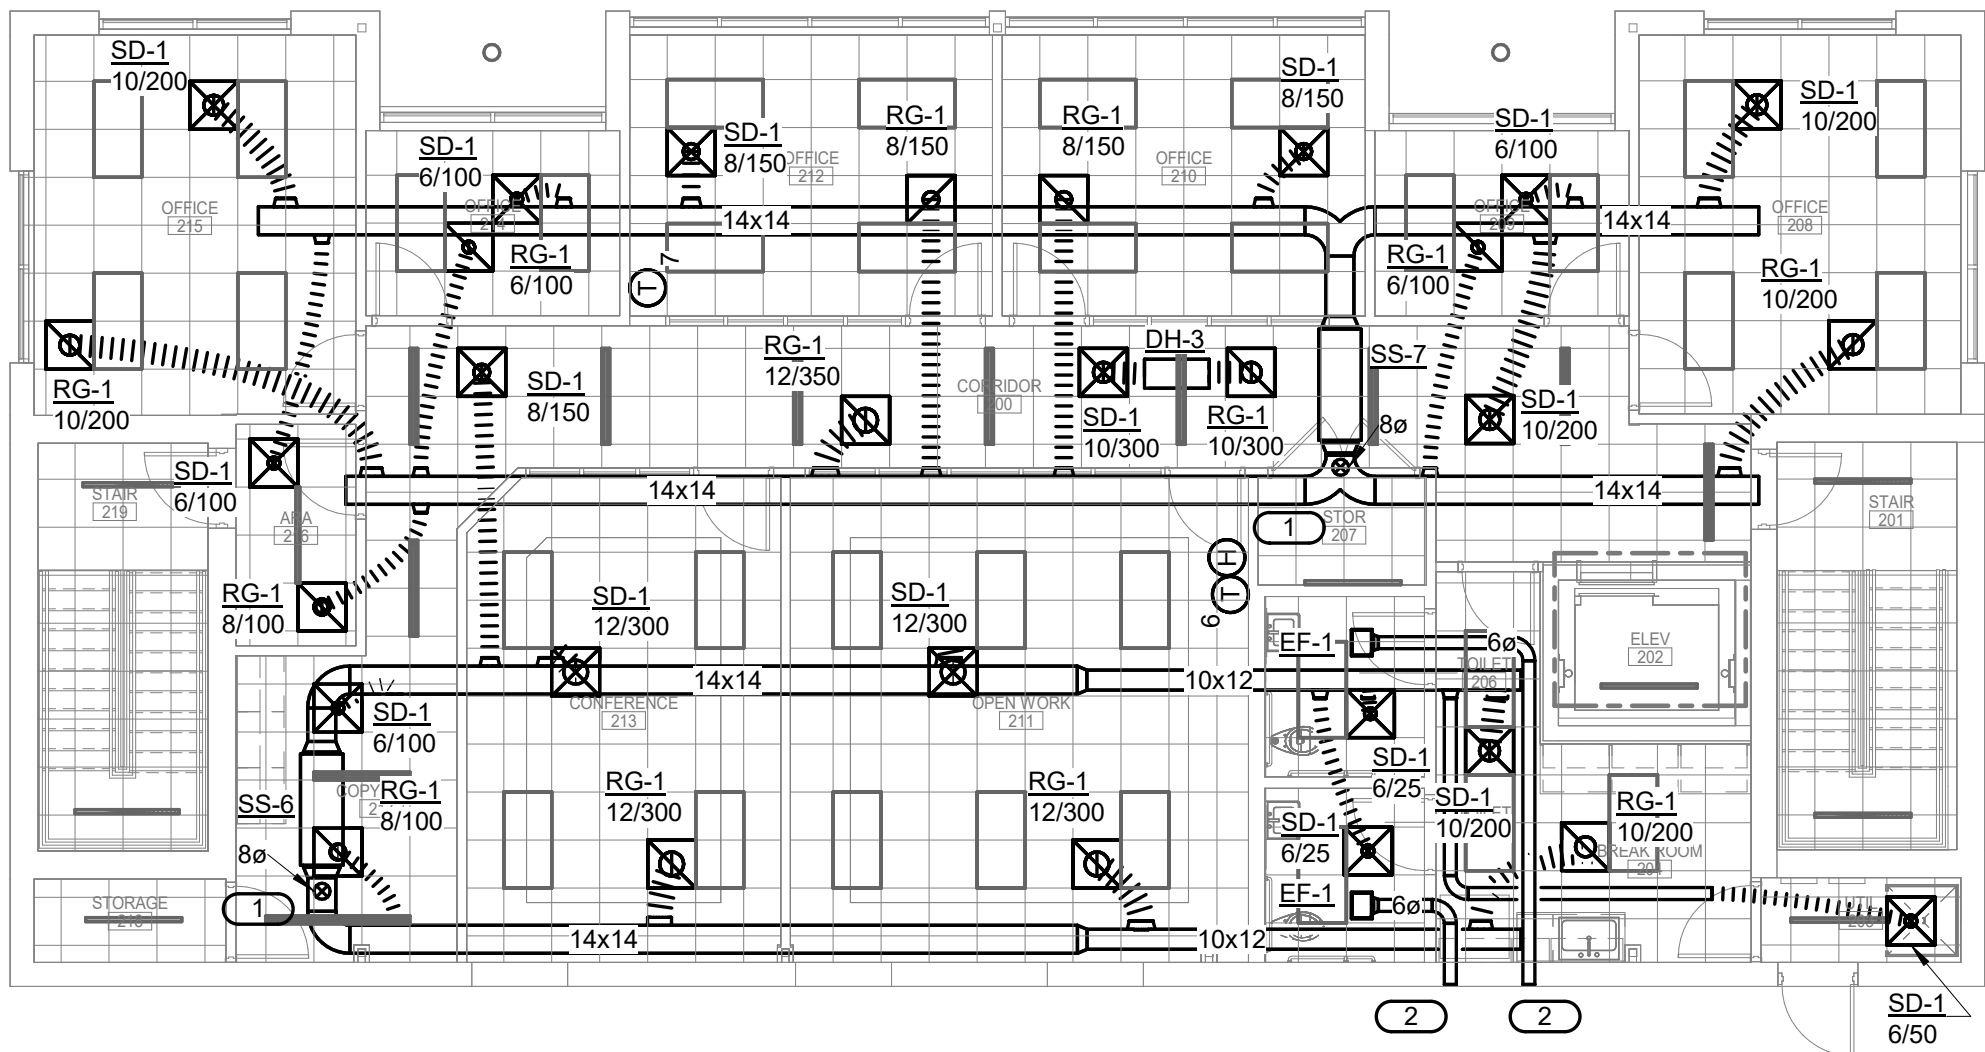

- KEYNOTE: **#**
1. PROVIDE 8"Ø OUTSIDE DUCT UP TO ROOF CAP.
 2. ROUTE 6"Ø EXHAUST DUCT TO EXTERIOR AND TERMINATE WITH WALL CAP.

IMEG
www.imegcorp.com
3221 BLUE RIDGE ROAD
SUITE 113
RALEIGH, NC 27612
P. 919.971.1111



IMEG RESERVES PROPRIETARY RIGHTS, INCLUDING COPYRIGHTS, TO THIS DRAWING AND THE DATA SHOWN THEREON. SAID DRAWING AND/OR DATA ARE THE EXCLUSIVE PROPERTY OF IMEG AND SHALL NOT BE USED OR REPRODUCED FOR ANY OTHER PROJECT WITHOUT THE EXPRESS WRITTEN APPROVAL AND PARTICIPATION OF IMEG.
©2026 IMEG CONSULTANTS CORP.
North Carolina Design Registration #F-1507

0 1 2 3
REF. SCALE IN INCHES PROJECT #26001727.00

RENOVATION FOR:

CRAVEN COUNTY GOVERNMENT CENTER
EAST


CRAVEN COUNTY
1208 E. MAIN STREET, HAVELOCK, NORTH CAROLINA 28532

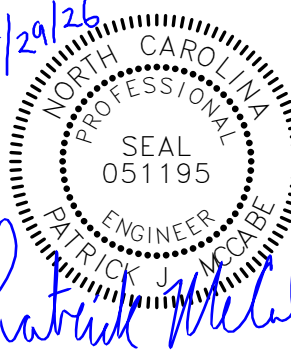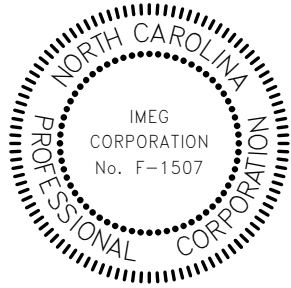


GENERAL NOTE: Prior to construction start. Contractor shall verify & be responsible for all Dimensions.		
Revisions		
#	Description	Date
Date	Project No.	
05-28-26	26001727.00	
Drawn By	Sheet No.	
PJM		
Checked By	M102	
GWD		
Sheet Title		
SECOND FLOOR PLAN - HVAC		

OAKLEY COLLIER ARCHITECTS
OCA
109 Candlewood Road, Rocky Mount, NC 27804 (P) 252.937.2500
205 W. Martin Street, Raleigh, NC 27601


Copyright © 2025 Oakley Collier Architects. These drawings are of the property of the Architect for use under his supervision. No reproduction or other use is allowed without permission.

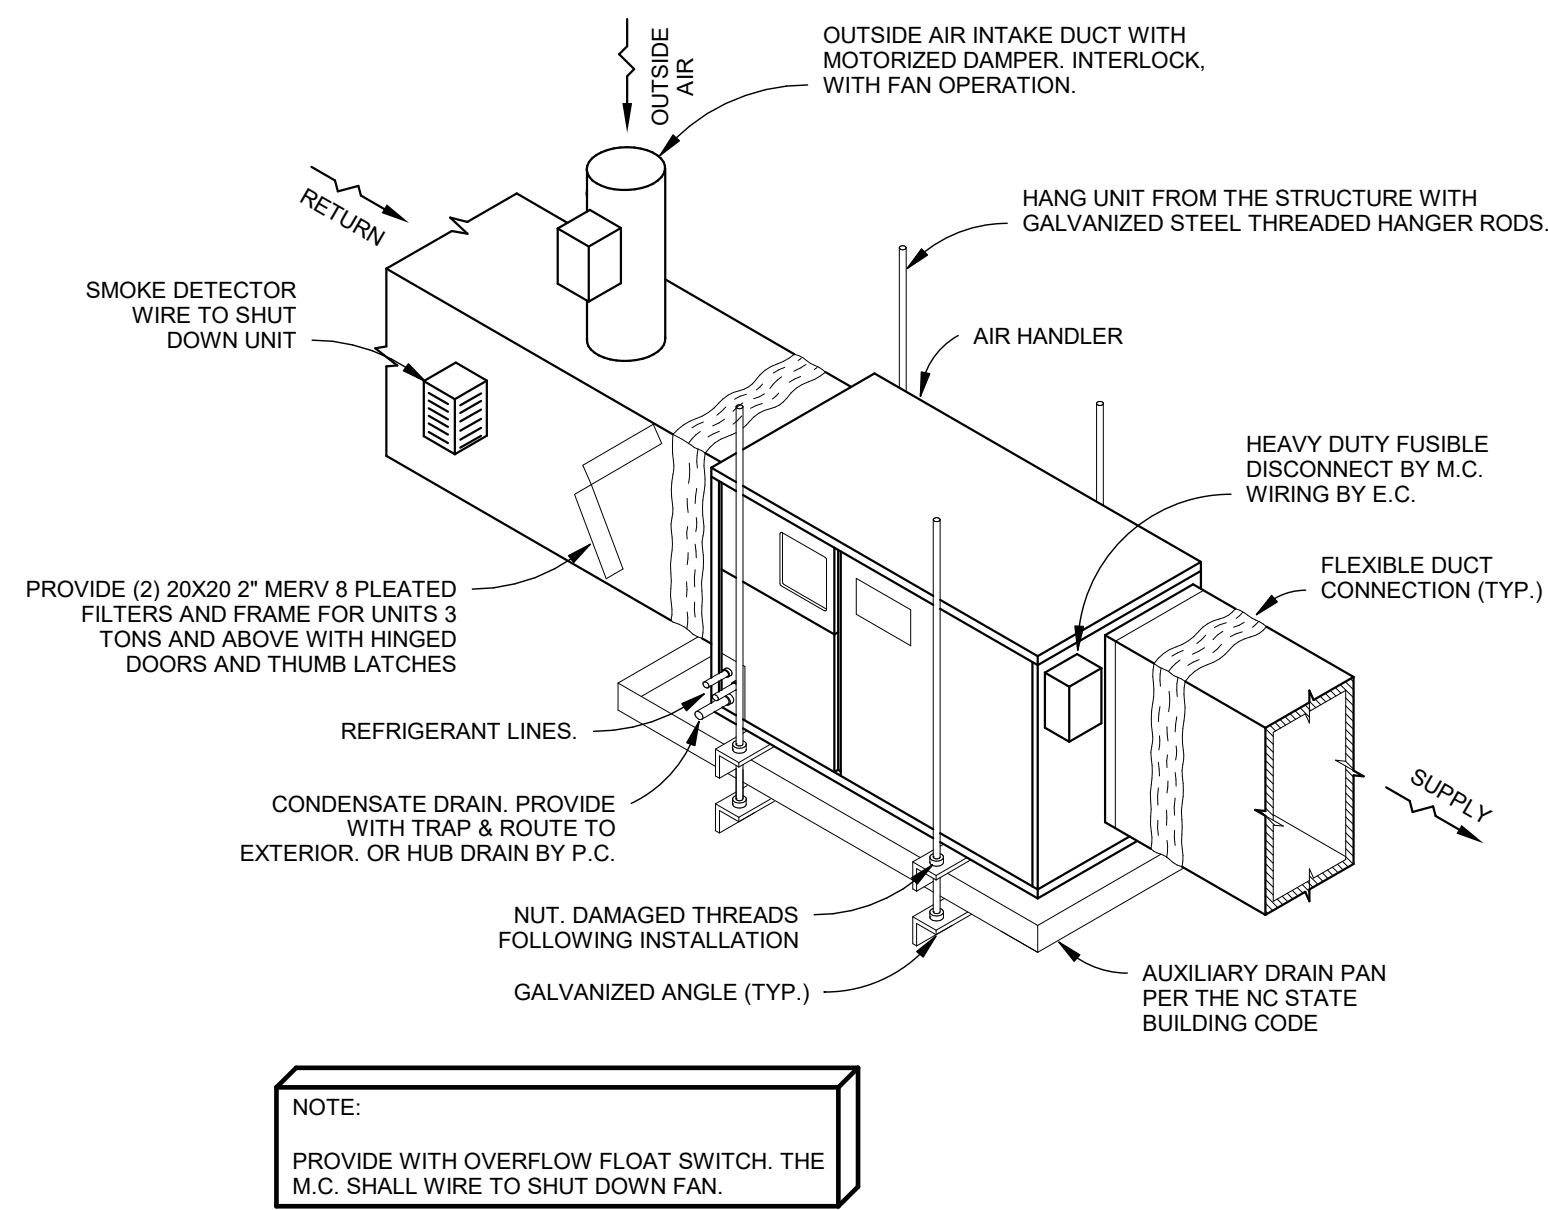

1 HOR SUSPENDED DETAIL
NO SCALE

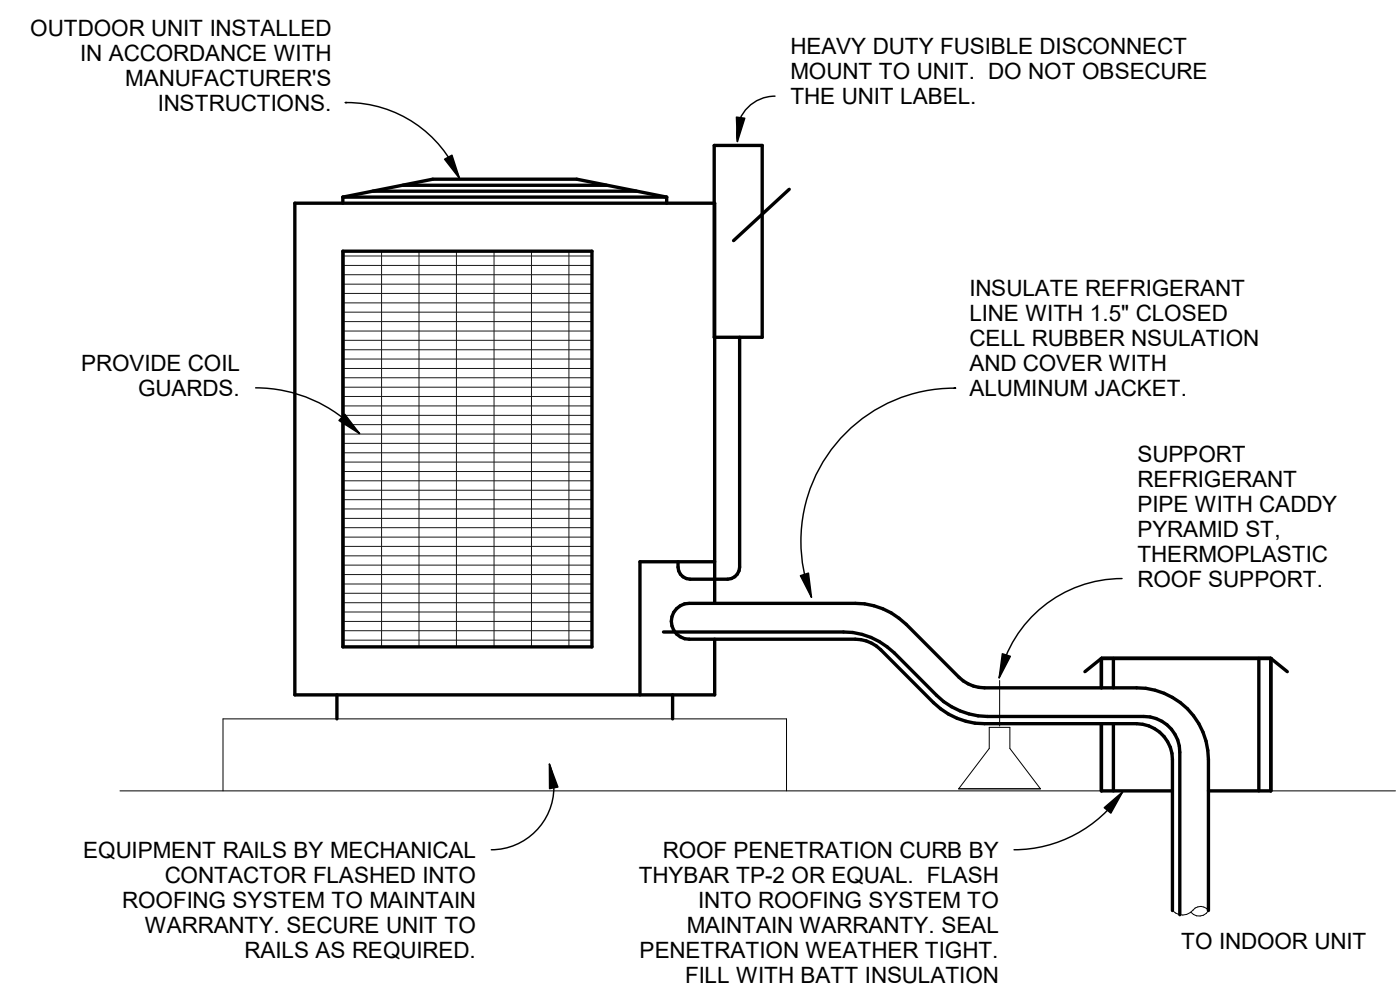


2 ROOF MOUNT DETAIL
NO SCALE

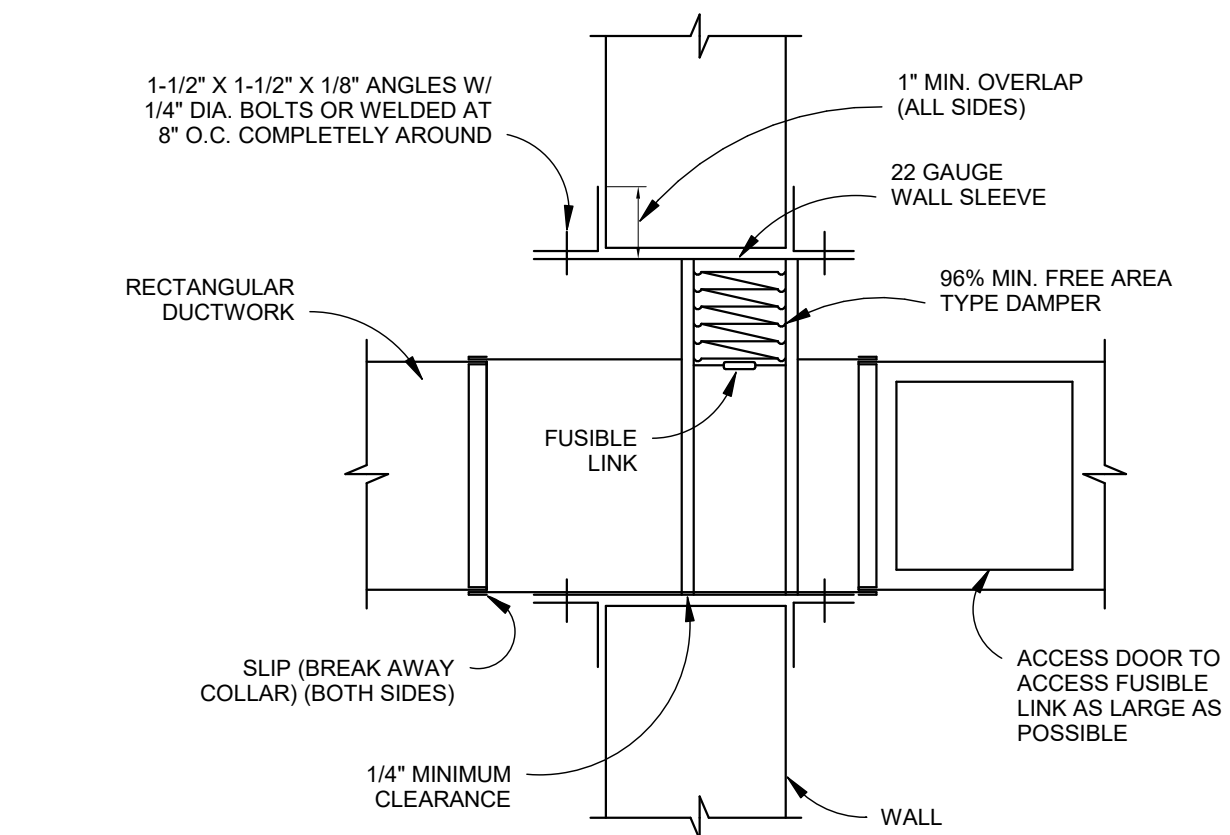


NOTE:
DETAIL FOR REFERENCE ONLY. DAMPERS SHALL BE INSTALLED PER MANUFACTURER'S INSTALLATION INSTRUCTIONS. DO NOT FIRE STOP THE GAP BETWEEN THE FIRE DAMPER SLEEVE AND THE PENETRATION UNLESS SPECIFICALLY CALLED FOR IN THE MANUFACTURER'S INSTALLATION INSTRUCTIONS.


3 FIRE DAMPER DETAIL
NO SCALE

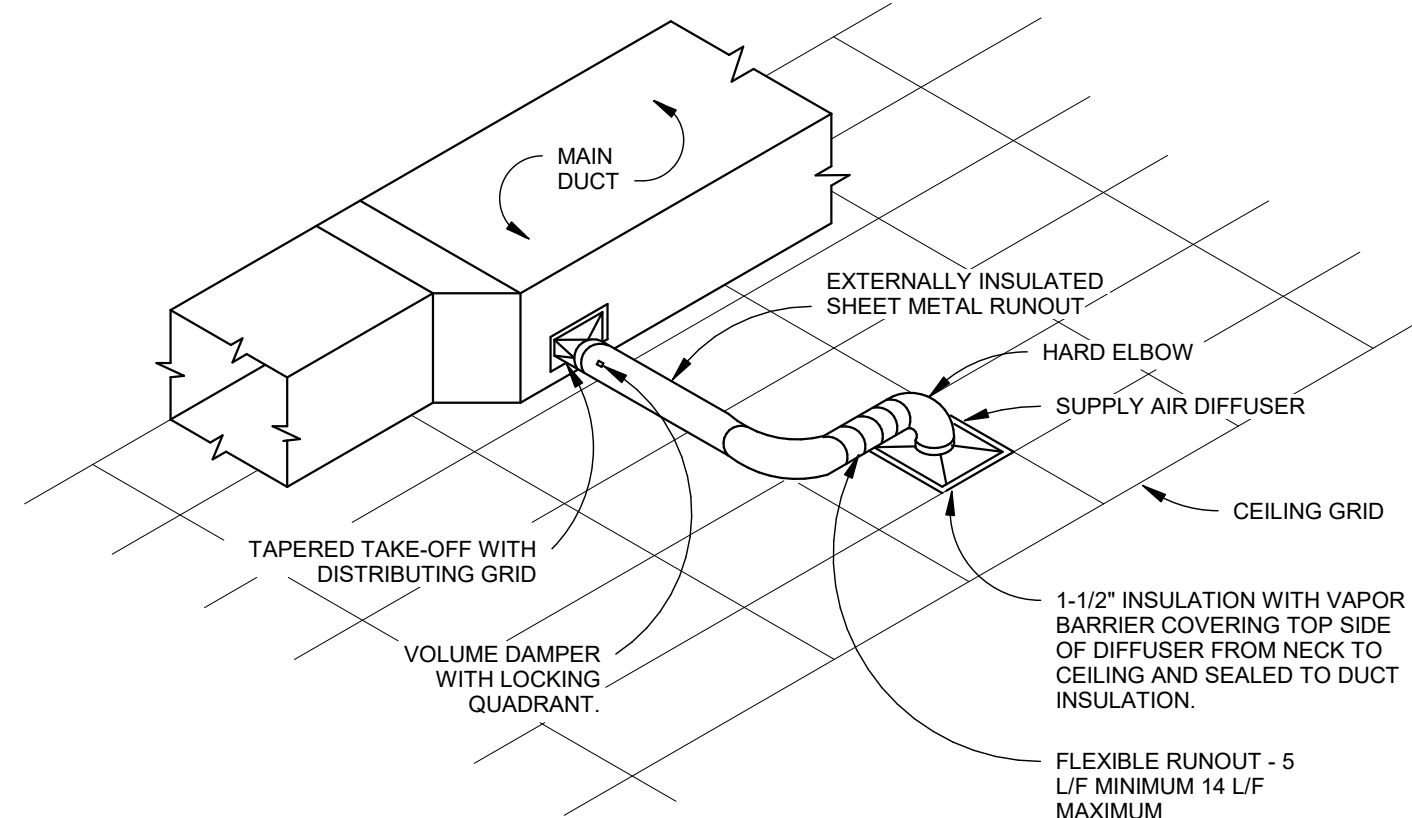


4 LAY-IN SUPPLY DETAIL
NO SCALE

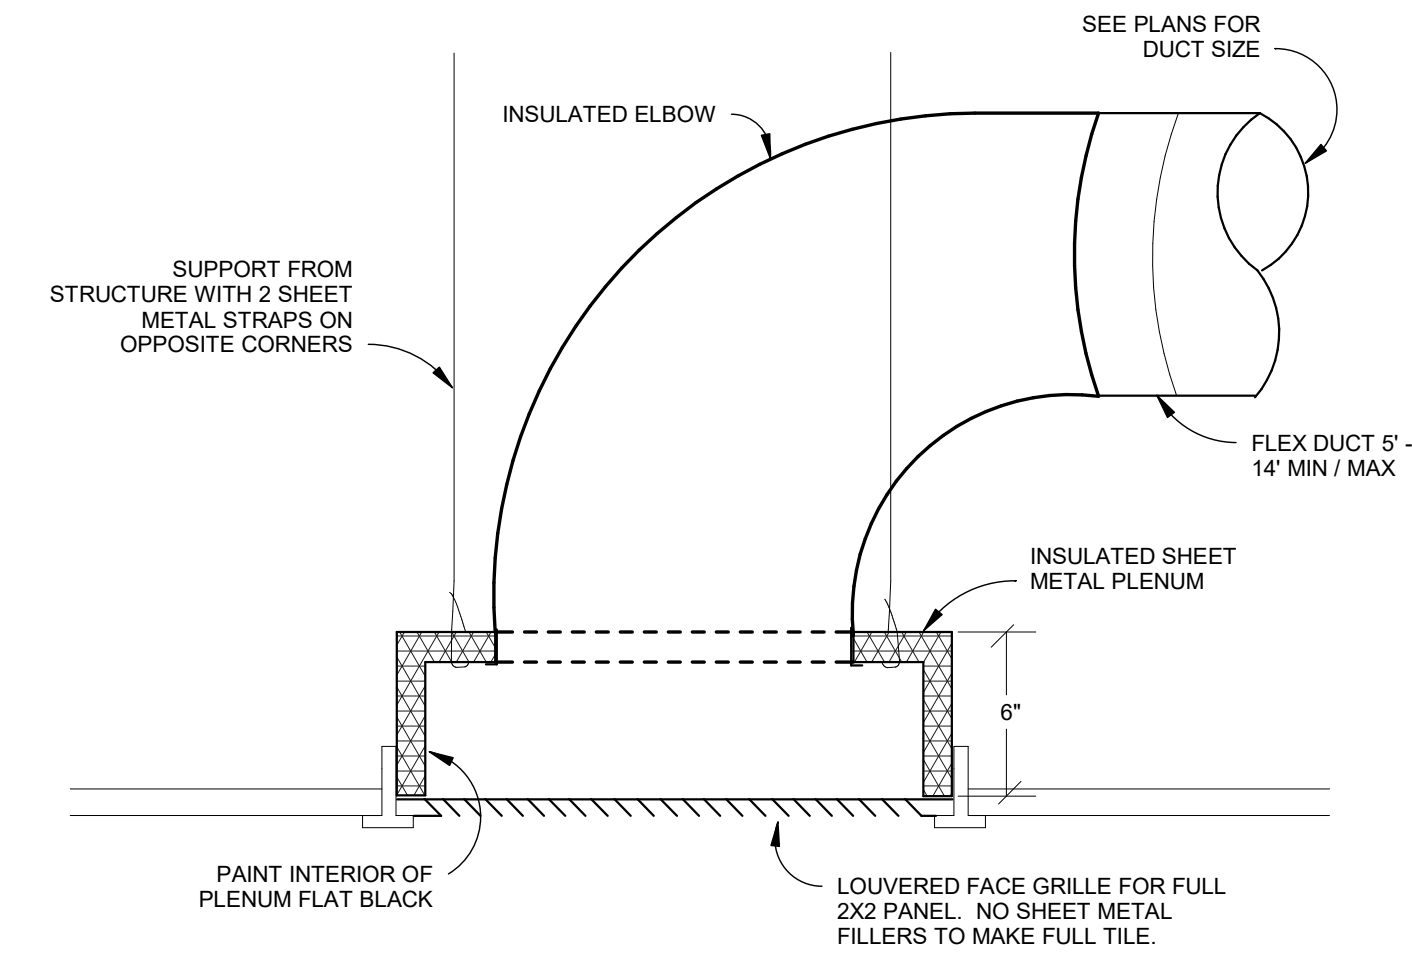


5 LAY IN RETURN DETAIL
NO SCALE

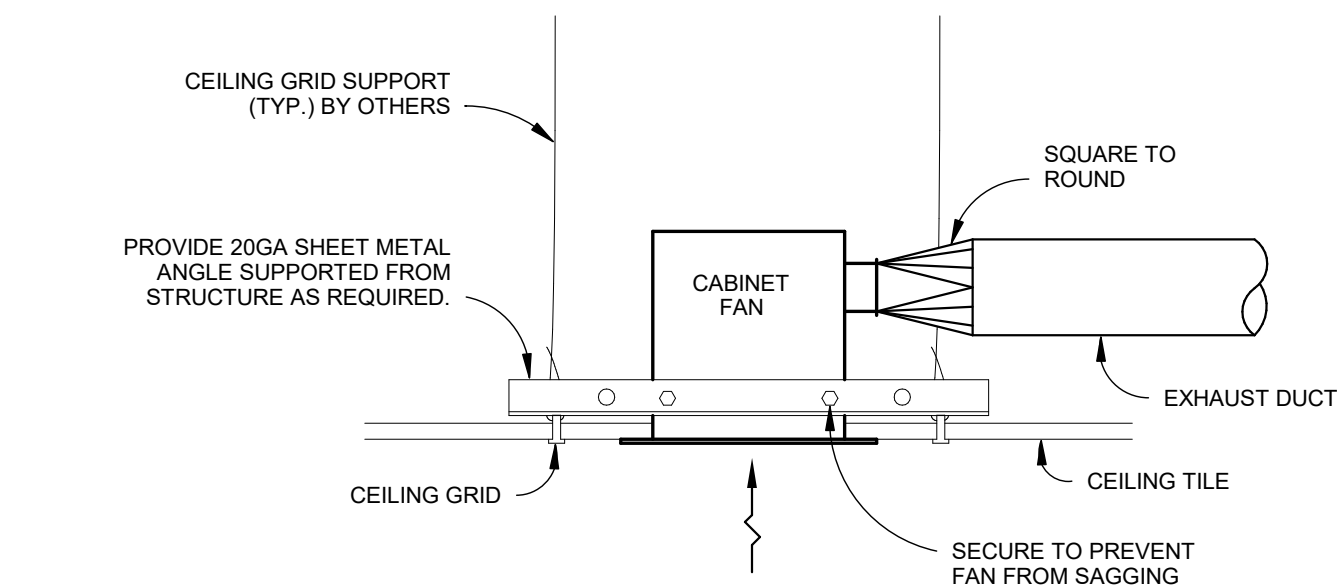


6 LAY-IN CABINET DETAIL
NO SCALE

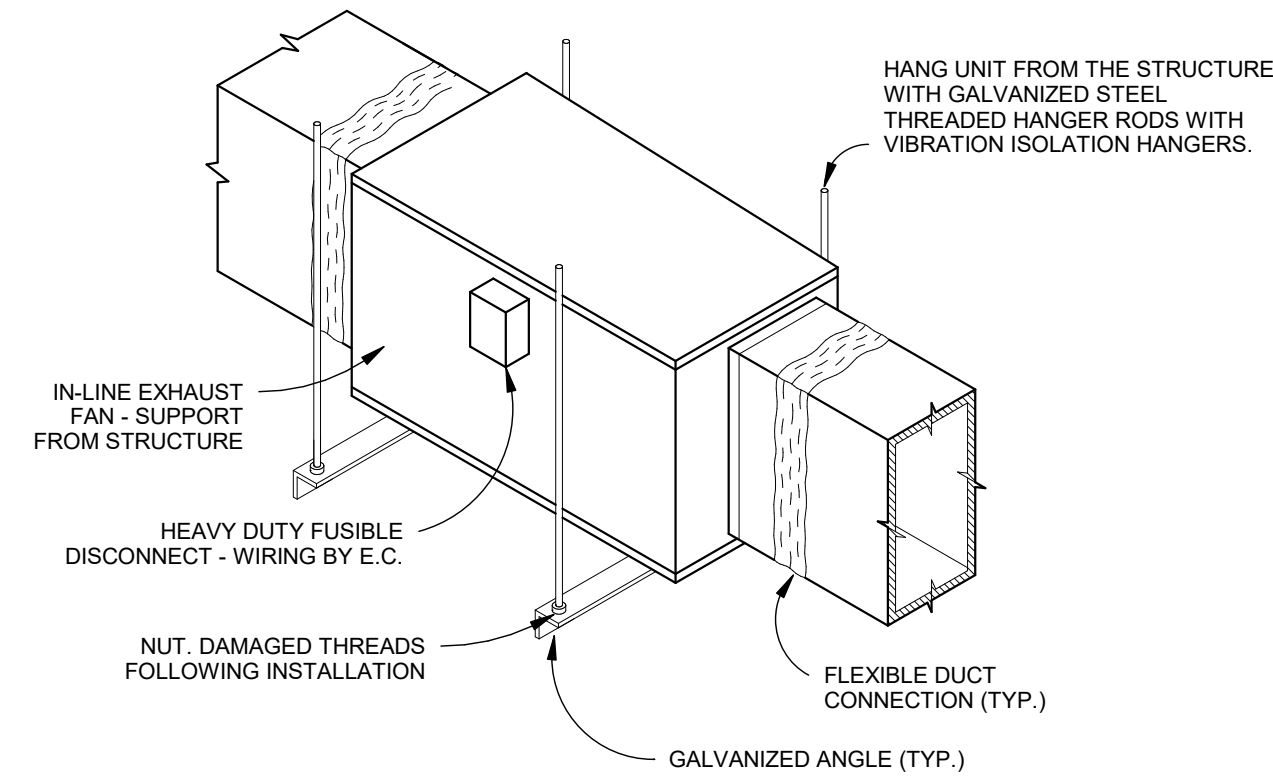

7 IN-LINE DIRECT DRIVE FAN DETAIL
NO SCALE

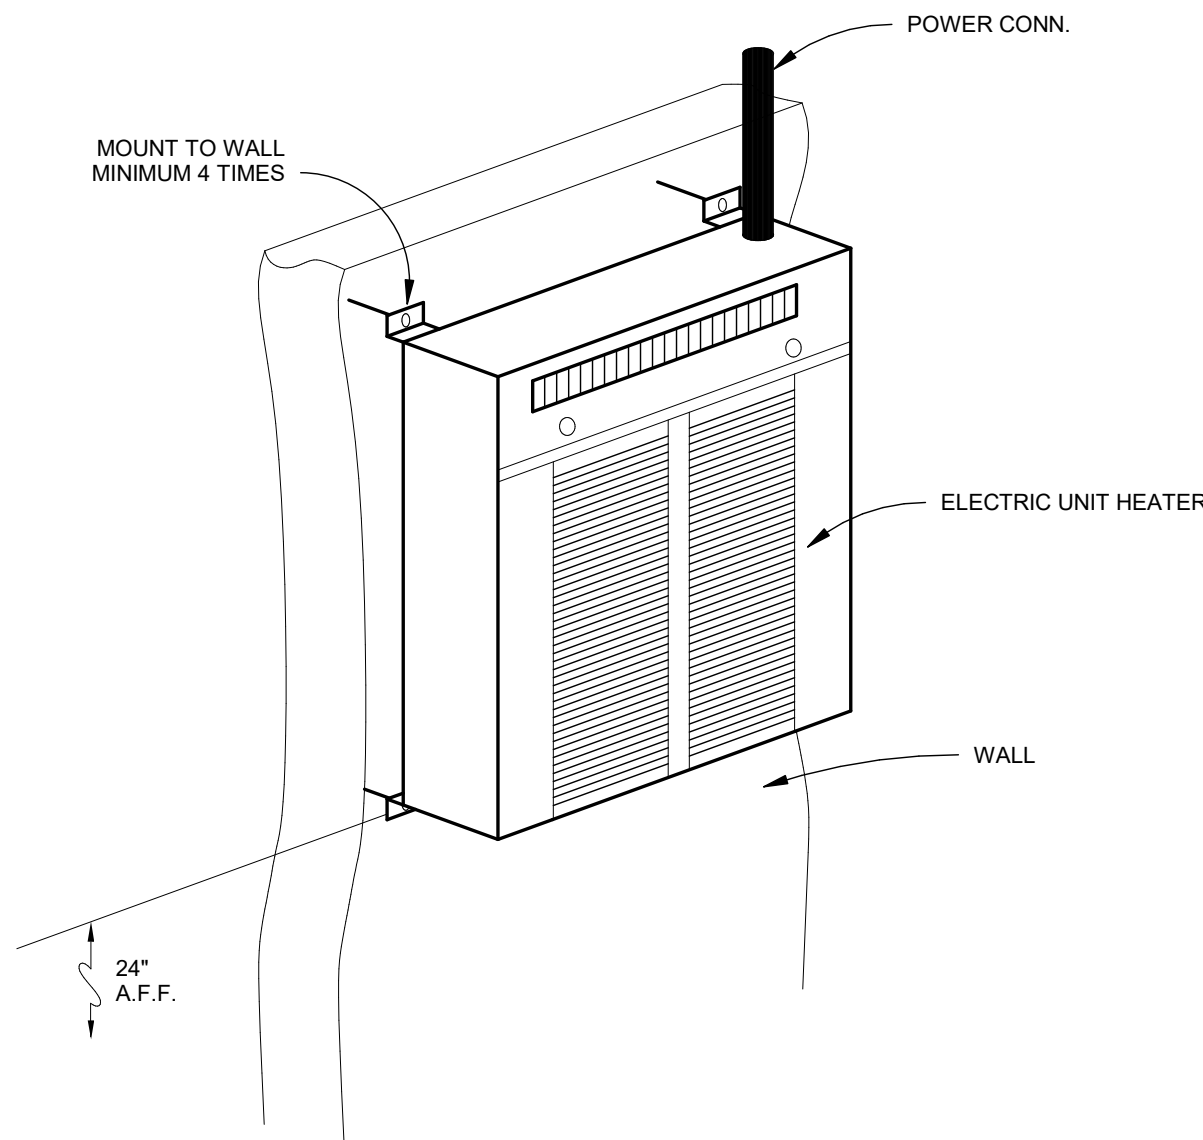

8 UNIT HTR STANDARD DETAIL
NO SCALE

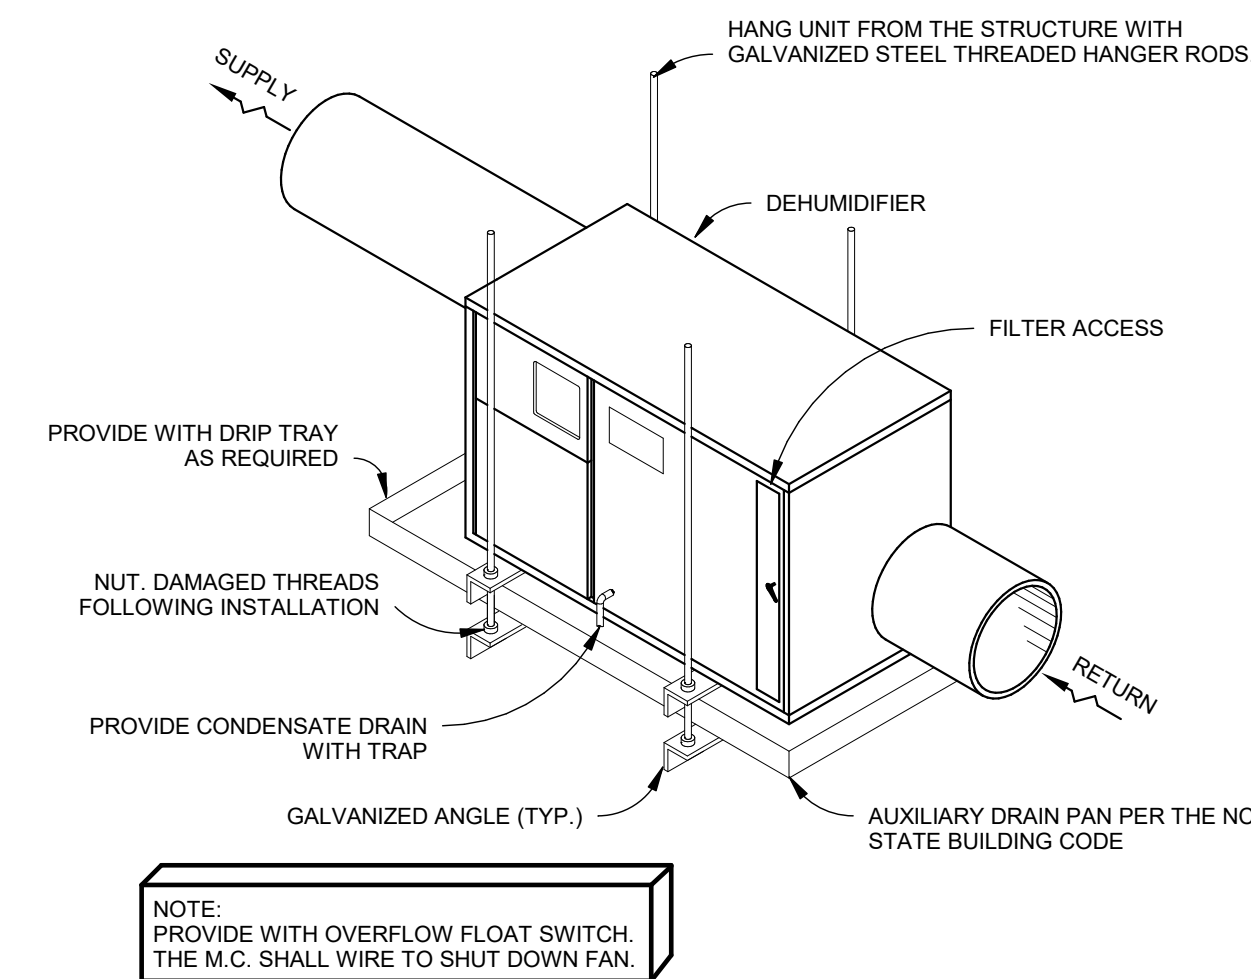


9 DEHUMIDIFIER SUSPENDED DETAIL
NO SCALE

IMEG
www.imegcorp.com
3221 BLUE RIDGE ROAD
SUITE 113
RALEIGH, NC 27612
P. 919.971.1111


IMEG RESERVES PROPRIETARY RIGHTS, INCLUDING COPYRIGHTS, TO THIS DRAWING AND THE DATA SHOWN THEREON. SAID DRAWING AND/OR DATA ARE THE EXCLUSIVE PROPERTY OF IMEG AND SHALL NOT BE USED OR REPRODUCED FOR ANY OTHER PROJECT WITHOUT THE EXPRESS WRITTEN APPROVAL AND PARTICIPATION OF IMEG.
©2026 IMEG CONSULTANTS CORP.
North Carolina Design Registration #E-1507

0 1 2 3
REF. SCALE IN INCHES PROJECT #26001727.00


Revisions		
#	Description	Date
Date	Project No.	
05-28-26	26001727.00	
Drawn By	Sheet No.	
PJM	M201	
Checked By		
GWD		
Sheet Title		
HVAC DETAILS		

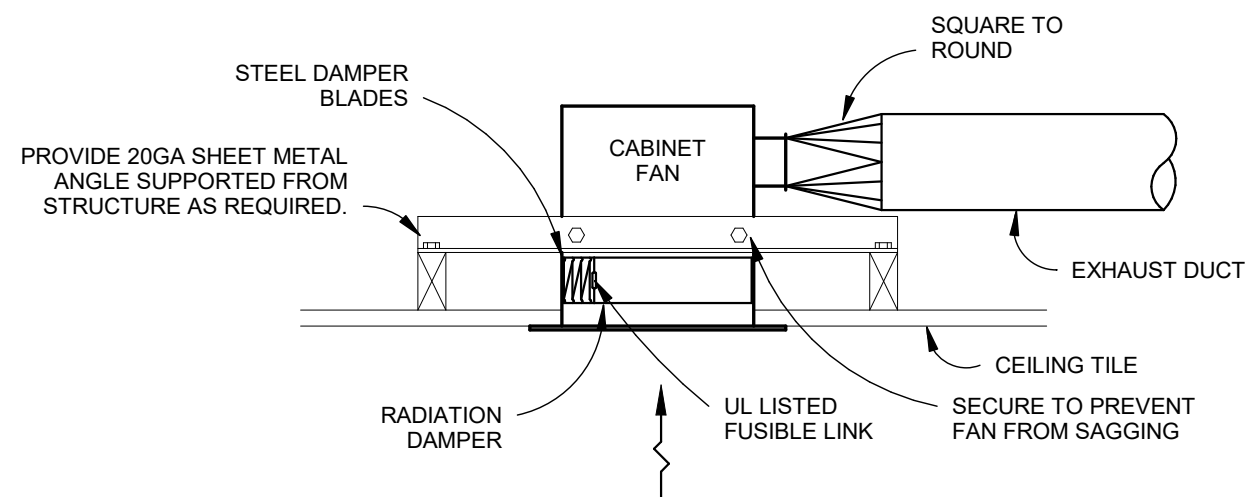

1 HARD CEILING CABINET DAMPER DETAIL



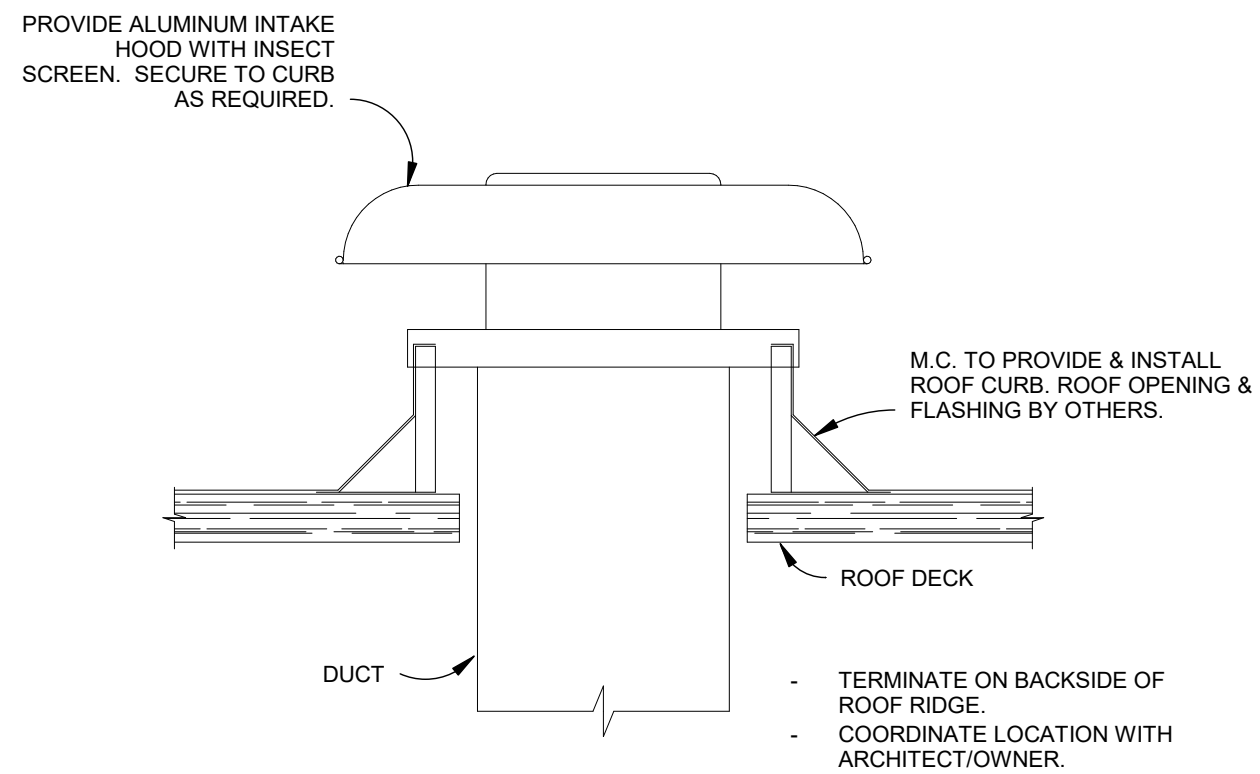


2 GRAVITY VENT ROUND DETAIL

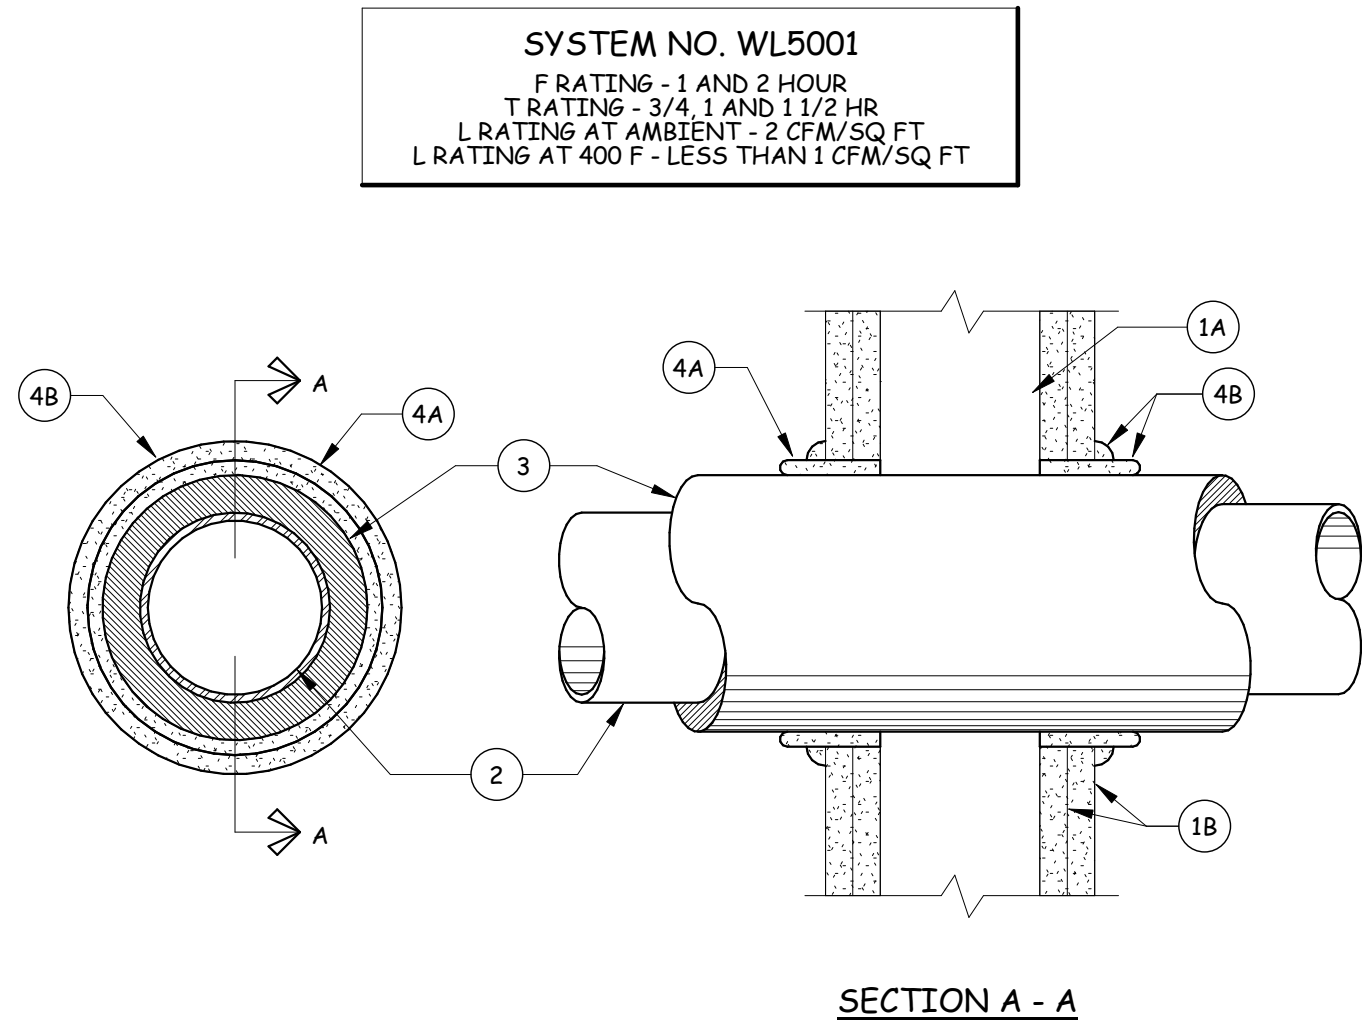

- 1 WALL ASSEMBLY: THE 1 OR 2 HR FIRE-RATED GYPSUM WALLBOARD/STUD WALL ASSEMBLY SHALL BE CONSTRUCTED OF THE MATERIALS AND IN THE MANNER DESCRIBED IN THE INDIVIDUAL U300 OR U400 SERIES WALL OR PARTITION DESIGN IN THE 1 HR FIRE RATED WALL DESIGN DIRECTORY AND SHALL INCLUDE THE FOLLOWING CONSTRUCTION FEATURES:
 - A. STUDS-WALL FRAMING MAY CONSIST OF EITHER WOOD STUDS OR STEEL CHANNEL STUDS. WOOD STUDS TO CONSIST OF NOM 2 BY 4 IN LUMBER SPACED 16 IN OC WITH MAX 2 BY 4 IN LUMBER ON PLAYSIDE AND CROSS BRACES.
 - B. STEEL STUDS TO BE MIN 3/8 IN. THICK BY 3/8 IN. DEEP CHANNELS SPACED MAX 24 IN. OC.
 - C. WALLBOARD, GYPSUM*-NOM 5/8 IN. THICK, 4 FT WIDE WITH SQUARE OR ROUNDED EDGES. GYPSUM WALLBOARD TO BE THICKER THAN U400 WALLBOARD. FASTENER TYPE AND SHEET ORIENTATION SHALL BE AS SPECIFIED IN THE INDIVIDUAL U300 OR U400 SERIES DESIGN IN THE UL FIRE RESISTANCE DIRECTORY. MAX DIAM OF OPENING IS 1/4-1/2 IN FOR WOOD STUD WALLS AND 18 IN FOR STEEL STUD WALLS.
 - D. THE HOURLY F RATING OF THE FIRESTOP SYSTEM IS 1 HR WHEN INSTALLED IN A 1 HR FIRE RATED WALL AND 2 HR WHEN INSTALLED IN A 2 HR FIRE RATED WALL.
- 2 THROUGH PENETRANTS-ONE METALLIC PIPE OR TUBING TO BE CENTERED WITHIN THE FIRESTOP SYSTEM. PIPE OR TUBING TO BE RIGIDLY SUPPORTED ON BOTH SIDES OF WALL ASSEMBLY. THE FOLLOWING TYPES AND SIZES OF METALLIC PIPES OR TUBING MAY BE USED:
 - A. STEEL PIPE-NOM 12 IN. DIAM (OR SMALLER) SCHEDULE 10 (OR HEAVIER) STEEL PIPE.
 - B. COPPER TUBING-NOM 6 IN. DIAM (OR SMALLER) TYPE L (OR HEAVIER) COPPER TUBING.
 - C. COPPER PIPE-NOM 6 IN. DIAM (OR SMALLER) REGULAR (OR HEAVIER) COPPER PIPE.
- 3 PIPE COVERING-NOM 1 OR 2 IN. THICK HOLLOW CYLINDRICAL HEAVY DENSITY (MIN 15 PCF) GLASS FIBER INSUL. TO BE USED ON THE OUTSIDE WITH ALL SERVICE JACKET, LONGITUDINAL JOINTS SEALED WITH METAL FASTENERS OR FACTORY-APPLIED SELF-SEALING LAP TAPE. TRANSVERSE JOINTS SEALED WITH METAL FASTENERS WITH BUTT STRIP TAPE SUPPLIED WITH THE PRODUCT. WHEN NOM 1 IN. THICK PIPE COVERING IS USED, THE ANNUAL SPACE BETWEEN THE PIPE COVERING AND THE CIRCULAR CUTOUT IN THE GYPSUM WALLBOARD LAYERS ON EACH SIDE OF THE WALL SHALL BE MIN 1/4 IN. TO MAX 3/8 IN. WHEN NOM 2 IN. THICK PIPE COVERING IS USED, THE ANNUAL SPACE BETWEEN THE PIPE COVERING AND THE CIRCULAR CUTOUT IN THE GYPSUM WALLBOARD LAYERS ON EACH SIDE OF THE WALL SHALL BE MIN 1/2 IN. TO MAX 3/4 IN. SEE PIPE AND EQUIPMENT COVERING MATERIALS (RGU) CATEGORY IN BUILDING MATERIALS DIRECTORY FOR NAMES OF MANUFACTURERS. ANY PIPE COVERING MATERIAL MEETING THE UL CLASSIFICATION SPECIFICATION AND BEARING THE UL CLASSIFICATION MARKING WITH A FLAME SPREAD INDEX OF 25 OR LESS AND A SMOKE DEVELOPED INDEX OF 50 OR LESS MAY BE USED. THE HOURLY T RATING OF THE FIRESTOP SYSTEM IS 3/4 HR WHEN NOM 1 IN. THICK PIPE COVERING IS USED. THE HOURLY T RATING OF THE FIRESTOP SYSTEM IS 1 HR AND 1-1/2 HR WHEN NOM 2 IN. THICK PIPE COVERING IS USED WITH 1 HR AND 2 HR FIRE RATED WALLS, RESPECTIVELY.
- 4 FIRESTOP SYSTEM-INSTALLED SYMMETRICALLY ON BOTH SIDES OF WALL ASSEMBLY. THE DETAILS OF THE FIRESTOP SYSTEM SHALL BE AS FOLLOWS:
 - A. FILL, VOID OR CAVITY MATERIALS*-WRAP STRIP-NOM 1/4 IN. THICK INTENSIVELY ELASTOMERIC MATERIAL, FACED ON ONE SIDE WITH ALUMINUM FOIL SUPPLIED IN THE WRAP STRIPS. NOM 1/4 IN. RATING OF THE FIRESTOP SYSTEM AROUND PIPE COVERING (FOIL SIDE OUT) WITH SEAM BUTTED. WRAP STRIP LAYER SECURELY BOUND WITH STEEL WIRE OR ALUMINUM FOIL TAPE AND SLID INTO ANNUAL SPACE APPROX 1/4 IN. SUCH THAT APPROX 1/4 IN. OF THE CIRCULAR STRIP WIDENESS OF THE FOIL STRIP LAYER IS EXPOSED. WRAP STRIP IS REQUIRED WHEN NOM 1 IN. THICK PIPE COVERING IS USED. TWO LAYERS OF WRAP STRIP ARE REQUIRED WHEN NOM 2 IN. THICK PIPE COVERING IS USED.
 - B. MINNESOTA MINING & MFG. CO.-FS-F55-
 - C. FILL, VOID OR CAVITY MATERIALS*-CAULK-MIN 1/4 IN. DIAM CONTINUOUS BEAD APPLIED TO THE WRAP STRIP WALL INTERFACE AND TO THE EXPOSED EDGE OF THE WRAP STRIP LAYER APPROX 1/4 IN. FROM THE WALL SURFACE.
 - D. MINNESOTA MINING & MFG. CO.-CP-25WB-*BEARING THE UL CLASSIFICATION MARKING

3 PENETRATION DETAIL

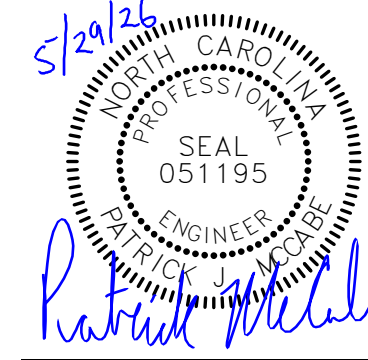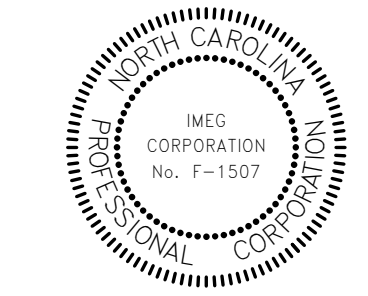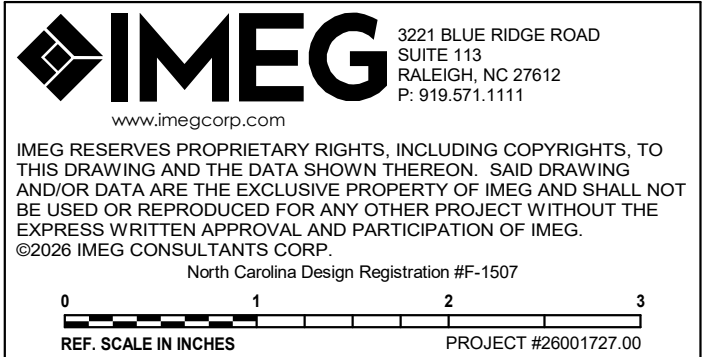

GENERAL NOTE:
Prior to construction start. Contractor shall verify & be responsible for all Dimensions.

Revisions  Description Date	
Date 05-28-26	
Project No. 26001727.00	
Drawn By PJM	Sheet No. M202
Checked By GWD	
Sheet Title HVAC DETAILS	

Copyright © 2025 Oakley Collier Architects. These drawings are of the property of the Architect for use under his supervision. No reproduction or other use is allowed without permission.

SPLIT SYSTEM INDOOR UNIT SCHEDULE (SS)

NOTES:
1. PROVIDE WITH FUSIBLE DISCONNECT.
2. PROVIDE WITH SINGLE POINT ELETRICAL CONNECTION.
3. SEE OUTSIDE AIR SUMMARY FOR OUTSIDE AIR INTAKE FLOW SETTINGS.
4. ROUTE CONDENSATE TO EXTERIOR SPLASH BLOCK.
6. PROVIDE WITH LOW AMBIENT CONTROLS FOR OPERATION DOWN TO 0 DEGREES FAHRENHEIT.
7. PROVIDE WITH 2" PLEATED FILTER RACK AND FILTER AT UNIT.
8. EQUIPMENT UTILIZES 454B REFRIGERANT. THE CONTRACTOR SHALL BE RESPONSIBLE FOR INSTALLATION, COST, AND LABOR FOR ALL REFRIGERANT REQUIRED PER MANUFACTURE'S INSTALLATION INSTRUCTIONS AND ASHRAE 15 STANDARDS.

TAG NAME	CFM DESIGN	COOLING (MBH)	HEATING (MBH)	AUXILLARY HEAT	ELECTRICAL					SEER2	HSPF	MANUFACTURER	MODEL	NOTES
				KW	VOLTS	PH	FLA	MCA	MOCP					
SS-1	1,050	36	36	10.8	208	3	33.9	42	45	14.3	7.5	TRANE	5TEM4B04	1-8
SS-2	1,975	60	60	10.8	208	3	36	44	45	14.3	7.5	TRANE	5TEM4D07	1-8
SS-3	1,950	60	60	10.8	208	3	36	44	45	14.3	7.5	TRANE	5TEM4D07	1-8
SS-4	1,000	36	36	10.8	208	3	33.9	42	45	14.3	7.5	TRANE	5TEM4B04	1-8
SS-5	1,200	36	36	10.8	208	3	33.9	42	45	14.3	7.5	TRANE	5TEM4B04	1-8
SS-6	1,100	36	36	10.8	208	3	33.9	42	45	14.3	7.5	TRANE	5TEM4B04	1-8
SS-7	1,200	36	36	10.8	208	3	33.9	42	45	14.3	7.5	TRANE	5TEM4B04	1-8

CONDENSING UNIT SCHEDULE - COOLING (CU)

NOTES:
1. PROVIDE WITH FUSEIBLE DISCONNECT.

TAG NAME	TONS	ELECTRIC AL		FLA	MINIMUM CIRCUIT AMPACITY	MAXIMUM OVERCURRENT PROTECTION	CURB / PAD		MANUFACTURER	MODEL	NOTES
		VOLTS	PH				TYPE / BY [G]	HEIGHT			
CU-1	3	208	3	13.4	16.6	25	PAD	4"	TRANE	5TWR4036	1
CU-2	5	208	3	18.8	22.8	35	PAD	4"	TRANE	5TWR4060	1
CU-3	5	208	3	18.8	22.8	35	PAD	4"	TRANE	5TWR4060	1
CU-4	3	208	3	13.4	16.6	25	PAD	4"	TRANE	5TWR4036	1
CU-5	3	208	3	13.4	16.6	25	PAD	4"	TRANE	5TWR4036	1
CU-6	3	208	3	13.4	16.6	25	PAD	4"	TRANE	5TWR4036	1
CU-7	3	208	3	13.4	16.6	25	PAD	4"	TRANE	5TWR4036	1

FAN SCHEDULE (EF, RF, SF, etc.)

NOTES:
1. PROVIDE WITH DISCONNECT SWITCH.
2. PROVIDE WITH BACKDRAFT DAMPER.
3. CONTROL VIA LIGHT SWITCH BY E.C.
4. CONTRIL VIA TIME CLOCK BY E.C.
5. CONTROL VIA THERMOSTAT.

TAG NAME	ARRANGEMENT	CFM	TOTAL S.P. IN. WC	DRIVE	RPM	MOTOR MHP [E]	MANUFACTURER	MODEL	NOTES
		DESIGN							
EF-1	CABINET FAN	25	0.25	DIRECT	1500	0.2	COOK	GC-140	1-3
EF-1	CABINET FAN	25	0.25	DIRECT	1500	0.2	COOK	GC-140	1-3
EF-1	CABINET FAN	25	0.25	DIRECT	1500	0.2	COOK	GC-140	1-3
EF-2	INLINE	350	0.5	DIRECT	1500	0.2	COOK	100SQN12D	1,4
EF-3	CABINET FAN	110	0.25	DIRECT	1500	0.2	COOK	GC-140	1,2,5

AIR TERMINAL SCHEDULE (EG, RG, SD, etc.)

NOTES:
1. COORDINATE FINISH WITH ARCHITECT.

TAG NAME	TYPE	MATERIAL	FINISH	FACE SIZE		BORDER	MANUFACTURER	MODEL	NOTES
				WIDTH	HEIGHT				
EG-1	LOUVERED	STEEL	WHITE	24"	24"	LAY-IN	PRICE	530	1
RG-1	LOUVERED	STEEL	WHITE	24"	24"	LAY-IN	PRICE	530	1
SD-1	LOUVERED	STEEL	WHITE	24"	24"	LAY-IN	PRICE	SCD 4 CONE	1

UNIT HEATER SCHEDULE - ELECTRIC (UH)

NOTES:
1. PROVIDE WITH POWER DISCONNECT.
2. PROVIDE WITH INTEGRAL THERMOSTAT.
3. PROVIDE WITH SURFACE MOUNTING KIT.

TAG NAME	LOCATION	CFM	Heating Capacity (BTUH)	AMPS	KW	VOLTAGE	PHASES	MANUFACTURER	MODEL	NOTES
UH-1	STAIRS	300	5,000	12.5	1.5	120	1	QMARK	CWH3150F	1-3
UH-2	STAIRS	300	5,000	12.5	1.5	120	1	QMARK	CWH3150F	1-3

DEHUMIDIFIER MANIFOLD SCHEDULE (DH)

NOTES:
1. PROVIDE WITH DISCONNECT SWITCH AND HARDWIRED CONNECTION. RECEPTACLE NOT ALLOWED ABOVE CEILING.
2. CONTROL VIA WALL MOUNTED HUMIDISTAT.
3. PROVIDE CONDENSATE TRAP AND ROUTE TO EXTERIOR SPLASH BLOCK.

TAG NAME	CFM	STATIC PRESSURE	WATTS	PINTS/DAY	VOLTAGE	PHASES	FULL LOAD AMPS	MAXIMUM OVERCURRENT PROTECTION	MANUFACTURER	MODEL	NOTES
DH-1	300	0.2	670	98	120	1	5.9	15	ULTRA-AIRE	98H	1-3
DH-2	300	0.2	670	98	120	1	5.9	15	ULTRA-AIRE	98H	1-3
DH-3	300	0.2	670	98	120	1	5.9	15	ULTRA-AIRE	98H	1-3

MINI-SPLIT SYSTEM SCHEDULE

NOTES:
1. PROVIDE FUSIBLE DISCONNECT ON OUTDOOR UNIT.
2. PROVIDE MOTOR RATED SWITCH FOR INDOOR UNIT.
3. PROVIDE WITH CONDENSATE PUMP AND ROUTE DISCHARGE TO EXTERIOR.
4. PROVIDE WITH WIRED THERMOSTAT.
5. PROVIDE WITH LOW AMBIENT CONTROLS DOWN TO 0°F.

TAG NAME	MANUFACTOR	INDOOR MODEL	CFM	ELECTRICAL		TAG NAME	OUTDOOR MODEL	COOLING (MBH)	ELECTRICAL				SEER2	NOTES
			DESIGN	FLA					VOLTS	PH	MCA	MOCP		
FC-8	MITSUBISHI	PKA-A24KA8	800		0.3	CU-8	PUY-A24NHA7	24	208	1	19	25	21.3	1-5



www.imegcorp.com

IMEG RESERVES PROPRIETARY RIGHTS, INCLUDING COPYRIGHTS, TO THIS DRAWING AND THE DATA SHOWN THEREON. SAID DRAWING AND/OR DATA ARE THE EXCLUSIVE PROPERTY OF IMEG AND SHALL NOT BE USED OR REPRODUCED FOR ANY OTHER PROJECT WITHOUT THE EXPRESS WRITTEN APPROVAL AND PARTICIPATION OF IMEG.
©2026 IMEG CONSULTANTS CORP.
North Carolina Design Registration #E-1507

0123

REF. SCALE IN INCHES



PROJECT #26001727.00

RENOVATION FOR:

CRAVEN COUNTY GOVERNMENT CENTER
EAST

CRAVEN COUNTY

1208 E. MAIN STREET, HAVELOCK, NORTH CAROLINA 28532

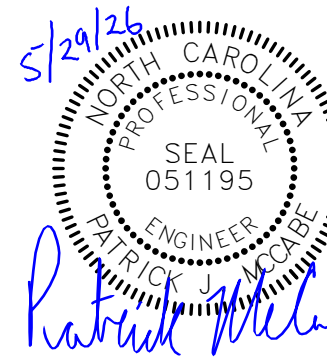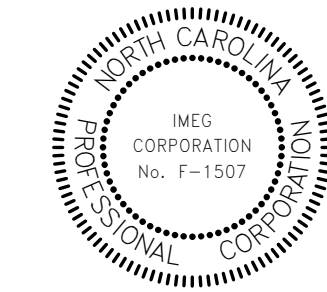

GENERAL NOTE: Prior to construction start, Contractor shall verify & be responsible for all Dimensions.		
Revisions		
#	Description	Date
Date	Project No.	
05-28-26	26001727.0	
Drawn By	Sheet No.	
PJM	M301	
Checked By		
GWD		
Sheet Title		
HVAC SCHEDULES		

NAME

10'-0"

HEIGHT ABOVE PROJECT 0'-0"

1

KEYNOTE: INDICATES NOTE USED TO DESCRIBE ADDITIONAL INFORMATION ABOUT WORK REQUIRED, SPECIFIC TO THE SHEET AND/OR DETAIL

INDICATES DIRECTION OF TRUE NORTH

PLAN OR DETAIL NUMBER

PLAN OR DETAIL NAME

1

VIEW NAME

1/8" = 1'-0"

PLAN OR DETAIL SCALE

INDICATES SIMILAR DETAIL REFERENCED IN MULTIPLE LOCATIONS

DETAIL REFERRED TO BY SECTION CUT

SHEET DETAIL IS LOCATED ON

1

2

3

LINE TYPE AND TAG KEY:

NEW WORK BY THIS CONTRACTOR (WIDE LINE)

----- EXISTING TO BE REMOVED (SHORT DASHED PATTERN)

----- NEW UNDERFLOOR OR UNDERGROUND (LONG DASHED PATTERN)

EXISTING TO REMAIN OR WORK BY OTHERS (NARROW LINE)

----- EXISTING TO BE REMOVED BY OTHERS (SHORT DASHED PATTERN)

----- EXISTING UNDERFLOOR OR UNDERGROUND (LONG DASHED PATTERN)

HALFTONING DOES NOT MODIFY SCOPE.

'TAG-E' TAGS WITH DASH 'E' INDICATES THE REFERENCED OBJECT IS EXISTING

TAG-1 UNDERLINED TAG INDICATES OBJECT IS IN-SCOPE. IF NEW, ADDITIONAL INFORMATION IS AVAILABLE IN A SCHEDULE, MATERIAL LIST, OR SYMBOL LIST

INDICATES AN EXISTING SYSTEM'S POINT OF CONNECTION/REMOVAL

ELECTRICAL SYMBOL LIST - RECEPTACLES				
SYMBOL	TAG	EQUIP ABBREV	SPEC SECTION	DESCRIPTION
#		REC-DUP	26 27 26	DUPLEX RECEPTACLE, 125V
W		REC-DUP-W	26 27 26	DUPLEX GFI WEATHERPROOF RECEPTACLE, 125V - NEMA 3R WHILE IN-USE COVER
#		REC-DUP-GFI	26 27 26	DUPLEX RECEPTACLE, GROUND FAULT CIRCUIT INTERRUPTER, 125V
#		REC-QUAD	26 27 26	QUAD RECEPTACLE, 125V
#	520	REC-SIM-520R	26 27 26	RECEPTACLE, 5-20R, 125V
		FB-#	26 27 26	ELECTRICAL FLOOR BOX
		PT-#	26 27 26	ELECTRICAL POKE THROUGH

RECEPTACLE SUBSCRIPT KEY:

DEVICE KEY:

DEVICE # = MOUNTING (IF APPLICABLE)
1 = CIRCUIT NUMBER

*IF LABEL IS ORIENTED HORIZONTALLY A SLASH WILL SEPARATE THIS INFORMATION. EX: A / 1

ELECTRICAL MOUNTING SUBSCRIPT KEY:

A MOUNT AT +6" TO CENTERLINE ABOVE COUNTER OR BACKSPLASH
C MOUNT AT CEILING (DEVICE OR ROUGH-IN CONTEXT)
L MOUNT IN CASEWORK
+##" MOUNT AT #" TO CENTERLINE ABOVE FINISHED FLOOR

ELECTRICAL SYMBOL LIST - POWER			
SYMBOL	EQUIP ABBREV	SPEC SECTION	DESCRIPTION
Ⓢ	ECONN	26 05 33	ELECTRICAL CONNECTION - CEILING/SURFACE
Ⓛ	ECONN	26 05 33	ELECTRICAL CONNECTION - WALL
	CT	26 24 16	PANELBOARD - SURFACE MOUNT
	PANEL-##	26 24 16	PANELBOARD - SURFACE MOUNT
	MTS-#	26 36 00	AUTOMATIC TRANSFER SWITCH, REFER TO TRANSFER SWITCH SCHEDULE
	FDS-#	26 28 16	FUSIBLE DISCONNECT SWITCH, REFER TO DISCONNECT AND STARTER SCHEDULE
Ⓜ	KWM	26 09 13	ELECTRIC METER

TECHNOLOGY SYMBOL LIST			
SYMBOL	TAG	EQUIPMENT LIST ABBREVIATION	DESCRIPTION
C#	C1	SC-IO-W	INFORMATION OUTLET (WALL)
CR			SECURITY ACCESS: KEYCARD READER
			TIME CLOCK

2018 APPENDIX B BUILDING CODE SUMMARY FOR COMMERCIAL PROJECTS ELECTRICAL SUMMARY

ELECTRICAL SYSTEMS AND EQUIPMENT

METHOD OF COMPLIANCE: Energy Code: ☒ Prescriptive ☐ Performance
ASHRAE 90.1: ☐ Prescriptive ☐ Performance

LIGHTING SCHEDULE

LAMP TYPE REQUIRED IN FIXTURE: SEE FIXTURE SCHEDULE
NUMBER OF LAMPS IN THE FIXTURE: SEE FIXTURE SCHEDULE
BALLAST TYPE USED IN THE FIXTURE: SEE FIXTURE SCHEDULE
NUMBER OF BALLASTS IN THE FIXTURE: SEE FIXTURE SCHEDULE
TOTAL WATTAGE PER FIXTURE: SEE FIXTURE SCHEDULE
TOTAL INTERIOR WATTAGE: 5755 VS 9187
SPECIFIED VS. ALLOWED (WHOLE BUILDING OR SPACE BY SPACE)
TOTAL EXTERIOR WATTAGE: 564 VS 750
SPECIFIED VS. ALLOWED

ADDITIONAL EFFICIENCY PACKAGE OPTIONS (WHEN USING THE 2018 NCECC; NOT REQUIRED FOR ASHRAE 90.1)

☐ C406.2 MORE EFFICIENT HVAC EQUIPMENT PERFORMANCE
☒ C406.3 REDUCED LIGHTING POWER DENSITY
☐ C406.4 ENHANCED DIGITAL LIGHTING CONTROLS
☐ C406.5 ON-SITE RENEWABLE ENERGY
☐ C406.6 DEDICATED OUTDOOR AIR SYSTEM
☐ C406.7 REDUCED ENERGY USE IN SERVICE WATER HEATING

DESIGNER STATEMENT:
TO THE BEST OF MY KNOWLEDGE AND BELIEF, THE DESIGN OF THIS BUILDING COMPLIES WITH THE ELECTRICAL SYSTEM AND EQUIPMENT REQUIREMENTS OF THE NORTH CAROLINA STATE BUILDING CODE, 2018 - ENERGY.

SIGNED: Alex Bowling
NAME: ALEX BOWLING P.E.
TITLE: ENGINEER

ELECTRICAL INSTALLATION NOTES:

- CIRCUIT NUMBERS ARE SHOWN FOR CIRCUIT IDENTIFICATION. CIRCUITING SHALL AGREE WITH NUMBERING ON THE PANEL PROVIDED. COMMON NEUTRALS MAY NOT BE USED FOR BRANCH CIRCUITS. BALANCE THE LOAD ON PANEL AS EVENLY AS POSSIBLE BETWEEN EACH PHASE.
- FLUSH MOUNT ALL LIGHTING CONTROL DEVICES AT +42" FROM FLOOR (CENTERLINE DIMENSION), EXCEPT WHERE OTHERWISE NOTED.
- FLUSH MOUNT ALL DUPLEX RECEPTACLES AND TECHNOLOGY OUTLETS AT +18" FROM FLOOR (CENTERLINE DIMENSION), EXCEPT WHERE OTHERWISE NOTED. RECEPTACLES AND OUTLETS MAY BE SURFACE MOUNTED WHEN CONDUIT IS SPECIFIED EXPOSED. MOUNT EXTERIOR LOCATED RECEPTACLES WITH WHILE-IN-USE COVERS AT +20" FROM FINISHED GRADE (CENTER DIMENSIONS) TO MAINTAIN INSTALLATION ADA COMPLIANCE.
- ALL MATERIALS USED TO SEAL PENETRATIONS OF FIRE RATED WALLS AND FLOORS SHALL BE TESTED AND CERTIFIED AS A SYSTEM PER ASTM E814 STANDARDS FOR FIRE TESTS OF THROUGH-PENETRATION FIRESTOPS. REFER TO 27 05 03 AND 28 05 03 DIVISION 7 26 05 03 FOR ADDITIONAL INFORMATION AND REQUIREMENTS SPECIFIC TO FIRESTOPPING.
- CONNECTION FOR ELECTRIC WATER COOLERS (EWC) SHALL BE A JUNCTION BOX CONCEALED BEHIND WATER COOLER ACCESS PLATE OR BE A GFI RECEPTACLE LOCATED DIRECTLY BELOW AND CENTERED ON EWC. CONTRACTOR SHALL VERIFY TYPE OF EWC TO BE INSTALLED.
- CONTRACTOR SHALL COORDINATE THE LOCATION OF ALL CEILING MOUNTED DEVICES AND EQUIPMENT WITH LUMINAIRES, SPRINKLER, AND CEILING DIFFUSERS. CENTER ALL DEVICES IN CEILING TILE PATTERN. SMOKE DETECTORS CARBON MONOXIDE DETECTORS, AND OCCUPANCY/VACANCY SENSORS SHALL BE LOCATED NO CLOSER THAN 3 FEET TO AN AIR SUPPLY DIFFUSER OR RETURN GRILLE. CARBON MONOXIDE DETECTORS SHALL BE LOCATED 10 PLUS FT FROM FIRE PLACES, COOKING, AND SIMILAR FUEL-BURNING APPLIANCES.
- CONTRACTOR SHALL VERIFY ALL FURNITURE, MODULAR FURNITURE, AND EQUIPMENT LOCATIONS WITH ARCHITECTURAL PLANS, ELEVATIONS, AND REVIEWED SHOP DRAWINGS. PRIOR TO MAKING THE ACTUAL ELECTRICAL INSTALLATION, THIS CONTRACTOR SHALL ADJUST RECEPTACLES, OUTLETS, OR CONNECTION LOCATIONS TO ACCOMMODATE FURNITURE AND/OR EQUIPMENT.
- ELECTRICAL AND TECHNOLOGY EQUIPMENT SHALL BE MOUNTED TO AVOID IMPEDANCE OF OPERATION OF, AND/OR ACCESS TO ELECTRICAL AND MECHANICAL EQUIPMENT. ALL MOUNTING OF ELECTRICAL AND TELECOMMUNICATIONS EQUIPMENT, ON EQUIPMENT SUPPLIED BY ANOTHER CONTRACTOR, SHALL BE APPROVED IN ADVANCE BY THE OTHER CONTRACTOR.
- CONTRACTOR SHALL BE RESPONSIBLE FOR ALL OPENINGS REQUIRED IN WALLS. ALL OPENINGS SHALL BE REPAIRED TO MATCH EXISTING BY A QUALIFIED CONTRACTOR AT THE EXPENSE OF THIS CONTRACTOR. ALL CONDUITS THROUGH WALLS SHALL BE GROUTED OR SEALED INTO OPENINGS.
- EACH CONTRACTOR IS RESPONSIBLE FOR DAMAGE CAUSED BY THEIR ACTIONS TO THE WALLS, FLOORS, CEILINGS, AND ROOFS. THE CONTRACTOR WHOSE WORK CAUSES DAMAGE IS RESPONSIBLE FOR PATCHING TO MATCH ORIGINAL CONSTRUCTION, FIRE RATING, AND FINISH.
- REFER TO ARCHITECTURAL REFLECTED CEILING PLAN, ELECTRICAL, TECHNOLOGY AUDIO/VISUAL, AND OTHER ELECTRICAL PLANS FOR EXACT LOCATIONS OF ALL CEILING MOUNTED DEVICES, OTHER THAN SPRINKLERS.
- ELECTRICAL IDENTIFICATION. REFER TO SPECIFICATION SECTION 26 05 53 FOR COLOR/LABEL REQUIREMENTS FOR CONDUIT, BOX, CABLE/WIRE, AND EQUIPMENT.
- PROVIDE SEPARATE BRANCH CIRCUIT TO SUPPLY POWER TO THE HOIST WAY PIT LIGHTING. LIGHTING SHALL NOT BE CONNECTED TO LOAD SIDE OF GFI DEVICE. REFER TO ELEVATOR MANUFACTURER FOR EXACT LOCATION.
- COORDINATE ALL LUMINAIRE LOCATIONS WITH STRUCTURAL TRUSS AND BEAMS PRIOR TO ROUGH-IN.
- WHERE LUMINAIRE QUANTITIES OR LAYOUT DIFFER BETWEEN ELECTRICAL AND ARCHITECTURAL PLANS, HIGHER QUANTITY SHALL TAKE PRECEDENCE. CONTRACTOR TO CONFIRM QUANTITY AND LAYOUT WITH DESIGN TEAM.

APPLICABLE CODES

CONTRACTOR SHALL COMPLY WITH APPLICABLE CODES AND LOCAL AMENDMENTS INCLUDING, BUT NOT LIMITED TO, THE FOLLOWING:

ELECTRICAL CODE: NEC 2020
ENERGY CONSERVATION CODE: NCECC 2018

ELECTRICAL SHEET INDEX

E000	ELECTRICAL COVERSHEET
E201	FIRST FLOOR PLAN - LIGHTING
E202	SECOND FLOOR PLAN - LIGHTING
E211	FIRST FLOOR PLAN - POWER
E212	SECOND FLOOR PLAN - POWER
E400	ELECTRICAL DETAILS
E600	ELECTRICAL SCHEDULES
E601	ELECTRICAL SCHEDULES

GRAND TOTAL: 8



3221 BLUE RIDGE ROAD
SUITE 113
RALEIGH, NC 27612
P: 919.971.1111

www.imegcorp.com

IMEG RESERVES PROPRIETARY RIGHTS, INCLUDING COPYRIGHTS, TO THIS DRAWING AND THE DATA SHOWN THEREON. SAID DRAWING AND/OR DATA ARE THE EXCLUSIVE PROPERTY OF IMEG AND SHALL NOT BE USED OR REPRODUCED FOR ANY OTHER PROJECT WITHOUT THE EXPRESS WRITTEN APPROVAL AND PARTICIPATION OF IMEG.
©2026 IMEG CONSULTANTS CORP.
North Carolina Design Registration #E-1507

0 1 2 3

REF. SCALE IN INCHES

PROJECT #26001727.00

RENOVATION FOR:

CRAVEN COUNTY GOVERNMENT CENTER
EAST

CRAVEN COUNTY

1208 E. MAIN STREET, HAVELOCK, NORTH CAROLINA 28532

5/29/2026

GENERAL NOTE:
Prior to construction start, Contractor shall verify & be responsible for all Dimensions.

Revisions
Description Date

Date
05-28-26

Project No.
26001727.00

Drawn By
Author

Sheet No.

Checked By
Checker


E000

Sheet Title
ELECTRICAL
COVERSHEET


OAKLEY
COLLIER
ARCHITECTS
OCA

109 Candlewood Road, Rocky Mount, NC 27804 | P: 252.937.2500
205 W. Martin Street, Raleigh, NC 27601

Copyright © 2025 Oakley Collier Architects. These drawings are of the property of the Architect for use under his supervision. No reproduction or other use is allowed without permission.

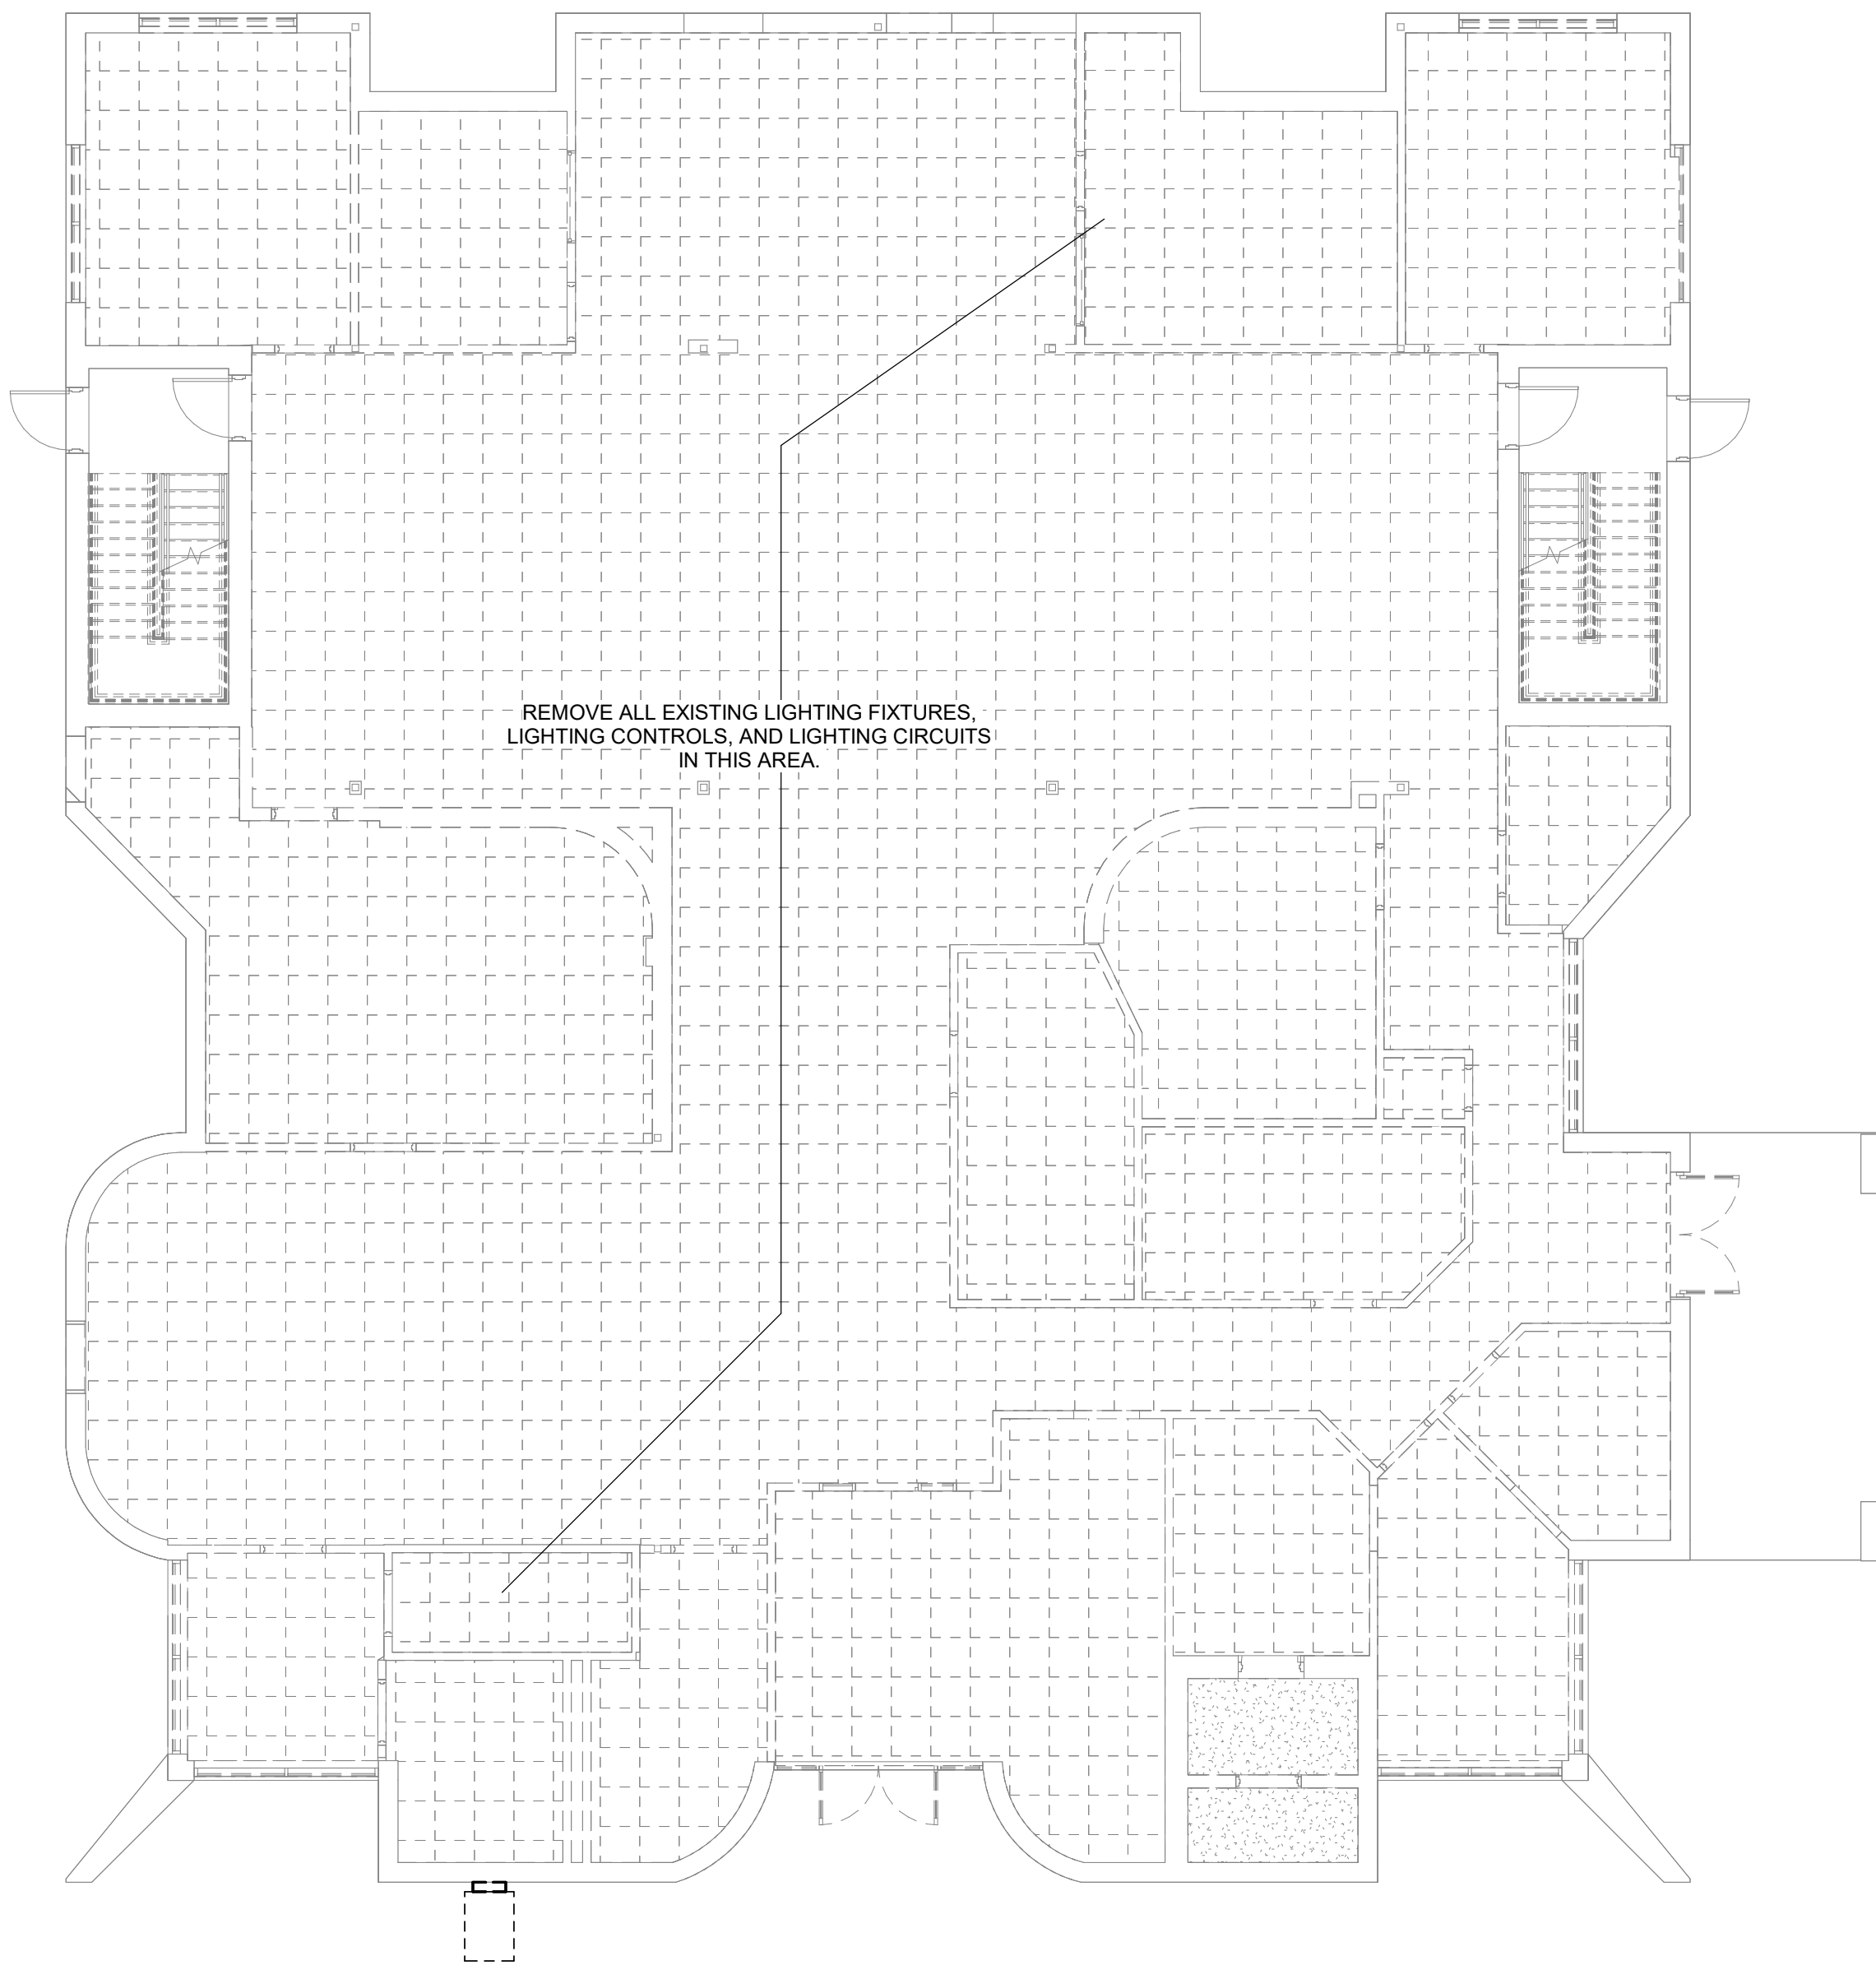

1 FIRST FLOOR DEMOLITION PLAN - LIGHTING
1/8" = 1'-0"


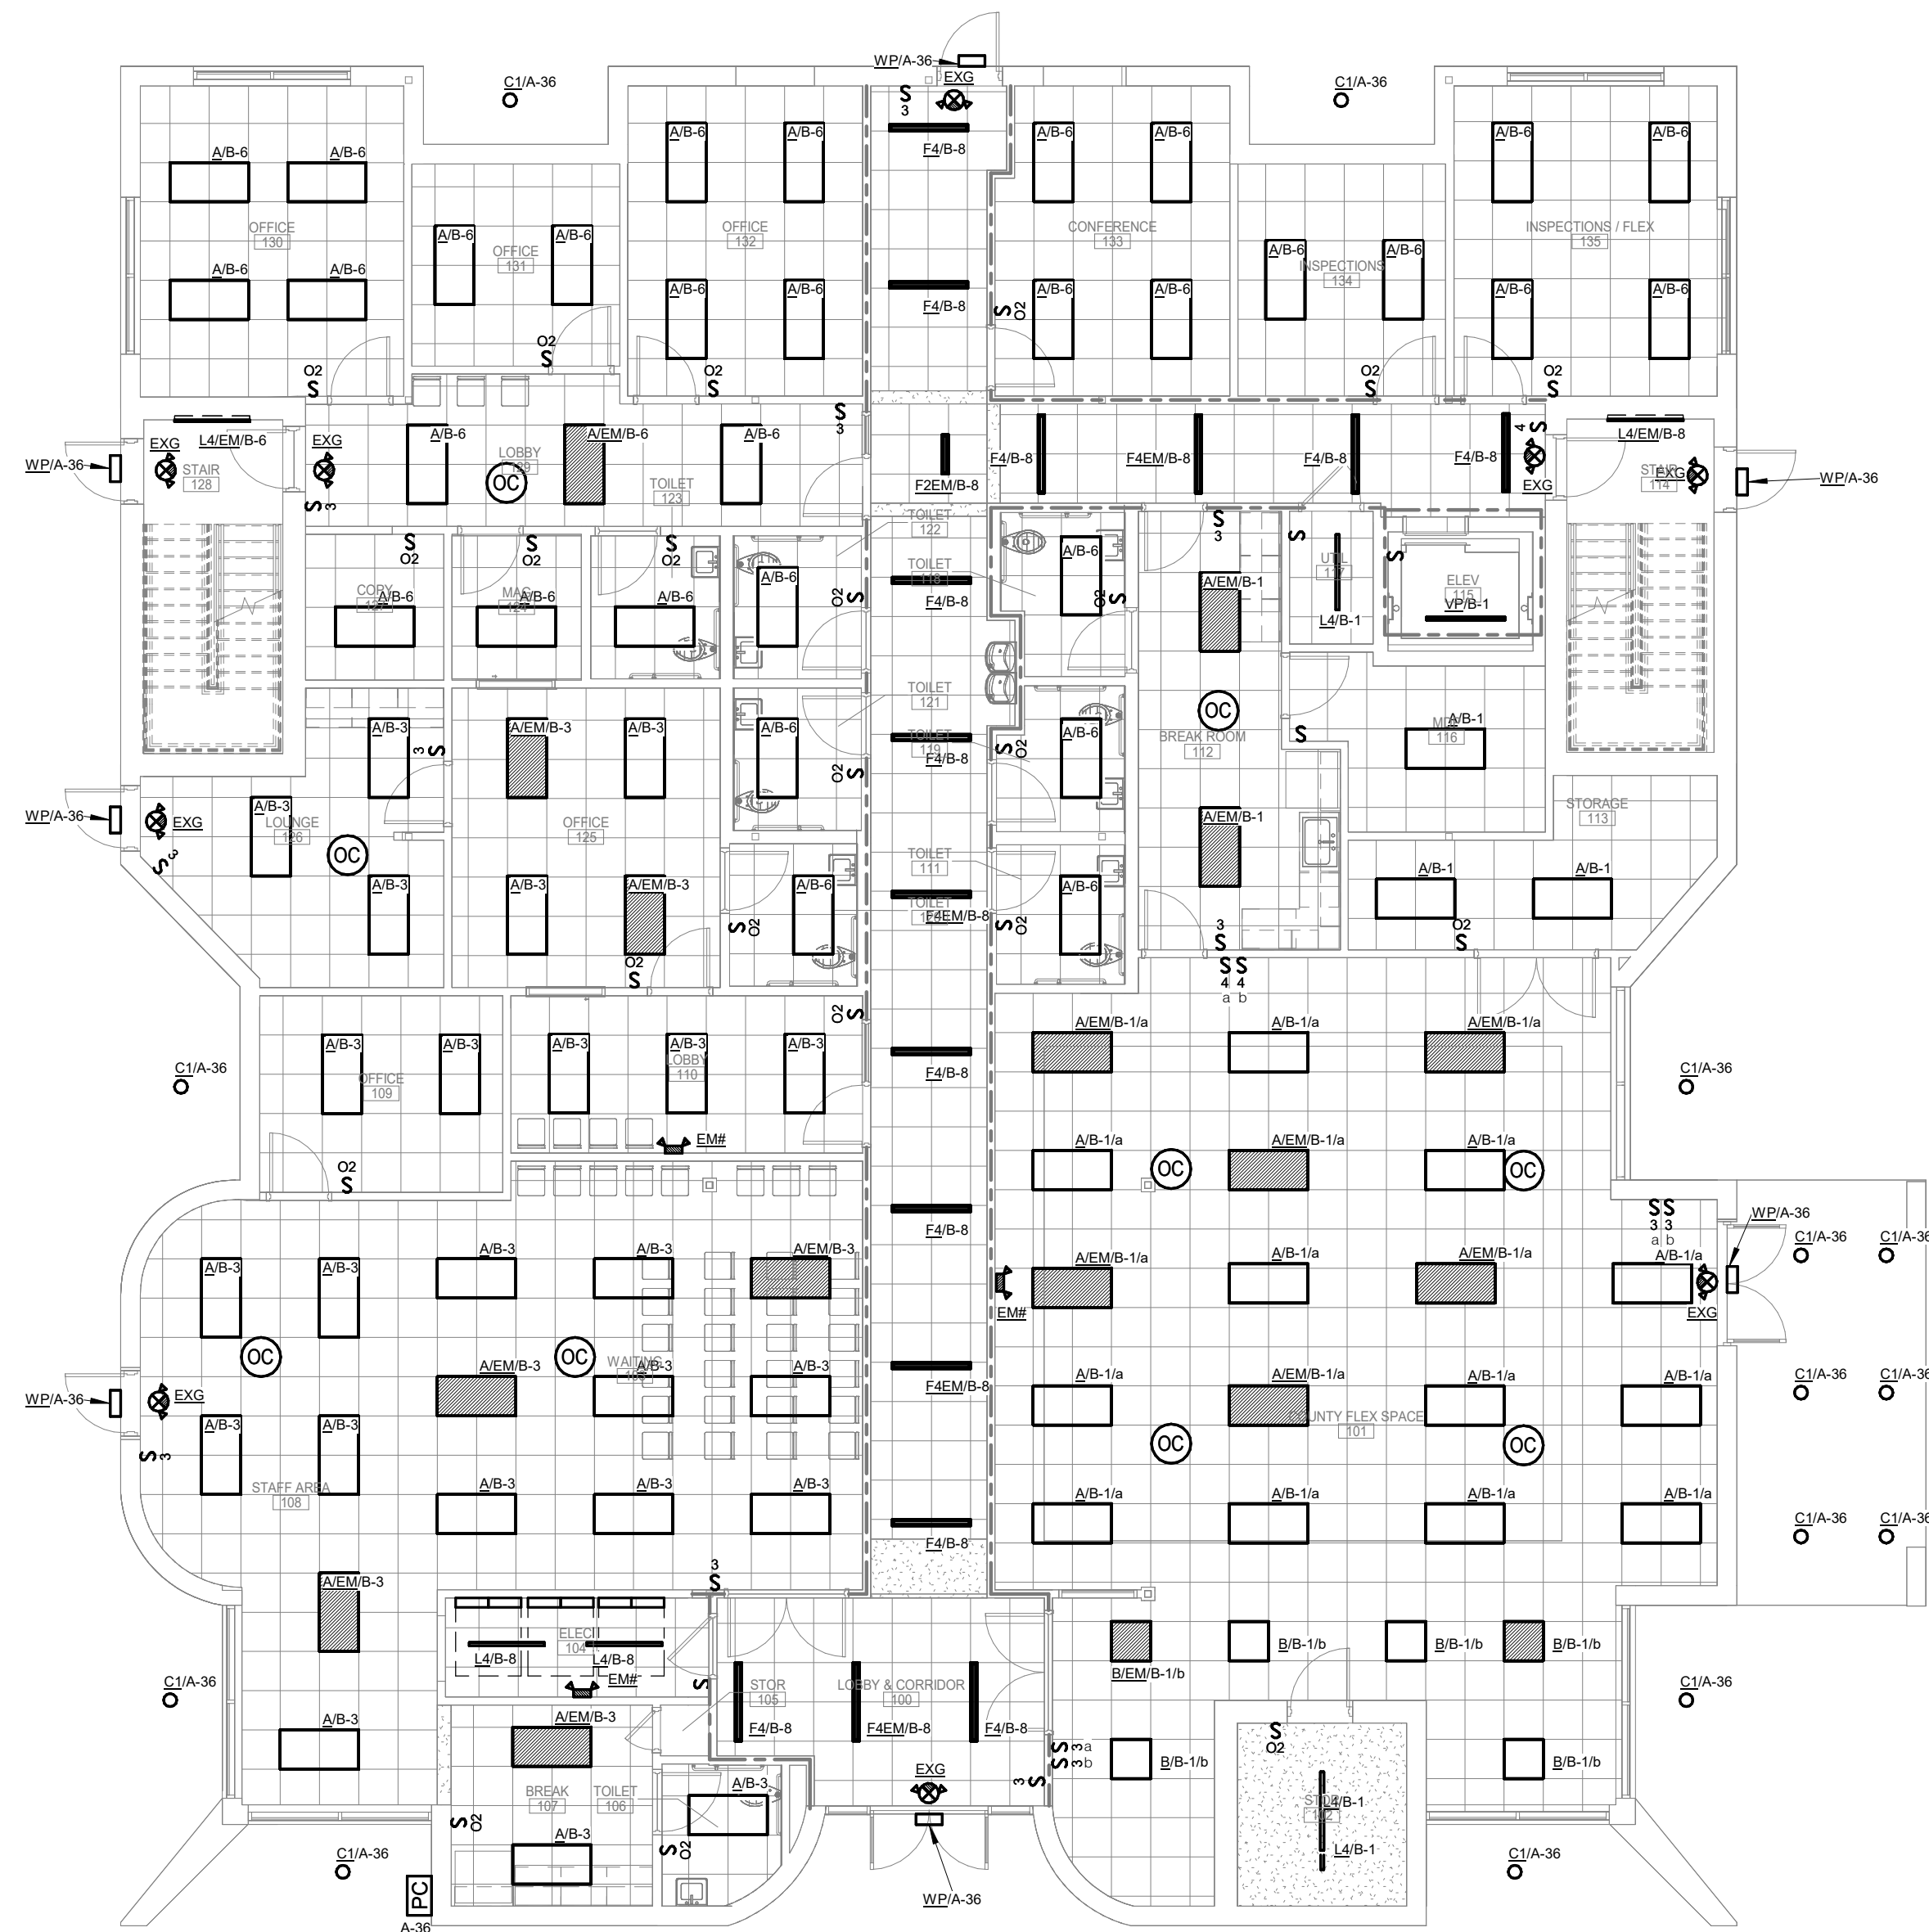


2 FIRST FLOOR PLAN - LIGHTING
1/8" = 1'-0"

IMEG
3221 BLUE RIDGE ROAD
SUITE 113
RALEIGH, NC 27612
P. 919.971.1111
www.imegcorp.com

IMEG RESERVES PROPRIETARY RIGHTS, INCLUDING COPYRIGHTS, TO THIS DRAWING AND THE DATA SHOWN THEREON. SAID DRAWING AND/OR DATA ARE THE EXCLUSIVE PROPERTY OF IMEG AND SHALL NOT BE USED OR REPRODUCED FOR ANY OTHER PROJECT WITHOUT THE EXPRESS WRITTEN APPROVAL AND PARTICIPATION OF IMEG.
©2026 IMEG CONSULTANTS CORP.
North Carolina Design Registration #F-1507

0 1 2 3
REF. SCALE IN INCHES PROJECT #26001727.00

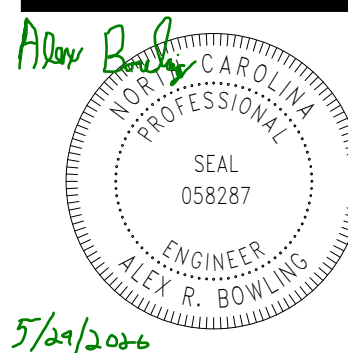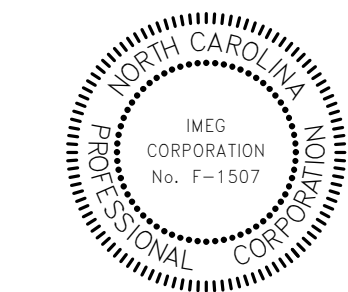


GENERAL NOTE:
Prior to construction start, Contractor shall verify & be responsible for all Dimensions.

Revisions	
 #	Description
Date	
Date	Project No.
05-28-26	26001727.00
Drawn By	Sheet No.
Author	E201
Checked By	
Checker	
Sheet Title	
FIRST FLOOR PLAN - LIGHTING	

Revisions		
	Description	Date


Sheet Title
SECOND FLOOR PLAN -
LIGHTING

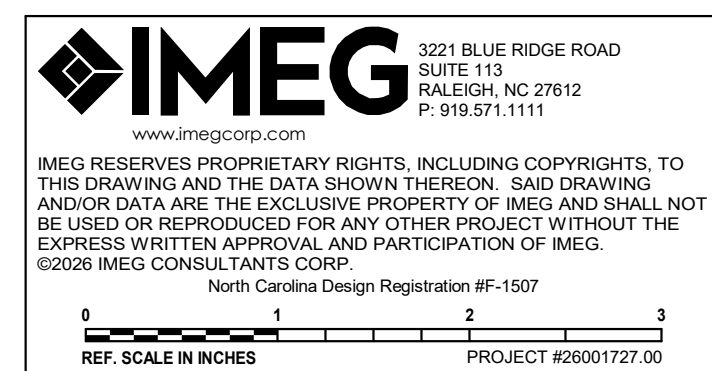

Copyright © 2025 Oakley Collier Architects. These drawings are of the property of the Architect for use under his supervision. No reproduction or other use is allowed without permission.


2 FIRST FLOOR DEMOLITION PLAN - POWER

1/8" = 1'-0"

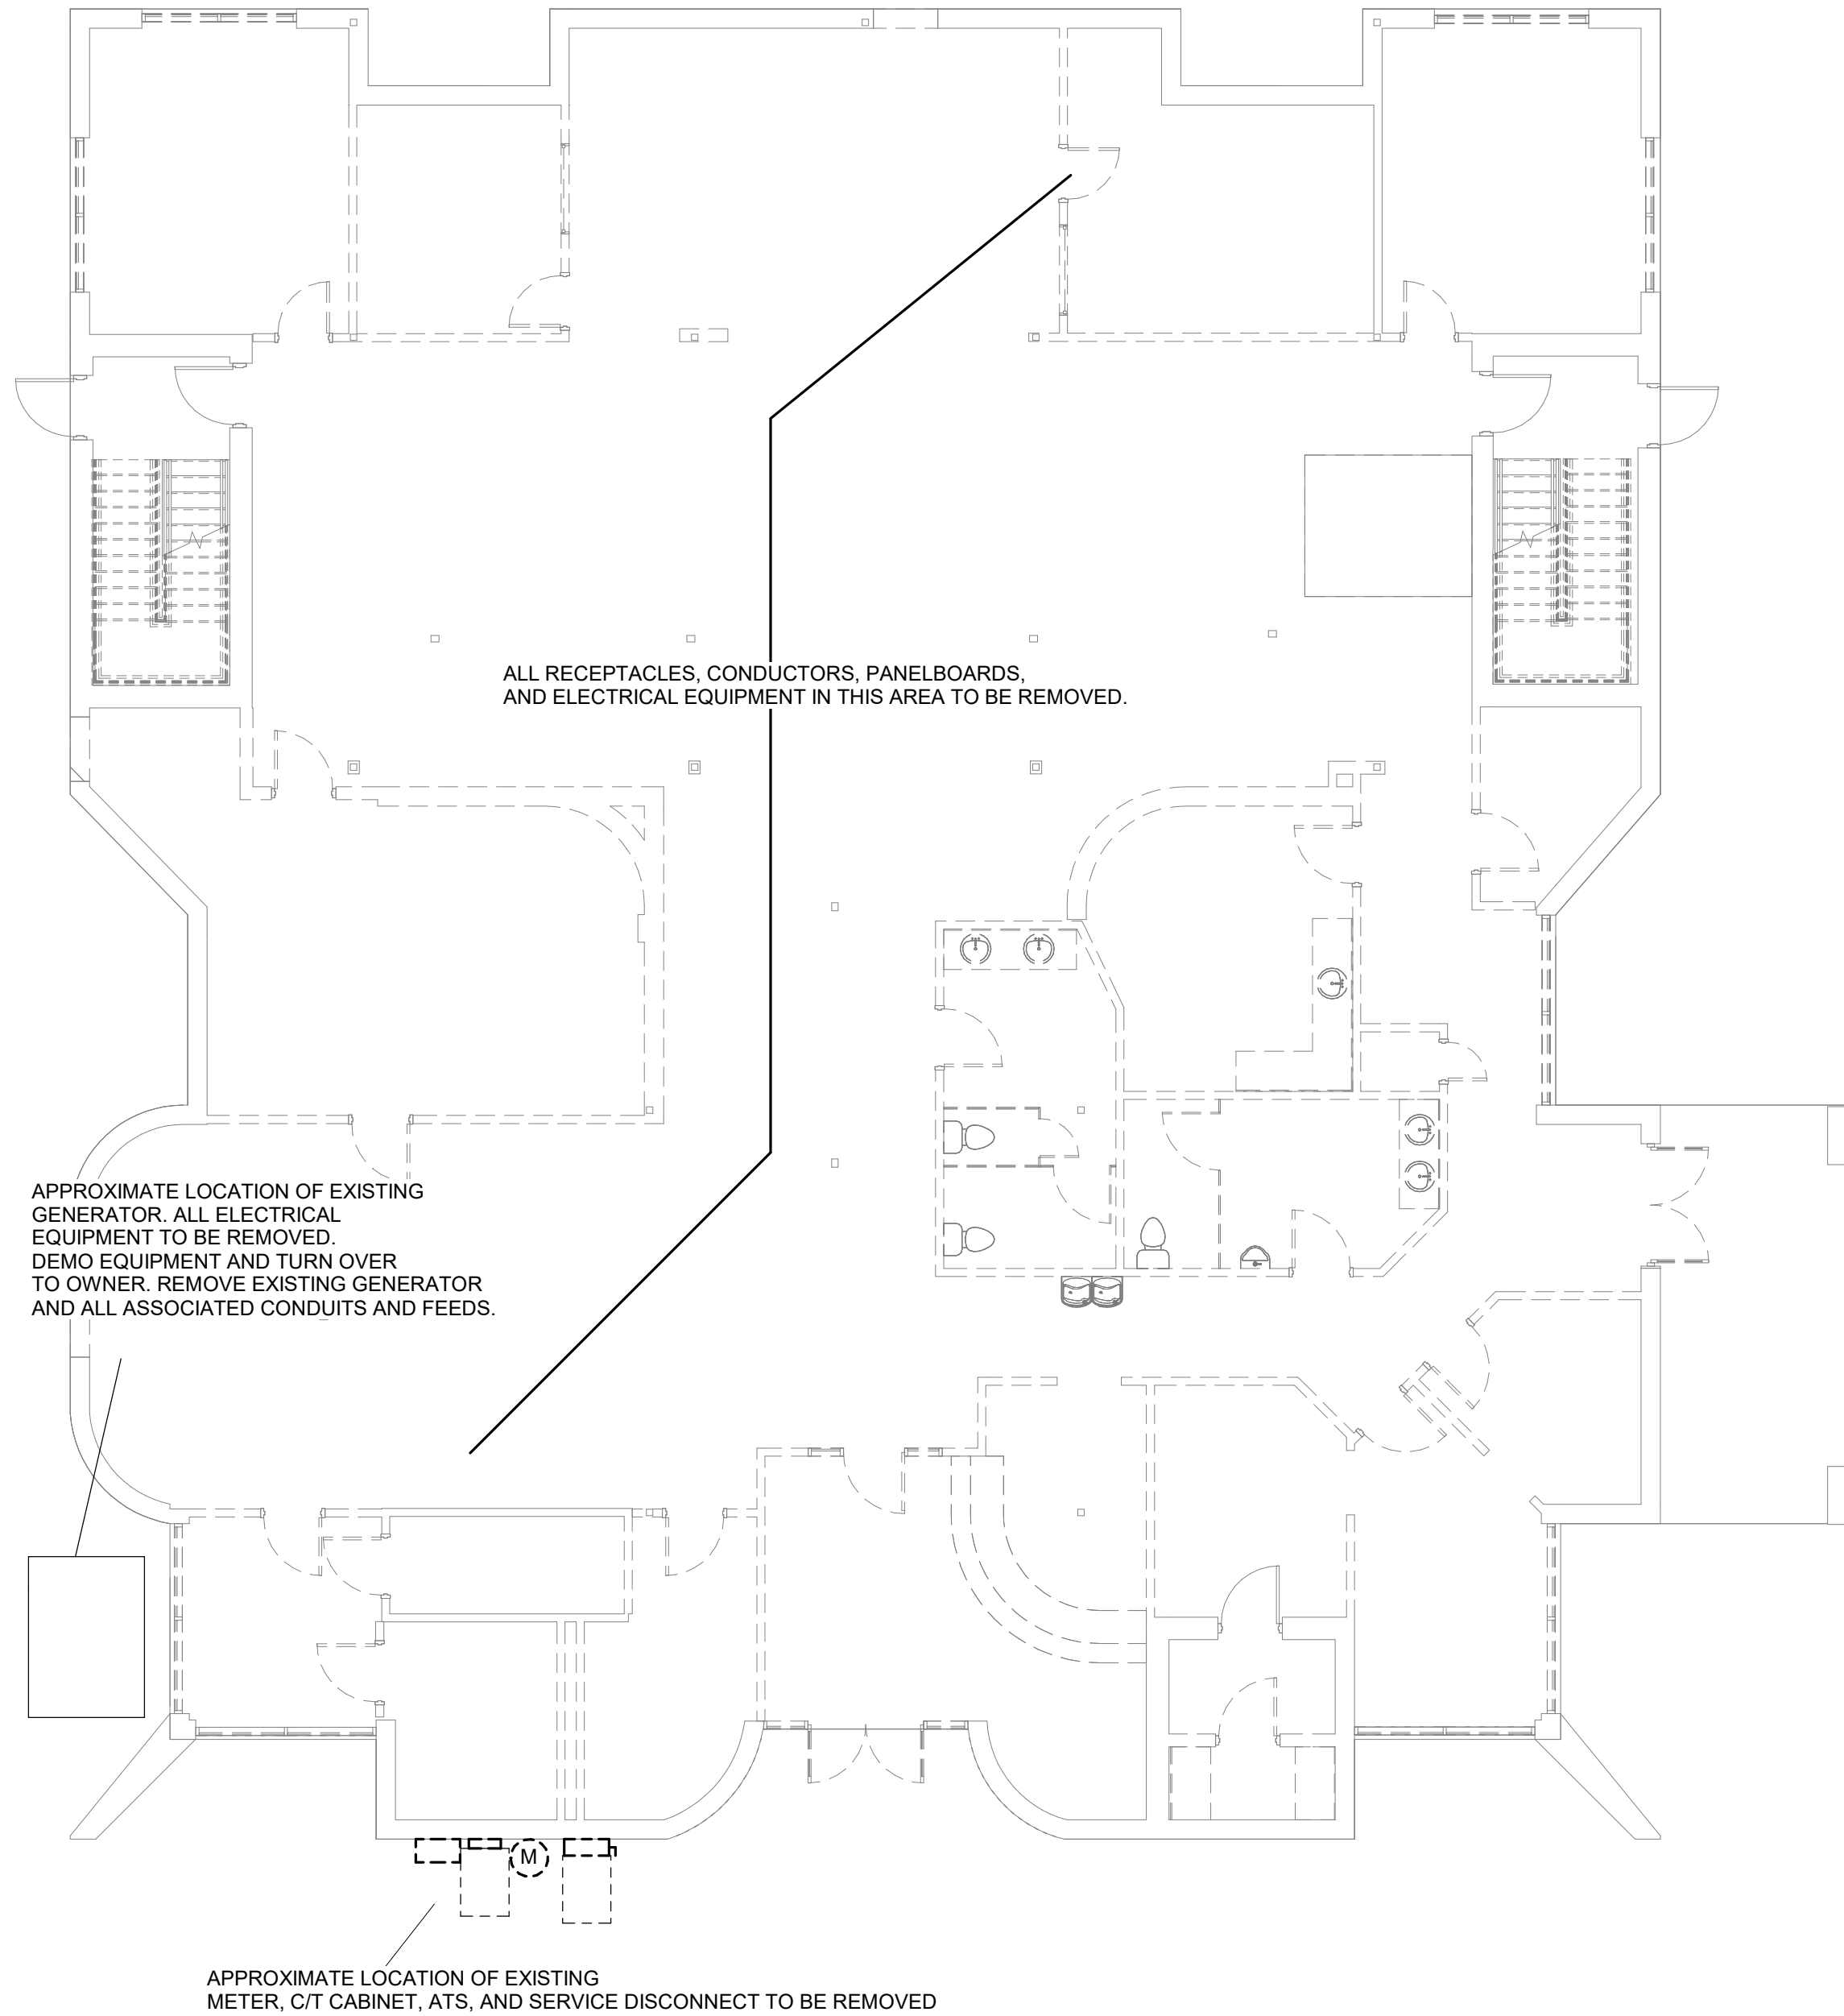

1 FIRST FLOOR PLAN - POWER

1/8" = 1'-0"

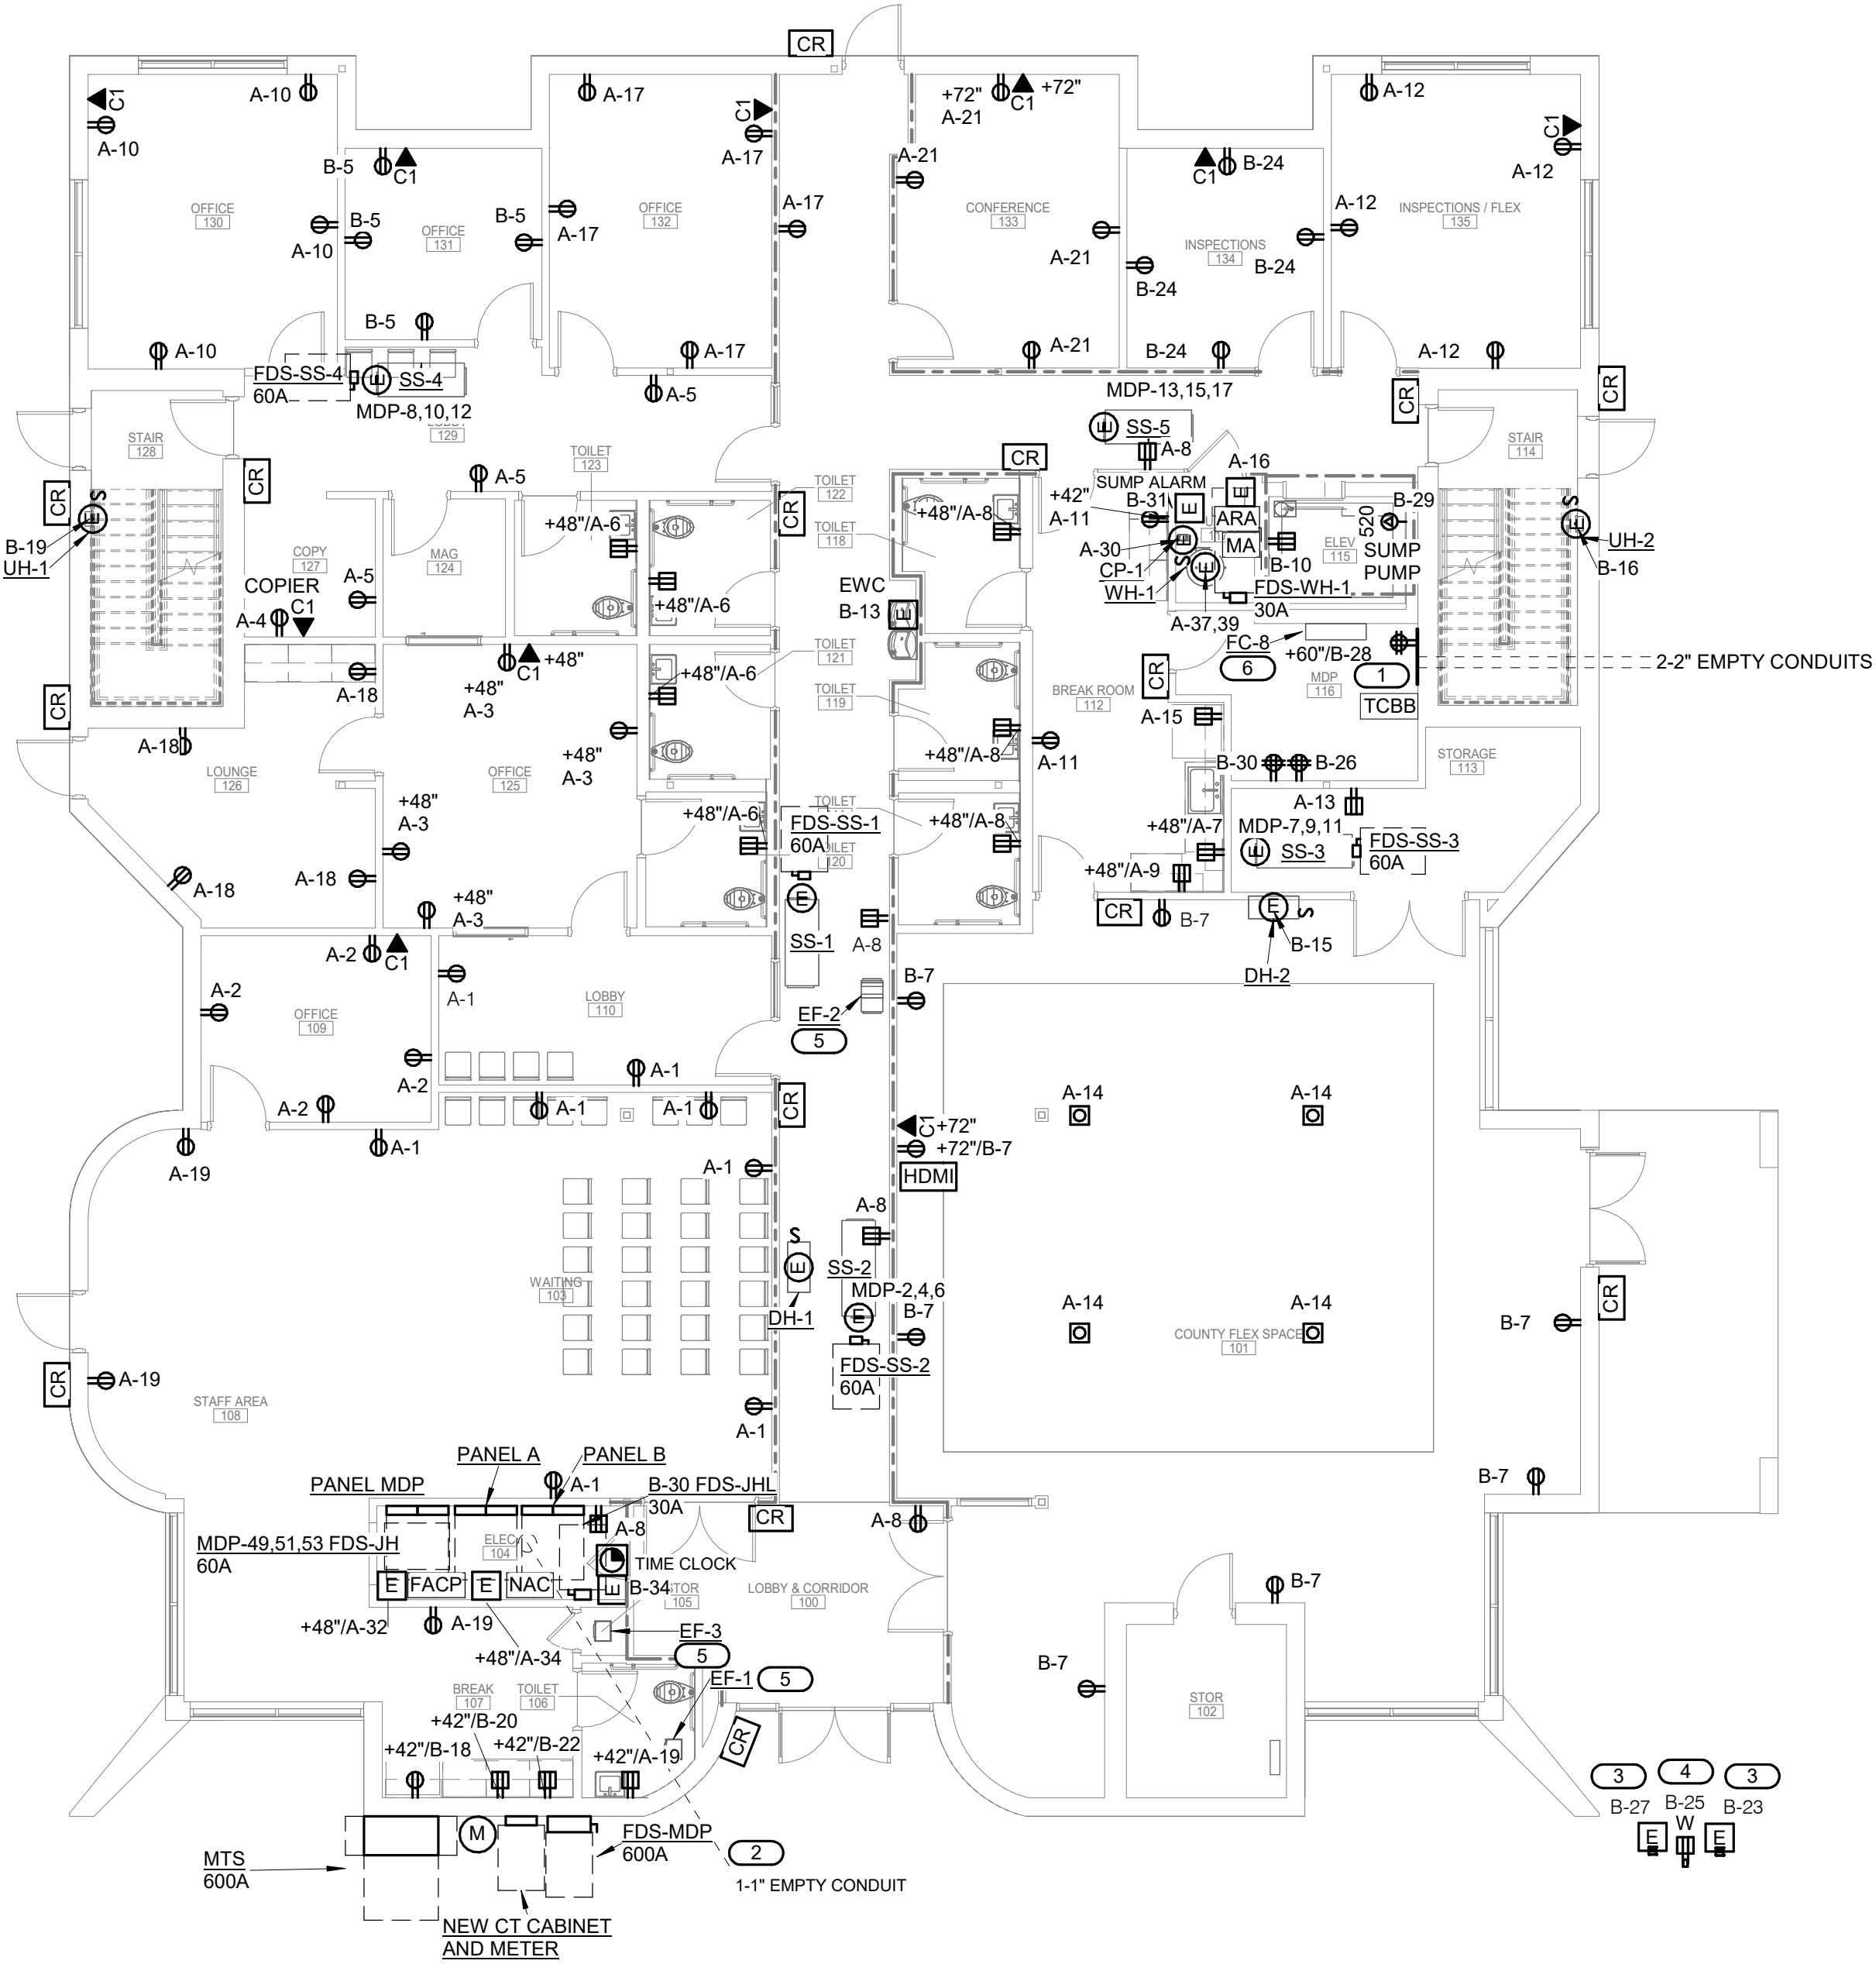

IMEG
www.imegcorp.com
3221 BLUE RIDGE ROAD
SUITE 113
RALEIGH, NC 27612
P. 919.971.1111

IMEG RESERVES PROPRIETARY RIGHTS, INCLUDING COPYRIGHTS, TO THIS DRAWING AND THE DATA SHOWN THEREON. SAID DRAWING AND/OR DATA ARE THE EXCLUSIVE PROPERTY OF IMEG AND SHALL NOT BE USED OR REPRODUCED FOR ANY OTHER PROJECT WITHOUT THE EXPRESS WRITTEN APPROVAL AND PARTICIPATION OF IMEG. ©2026 IMEG CONSULTANTS CORP.

North Carolina Design Registration #E-1507



0 1 2 3
REF. SCALE IN INCHES PROJECT #26001727.00

- KEYNOTES:**
- PROVIDE 2-2" EMPTY CONDUITS TO PROPERTY LINE PER TELEPHONE COMPANY. PROVIDE WITH PULLWIRE. PROVIDE GROUND BAR AND 1-# 6 CU IN 1/2" CONDUIT TO PANEL. MOUNT RECEPTACLE ON BOARD TO ACCOMMODATE EQUIPMENT.
 - PROVIDE 1-1" CONDUIT WITH PULL WIRE FOR FUTURE SITE LIGHTING COORDINATION. FIELD COORDINATE EXACT LOCATION AND ROUTING.
 - FIELD COORDINATE WEATHERPROOF GFPE PROTECTED DUPLEX RECEPTACLE WITH LOCATION OF HOT BOX.
 - FIELD COORDINATE EXACT LOCATION AND CONNECTION OF SITE SIGN.
 - SEE FAN SCHEDULE: M301.
 - INDOOR UNIT POWERED VIA OUTDOOR UNIT CU-8; SEE M301.

RENOVATION FOR:

**CRAVEN COUNTY GOVERNMENT CENTER
EAST**

CRAVEN COUNTY
1208 E. MAIN STREET, HAVELock, NORTH CAROLINA 28532

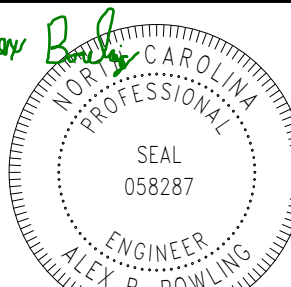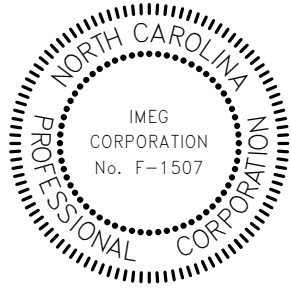

5/24/2026

GENERAL NOTE:
Prior to construction start. Contractor shall verify & be responsible for all Dimensions.


Revisions	Description	Date
#		
Date	Project No.	
05-28-26	26001727.00	
Drawn By	Sheet No.	
Author		
Checked By	E211	
Checker		
Sheet Title	FIRST FLOOR PLAN - POWER	

OAKLEY COLLIER ARCHITECTS
OCA
109 Candlewood Road, Rocky Mount, NC 27804 (P) 252.937.2500
205 W. Martin Street, Raleigh, NC 27601

Copyright © 2025 Oakley Collier Architects. These drawings are of the property of the Architect for use under his supervision. No reproduction or other use is allowed without permission.


2 SECOND FLOOR DEMOLITION PLAN - POWER

1/8" = 1'-0"

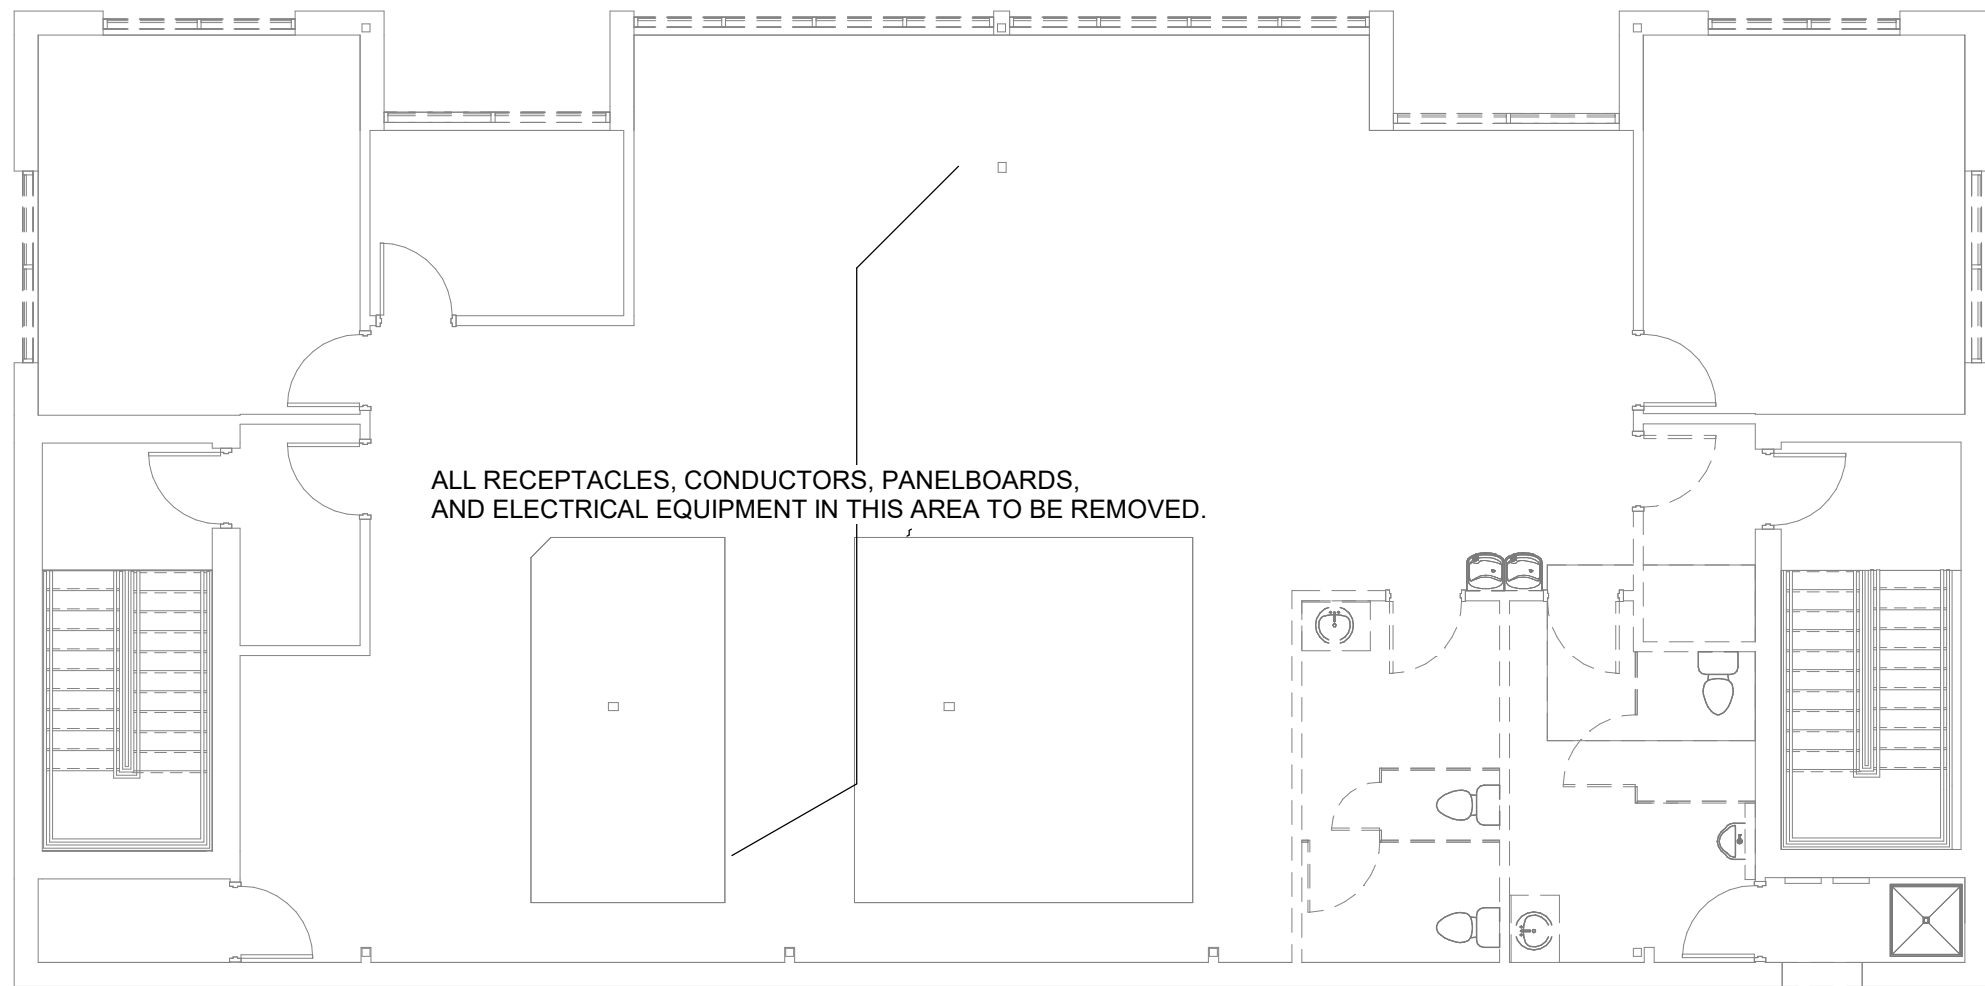

1 SECOND FLOOR PLAN - POWER

1/8" = 1'-0"

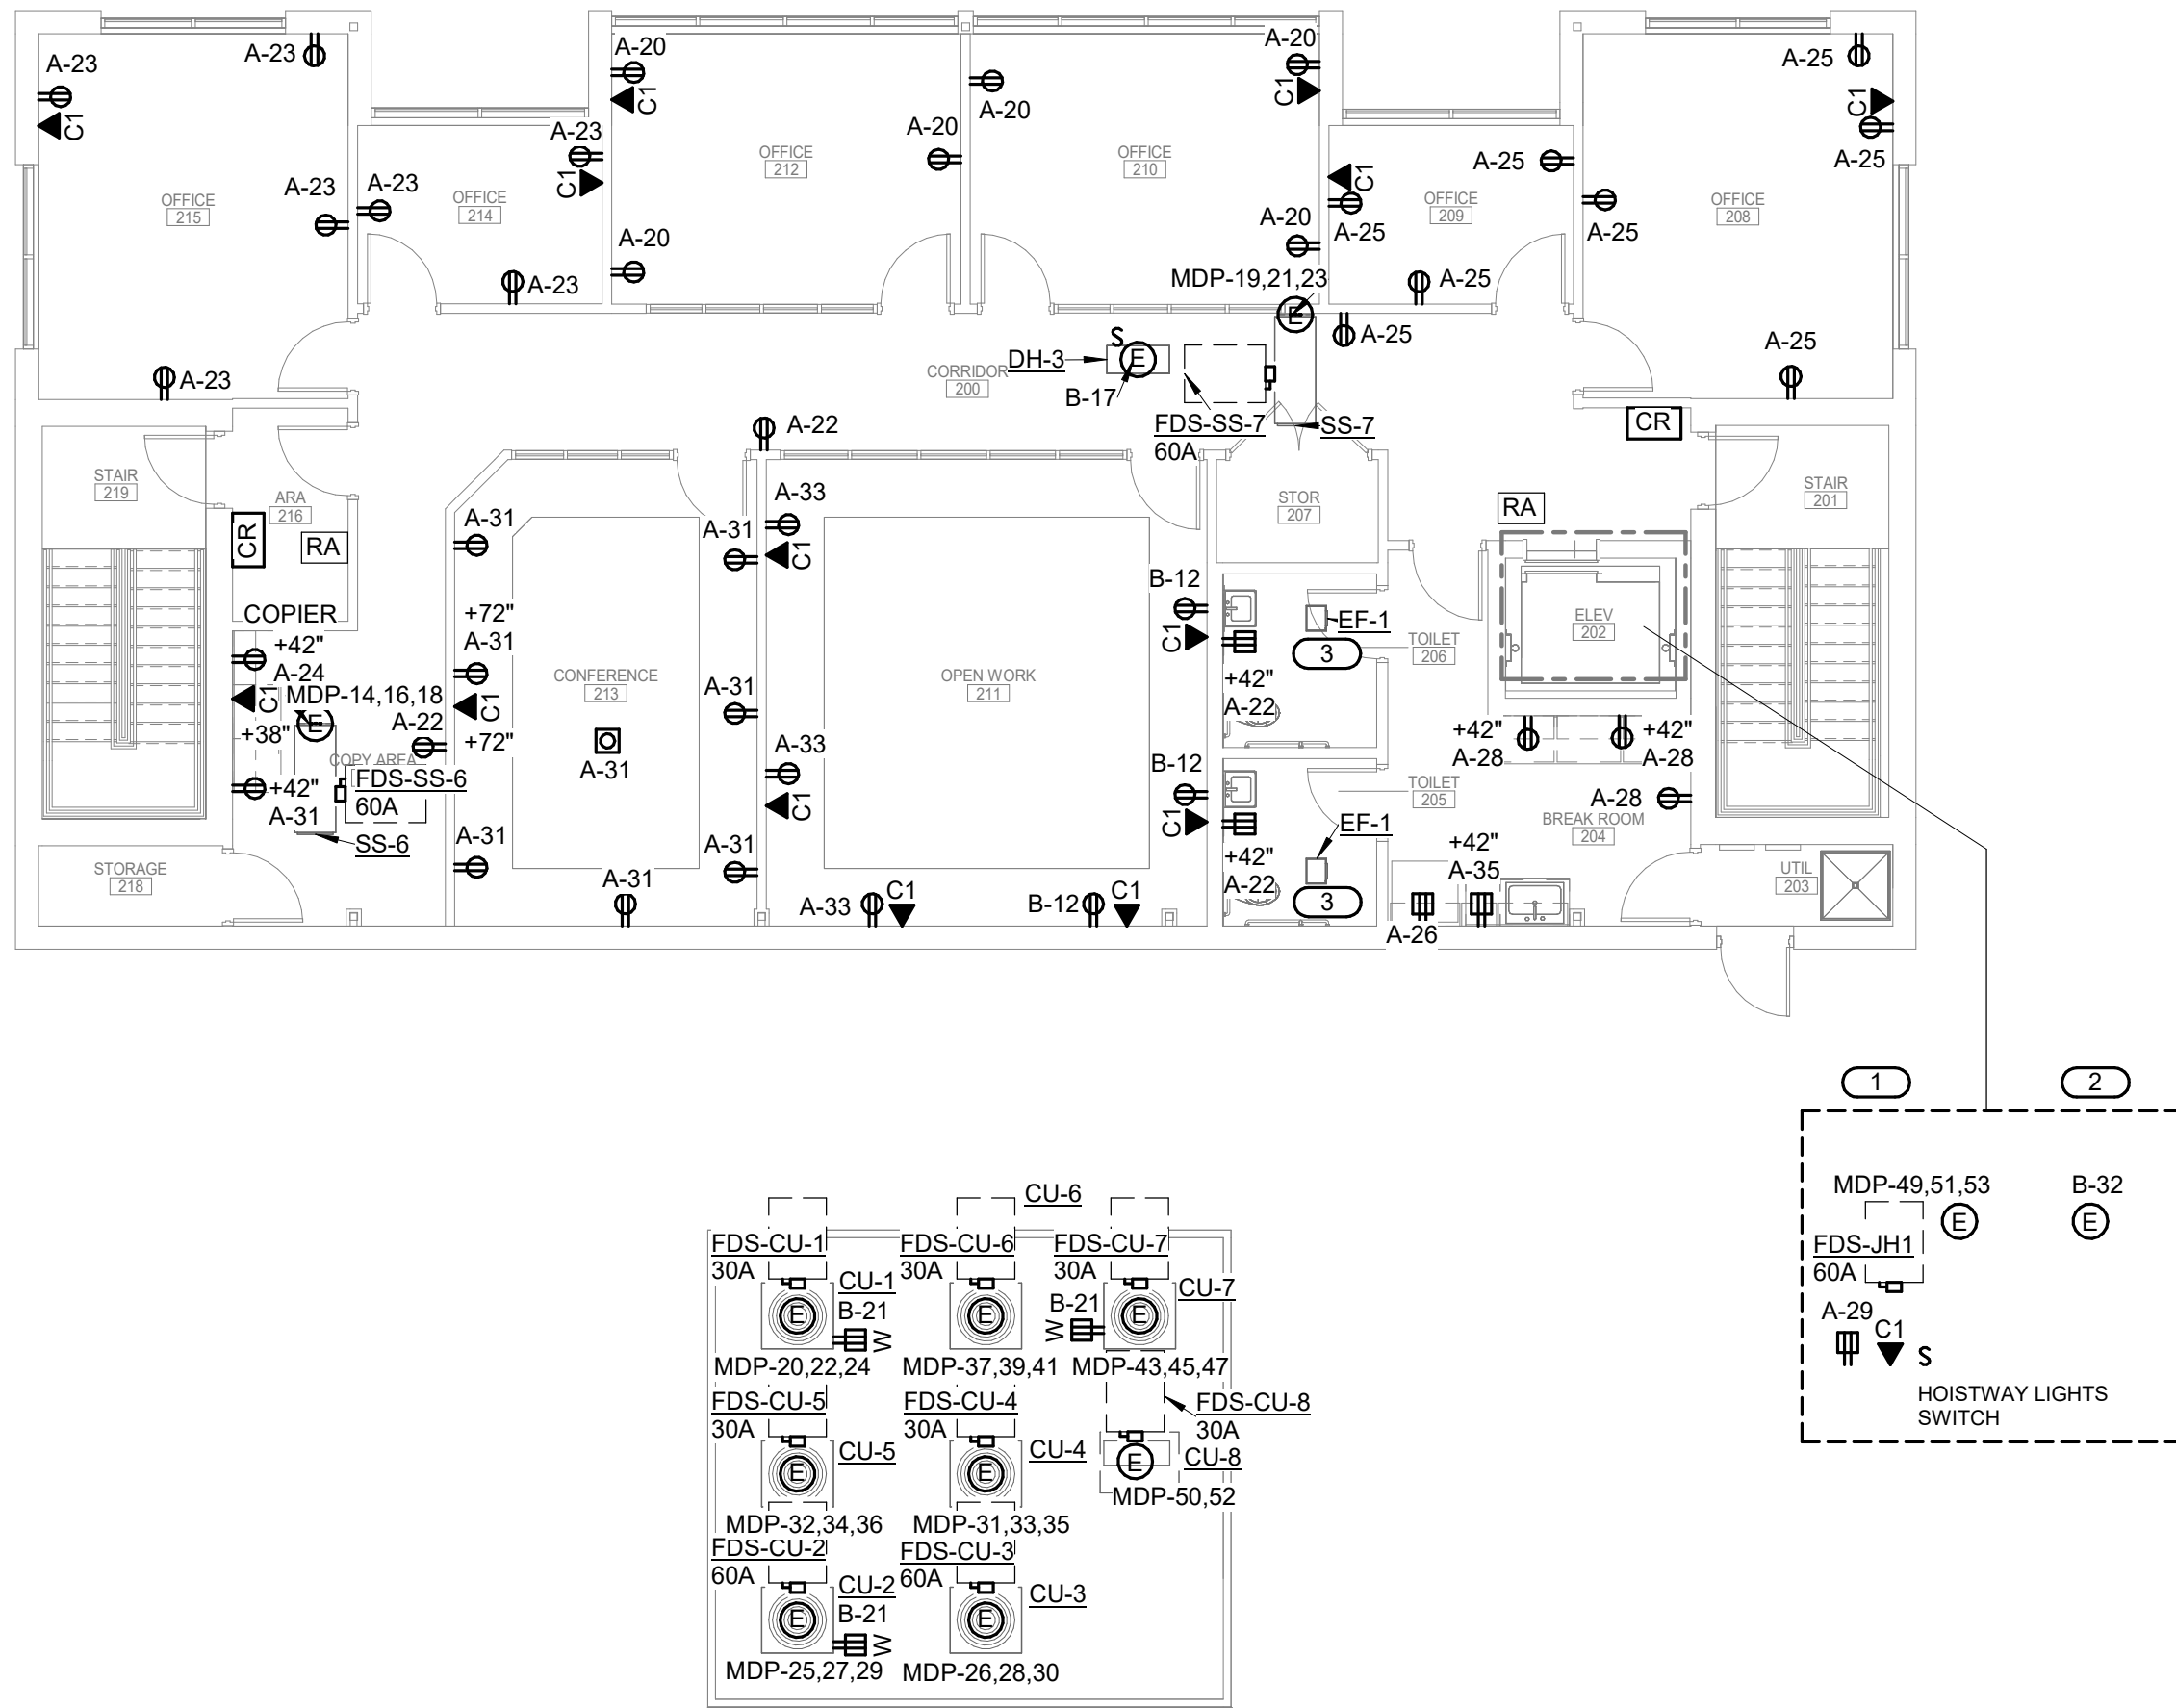

KEYNOTES:

- DISCONNECT LOCATED IN TOP OF ELEVATOR HOISTWAY. COORDINATE WITH ELEVATOR VENDOR.
 - CONNECT VIA DISCONNECT IN ELECTRICAL ROOM. SEE FIRST FLOOR POWER PLAN 2/E211.
 - SEE ELEVATOR SUBMITTALS FOR COORDINATION PRIOR TO ROUGH-IN.
 - PROVIDE LIGHT FIXTURE 'L2' (VAPORTIGHT) IN TOP OF HOISTWAY. SEE SECOND FLOOR LIGHTING PLAN 2/E202.
 - PROVIDE AUXILIARY DRY CONTACT ON DISCONNECT AND CONTROL WIRING ON DISCONNECT PER ELEVATOR SHOP DRAWINGS.
- VERIFY ELEVATOR MACHINE SPACE LOCATION WITH ELEVATOR SHOP DRAWINGS. DISCONNECT SHALL BE FUSED AT 60A WITH DUAL ELEMENT CURRENT LIMITING FUSES.
- SEE FAN SCHEDULE; M301

IMEG
www.imegcorp.com
3221 BLUE RIDGE ROAD
SUITE 113
RALEIGH, NC 27612
P: 919.971.1111



IMEG RESERVES PROPRIETARY RIGHTS, INCLUDING COPYRIGHTS, TO THIS DRAWING AND THE DATA SHOWN THEREON. SAID DRAWING AND/OR DATA ARE THE EXCLUSIVE PROPERTY OF IMEG AND SHALL NOT BE USED OR REPRODUCED FOR ANY OTHER PROJECT WITHOUT THE EXPRESS WRITTEN APPROVAL AND PARTICIPATION OF IMEG.
©2026 IMEG CONSULTANTS CORP.
North Carolina Design Registration #E-1507

0 1 2 3
REF. SCALE IN INCHES PROJECT #26001727.00

RENOVATION FOR:

**CRAVEN COUNTY GOVERNMENT CENTER
EAST**

CRAVEN COUNTY
1208 E. MAIN STREET, HAVELOCK, NORTH CAROLINA 28532

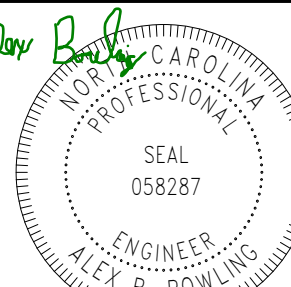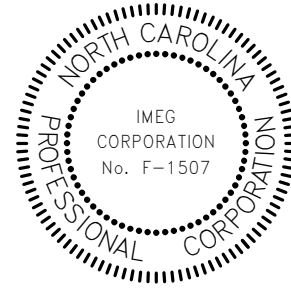

5/24/2026

GENERAL NOTE:
Prior to construction start, Contractor shall verify & be responsible for all Dimensions.

Revisions
Description Date

Date
05-28-26

Project No.
26001727.00

Drawn By
Author

Sheet No.
E212

Checked By
Checker

Sheet Title
SECOND FLOOR PLAN - POWER

OAKLEY
COLLIER
ARCHITECTS
OCA
109 Candlewood Road, Rocky Mount, NC 27804 (P) 252.937.2500
205 W. Martin Street, Raleigh, NC 27601




- a. THE SYSTEM SHALL COMPLY WITH:
 - a. THE AMERICANS WITH DISABILITIES ACT, SECTIONS 4.3.11.4 AND 4.3.11.5
 - b. 2018 NC BUILDING CODE, SECTION 1009.8.1.
 - c. UL LISTED FOR USE AS AN AREA OF RESCUE ASSISTANCE SYSTEM.
2. SIGNAGE:
 - a. AT MAIN STATION, C.E. SHALL POST DIRECTIONS FOR THE USE OF THE TWO-WAY COMMUNICATION SYSTEM ADJACENT TO MAIN STATION IN COMPLIANCE WITH 2018 NC BUILDING CODE SECTION 1009.8.2.
 - b. AT REMOTE STATION, C.E. SHALL POST:
 - DIRECTIONS FOR THE USE OF THE TWO-WAY COMMUNICATION SYSTEM ADJACENT TO REMOTE STATION IN COMPLIANCE WITH 2018 NC BUILDING CODE SECTION 1009.8.2.
 - INSTRUCTION HOW TO USE ARE OF REFUGE IN COMPLIANCE WITH 2018 NC BUILDING CODE SECTION 1009.11.
 - c. AT EACH DOOR PROVIDING ACCESS TO AN AREA OF REFUGE, C.E. SHALL PROVIDE SIGNAGES IN COMPLIANCE WITH 2018 NC BUILDING CODE, SECTION 1009.9.
 - AN ILLUMINATED SIGN ABOVE DOOR ADJACENT TO EXIT SIGN.
 - AREA OF REFUGE GRAPHIC WITH RAISED LETTERING AND BRAILLE DOOR SIGN.
3. SEE FLOOR PLANS FOR QUANTITY AND LOCATION OF ALL EQUIPMENT.
4. LOW VOLTAGE WIRING:
 - a. WIRING SHALL BE CIRCUIT INTEGRITY TYPE CABLE (CI), LISTED FOR 2 HOUR RATING PER MANUFACTURER SPECIFICATIONS.
 - b. WIRING SHALL BE IN CONDUIT.
5. AREA OF RESCUE ASSISTANCE SYSTEM INSTALLATION SHALL BE BY A LICENSED CONTRACTOR.
6. SYSTEM WIRING SHALL BE IN ACCORDANCE WITH GOOD ENGINEERING PRACTICES AS ESTABLISHED BY EIA AND NEC. WIRING SHALL MEET ALL ESTABLISHED STATE AND LOCAL ELECTRICAL CODES. ALL WIRING SHALL BE TYPED FOR FLET, TYPED SHOWINGS AND GROUNDED AS SPECIFIED.
7. MASTER AND REMOTE STATION MOUNTING HEIGHT SHALL BE IN ACCORDANCE WITH ADA RECOMMENDATIONS AND SPECIFICATIONS.
8. DIAGRAM SHOWN IN THIS DETAIL IS BASED ON RATH COMMUNICATIONS SYSTEM AND SHOWN AS A GUIDELINE. ACTUAL SYSTEM AND WIRING SHALL BE PER MANUFACTURER INSTRUCTION.
9. ACCEPTABLE MANUFACTURER:
 - a. RATH COMMUNICATIONS
 - b. ALPHA COMMUNICATIONS
 - c. CORNELL

$$\frac{1}{2}'' = 1'-0''$$

NO SCALE



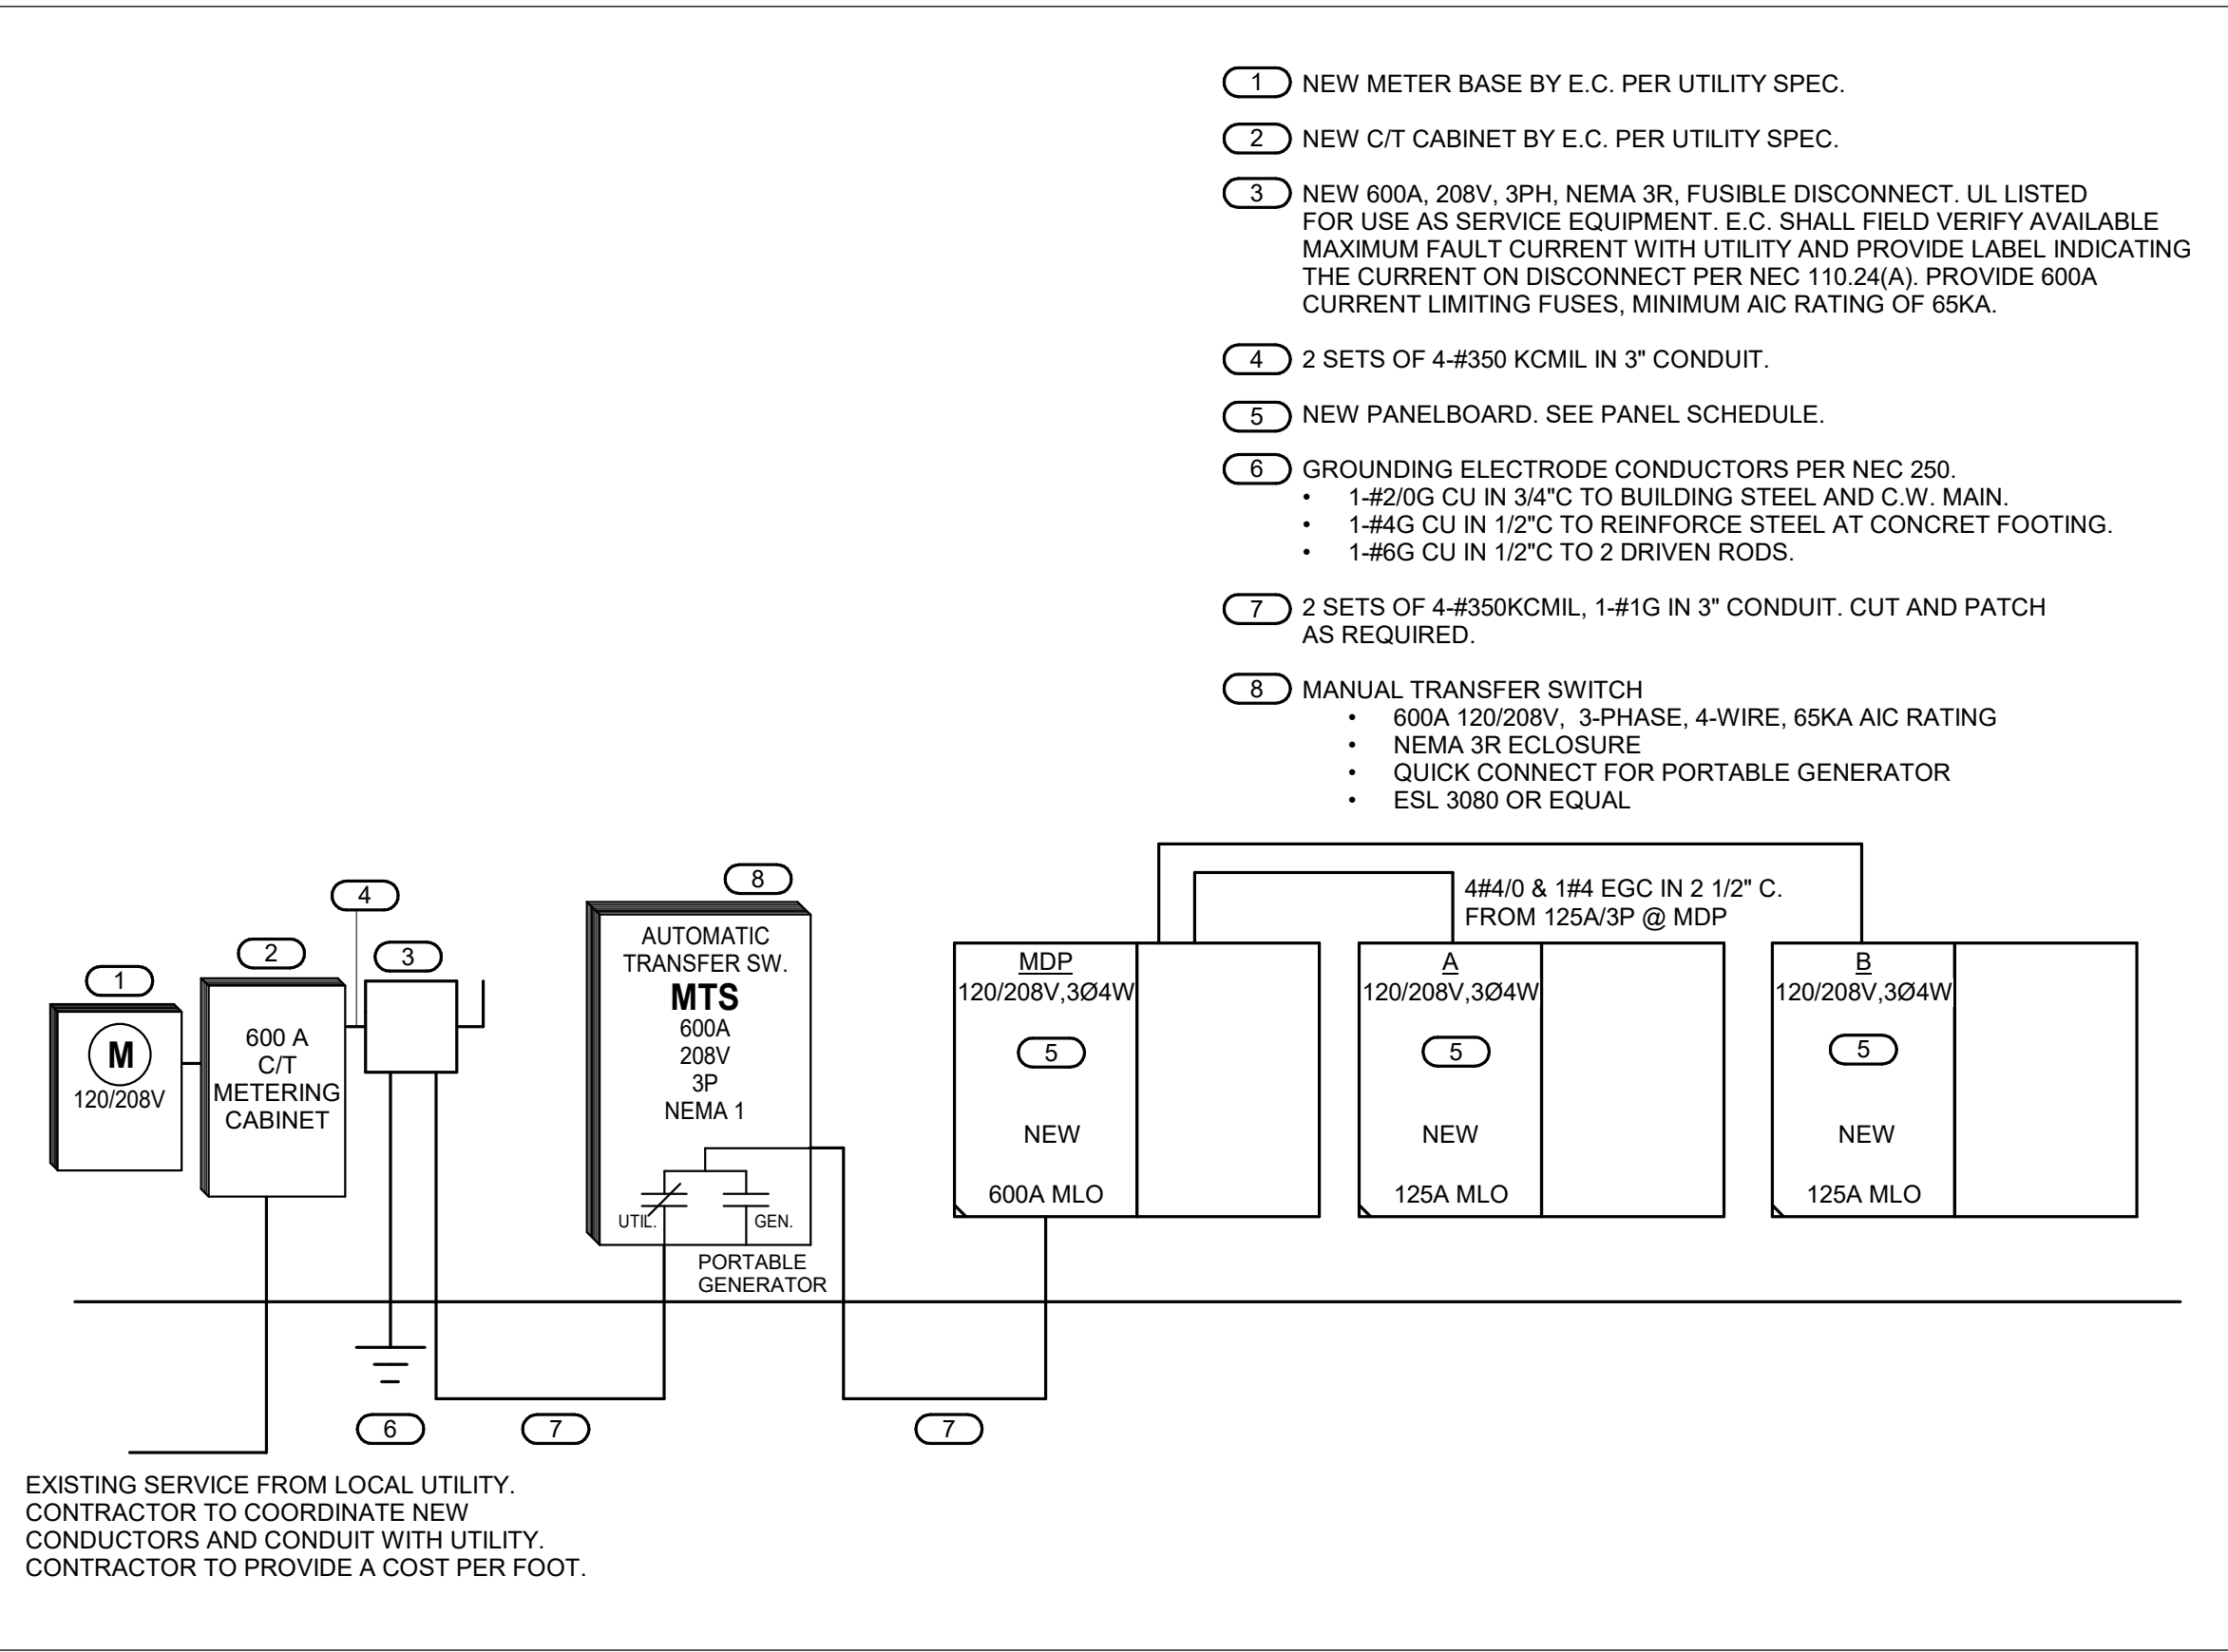

1 POWER RISER DIAGRAM

12" = 1'-0"

MOUNTING: SURFACE ENCLOSURE: NEMA 1 FED FROM: 0/0P @ LOCATION: ELEC 104										PANEL MDP DOUBLE TUB SOLID NEUTRAL GROUND BUS										MAIN: 600 MLO VOLTS: 120/208 Wye PHASE: 3 WIRE: 4 SCCR: 65 kA ISC UNKNOWN 0.00 kA																																																																																																																																																																																																																																																																																																																																																																																																																																																																																																																																																																																																																																																																																																																																																																																																																																																																																																																																																																																																																																																																																																																																																																																																																																																																																																		
NOTES:																																																																																																																																																																																																																																																																																																																																																																																																																																																																																																																																																																																																																																																																																																																																																																																																																																																																																																																																																																																																																																																																																																																																																																																																																																																																																																																						
K E Y	CKT NO.	LOAD DESCRIPTION										OCPD AMPS	P	H	WIRE SIZE N G			A		B		C		WIRE SIZE G N H			P	OCPD AMPS	LOAD DESCRIPTION										CKT NO.	K E Y																																																																																																																																																																																																																																																																																																																																																																																																																																																																																																																																																																																																																																																																																																																																																																																																																																																																																																																																																																																																																																																																																																																																																																																																																																																																														
	1	SS-1										45	3	8	8	10	5.04	4.32	5.04 4.32		5.04 4.32		5.04 4.32		10	8	8	3	45	SS-2										2	3																																																																																																																																																																																																																																																																																																																																																																																																																																																																																																																																																																																																																																																																																																																																																																																																																																																																																																																																																																																																																																																																																																																																																																																																																																																																													
	3																																																																																																																																																																																																																																																																																																																																																																																																																																																																																																																																																																																																																																																																																																																																																																																																																																																																																																																																																																																																																																																																																																																																																																																																																																																																																																																					</

MOUNTING: SURFACE ENCLOSURE: NEMA 1 FED FROM: 125/3P @ MDP LOCATION: ELEC 104						PANEL A DOUBLE TUB SOLID NEUTRAL GROUND BUS						MAIN: 125 MLO VOLTS: 120/208 Wye PHASE: 3 WIRE: 4 SCCR: 10 kA ISC: 0.24 kA											
NOTES:																							
KEY	CKT NO.	LOAD DESCRIPTION	OCPD AMPS	P	WIRE SIZE H N G	A	B	C	WIRE SIZE G N H	P	OCPD AMPS	LOAD DESCRIPTION	CKT NO.	KEY									
	1	WAITING RECPT + LOBBY 110	20	1	12 12 12	1.44	0.72		12 12 12	1	20	OFFICE 109 RECPT	2										
	3	OFFICE AND LOUNGE RECPT	20	1	12 12 12		0.72	0.18		12 12 12	1	20	COPIER DEDICATED RECPT	4									
	5	LOBBY AND COPY RECPT	20	1	12 12 12			0.54	0.72	12 12 12	1	20	BATHRM 120-123	6									
	7	BREAK 112 COUNTER 1	20	1	12 12 12	0.18	1.44			12 12 12	1	20	BATHROOM 111,119,118 AND HALLWAY	8									
	9	BREAK 112 COUNTER 2	20	1	12 12 12		0.18	0.72		12 12 12	1	20	OFFICE 130 +131 RECPT	10									
	11	BREAK 112 + FLEX RECPT	20	1	12 12 12			0.36	0.72	8 8 1	20	INSPECTIONS 134 +135 RECPT	12										
	13	MDP AND STORAGE 113 RECPT	20	1	12 12 12	0.18	0.72			12 12 12	1	20	FLEX 101 RECPT	14									
G	15	BREAK 112 REFRIGERATOR	20	1	12 12 12		0.18	0		12 12 12	1	20	ARA	16									
	17	OFFICE 131+132 RECPT	20	1	12 12 12			0.9	0.72	12 12 12	1	20	LOUNGE RM 126	18									
	19	STAFF 108 + BREAK 107 RECPT	20	1	12 12 12	0.72	1.08			10 10 10	20	OFFICE 212 + 210 RECPT	20										
	21	CONFERENCE 133 RECPT	20	1	12 12 12		0.72	0.9		12 12 12	1	20	TOILET 205+206+ CORRIDOR 200 RECPT	22									
	23	OFFICE 215 +214 RECPT	20	1	10 10 10			1.26	0.18	12 12 12	1	20	COPY 217 DEDICATED RECPT	24									
	25	OFFICE 208 +209 RECPT	20	1	10 10 10	1.26	0.18			12 12 12	1	20	BREAK 204 REFRIGERATOR	26									
	27	ELEVATOR SERVICE RECPT	20	1	12 12 12		0.18	0.54		12 12 12	1	20	BREAK 204 COUNTER 1 RECPT	28									
	29	ELEVATOR MACHINE RECPT	20	1	12 12 12			0.18	0.53	12 12 12	1	15	CP-1	30									
	31	CONFERENCE 213 + COPY 217 RECPT	20	1	12 12 12	1.62	0.5			12 12 12	1	20	FACP	32	LO								
	33	OPEN WORK 211	20	1	12 12 12		0.54	0.5		12 12 12	1	20	NAC	34	LO								
	35	BREAK 204 COUNTER 2 RECPT	20	1	12 12 12			0.18	0.7	12 12 12	1	20	PC + EXTERIOR LIGHTING	36									
	37	WH-1	30	2	10 10 10	2.25	0			-- --	1	20	SPARE	38	--								
	39						2.25	0		-- --	1	20	SPARE	40	--								
--	41	SPARE	20	1	-- -- --			0	0	-- --	1	20	SPARE	42	--								
--	43	SPARE	20	1	-- -- --	0	0			-- --	1	20	SPARE	44	--								
--	45	SPARE	20	1	-- -- --		0	0		-- --	1	20	SPARE	46	--								
--	47	SPARE	20	1	-- -- --			0	0	-- --	1	20	SPARE	48	--								
--	49	SPACE	--	1	-- -- --	-- --				-- --	1	--	SPACE	50	--								
--	51	SPACE	--	1	-- -- --	-- --	-- --			-- --	1	--	SPACE	52	--								
--	53	SPACE	--	1	-- -- --	-- --	-- --	-- --		-- --	1	--	SPACE	54	--								
Total Load:						12.29 kVA	7.61 kVA	6.99 kVA															
Total Amps:						103.21	64.21	58.27															
LOAD SUMMARY																							
LOAD CLASSIFICATION			CONNECTED LOAD	DEMAND FACTOR		ESTIMATED DEMAND		TOTALS*															
Lighting			0.704 kVA	100.00%		0.704 kVA																	
Power			6.028 kVA	100.00%		6.028 kVA		TOTAL CONNECTED LOAD:							26.89 kVA								
Receptacles			20.16 kVA	74.80%		15.08 kVA		TOTAL ESTIMATED DEMAND LOAD:							21.812 kVA								
								TOTAL CONNECTED AMPS:							74.65 A								
								TOTAL ESTIMATED DEMAND AMPS:							60.5								
*TOTAL DEMAND CALCS SUBTRACT ANY REDUNDANT LOAD AND THE SMALLER OF ANY NONCOINCIDENT HVAC LOADS. THIS CALC IS DONE AT EACH PANEL.																							
CIRCUIT KEY NOTES: SEE ELECTRICAL DISTRIBUTION AND PANEL SCHEDULE NOTES																							

MOUNTING: SURFACE ENCLOSURE: NEMA 1 FED FROM: 125/3P @ MDP LOCATION: ELEC 104					PANEL B DOUBLE TUB SOLID NEUTRAL GROUND BUS					MAIN: 125 MLO VOLTS: 120/208 Wye PHASE: 3 WIRE: 4 SCCR: 10 kA ISC: 0.23 kA				
NOTES:														
KEY	CKT NO.	LOAD DESCRIPTION	OCPD AMPS	P	WIRE SIZE H N G	A	B	C	WIRE SIZE G N H	P	OCPD AMPS	LOAD DESCRIPTION	CKT NO.	KEY
	1	FIRST FLOOR Q3	20	1	8 8 8 8	1.79 0.85			10 10 10 1	20		2ND FLOOR COORIDOR/BATHRM LIGHTS	2	
	3	FIRST FLOOR Q2	20	1	10 10 10 10		1.3 0.56		12 12 12 1	20		2ND FLOOR COMMON AREA LIGHTS	4	
	5	OFFICE 131 RECPT	20	1	12 12 12 12			0.72 1.6	8 8 8 1	20		FIRST FLOOR Q1 LIGHTS	6	
	7	COUNTY FLEX SPACE WALL RECPT	20	1	12 12 12 12	1.44 0.67			12 12 12 1	20		FIRST FLOOR COORIDOR LIGHTS	8	
	9	2ND FLOOR OFFICES LIGHTS	20	1	10 10 10 10		0.86 0.18		12 12 12 1	20		ARA AND ELEVATOR RECEPT	10	
	11	STAIRWELL LIGHTS	20	1	10 10 10 10			0.91 0.54	12 12 12 1	20		OPEN WORK 211 RECPT	12	
G	13	WATER COOLER POWER	20	1	12 12 12 12	0.5 0.67			10 10 10 1	30		DEHUMIDIFIER 1	14	
	15	DEHUMIDIFIER 2	30	1	10 10 10 10		0.67 1.5		12 12 12 1	15		UNIT HEATER 2	16	
	17	DEHUMIDIFIER 3	30	1	10 10 10 10			0.67 0.18	12 12 12 1	20		BREAK 107 RECPT	18	
	19	UNIT HEATER 1	20	1	12 12 12 12	1.5 0.18			12 12 12 1	20		BREAK 107 RECPT	20	
	21	ROOFTOP RECPT	20	1	12 12 12 12		0.54 0.18		12 12 12 1	20		BREAK 107 RECPT	22	
	23	SIGN LIGHTING	20	1	12 12 12 12			0.5 0.72	12 12 12 1	20		INSPECTION 134 RECPT	24	
GP	25	HOT BOX RECPT	20	1	12 12 12 12	0.18 0.18			12 12 12 1	20		MDP 116	26	
	27	SIGN LIGHTING	20	1	12 12 12 12		0.5 0.36		12 12 12 1	20		TCBB RECEPT	28	
G	29	SUMP PUMP RECPT ELEVATOR	20	1	12 12 12 12			1.18 0.18	12 12 12 1	20		MDP 116	30	
	31	SUMP ALARM	20	1	12 12 12 12	0.1 0.5			12 12 12 1	20		ELEVATOR CAR LIGHTS/CONTROLS	32	
--	33	SPARE	20	1	-- -- -- --		0 0		12 12 12 1	20		TIME CLOCK	34	
--	35	SPARE	20	1	-- -- -- --			0 0	-- -- -- 1	20		SPARE	36	--
--	37	SPARE	20	1	-- -- -- --	0 0			-- -- -- 1	20		SPARE	38	--
--	39	SPARE	20	1	-- -- -- --		0 0		-- -- -- 1	20		SPARE	40	--
--	41	SPARE	20	1	-- -- -- --			0 0	-- -- -- 1	20		SPARE	42	--
--	43	SPARE	20	1	-- -- -- --	0 0			-- -- -- 1	20		SPARE	44	--
--	45	SPACE	--	1	-- -- -- --		-- --		-- -- -- 1	--		SPACE	46	--
--	47	SPACE	--	1	-- -- -- --			-- --	-- -- -- 1	--		SPACE	48	--
--	49	SPACE	--	1	-- -- -- --	-- --			-- -- -- 1	--		SPACE	50	--
--	51	SPACE	--	1	-- -- -- --		-- --		-- -- -- 1	--		SPACE	52	--
--	53	SPACE	--	1	-- -- -- --				-- -- -- 1	--		SPACE	54	--
Total Load:						8.56 kVA	6.65 kVA	7.19 kVA						
Total Amps:						71.99	55.44	60.60						
LOAD SUMMARY														
LOAD CLASSIFICATION			CONNECTED LOAD	DEMAND FACTOR	ESTIMATED DEMAND		TOTALS*							
Lighting			8.532 kVA	100.00%	8.532 kVA					TOTAL CONNECTED LOAD:			22.40 kVA	
Power			7.11 kVA	100.00%	7.11 kVA					TOTAL ESTIMATED DEMAND LOAD:			22.398 kVA	
Receptacles			6.756 kVA	100.00%	6.756 kVA					TOTAL CONNECTED AMPS:			62.17 A	
										TOTAL ESTIMATED DEMAND AMPS:			62.2	
*TOTAL DEMAND CALCS SUBTRACT ANY REDUNDANT LOAD AND THE SMALLER OF ANY NONCONCIDENT HVAC LOADS. THIS CALC IS DONE AT EACH PANEL.														
CIRCUIT KEY NOTES: SEE ELECTRICAL DISTRIBUTION AND PANEL SCHEDULE NOTES														

DISCONNECT AND STARTER SCHEDULE

NOTE: ALL DISCONNECTS (EXCEPT MANUAL STARTERS) SHALL BE HEAVY DUTY TYPE.							
DISCONNECT TYPE:		ACCESSORIES & OPTIONS					
FU - FUSED		SA - STANDARD ACCESSORIES...		PF - PHASE LOSS PROTECTION (5 HP OR GREATE...			
NF - NON-FUSED		*CT - CONTROL TRANSFORMER, FUSED...		TO - MELTING THERMAL OVERLOADS (1 PHASE)			
CB - CIRCUIT BREAKER		*EO - ELECTRONIC OVERLOAD (3 PHASE...		TS - 2 SPEED SELECTOR SWITCH IN DOOR			
		*HA - HAND-OFF-AUTO IN DOOR		GP - GREEN (OFF) PILOT LIGHT IN DOOR			
STARTER TYPE:		*RP - RED (RUN) PILOT LIGHT IN DOOR		FA - 4-CONVERTIBLE AUXILIARY CONTACTS			
FV - FULL VOLTAGE		*TA - TWO CONVERTIBLE AUXILIARY...		EI - ELECTRICAL INTERLOCK (2)-N.O. & (2)-N.C.			
YD - WYE - DELTA		S/N - INSULATED NEUTRAL ASSEMBLY		SS - START-STOP PUSHBUTTON IN DOOR			
RE - REVERSING				HL - HANDLE PADLOCK HASP			
MX - MANUAL SWITCH							
ITEM	DISCONNECT TYPE & RATING			VOLTAGE	POLES	ENCLOSURE	COMMENTS
	TYPE	RATING	TRIP RATING				
FDS-CU-1	FU	30	25	208	3	NEMA 3R	
FDS-CU-2	FU	60	35	208	3	NEMA 3R	
FDS-CU-3	FU	60	35	208	3	NEMA 3R	
FDS-CU-4	FU	30	25	208	3	NEMA 3R	
FDS-CU-5	FU	30	25	208	3	NEMA 3R	
FDS-CU-6	FU	30	25	208	3	NEMA 3R	
FDS-CU-7	FU	30	25	208	3	NEMA 3R	
FDS-CU-8	FU	30	25	208	3	NEMA 3R	
FDS-JH	FU	60	30	208	3	NEMA 1	
FDS-JH1	FU	60	60	208	3	NEMA 1	
FDS-JHL	FU	30	20	120	1	NEMA 1	
FDS-MDP	FU	600	600	208	3	NEMA 3R	
FDS-SS-1	FU	60	45	208	3	NEMA 1	
FDS-SS-2	FU	60	45	208	3	NEMA 1	
FDS-SS-3	FU	60	45	208	3	NEMA 1	
FDS-SS-4	FU	60	45	208	3	NEMA 1	
FDS-SS-6	FU	60	45	208	3	NEMA 1	
FDS-SS-7	FU	60	45	208	3	NEMA 1	
FDS-WH-1	FU	30	30	208	3	NEMA 1	

Luminaire Schedule (design)

TAG	DESCRIPTION	MTG	LIGHT SOURCE	DELIVERED LUMENS	ANSI WATTS	PER	VOLTAGE	MANUFACTURER SERIES	NOTES
A	2X4 FLAT PANEL	RE	LED	4,677 lm	39	FIX	120	LITHONIA CPX 2X4 ALO8 SWW7	OR SIMILAR
A/EM	2X4 BATTERY BACKUP FLAT PANEL	RE	LED	4,677 lm	39	FIX	120	LITHONIA CPX 2X4 ALO8 SWW7	OR SIMILAR
B	2X2 FLAT PANEL	RE	LED	3,356 lm	32	FIX	120	LITHONIA CPX 2X2 ALO7 SWW7	OR SIMILAR
B/EM	2X2 FLAT PANEL BATTERY BACKUP	RE	LED	3,356 lm	32	FIX	120	LITHONIA CPX 2X2 ALO7 SWW7	OR SIMILAR
C1	STANDARD DOWNLIGHT	RE	LED	2,000 lm	9	FIX	120	LITHONIA LBR8 ALO2 SWW1	OR SIMILAR
EM#	EMERGENCY UNIT - 2 HEAD	WL	<varies>	<varies>	0	FIX	120	LITHONIA ELM6L LTP	OR SIMILAR
EXG	SINGLE-FACE EXIT SIGN	CL	LED	0 lm	0	FIX	120	LITHONIA LHQM	OR SIMILAR
F2EM	2 FT BATTERY BACKUP/LINEAR RECESSED CHANNEL	RE	LED	1,061 lm	9	FIX	120	ALCON 12100-20-R- D9	OR SIMILAR
F4	4 FT VERTICAL LINEAR RECESSED CHANNEL	RE	LED	820 lm	7	FIX	120	ALCON 12100-20-R- D6	OR SIMILAR
F4EM	4 FT BATTERY BACKUP/LINEAR RECESSED CHANNEL	RE	LED	820 lm	7	FIX	120	ALCON 12100-20-R- D6	OR SIMILAR
F6	6 FT VERTICAL LINEAR RECESSED CHANNEL	RE	LED	820 lm	12	FIX	120	ALCON 12100-20-R- D6	OR SIMILAR
L4	4 FT LINEAR LED SYSTEM SURFACE	SM	LED	4,333 lm	38	FT	120	CSS L48 ALO15 MVOLT ZT	OR SIMILAR
L4/EM	4 FT BATTER BACKUP LINEAR LED SYSTEM SURFACE	SM	LED	3,000 lm	50	FT	120	LITHONIA LL# 3000LM 80CRI 35K ZT	OR SIMILAR
VP	4 FT BATTERY BACKUP LINEAR LED SYSTEM VAPORTIGHT	SM	LED	2,648 lm	19	FT	120	CSVLT L48 ALO3 MVOLT SWW3 80CRI	OR SIMILAR
WP	WALL MOUNTED PACK LIGHT	WL	LED	1,500 lm	70	FIX	120	LITHONIA WDGE1	OR SIMILAR

LUMINAIRE SHADING KEY

- NORMAL BRANCH LUMINAIRE
- ⊗

FIXTURE WITH INTEGRAL BATTERY BACKUP

LUMINAIRE CIRCUIT AND CONTROL KEY

- LUMINAIRE
- E1 = FIXTURE TAG
1 = CIRCUIT NUMBER
a = SWITCH DESIGNATION
z1=ZONE DESIGNATION
"NL" INDICATES LUMINAIRE IS UNSWITCHED FOR NIGHT LIGHT.
*IF LABEL IS ORIENTED HORIZONTALLY A SLASH WILL SEPARATE THIS INFORMATION. EX: F1 / 1 / a / NL

ELECTRICAL SYMBOL LIST

SYMBOL:	TAG:	DESCRIPTION:
		LINEAR LUMINAIRES
		TROFFER
		WALL SCONCE LUMINAIRE
		DOWNLIGHT LUMINAIRE
		AIMABLE OR WALL WASH LUMINAIRE
	REFER TO LUMINAIRE SCHEDULE	INDUSTRIAL LUMINAIRE
		WALL BRACKET LUMINAIRE
		POLE MOUNTED LUMINAIRE
		SINGLE FACE EXIT SIGN
		DOUBLE FACE EXIT SIGN
		WALL/CEILING EMERGENCY EXIT SIGN
		EMERGENCY UNIT



3221 BLUE RIDGE ROAD
SUITE 113
RALEIGH, NC 27612
P: 919.971.1111

www.imegcorp.com

IMEG RESERVES PROPRIETARY RIGHTS, INCLUDING COPYRIGHTS, TO THIS DRAWING AND THE DATA SHOWN THEREON. SAID DRAWING AND/OR DATA ARE THE EXCLUSIVE PROPERTY OF IMEG AND SHALL NOT BE USED OR REPRODUCED FOR ANY OTHER PROJECT WITHOUT THE EXPRESS WRITTEN APPROVAL AND PARTICIPATION OF IMEG.
©2026 IMEG CONSULTANTS CORP.
North Carolina Design Registration #F-1507

0123

REF. SCALE IN INCHES

PROJECT #26001727.00

RENOVATION FOR:

CRAVEN COUNTY GOVERNMENT CENTER
EAST



CRAVEN COUNTY

1208 E. MAIN STREET, HAVELOCK, NORTH CAROLINA 28532

OAKLEY COLIER ARCHITECTS

OCA

109 Candlewood Road, Rocky Mount, NC 27804 (P) 252.937.2500
205 W. Martin Street, Raleigh, NC 27601

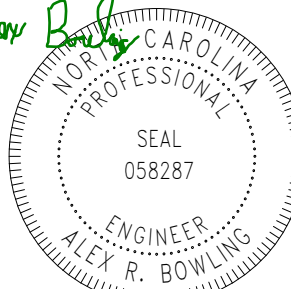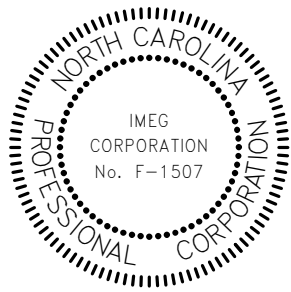

GENERAL NOTE: Prior to construction start, Contractor shall verify & be responsible for all Dimensions.		
Revisions		
#	Description	Date
Date	Project No.	
05-28-26	26001727.00	
Drawn By	Sheet No.	
Author		
Checked By	E601	
Checker		
Sheet Title		
ELECTRICAL SCHEDULES		

Copyright © 2025 Oakley Collier Architects. These drawings are of the property of the Architect for use under his supervision. No reproduction or other use is allowed without permission.

SEQUENCE OF OPERATION		PANEL/ANNUNCIATOR ALARM INDICATION	PANEL/ANNUNCIATOR SUPERVISORY INDICATION	PANEL/ANNUNCIATOR TROUBLE INDICATION	AUDIBLE ALARMS SEQUENCE	VISUAL ALARMS SEQUENCE	ELECTRIC SPRINKLER BELL SEQUENCE	SPRINKLER PREACTION ACTIVATION SEQUENCE	SMOKE DAMPER CONTROL SEQUENCE	AHU & MECHANICAL FAULT SHUTDOWN SEQUENCE	ELEVATOR RECALL SEQUENCE	ELEVATOR SHUT DOWN SEQUENCE	FIREFIGHTER'S CAB VISUAL ALARM SEQUENCE	ELEVATOR HOISTWAY DAMPER SEQUENCE
FIRE ALARM PANEL, TRANSPONDER, NAC PANEL LOW BATTERY			X											
FIRE ALARM PANEL, TRANSPONDER, NAC PANEL BATTERY OR CHARGER FAILURE				X										
FIRE ALARM PANEL, TRANSPONDER, NAC PANEL ABNORMAL SWITCH OR CONTROL POSITION			X											
FIRE ALARM PANEL, TRANSPONDER, NAC PANEL GROUND FAULT, OPEN CIRCUIT, SHORT CIRCUIT				X										
FIRE ALARM PANEL, TRANSPONDER, NAC PANEL AC POWER LOSS OR IRREGULARITY				X										
NOTIFICATION APPLIANCE CIRCUIT OR SLC LOOP GROUND FAULT, OPEN CIRCUIT, SHORT CIRCUIT				X										
INITIATING DEVICE FAILURE OR COMMUNICATION ERROR				X										
FIRE ALARM PANEL MANUAL FIRE DRILL			X		X	X								
MANUAL PULL STATION		X			X	X			X	X				
SMOKE DETECTOR		X			X	X			X	X				
HEAT DETECTOR		X			X	X			X	X				
SMOKE DETECTORS IN ELEVATOR LOBBIES		X			X	X			X	X	X			X
SMOKE DETECTORS IN ELEVATOR MACHINE ROOM & HOISTWAY		X			X	X			X	X	X		X	X
HEAT DETECTOR NEAR ELEVATOR SPRINKLERS		X			X	X			X	X		X		
ELEVATOR SHUNT TRIP CIRCUIT POWER FAILURE			X											
ELEVATOR HOISTWAY DAMPER SWITCH			X											X
ELEVATOR HOISTWAY DAMPER POWER FAILURE			X											X

1 FIRE ALARM OPERATION MATRIX

NO SCALE

NOTES:

- ALL SYSTEM EVENTS SHALL BE LOGGED, PRINTED, AND DISPLAYED ON THE GRAPHICAL OR ANNUNCIATOR INTERFACE, IF APPLICABLE. SEE SPECIFICATIONS FOR MORE INFORMATION AND DESCRIPTIONS OF SEQUENCES OF OPERATION.
- PARTIAL EVACUATION OR RELOCATION OF OCCUPANTS IS THE STANDARD OPERATING PROCEDURE FOR THIS FACILITY IN THE EVENT OF AN ALARM. THEREFORE, ALL NOTIFICATION APPLIANCE CIRCUITS MUST BE INSTALLED AND PROTECTED IN ACCORDANCE WITH THE CIRCUIT SURVIVABILITY REQUIREMENTS DESCRIBED IN NFPA 72. SEE SPECIFICATIONS FOR ADDITIONAL REQUIREMENTS.

KEYNOTES:

- UTILIZE A GENERAL PURPOSE RELAY TO MONITOR POWER LOSS. CONNECT THE CONTACTS OF THE RELAY TO A FIRE ALARM MONITOR MODULE.
- UTILIZE (3) GENERAL PURPOSE RELAYS AS SHOWN ON DRAWINGS WITH A COIL VOLTAGE THAT MATCHES THE MOTOR VOLTAGE TO MONITOR POWER LOSS. CONNECT EACH RELAY COIL TO ONE PHASE OF THE MOTOR FEEDER DOWNSTREAM OF THE DISCONNECTING MEANS, BUT AHEAD OF THE CONTROL CONTACTOR. CONNECT THE CONTACTS OF THE RELAYS IN SERIES TO A FIRE ALARM MONITOR MODULE.

NOTES:


- THE RISER DIAGRAM IS INTENDED TO CONVEY THE TYPES OF FIRE ALARM CONNECTIONS AND SPECIFICALLY DOES NOT INDICATE QUANTITIES, NUMBER OF CIRCUITS REQUIRED OR DISTANCES.
- THE COMPLETE FIRE ALARM SYSTEM SHALL MEET ALL APPLICABLE CODES AND MANUFACTURER'S RECOMMENDATIONS.
- CONTRACTOR SHALL COORDINATE ALL WIRE SIZES, TYPES AND REQUIREMENTS WITH THE VENDOR PRIOR TO BID. REFER TO SPECIFICATIONS TO DETERMINE CIRCUIT STYLES AND IF CONDUIT IS REQUIRED OR PLENUM RATED CABLE IS ACCEPTABLE.
- ALL +120VAC WIRING REQUIRED FOR OPERATION OF THE SYSTEM AS DESCRIBED IN THE CONSTRUCTION DOCUMENTS SHALL BE PROVIDED BY THE ELECTRICAL CONTRACTOR.
- ALL NECESSARY RELAYS MAY NOT BE SHOWN ON THIS PLAN, BUT WHERE REQUIRED FOR PROPER OPERATION OF THE SYSTEM THEY SHALL BE PROVIDED BY THE CONTRACTOR.
- PARTIAL EVACUATION OR RELOCATION OF OCCUPANTS IS THE STANDARD OPERATING PROCEDURE FOR THIS FACILITY IN THE EVENT OF AN ALARM. THEREFORE, ALL NOTIFICATION APPLIANCE CIRCUITS MUST BE INSTALLED AND PROTECTED IN ACCORDANCE WITH THE CIRCUIT SURVIVABILITY REQUIREMENTS DESCRIBED IN NFPA 72. SEE SPECIFICATIONS FOR ADDITIONAL REQUIREMENTS.

KEYNOTES:

- REPRESENTATIVE OF PROGRAMMABLE I/O POINTS IN THE PANEL OR A GENERAL SYSTEM TROUBLE/ALARM CONTACT CONNECTED TO THE SYSTEM NOTED. REFER TO SPECIFICATIONS FOR MORE INFORMATION.
- REFER TO SPECIFICATION FOR REQUIREMENTS OF EACH INITIATION LOOP AND WIRING STYLE. REFER TO FLOOR PLANS FOR DEVICES AND THEIR LOCATIONS.
- REFER TO SPECIFICATION FOR REQUIREMENTS OF EACH NOTIFICATION APPLIANCE CIRCUIT AND WIRING STYLE. REFER TO FLOOR PLANS FOR DEVICES AND THEIR LOCATIONS.
- PROVIDE NOTIFICATION APPLIANCE EXTENDER PANELS AS REQUIRED. DETERMINATION OF NEED TO BE MADE BY FIRE ALARM VENDOR. REFER TO SPECIFICATIONS FOR REQUIREMENTS AND ACCEPTABLE MOUNTING LOCATIONS.
- FIREMAN'S PHONE SYSTEM SHALL BE A SINGLE CHANNEL IN ACCORDANCE WITH NFPA CODE REQUIREMENTS. VENDOR TO DETERMINE NUMBER OF CIRCUITS REQUIRED.
- THE RELEASE PANEL WILL PROVIDE CONTACT CLOSURES TO BE MONITORED BY THE FIRE ALARM PANEL. THE ALARM AND AGENT RELEASE SIGNALS SHALL ACTIVATE A GENERAL ALARM. THE PRE-SIGNAL SHALL ACTIVATE A WARNING ON THE GUI ONLY.
- REPRESENTS THE EXTENSION OF PROGRAMMABLE RELAYS TO THE ACCESS CONTROL SYSTEM. REFER TO SPECIFICATION SECTION 28 13 00 FOR QUANTITY OF POINTS REQUIRED.
- THIS CONTRACTOR SHALL PROVIDE AN RS-232 CONNECTION FROM THE FIRE ALARM PANEL TO THE ALPHANUMERIC PAGING SYSTEM. THE FIRE ALARM VENDOR SHALL SUPPLY THE COMMUNICATION PROTOCOL TO THE OWNER. REFER TO SPECIFICATIONS FOR MORE INFORMATION.

2 FIRE ALARM RISER

NO SCALE

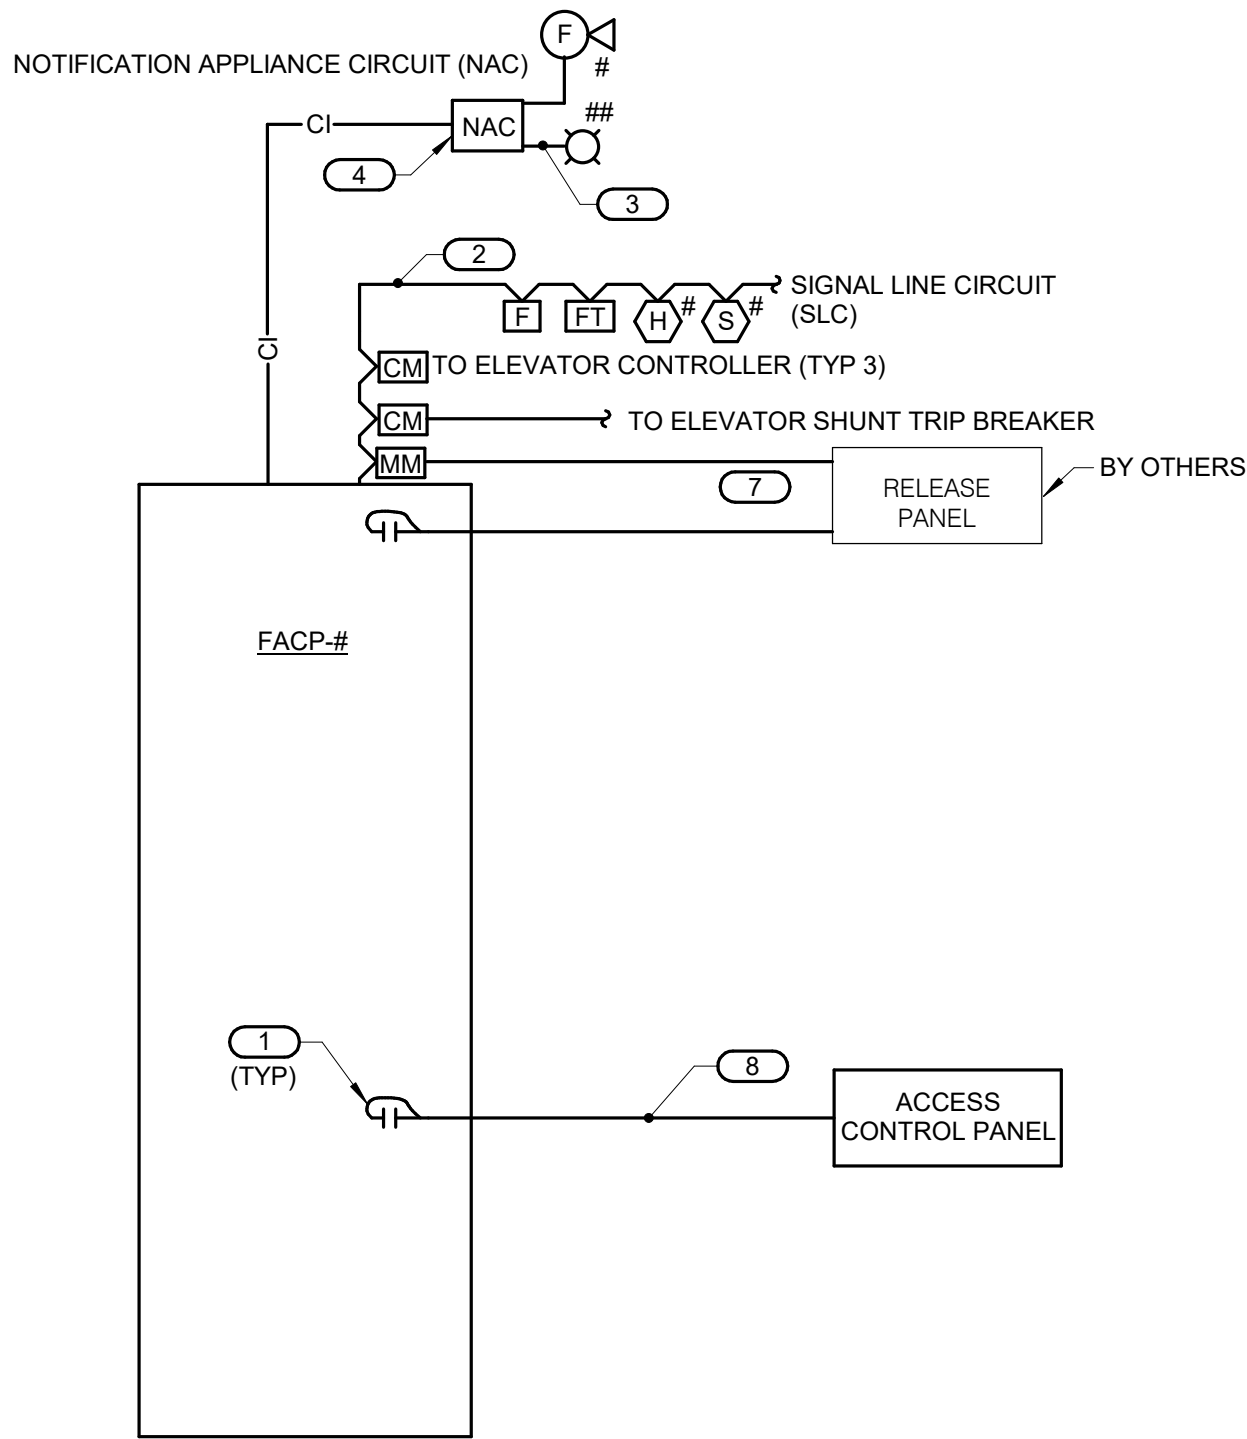

FIRE ALARM INSTALLATION NOTES:

- MOUNT ALL FIRE ALARM PULL STATIONS AT +42" FROM FLOOR (CENTERLINE DIMENSION) EXCEPT WHERE OTHERWISE NOTED.
- INSTALL ALL WALL MOUNTED FIRE ALARM NOTIFICATION DEVICES AT 90" ABOVE FINISHED FLOOR OR 6" BELOW THE CEILING, WHICHEVER IS LOWER, EXCEPT WHERE OTHERWISE NOTED. HEIGHT SHALL BE MEASURED TO THE TOP OF THE DEVICE.
- CONTRACTOR SHALL COORDINATE THE LOCATION OF ALL CEILING MOUNTED DEVICES AND EQUIPMENT WITH LUMINAIRES, SPRINKLER, AND CEILING DIFFUSERS. CENTER ALL DEVICES IN CEILING TILE PATTERN. SMOKE DETECTORS, CARBON MONOXIDE DETECTORS, AND OCCUPANCY/VACANCY SENSORS SHALL BE LOCATED NO CLOSER THAN 3 FEET TO AN AIR SUPPLY DIFFUSER OR RETURN GRILLE. CARBON MONOXIDE DETECTORS SHALL BE LOCATED 10 PLUS FT FROM FIRE PLACES, COOKING, AND SIMILAR FUEL-BURNING APPLIANCES.
- REFER TO ARCHITECTURAL REFLECTED CEILING PLAN, ELECTRICAL, TECHNOLOGY AUDIO/VISUAL, AND OTHER ELECTRICAL PLANS FOR EXACT LOCATIONS OF ALL CEILING MOUNTED DEVICES, OTHER THAN SPRINKLERS.

ELECTRICAL SYMBOL LIST - FIRE ALARM				
SYMBOL	TAG	EQUIP ABBREV	SPEC SECTION	DESCRIPTION
	<varies>	FA-120	28 31 00	SMOKE DETECTOR - LOCATED IN ATTIC
	E	FA-140	28 31 00	HEAT DETECTOR
	E	FA-140	28 31 00	HEAT DETECTOR - LOCATED IN ATTIC
	F	FA-130	28 31 00	MANUAL PULL STATION
	##	FA-200	28 31 00	VISUAL ALARM DEVICE - ## INDICATES CANDELA RATING
	##	FA-211	28 31 00	COMBINATION AUDIO (HORN/CHIME) / VISUAL ALARM DEVICE - ## INDICATES CANDELA RATING
	FACP	FACP		CONTROL PANEL
	NAC	NAC		NOTIFICATION APPLIANCE CIRCUIT
	FAAP	FAAP		ANNUNCIATOR PANEL

FIRE ALARM SEQUENCES KEY:

SUBSCRIPTS: TYPE/PROGRAMMING:
E ELEVATOR RECALL
SW STAIRWELL
15, 30, 75, 110, 177 CANDELA RATING
CD CANDELA RATING SELECTED BY NICET DESIGNER

www.imegcorp.com

IMEG RESERVES PROPRIETARY RIGHTS, INCLUDING COPYRIGHTS, TO THIS DRAWING AND THE DATA SHOWN THEREON. SAID DRAWING AND/OR DATA ARE THE EXCLUSIVE PROPERTY OF IMEG AND SHALL NOT BE USED OR REPRODUCED FOR ANY OTHER PROJECT WITHOUT THE EXPRESS WRITTEN APPROVAL AND PARTICIPATION OF IMEG.

©2026 IMEG CONSULTANTS CORP.



North Carolina Design Registration #E-1507

0 1 2 3
REF. SCALE IN INCHES PROJECT #26001727.00

RENOVATION FOR:

CRAVEN COUNTY GOVERNMENT CENTER
EAST

CRAVEN COUNTY
1208 E. MAIN STREET, HAVELOCK, NORTH CAROLINA 28532

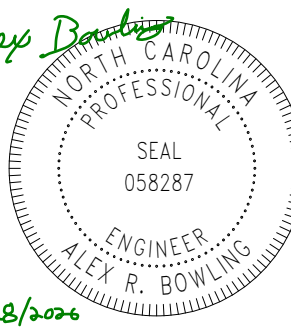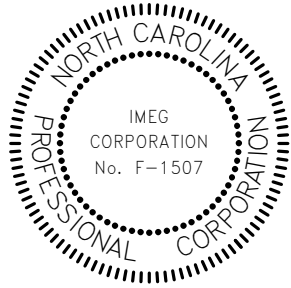

GENERAL NOTE:
Prior to construction start, Contractor shall verify & be responsible for all dimensions.

Revisions	#	Description	Date
Date	05-28-26	Project No.	26001727.00
Drawn By	Author	Sheet No.	FA000
Checked By	Checker	Sheet Title	FIRE ALARM COVERSHEET


OAKLEY COLLIER ARCHITECTS

OCA

109 Candlewood Road, Rocky Mount, NC 27804 (P) 252.937.2500
205 W. Martin Street, Raleigh, NC 27601

Copyright © 2025 Oakley Collier Architects. These drawings are of the property of the Architect for use under his supervision. No reproduction or other use is allowed without permission.

1 FIRST FLOOR DEMOLITION PLAN - FIRE ALARM
1/8" = 1'-0"

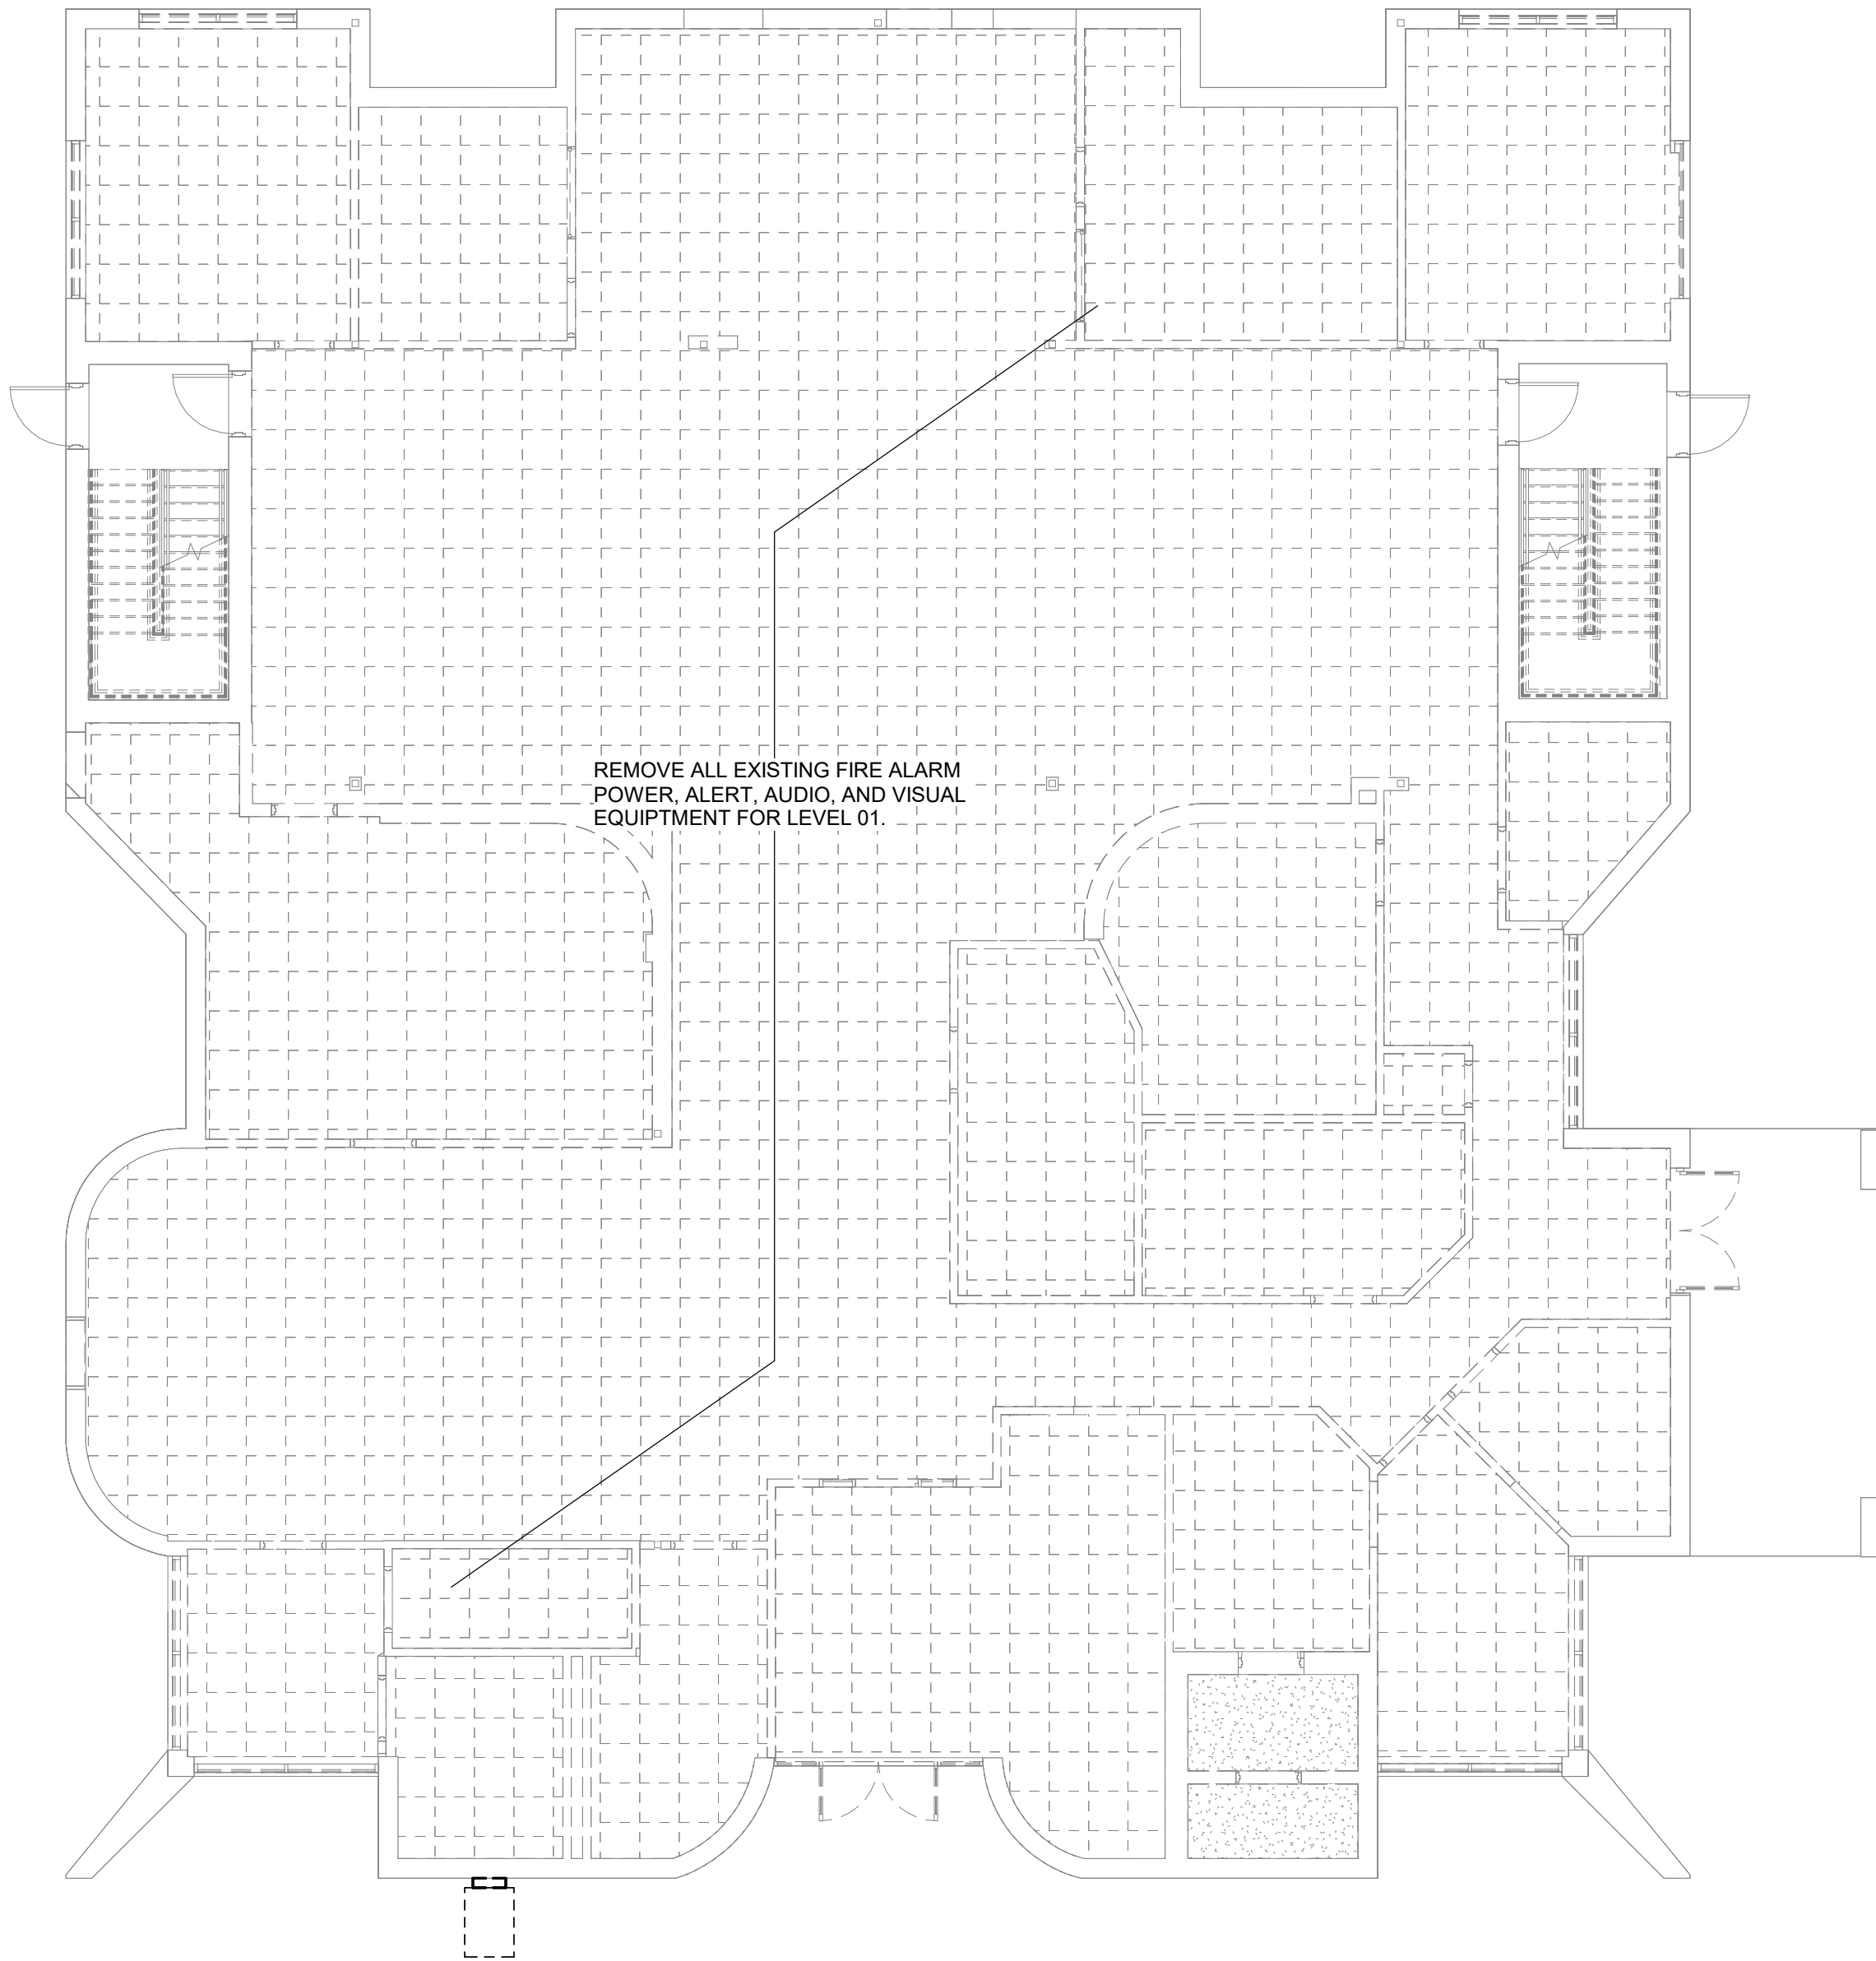

2 FIRST FLOOR PLAN - FIRE ALARM
1/8" = 1'-0"



IMEG
www.imegcorp.com
3221 BLUE RIDGE ROAD
SUITE 113
RALEIGH, NC 27612
P: 919.971.1111



IMEG RESERVES PROPRIETARY RIGHTS, INCLUDING COPYRIGHTS, TO THIS DRAWING AND THE DATA SHOWN THEREON. SAID DRAWING AND/OR DATA ARE THE EXCLUSIVE PROPERTY OF IMEG AND SHALL NOT BE USED OR REPRODUCED FOR ANY OTHER PROJECT WITHOUT THE EXPRESS WRITTEN APPROVAL AND PARTICIPATION OF IMEG.
©2026 IMEG CONSULTANTS CORP.
North Carolina Design Registration #F-1507

0 1 2 3
REF. SCALE IN INCHES PROJECT #26001727.00

RENOVATION FOR:

CRAVEN COUNTY GOVERNMENT CENTER
EAST

CRAVEN COUNTY
1208 E. MAIN STREET, HAVELOCK, NORTH CAROLINA 28532

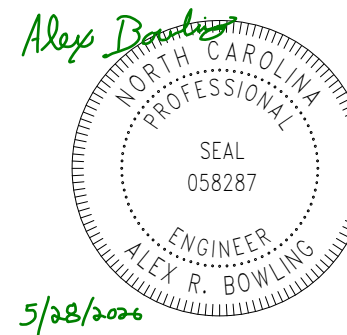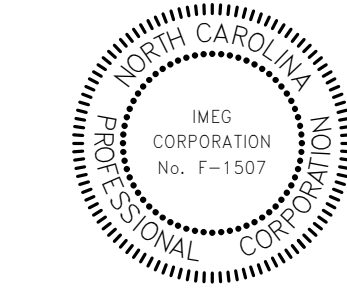


GENERAL NOTE:
Prior to construction start, Contractor shall verify & be responsible for all Dimensions.

Revisions		
	Description	Date
Date	Project No.	
05-28-26	26001727.0	
Drawn By	Sheet No.	
Author	FA204	
Checked By	Checker	
Sheet Title		
FIRST FLOOR PLAN - FIRE ALARM		

OCA
OAKLEY COLLIER ARCHITECTS
109 Candlewood Road, Rocky Mount, NC 27804 (P) 252.937.2500
205 W. Martin Street, Raleigh, NC 27601

CRAVEN COUNTY
1208 E. MAIN STREET, HAVELock, NORTH CAROLINA 28532

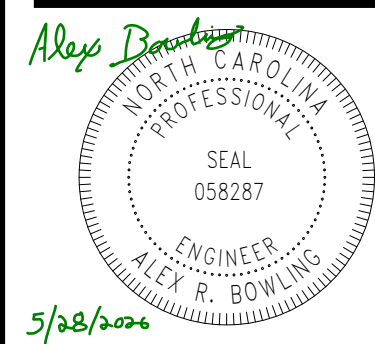

Revisions		
#	Description	Date

Date 05-28-26	Project No. 26001727.00
Drawn By Author	Sheet No. FA205
Checked By Checker	
Sheet Title SECOND FLOOR PLAN - FIRE ALARM	

